


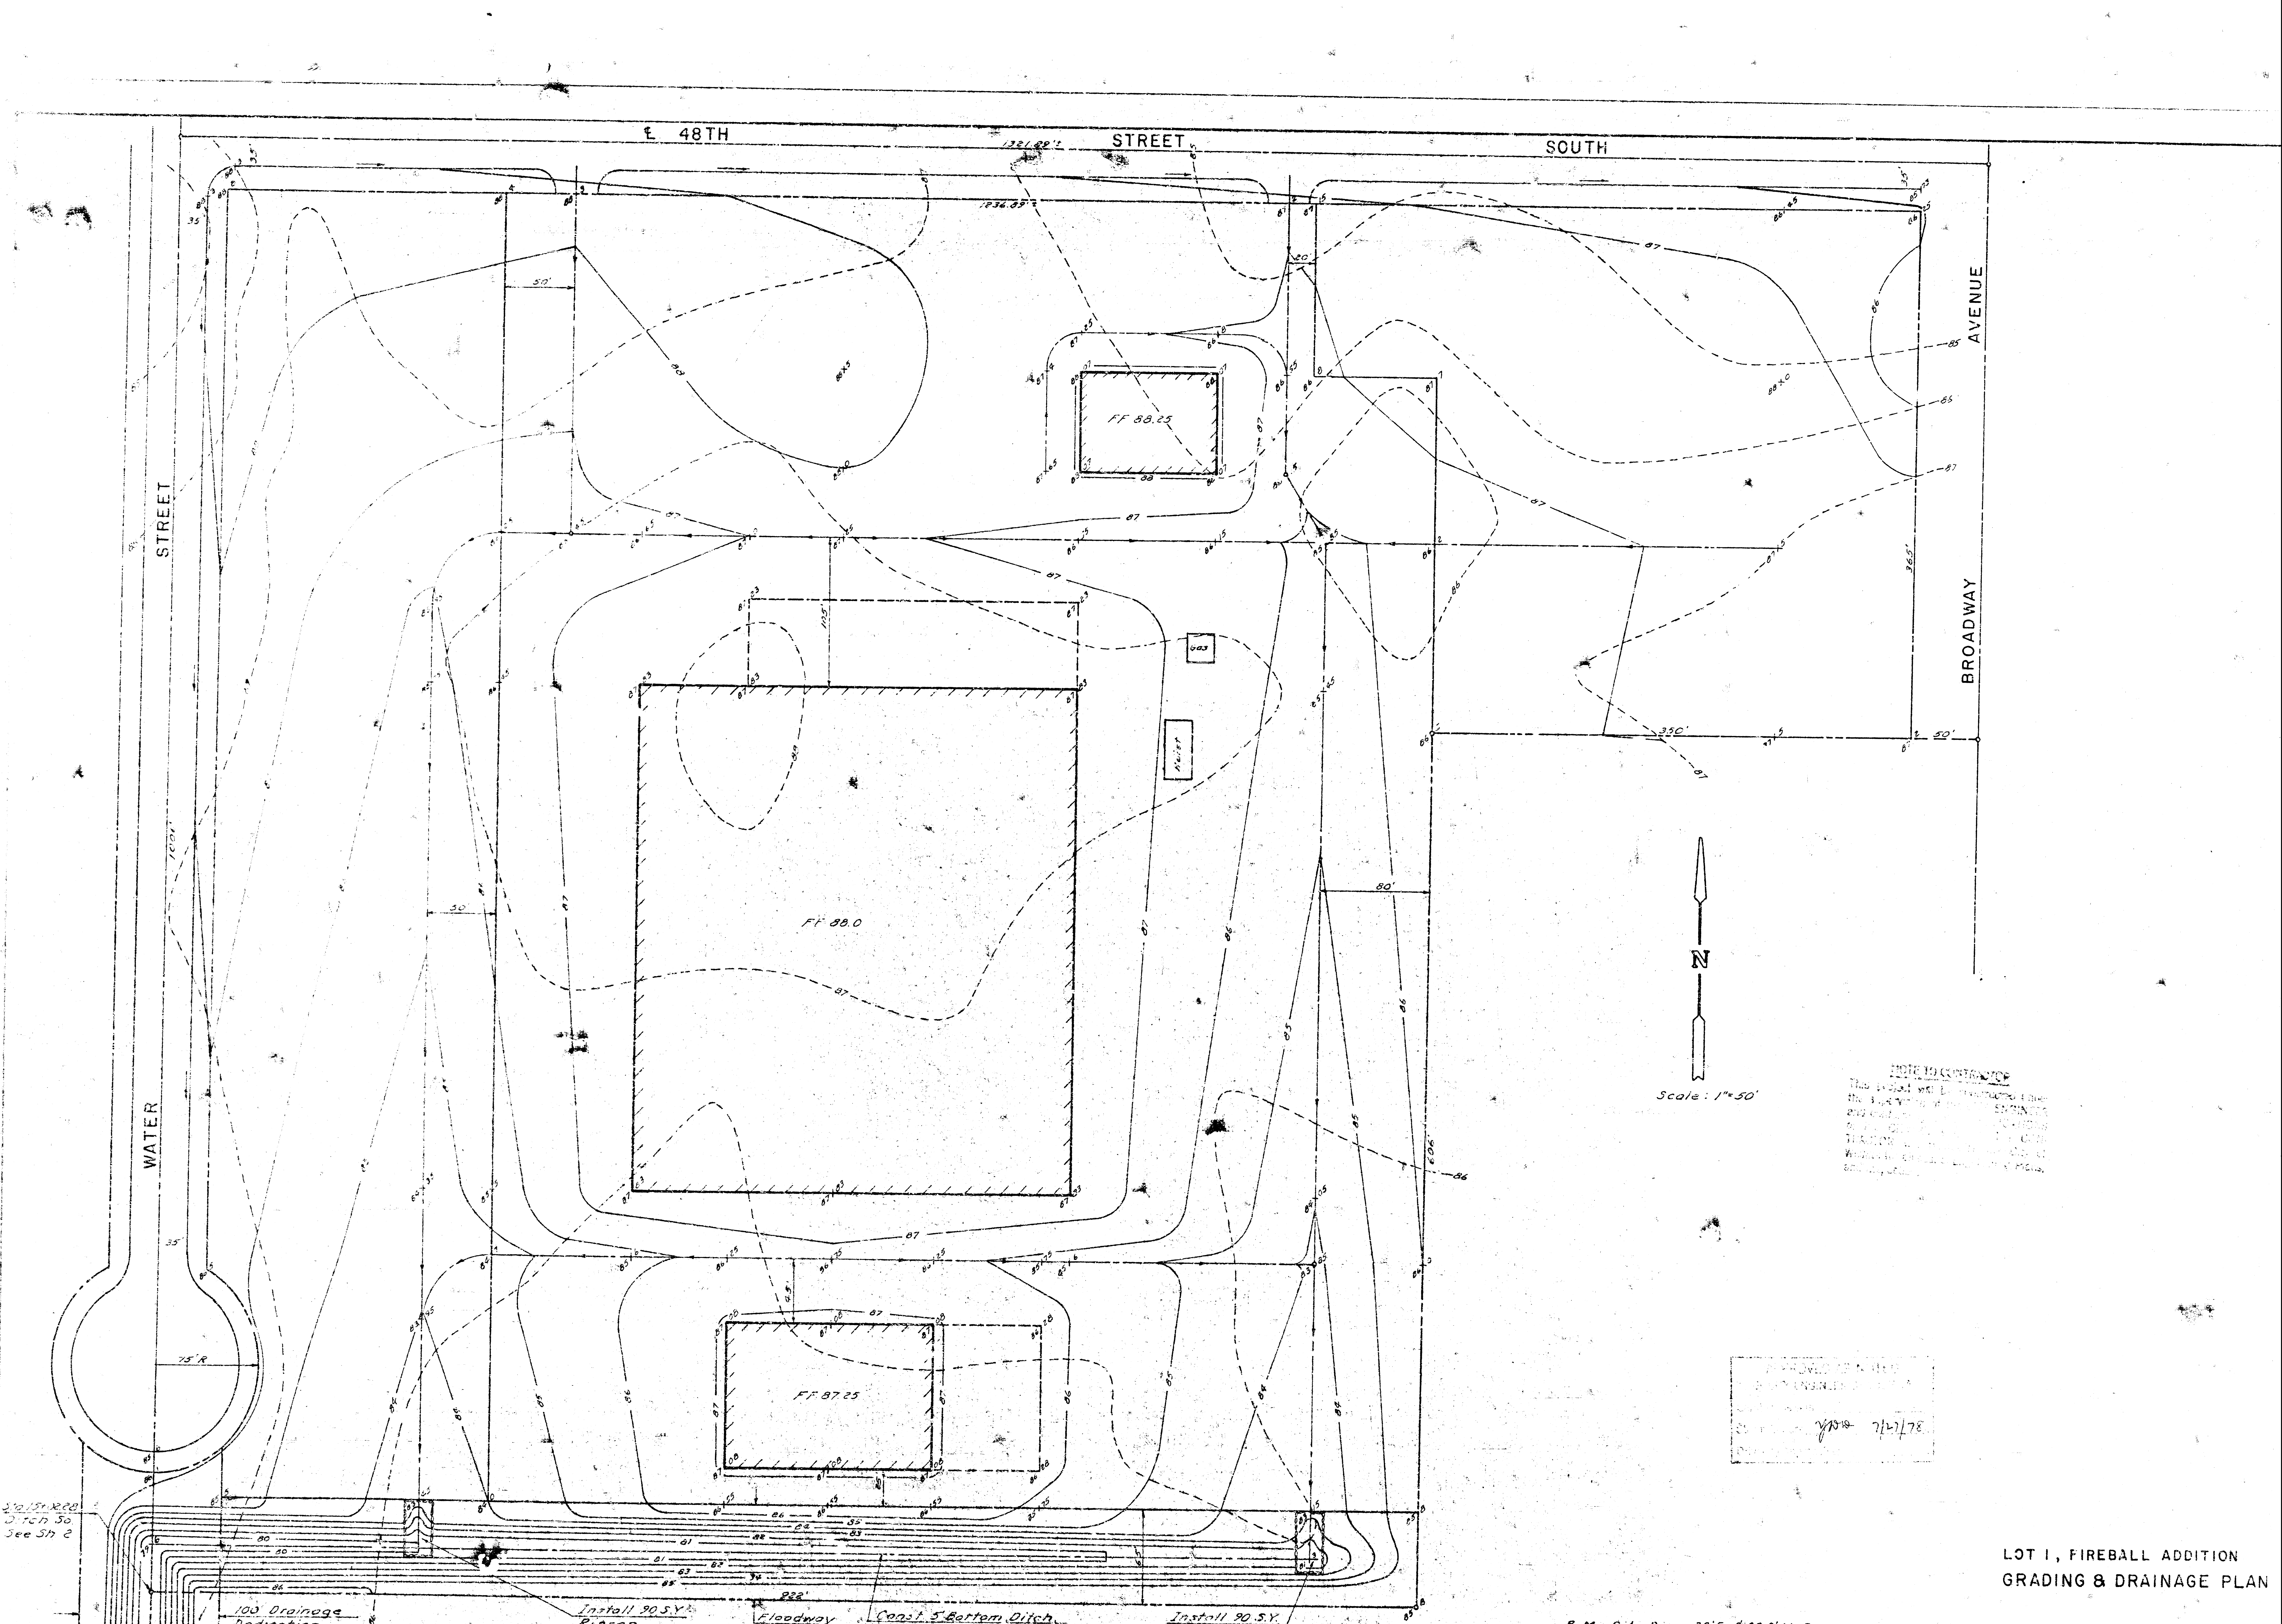

E 48TH

STREET

SOUTH

AVENUE

BROADWAY

STREET

WATER

FF 88.25

FF 88.0

FF 87.25

N

Scale: 1"=50'

NOTE TO CONTRACTOR
This plan was prepared for the
information of the ENGINEER
and is not to be used for
construction without the
approval of the ENGINEER.
The ENGINEER is not responsible
for any errors or omissions
in this plan.

APPROVED FOR THE
ENGINEER
DATE 7/17/78
BY [Signature]

LOT 1, FIREBALL ADDITION
GRADING & DRAINAGE PLAN

See S17 2





100' Drainage

Install 90' S.Y.

Floodway


Const. 5' Bottom Ditch

Install 90' S.Y.

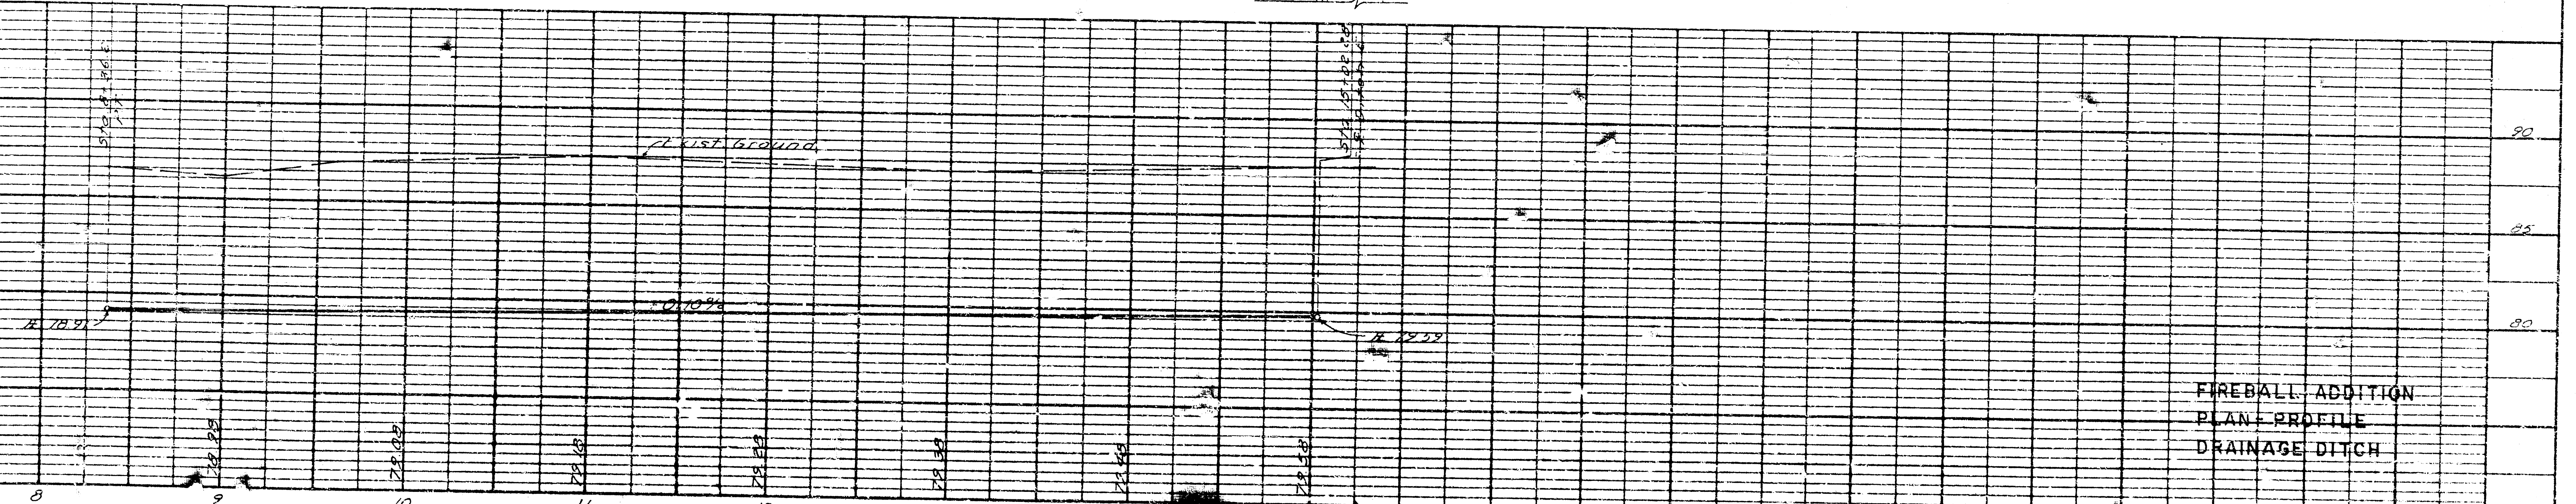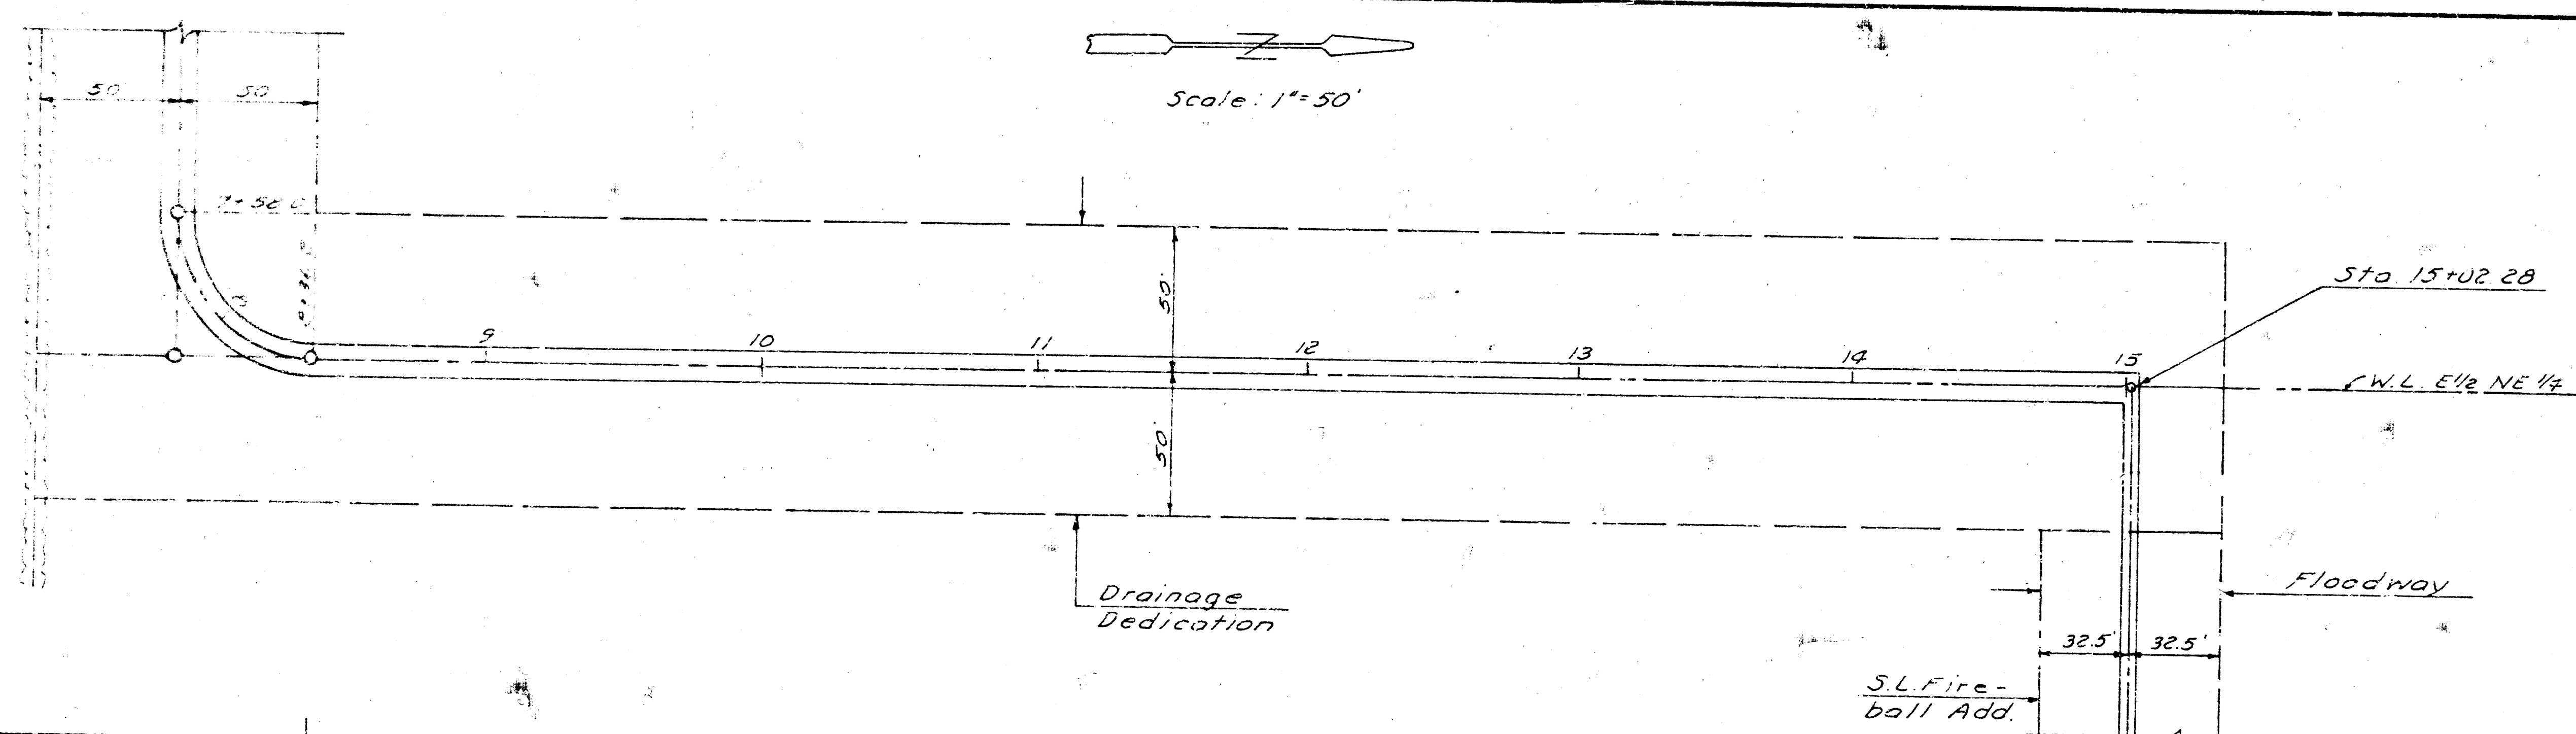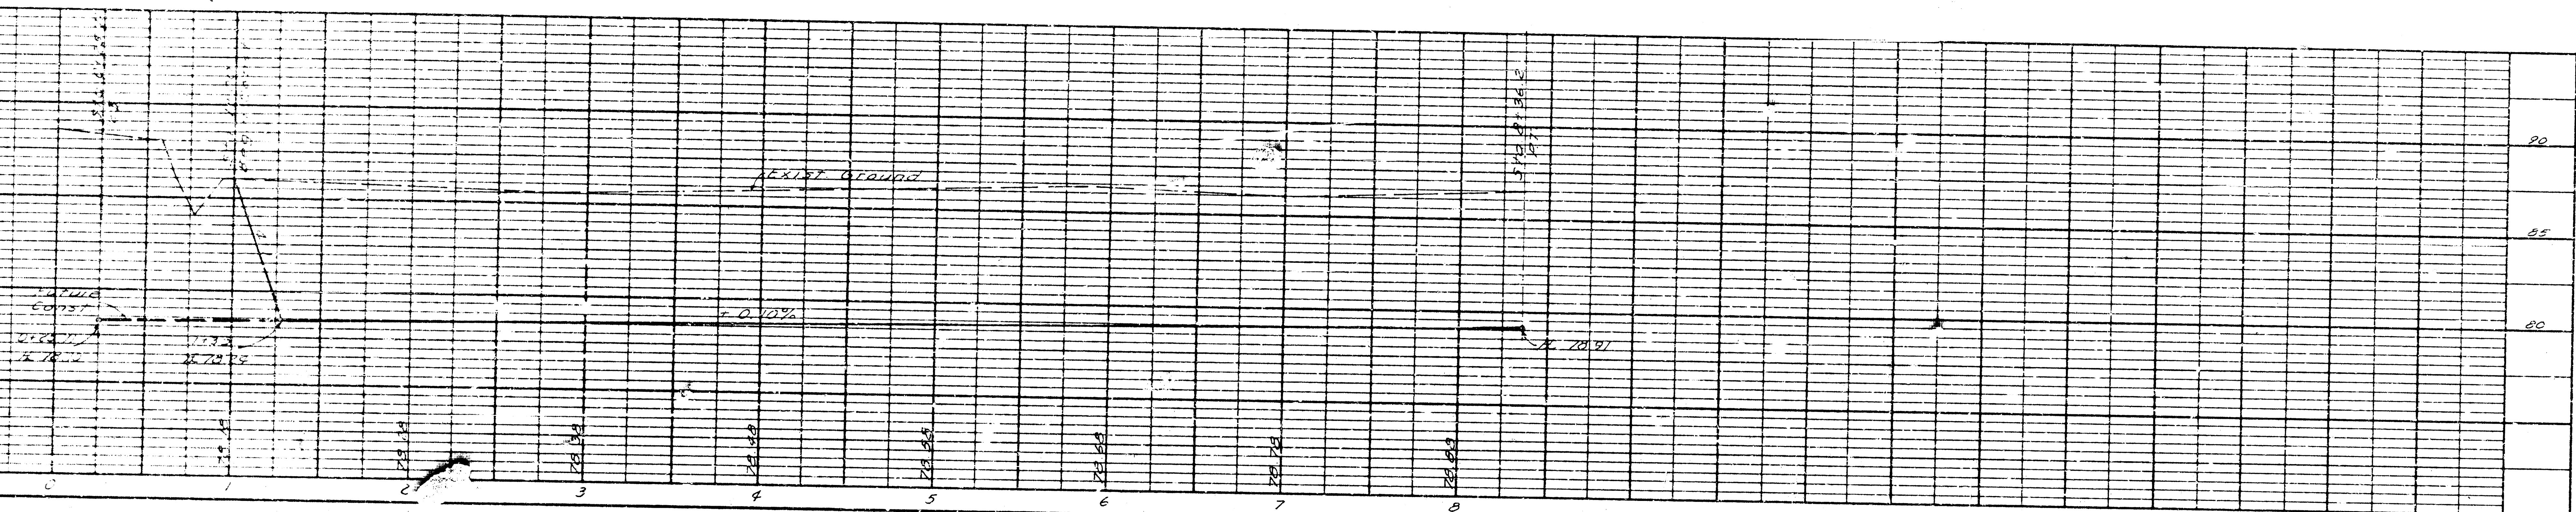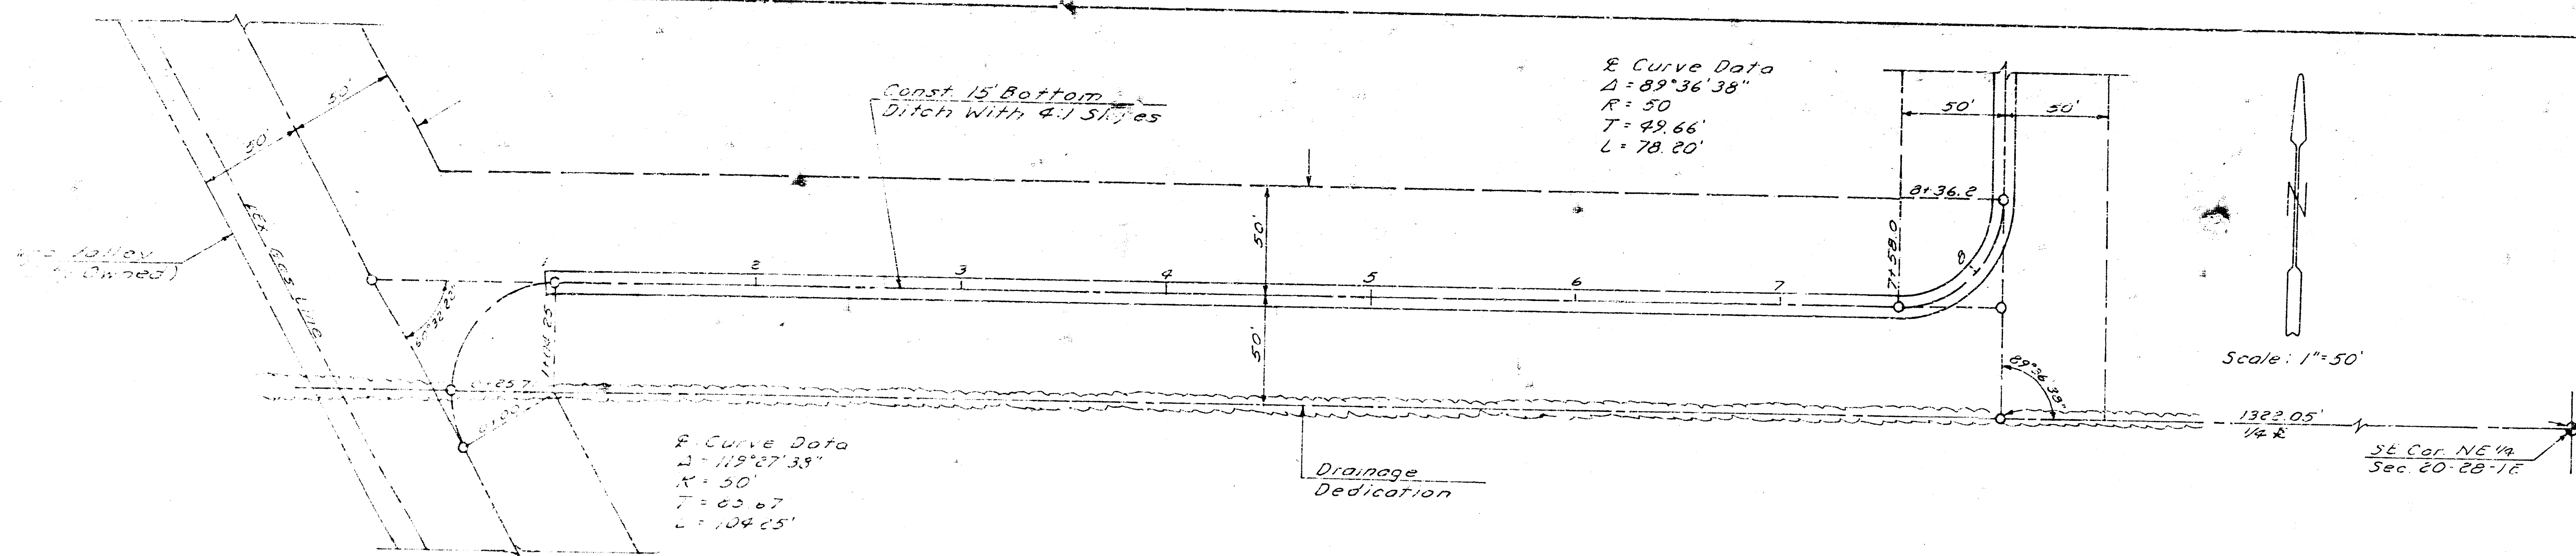

FIREBALL ADDITION
PLAN-PROFILE
DRAINAGE DITCH

FIREBALL GRADING SECTION

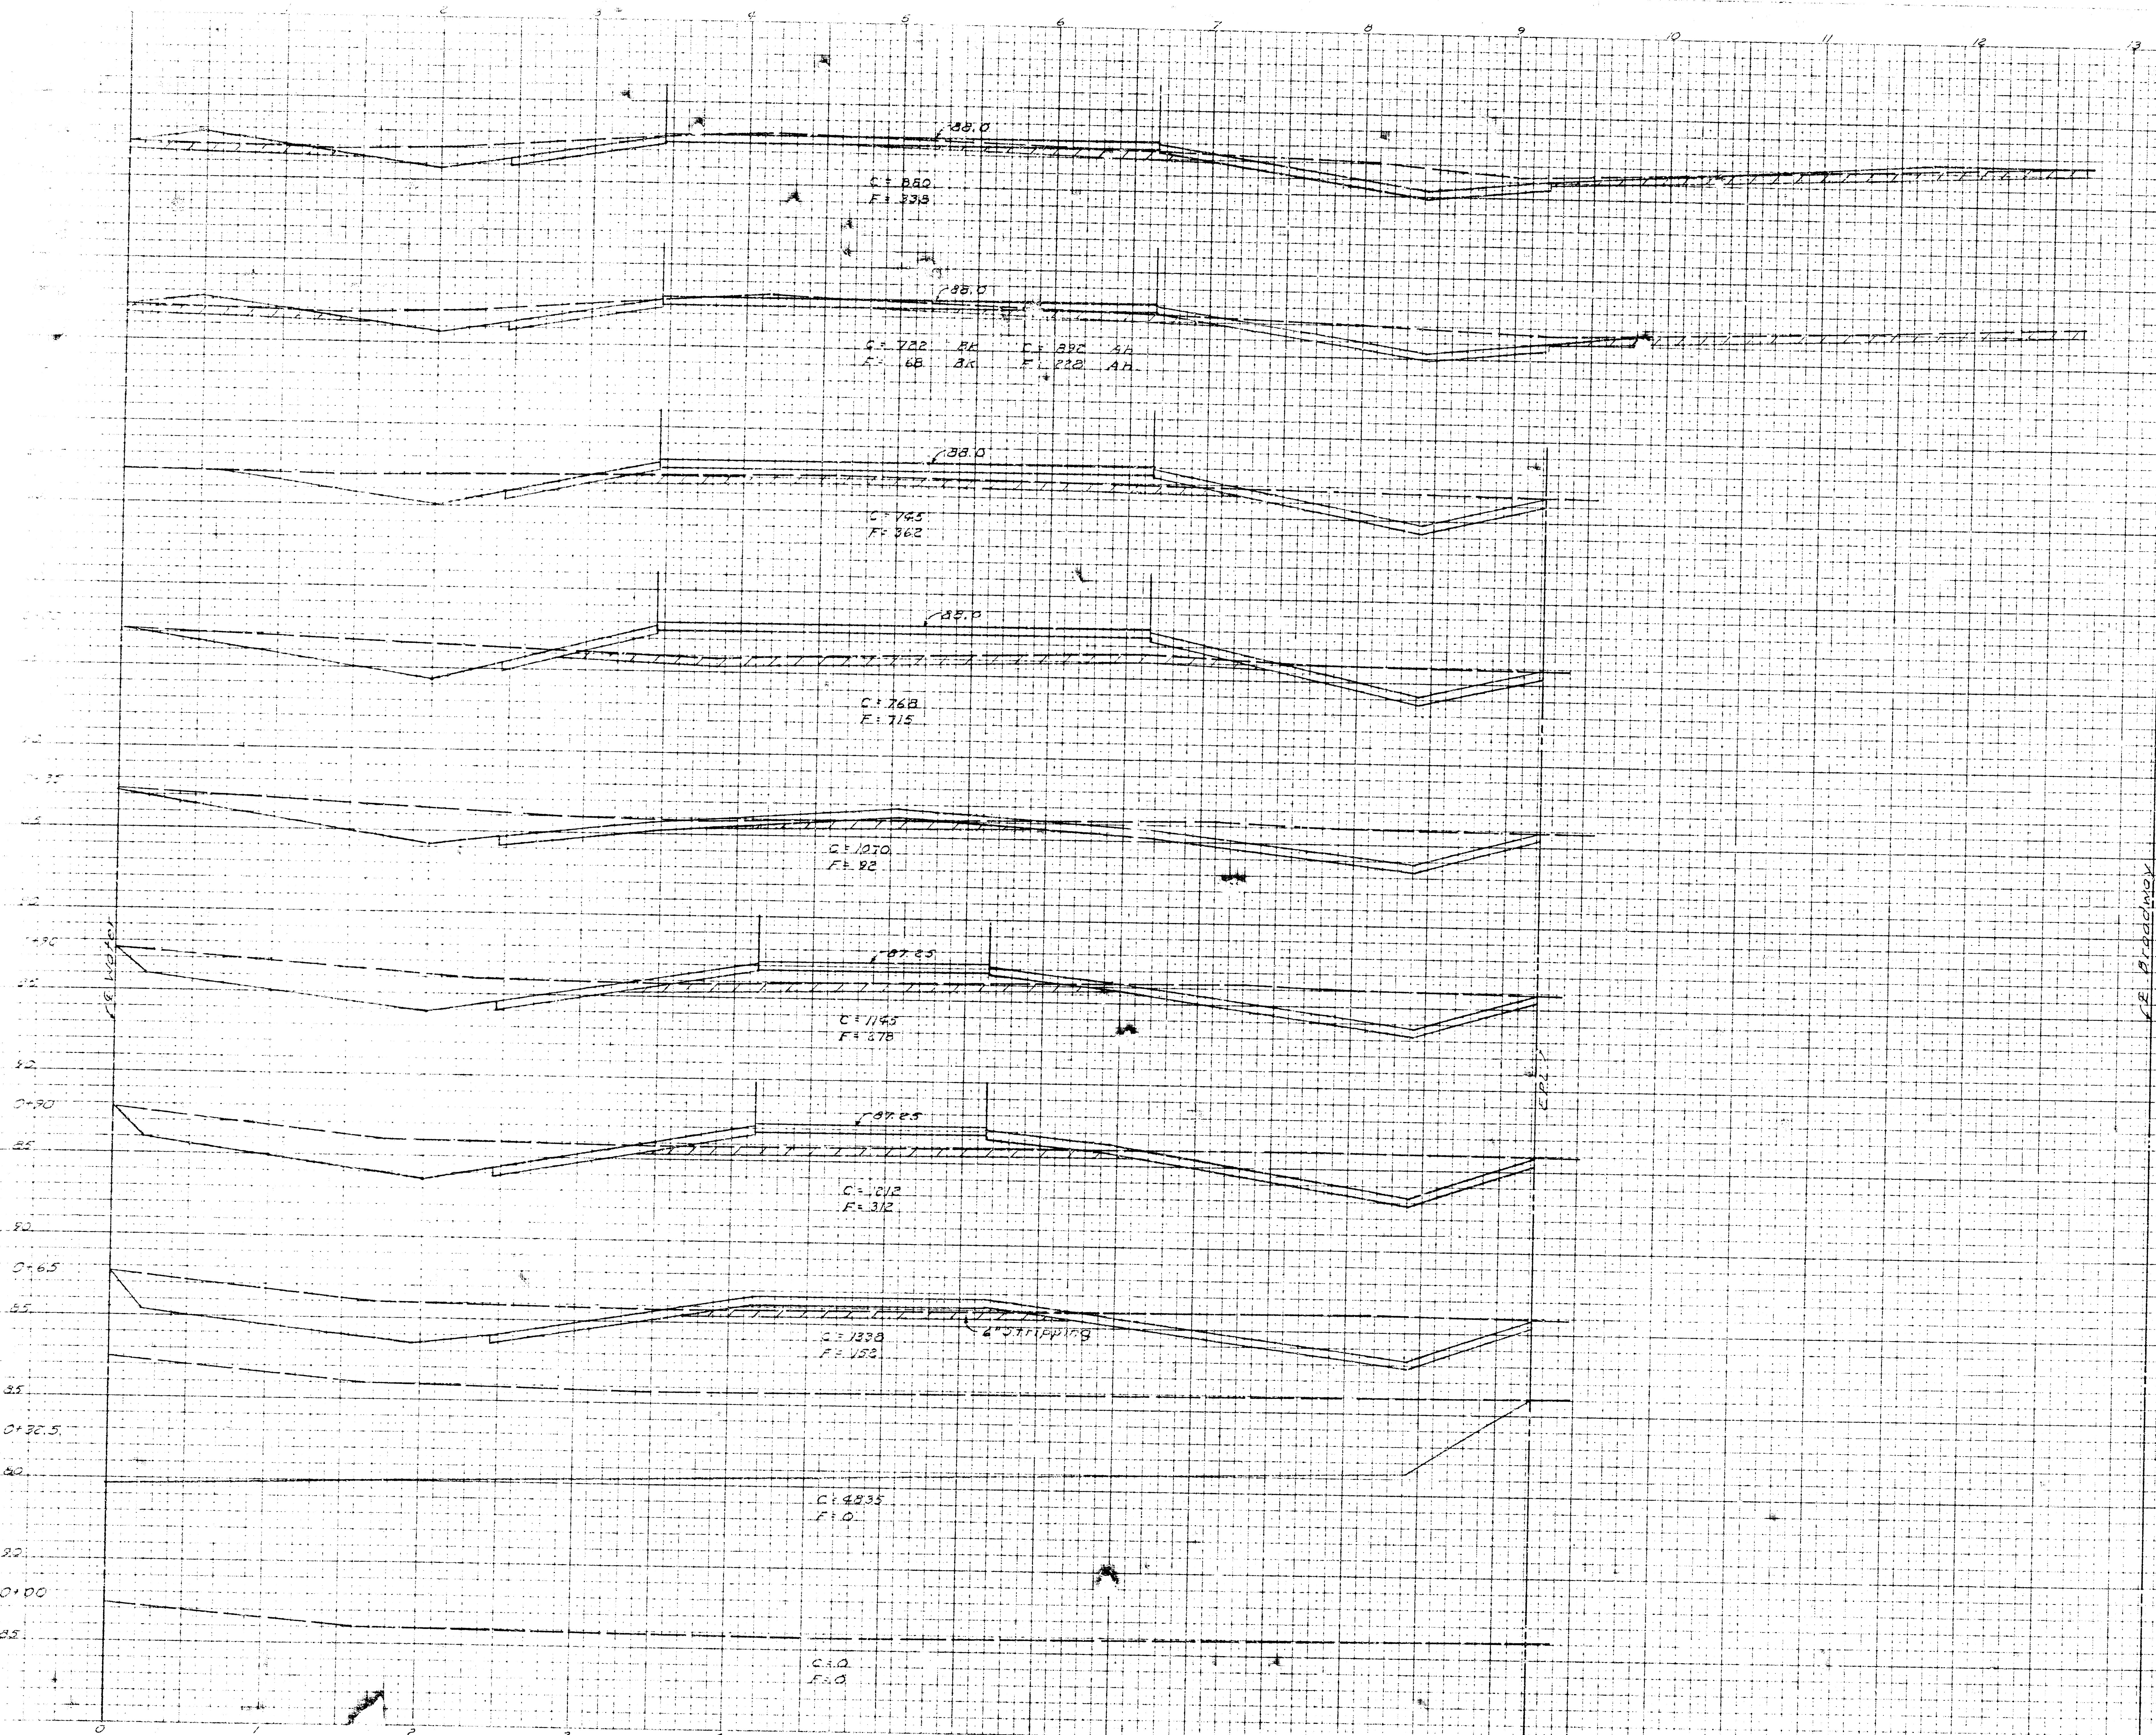

FIREBALL GRADING SECTION

