


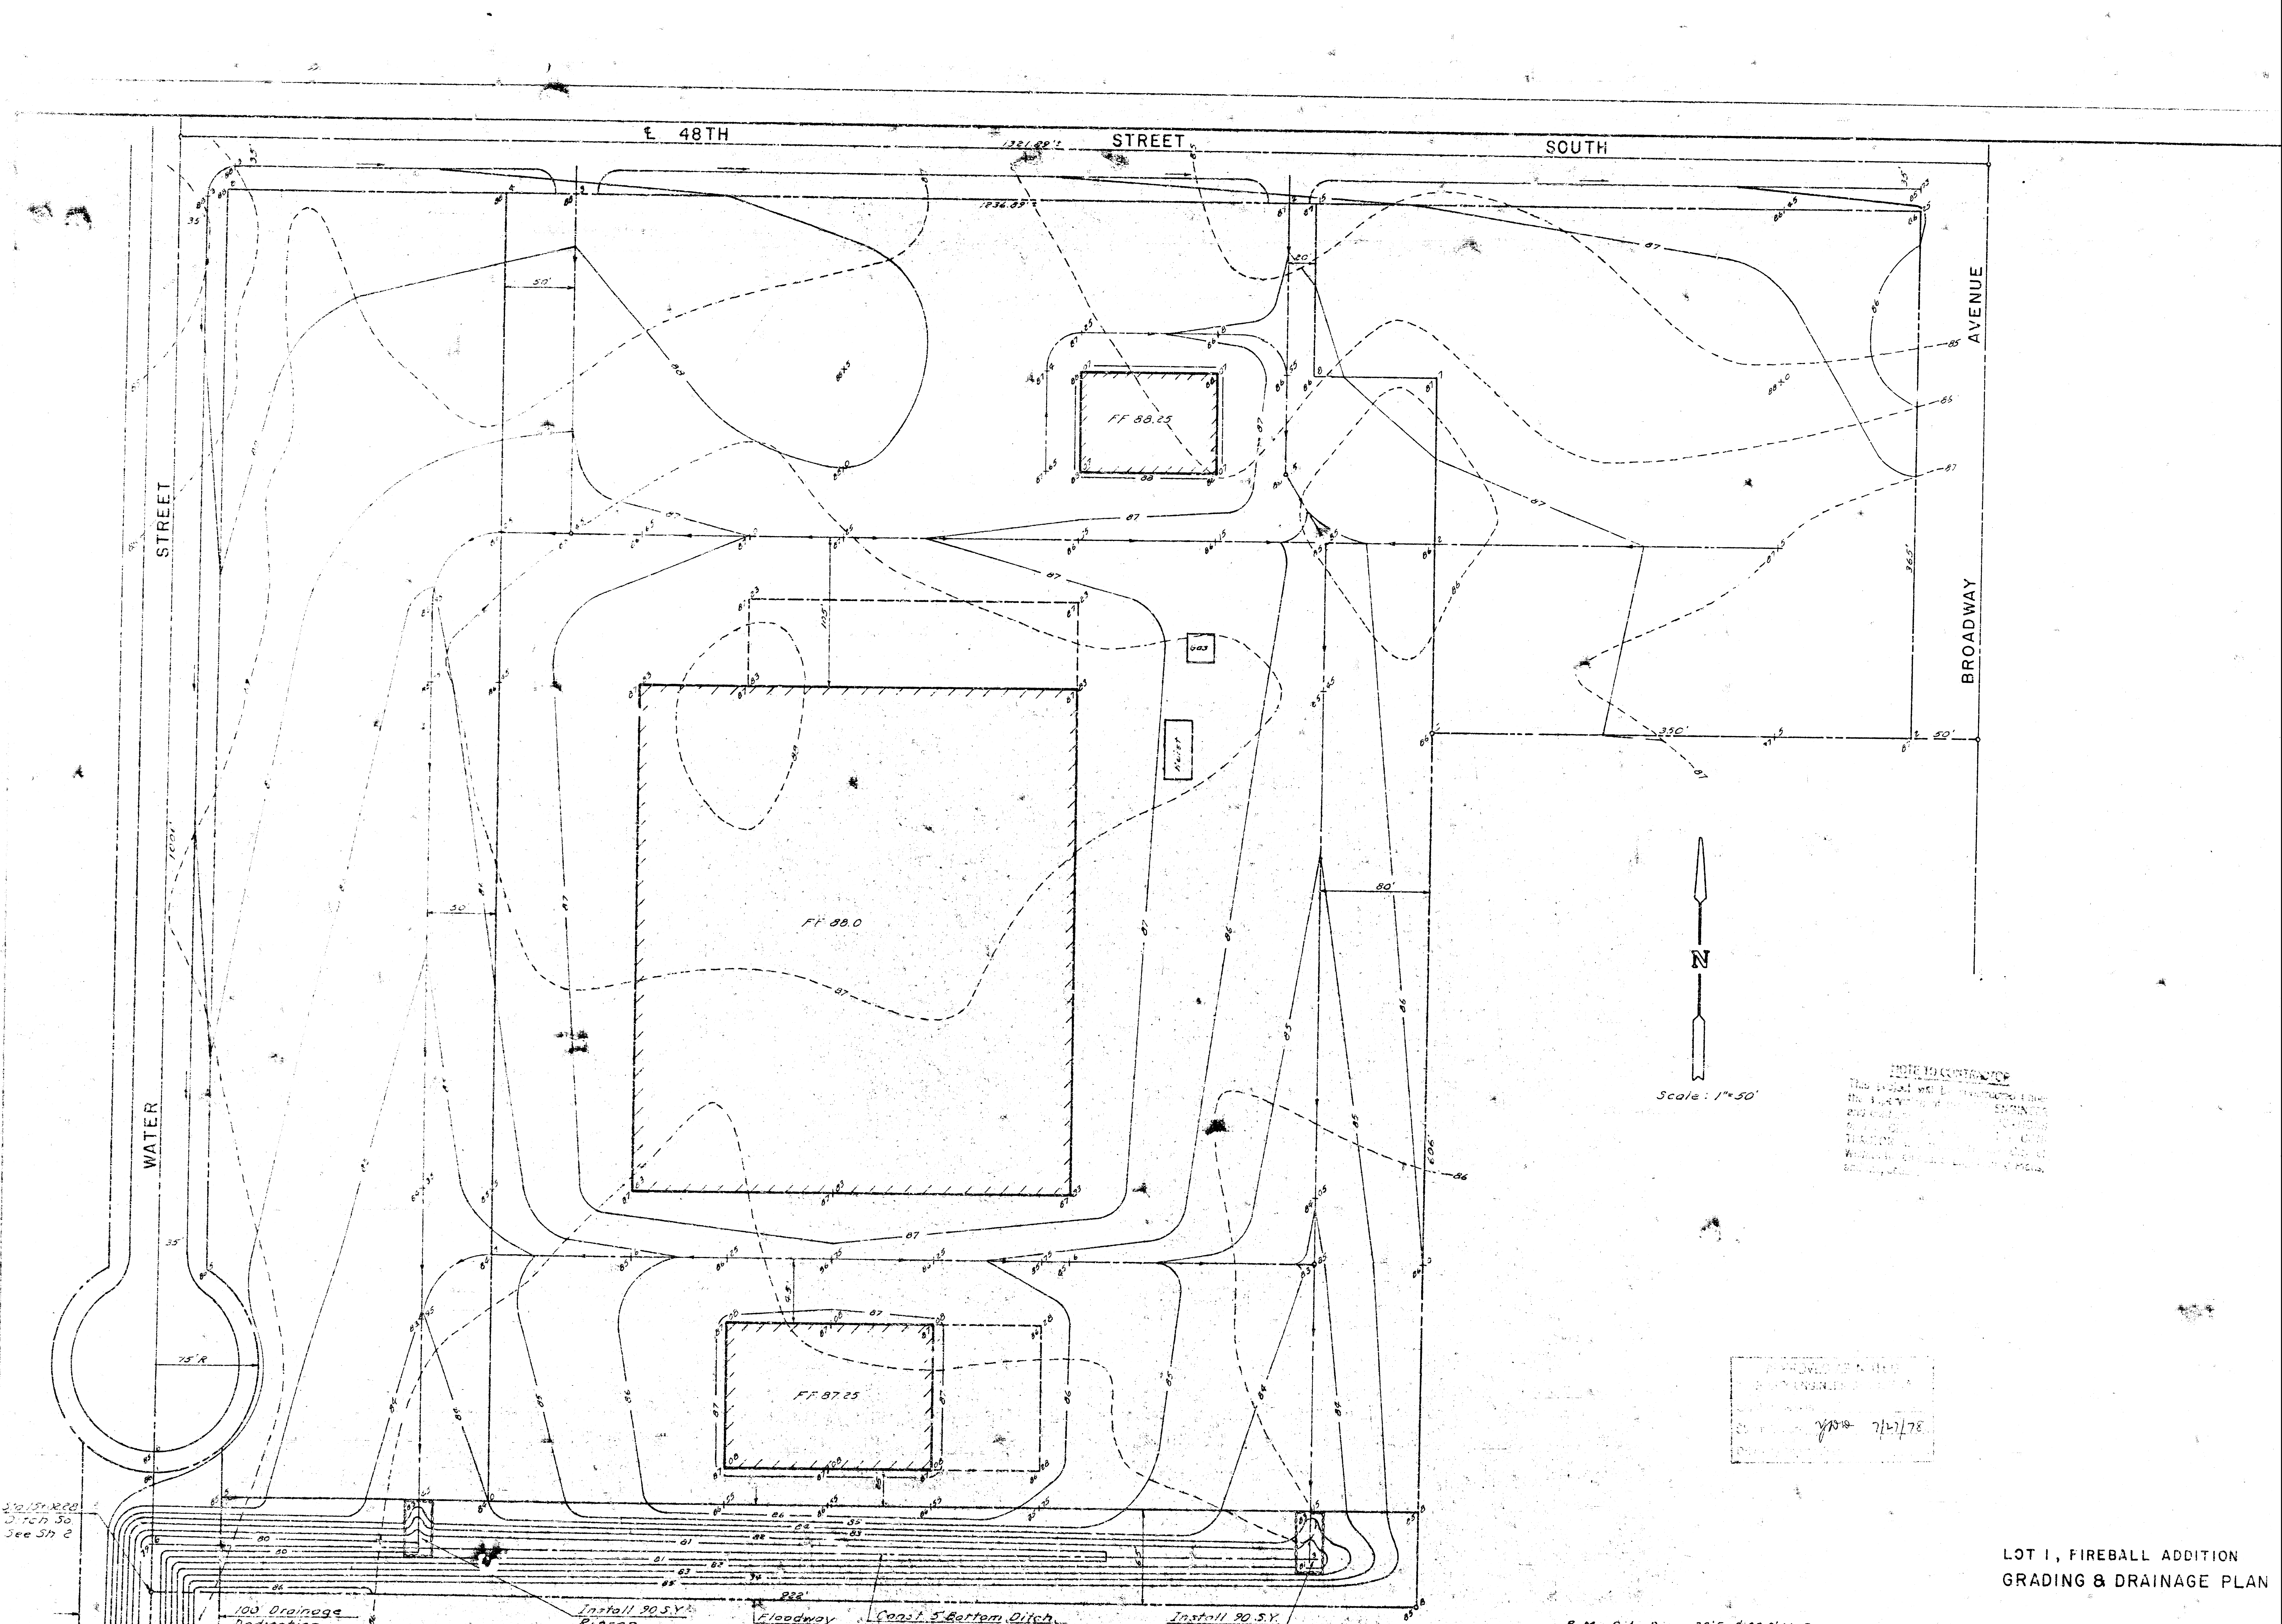

E 48TH

STREET

SOUTH

AVENUE

BROADWAY

STREET

WATER



Scale: 1"=50'


NOTE TO CONTRACTOR  
This project was prepared by the  
City of St. Paul, Minnesota, and  
is intended for use by the  
contractor. The City of St. Paul  
does not warrant the accuracy  
of the information contained  
herein.

RECEIVED  
CITY OF ST. PAUL  
7/17/78

LOT 1, FIREBALL ADDITION  
GRADING & DRAINAGE PLAN



FIREBALL GRADING SECTION

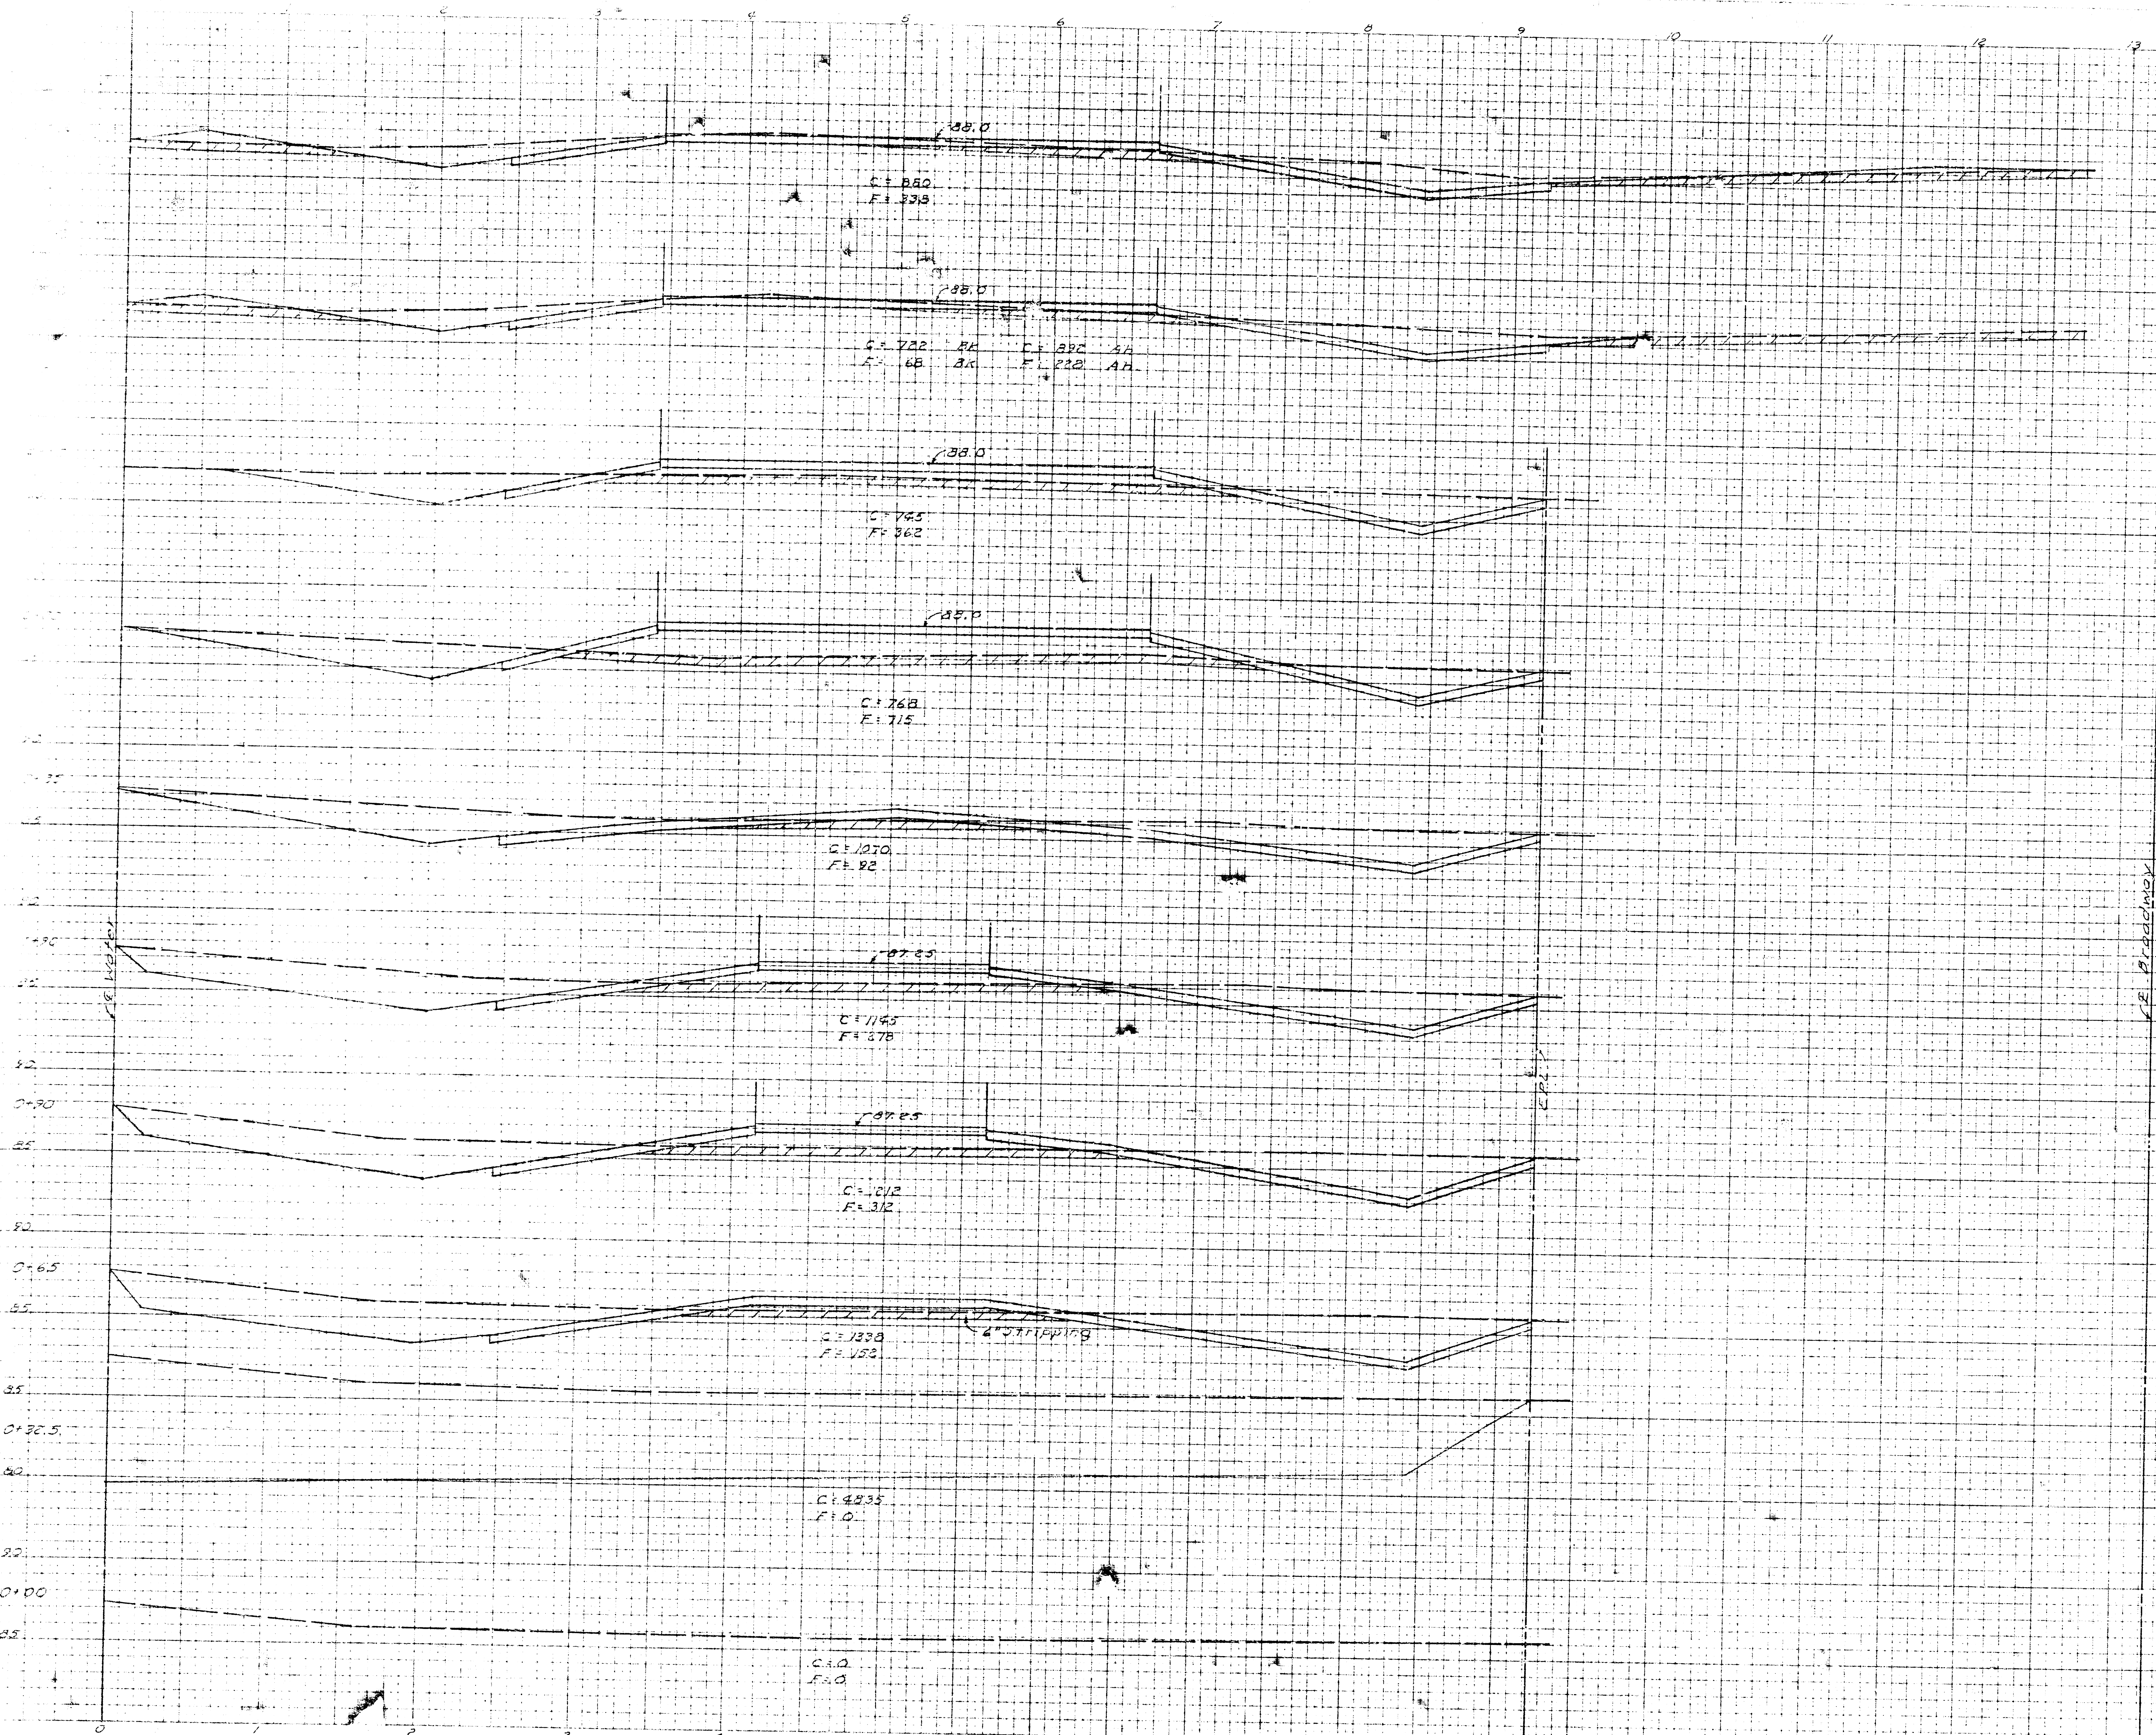

FIREBALL GRADING SECTION

