


THE URBAN RENEWAL AGENCY
OF THE
WICHITA, KANSAS METROPOLITAN AREA
WICHITA, KANSAS 67202

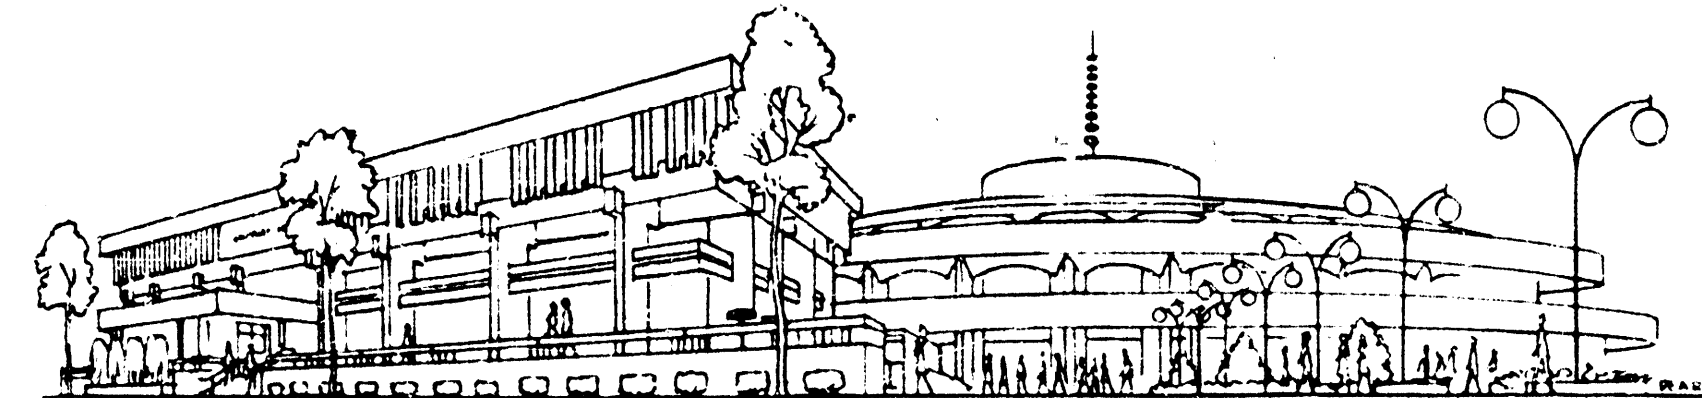


UTILITY RELOCATIONS


PARK PLAZA "A" PROJECT KANS. R-17


INDEX TO DRAWINGS


SHEET NO.	DESCRIPTION
1	TITLE, LOCATION MAP AND INDEX
2	LOCATION MAP - NORTH AREA
3	LOCATION MAP - SOUTH AREA
4	WATER MAINS - LAYOUT PLAN
5	WATER MAINS - LAYOUT PLAN
6	WATER MAINS - LAYOUT PLAN
7	WATER MAINS - DETAILS
8	WATER MAINS - DETAILS
9	SEWER - PLAN AND PROFILE
10	SEWER - PLAN AND PROFILE
11	SEWER - PLAN AND PROFILE
12	SEWER APPURTENANCES
13	SEWER DETAILS
14	SEWAGE PUMPING STATION

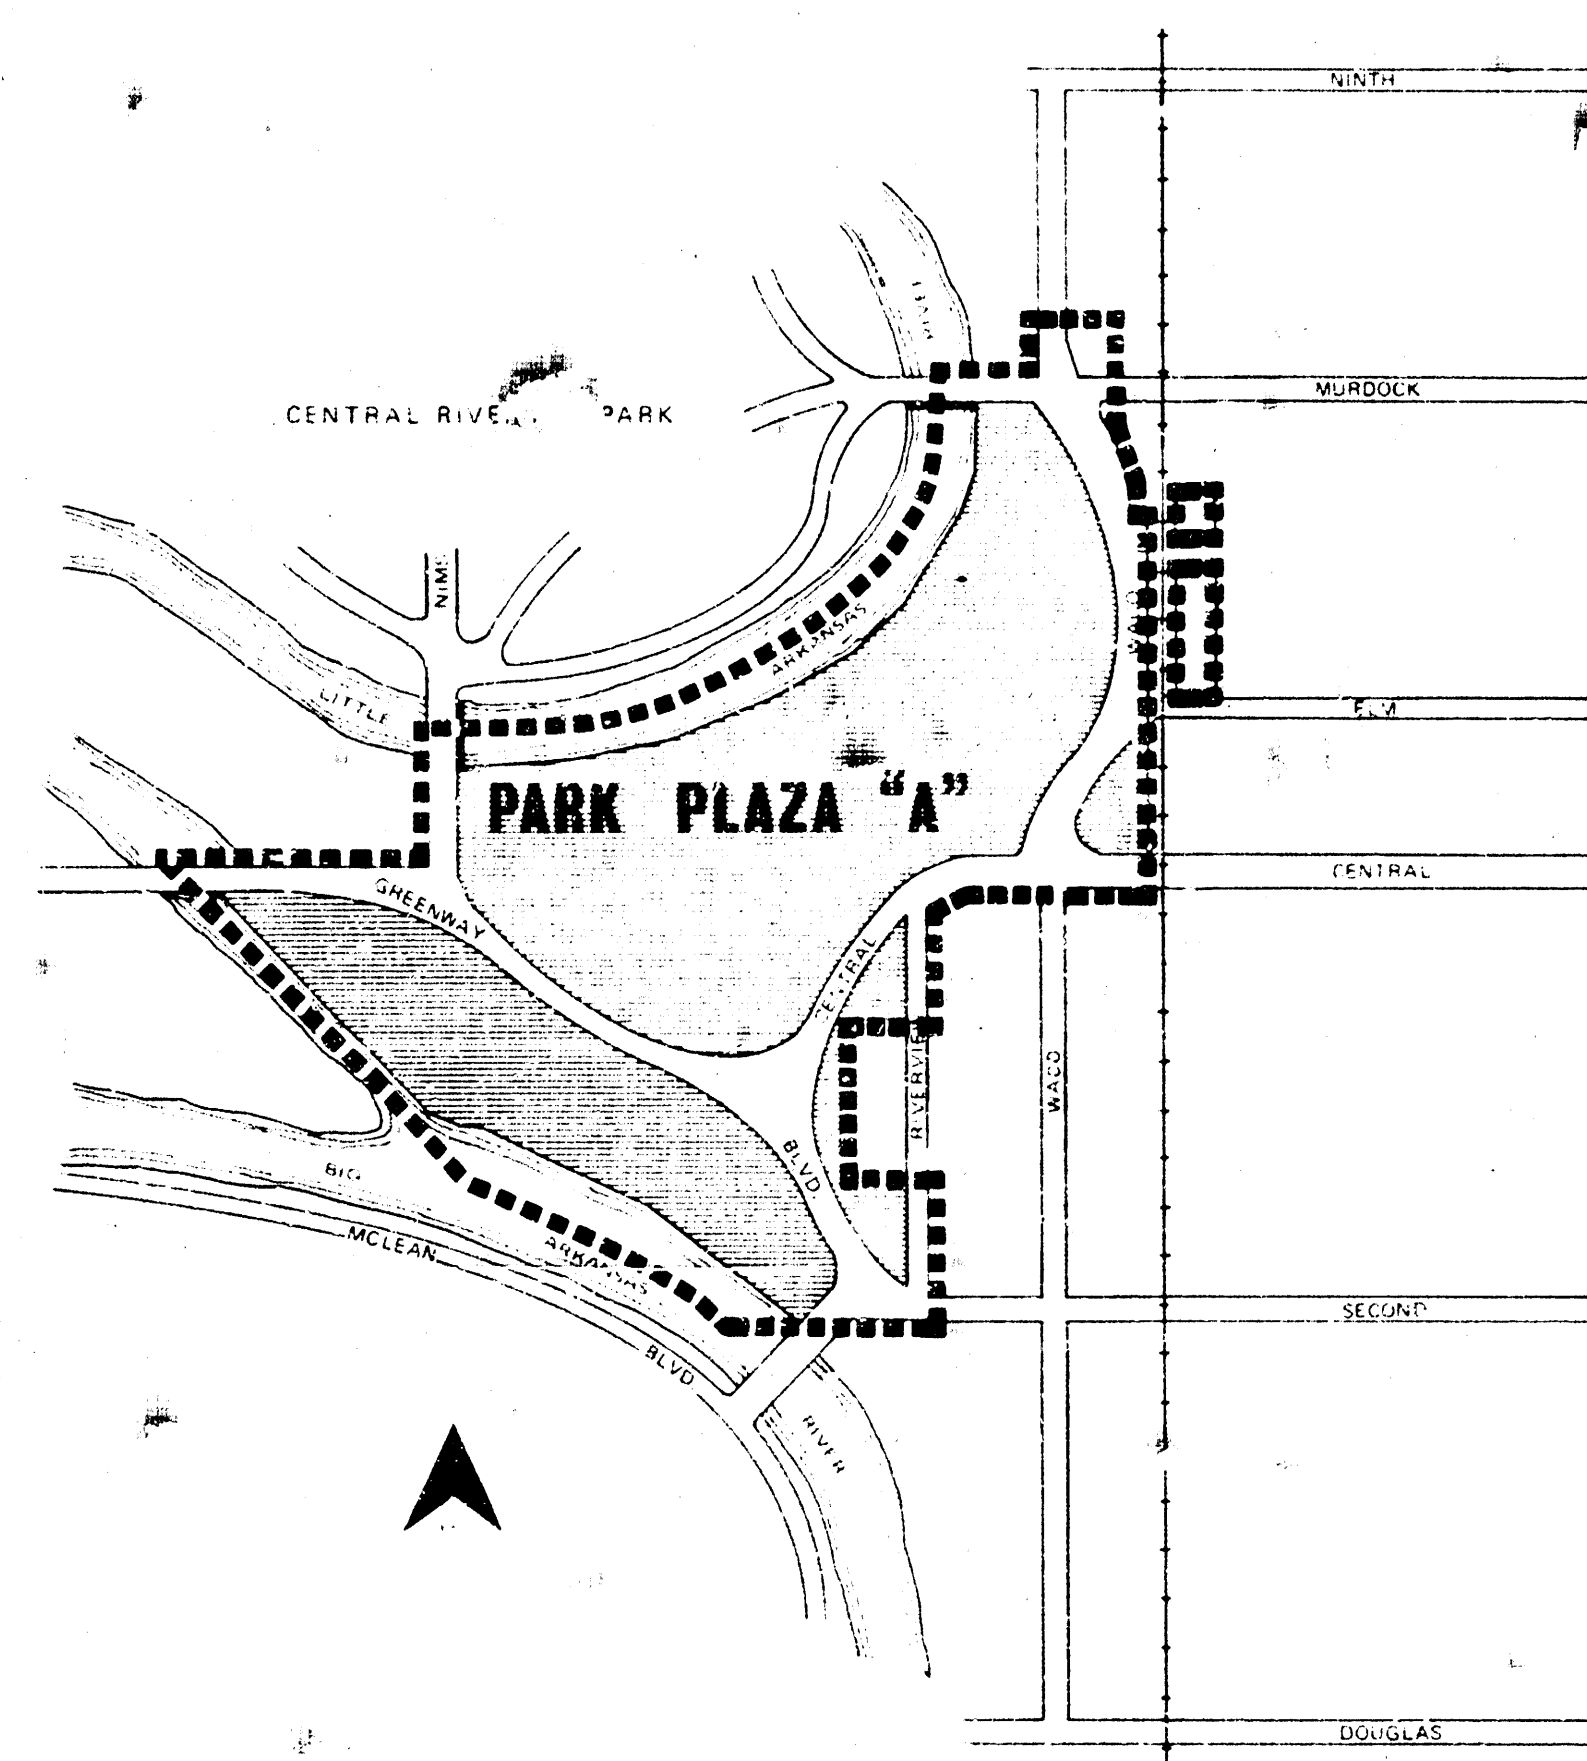



WILSON
& COMPANY
ENGINEERS &
ARCHITECTS
WICHITA — KANSAS

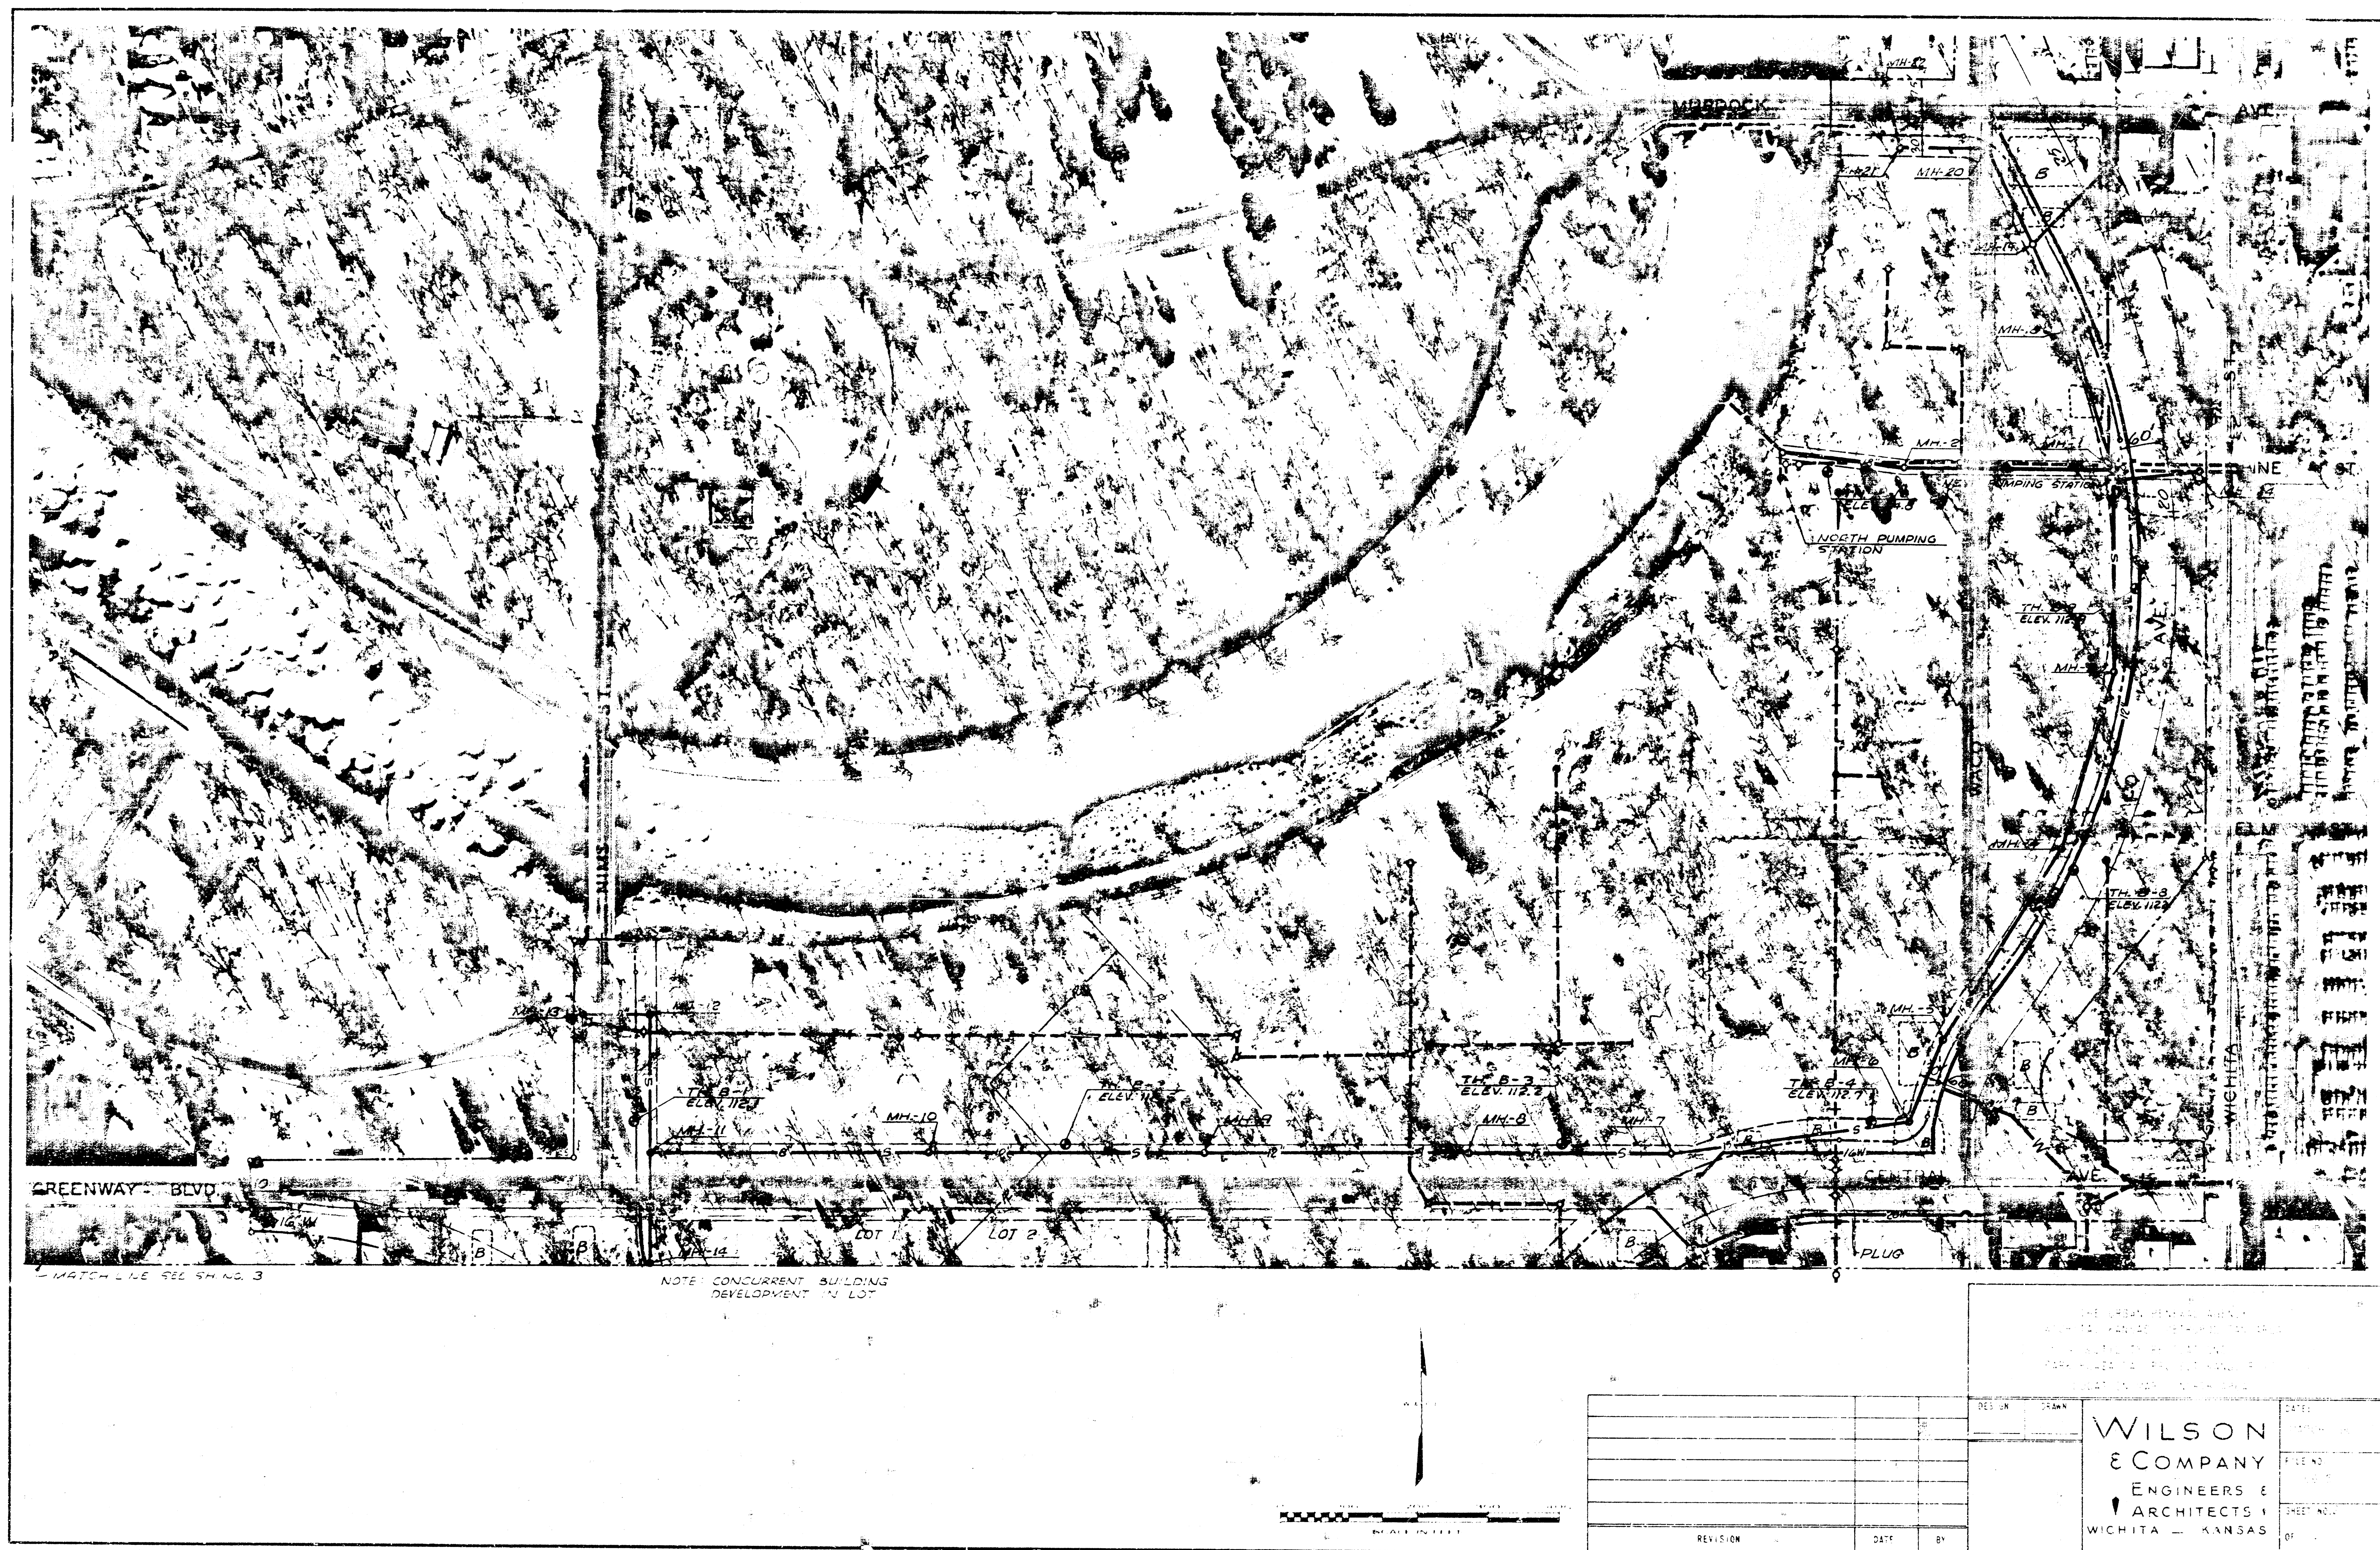

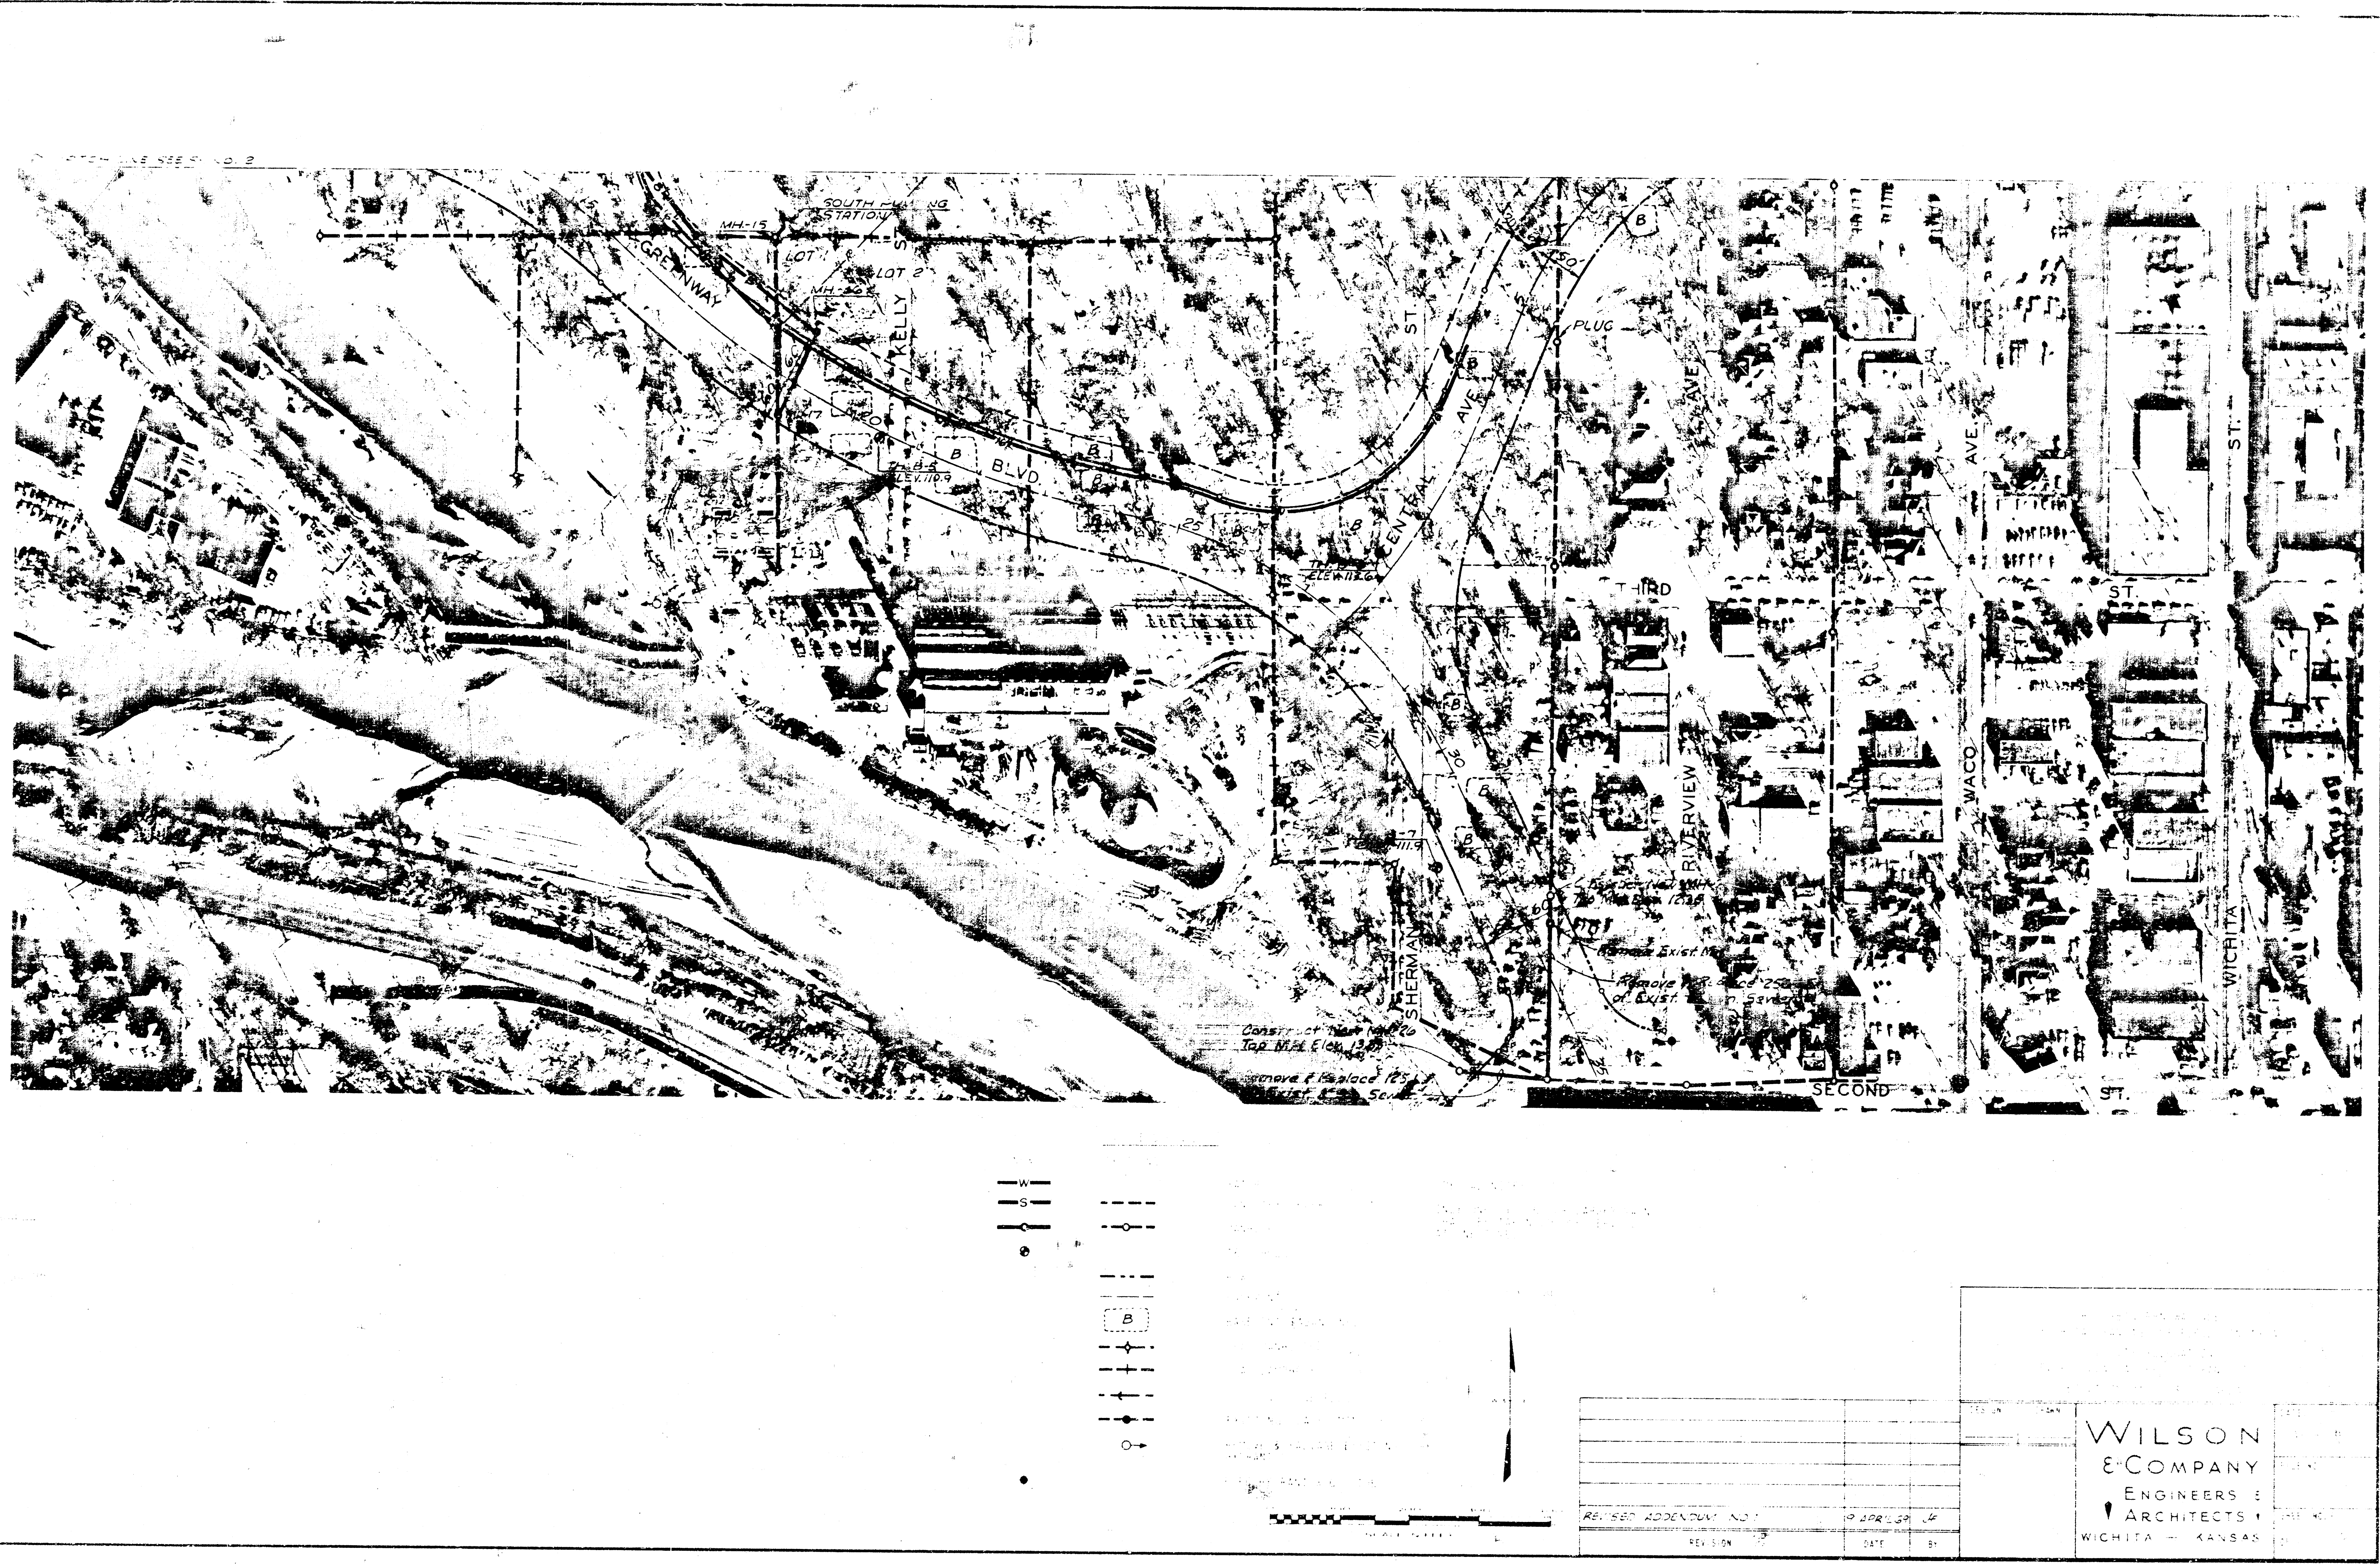

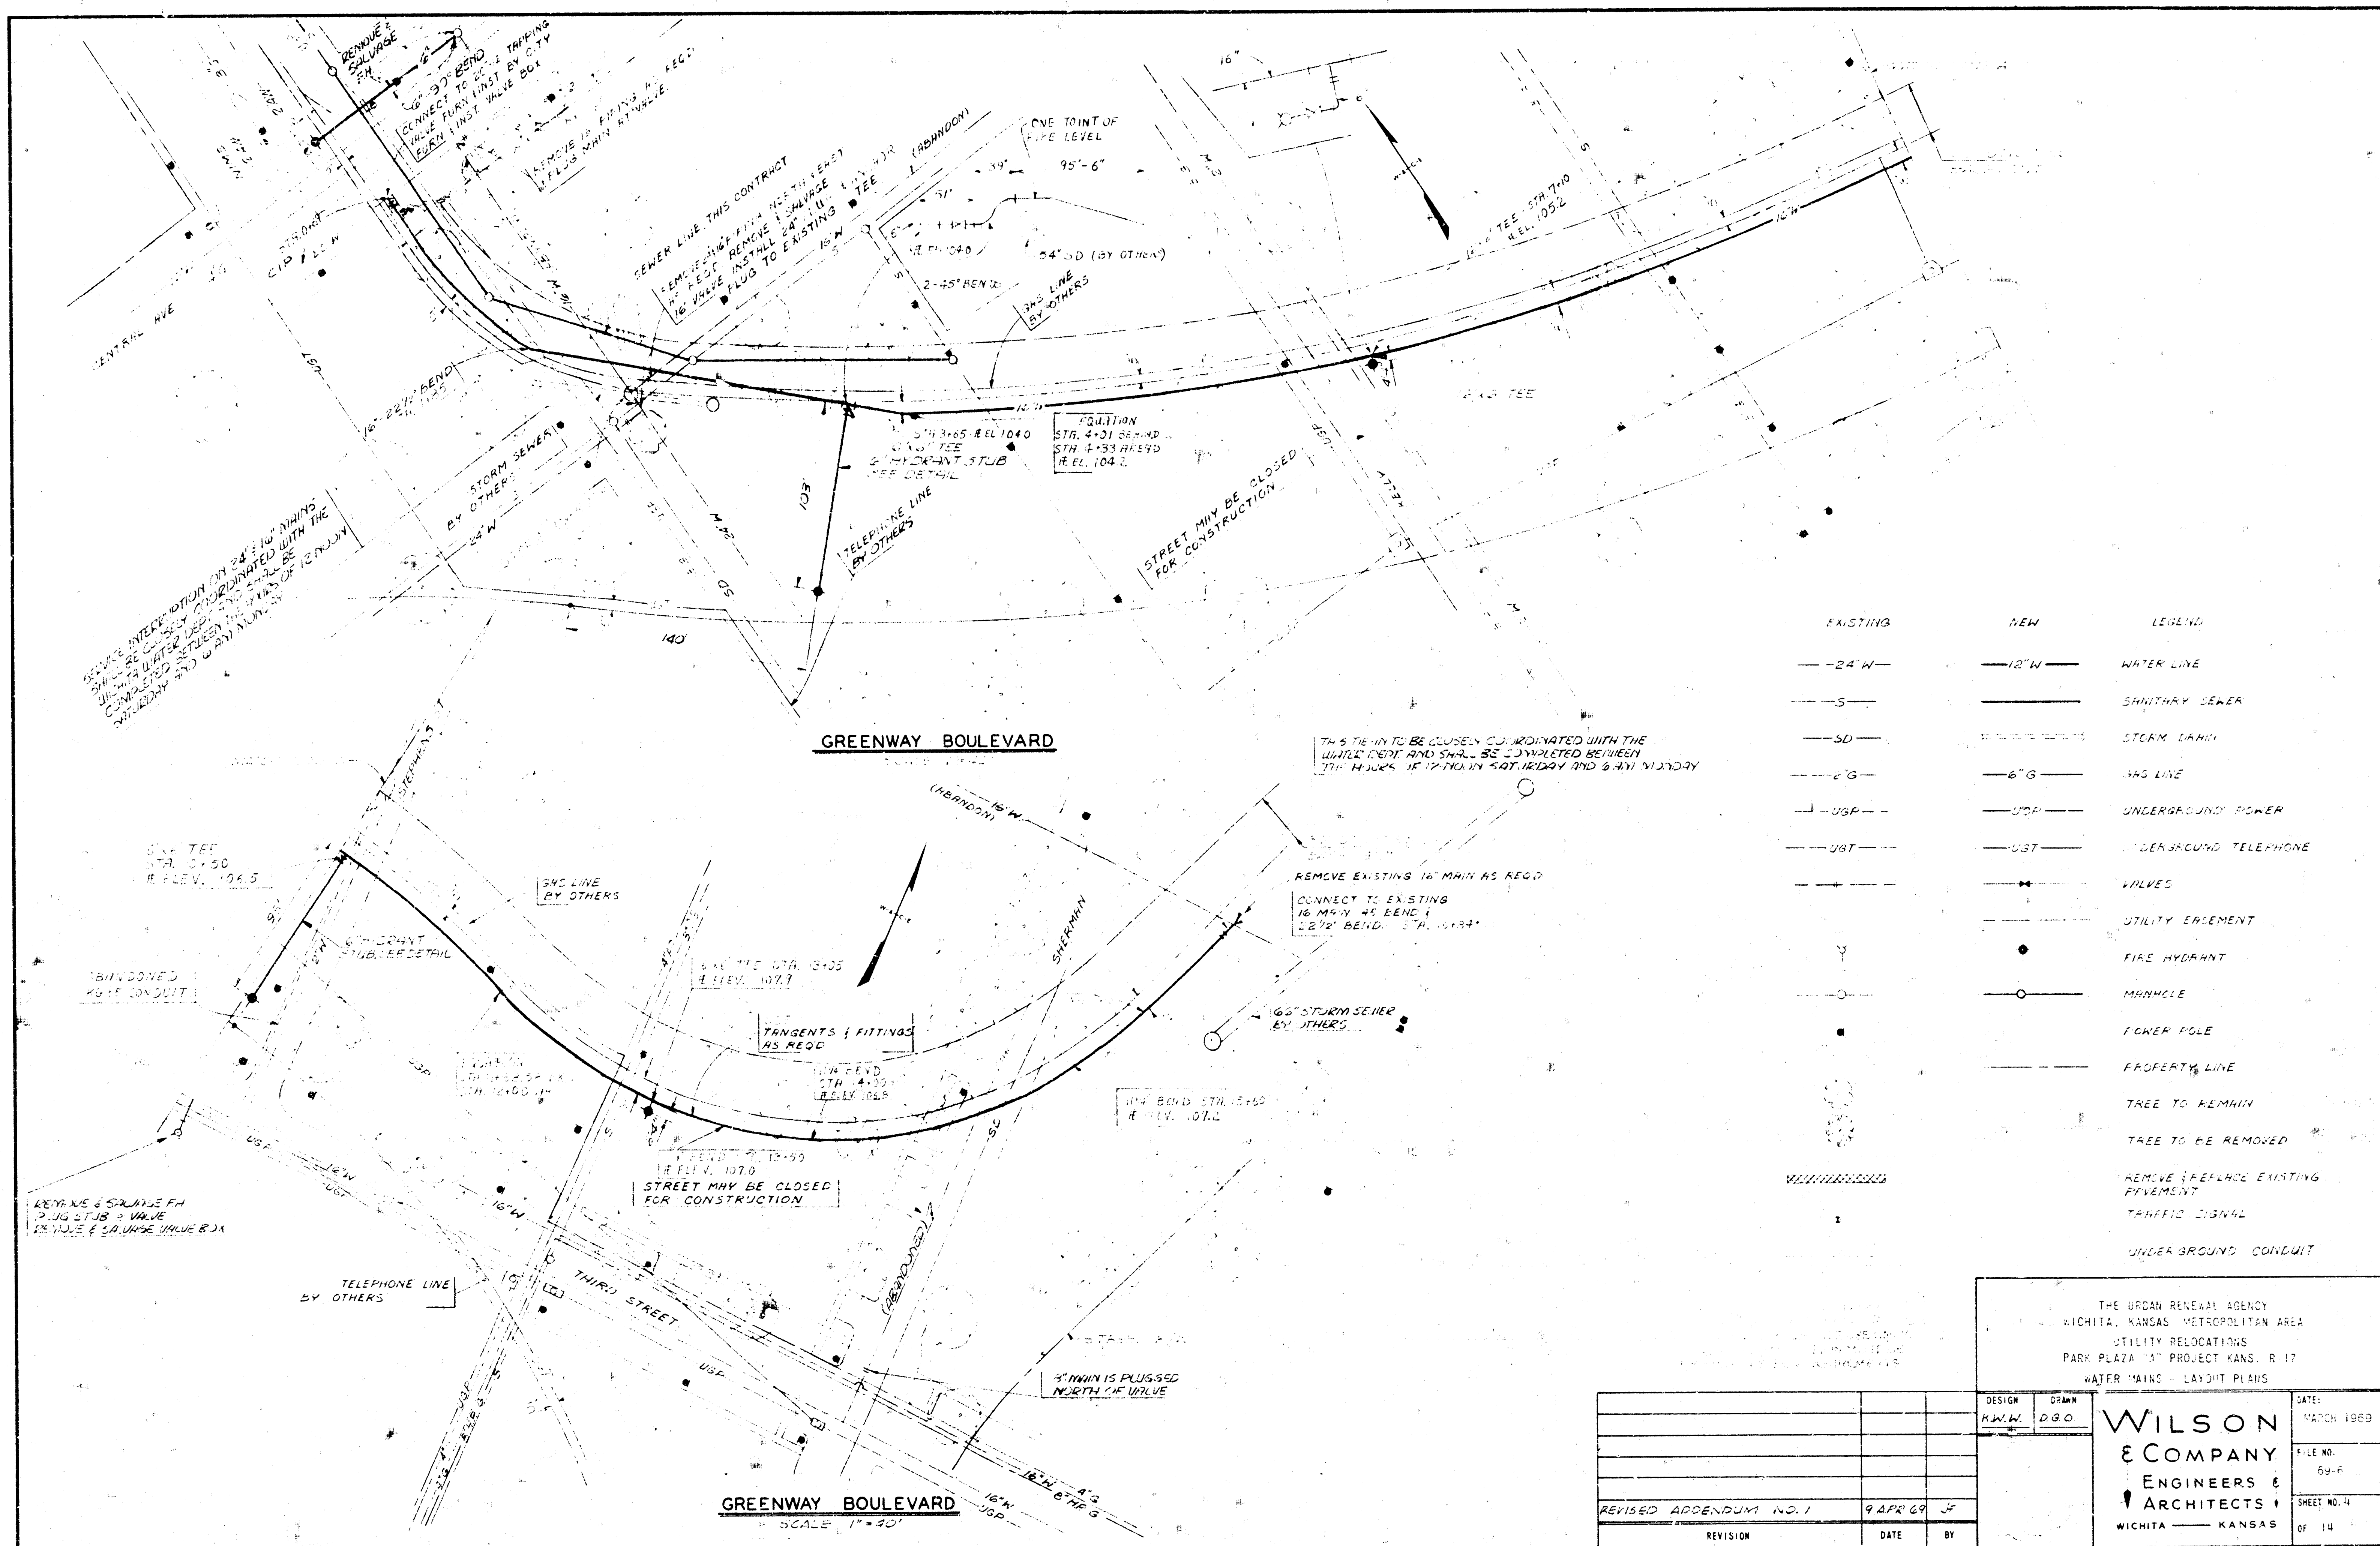

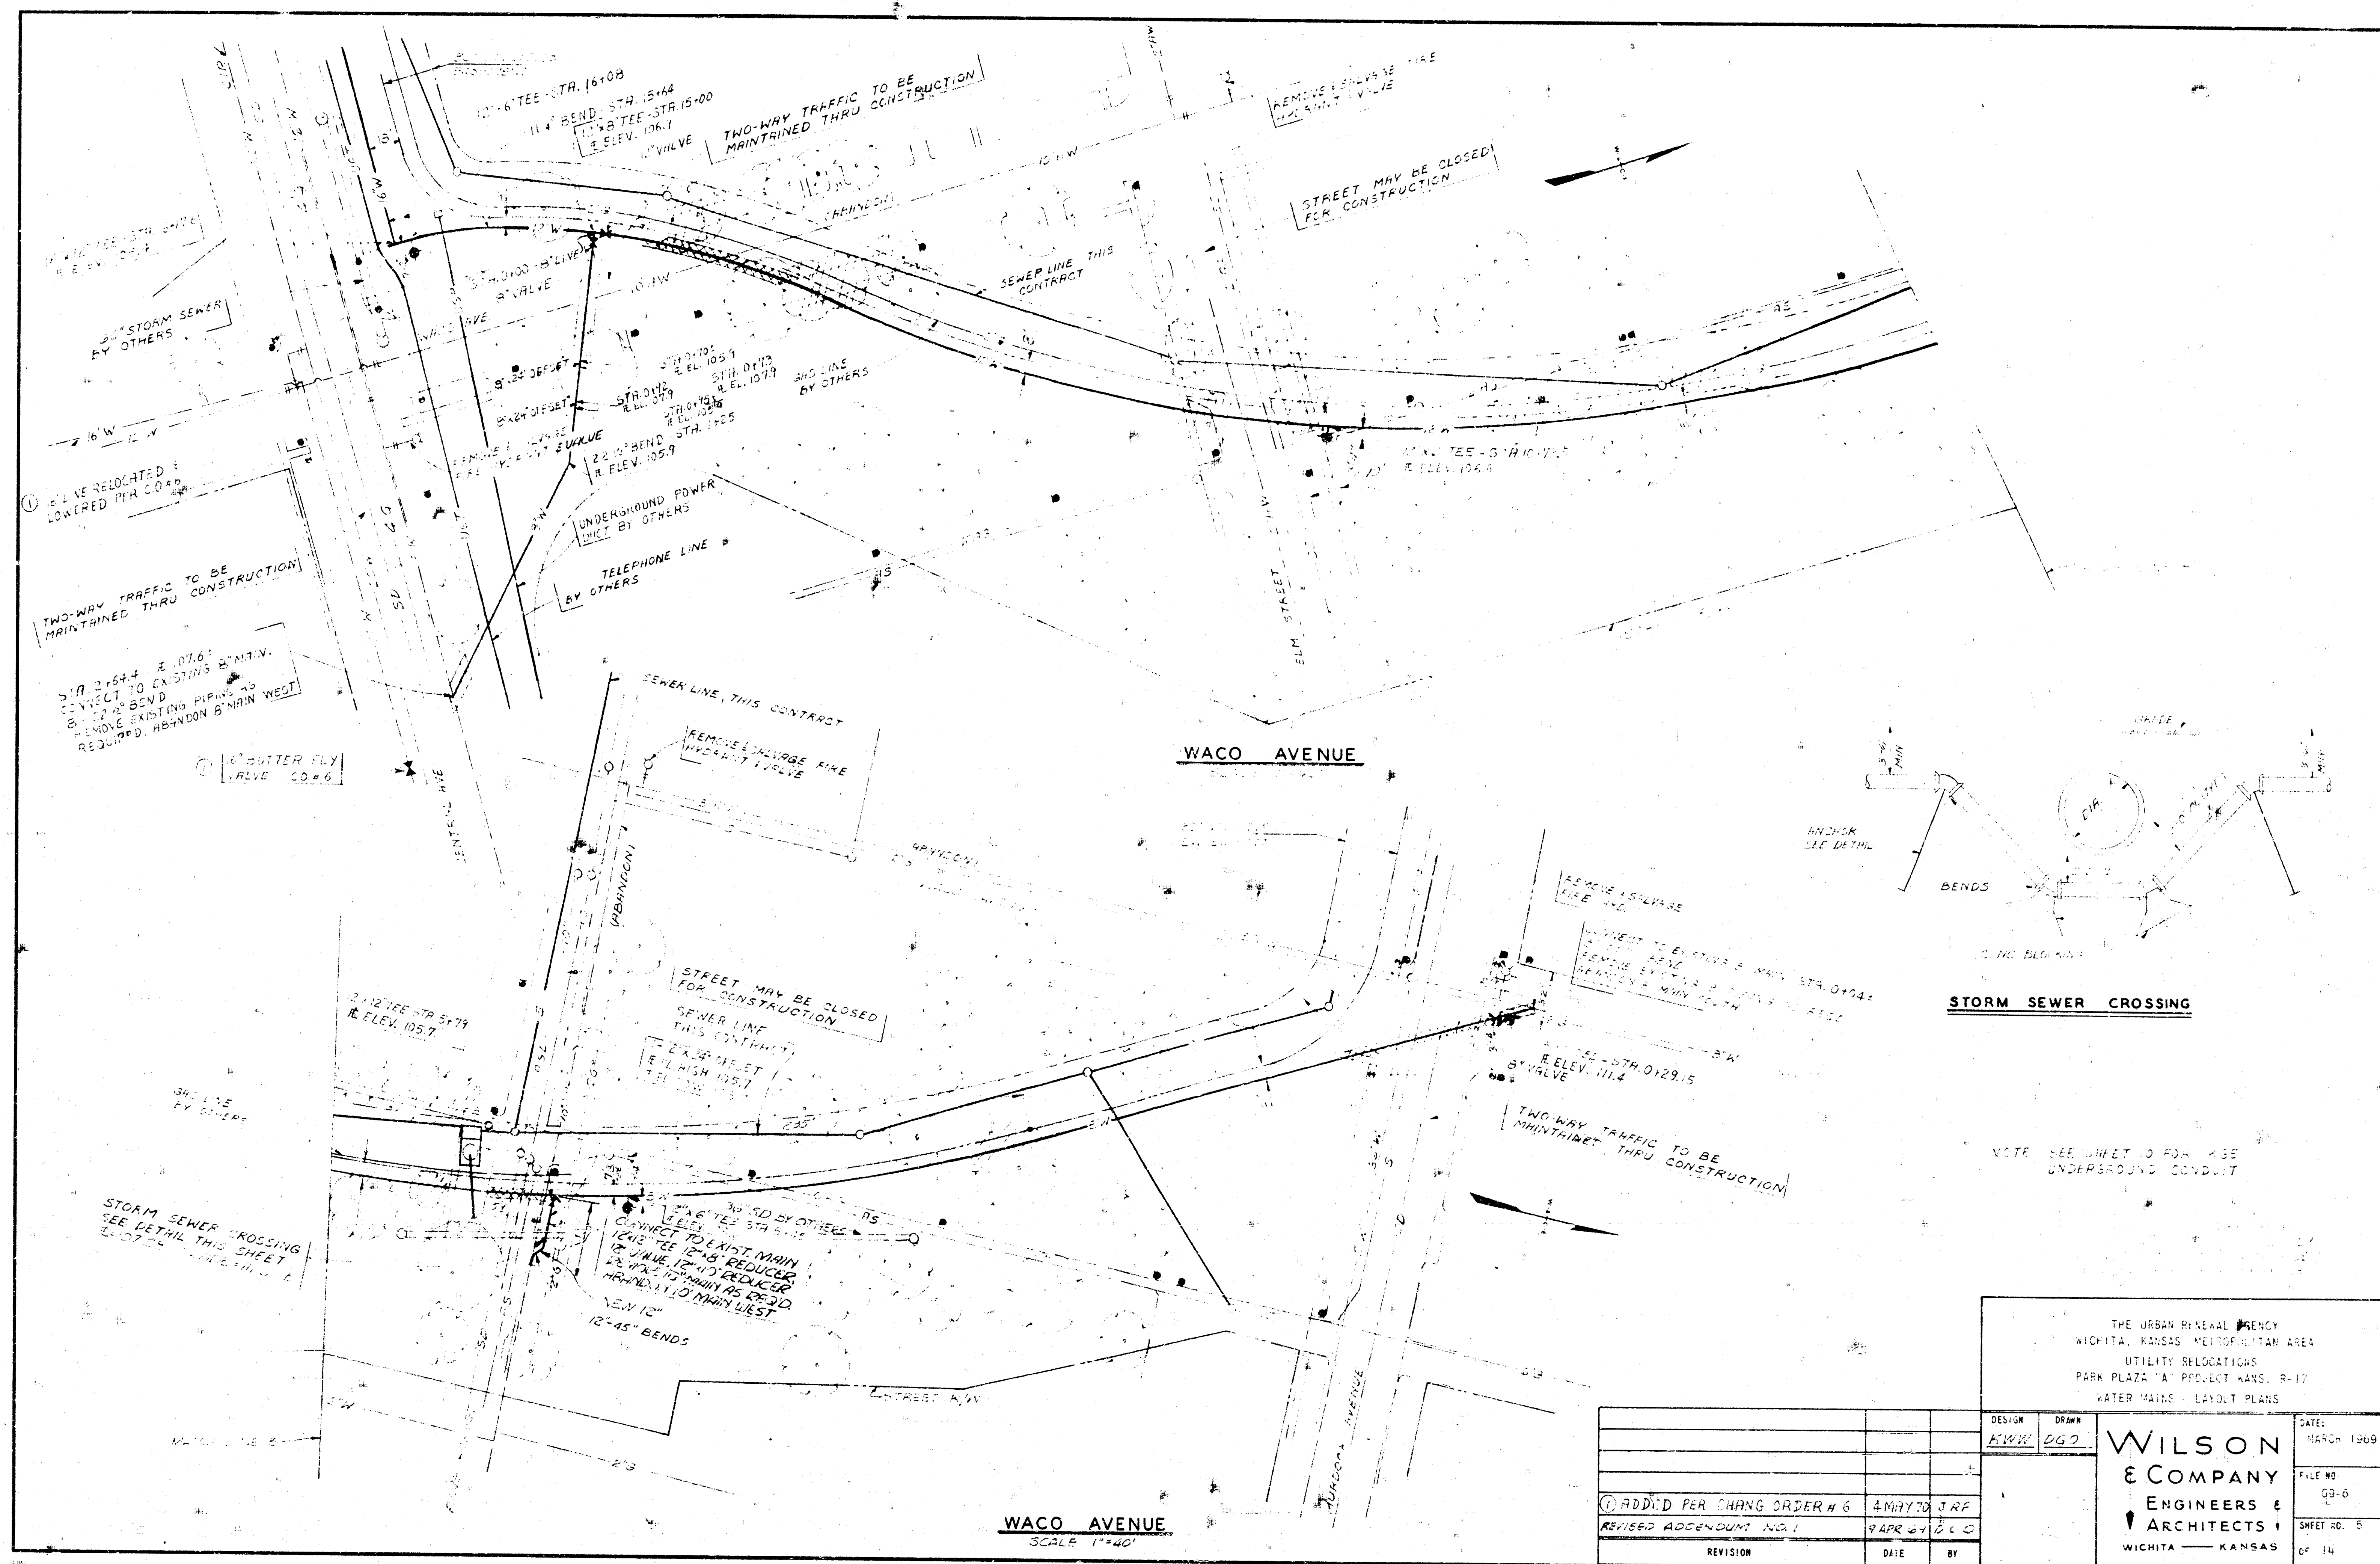

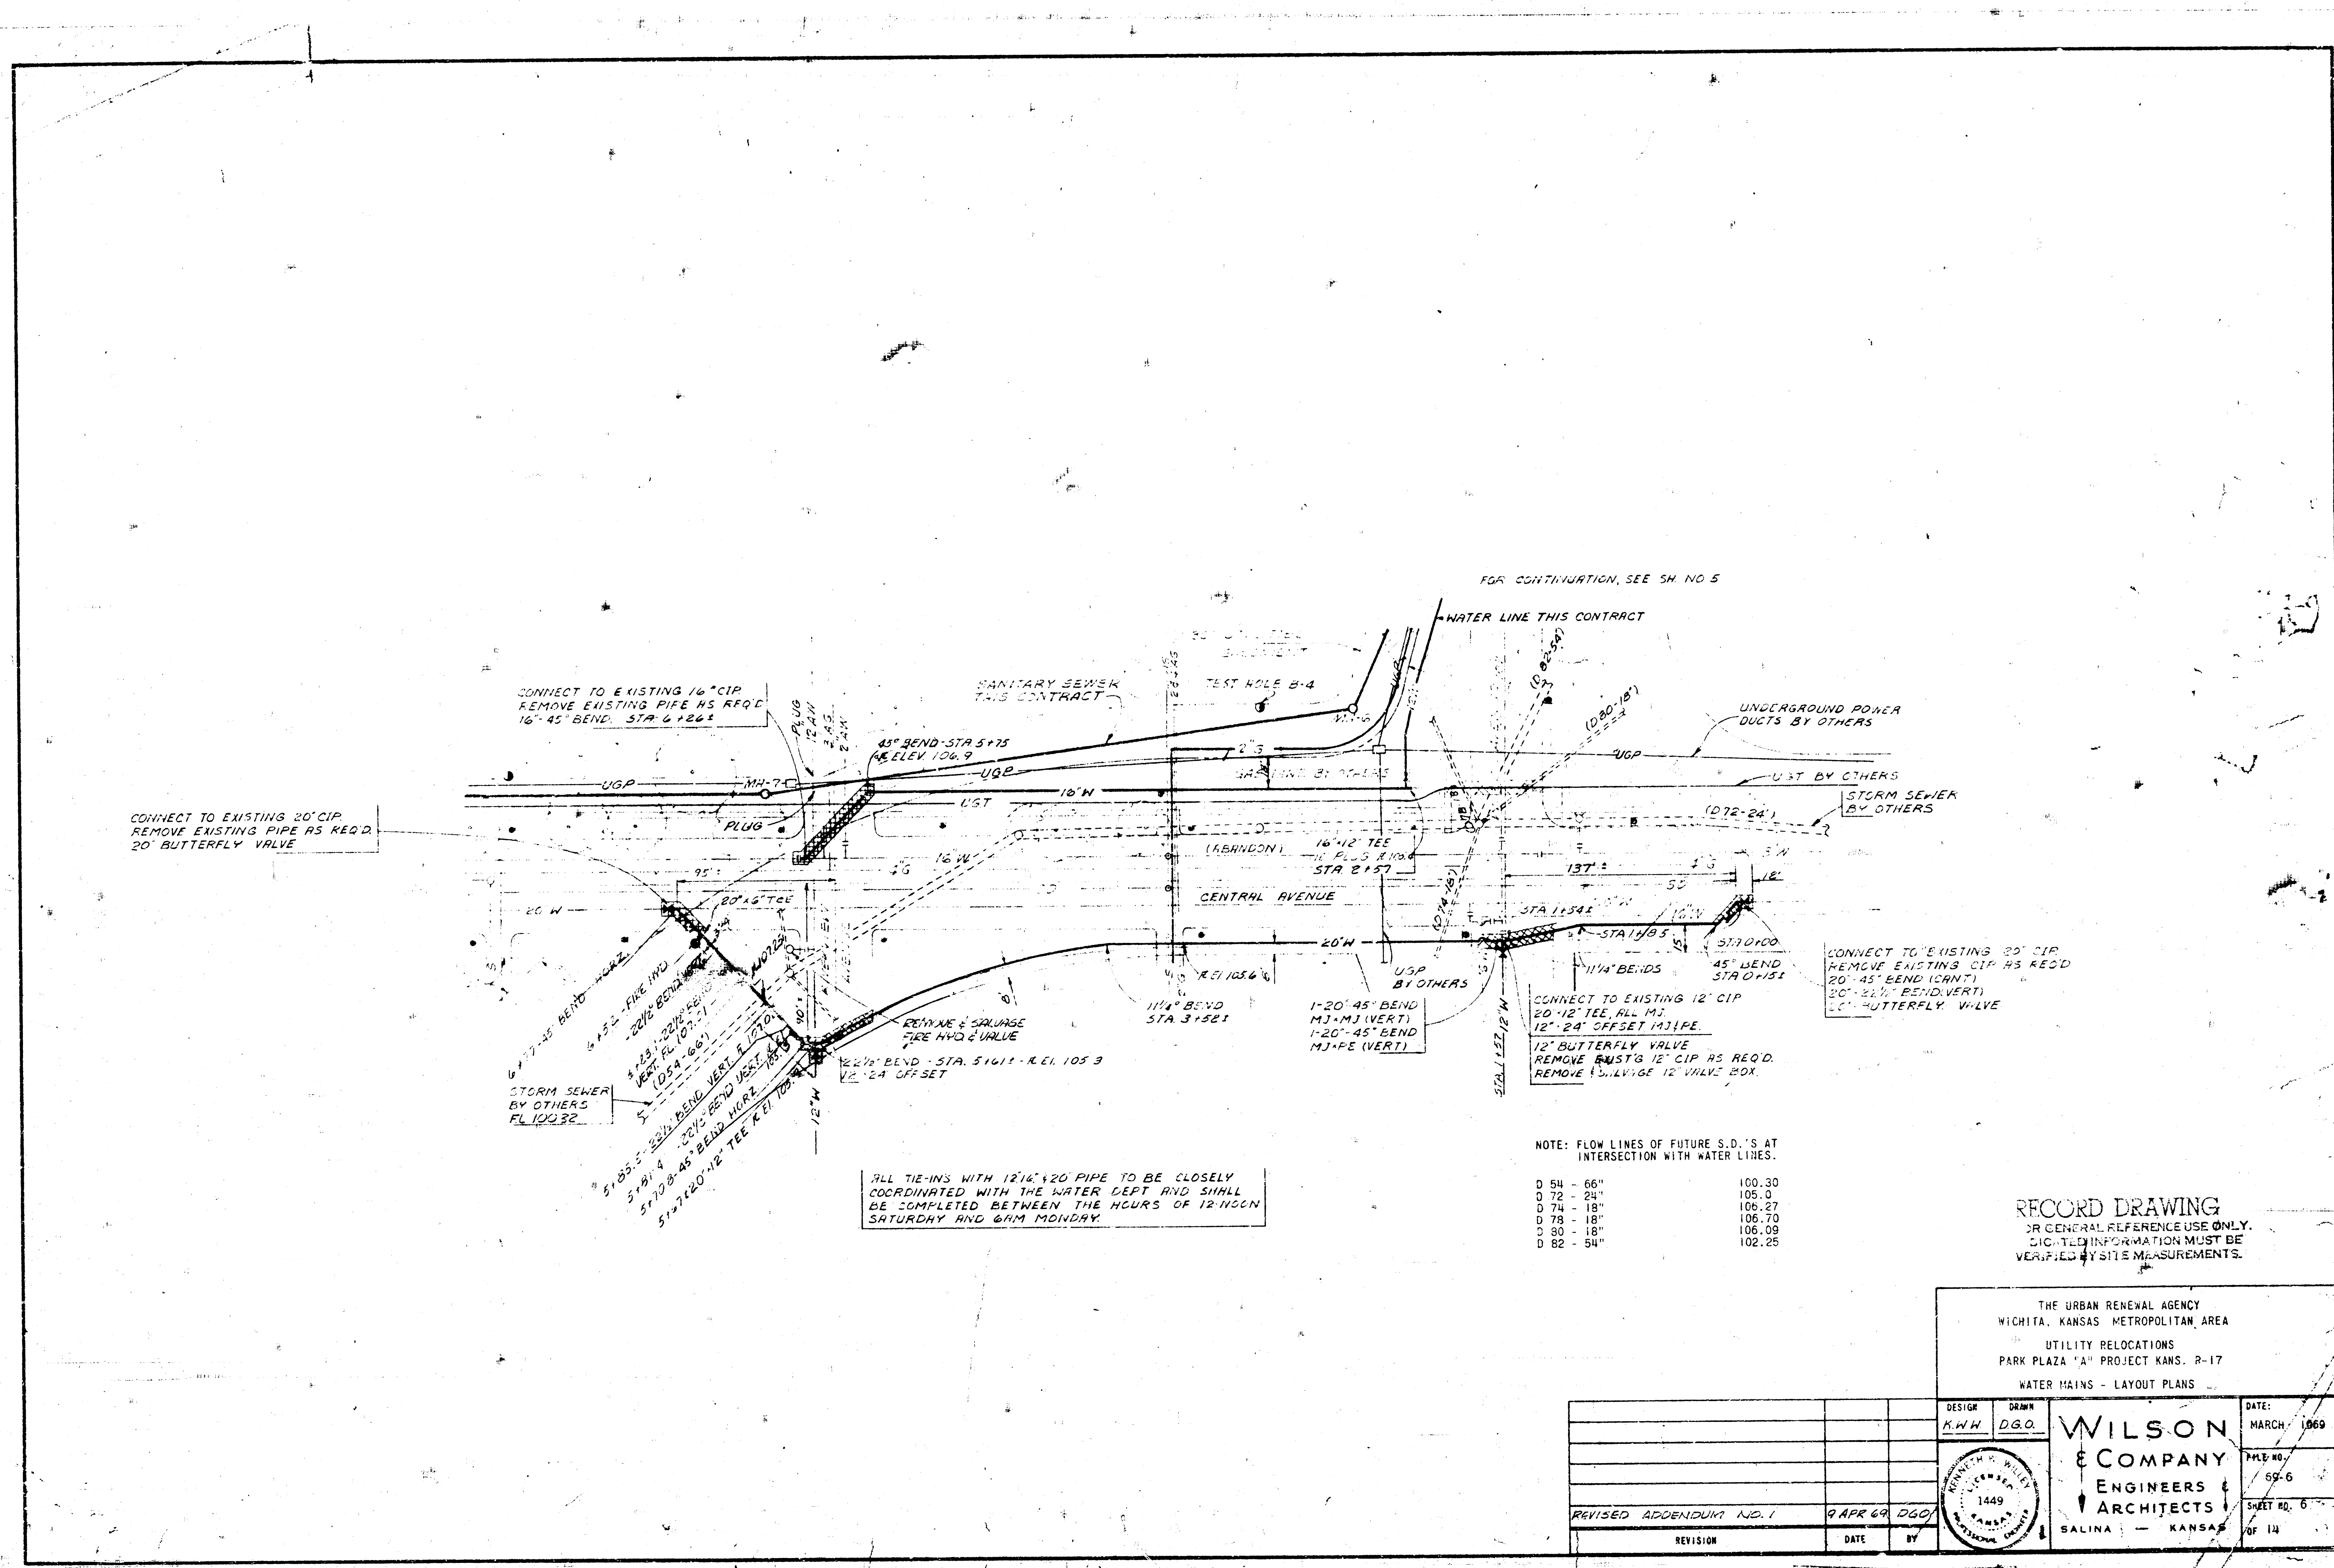

NOTE: FLOW LINES OF FUTURE S.D.'S AT INTERSECTION WITH WATER LINES.

D 54 - 66"	100.30
D 72 - 24"	105.0
D 74 - 18"	106.27
D 78 - 18"	106.70
D 80 - 18"	106.09
D 82 - 54"	102.25

RECORD DRAWING
OR GENERAL REFERENCE USE ONLY.
CITY INFORMATION MUST BE
VERIFIED BY SITE MEASUREMENTS.


THE URBAN RENEWAL AGENCY
WICHITA, KANSAS METROPOLITAN AREA
UTILITY RELOCATIONS
PARK PLAZA "A" PROJECT KANS. R-17
WATER MAINS - LAYOUT PLANS

DESIGN A.M.H.	DRAWN D.S.O.
REVISION	
DATE	BY

WILSON
& COMPANY
ENGINEERS &
ARCHITECTS
SALINA - KANSAS


DATE: MARCH 1969
FILE NO. 65-6
SHEET NO. 6 OF 14

MINIMUM DIMENSIONS FOR REACTION BLOCKING					
DESIGN PRESSURE 150 PSI			3.5' DEPTH OF BURY		
ANGLE OF INTERNAL FRICTION, ϕ 25 DEGREES					
FITTING	LENGTH (L)	WIDTH (W)	HEIGHT (H)	REINFORCING	
				HOR.	VERT.
67-1/2° BEND					
18"	12'-0"	4'-8"	3'-6"		
14"					
12"					
10"					
8"					
6"					
4"					
TEE OR PLUG					
18"	10'-9"	4'-9"	3'-6"		
14"					
12"	8'-2"	3'-7"	2'-9"		
10"	7'-0"	3'-0"	2'-4"		
8"	5'-5"	2'-4"	1'-10"		
6"	4'-0"	2'-0"	1'-5"		
4"					
45° BEND					
18"	9'-0"	3'-9"	4'-4"		
14"	8'-3"	3'-6"	3'-6"		
12"	6'-3"	2'-6"	2'-8"		
10"					
8"	4'-2"	1'-9"	1'-10"		
6"					
4"					
22-1/2° BEND					
18"	4'-7"	2'-0"	4'-4"		
14"	4'-2"	2'-0"	3'-6"		
12"	3'-2"	2'-0"	2'-8"		
10"					
8"	2'-1"	2'-0"	1'-10"		
6"					
4"					
11-1/4° BEND					
18"	2'-4"	2'-0"	4'-4"		
14"	2'-1"	2'-0"	3'-6"		
12"	1'-6"	2'-0"	2'-9"		
10"	1'-6"	2'-0"	1'-10"		
8"					
6"					
4"					

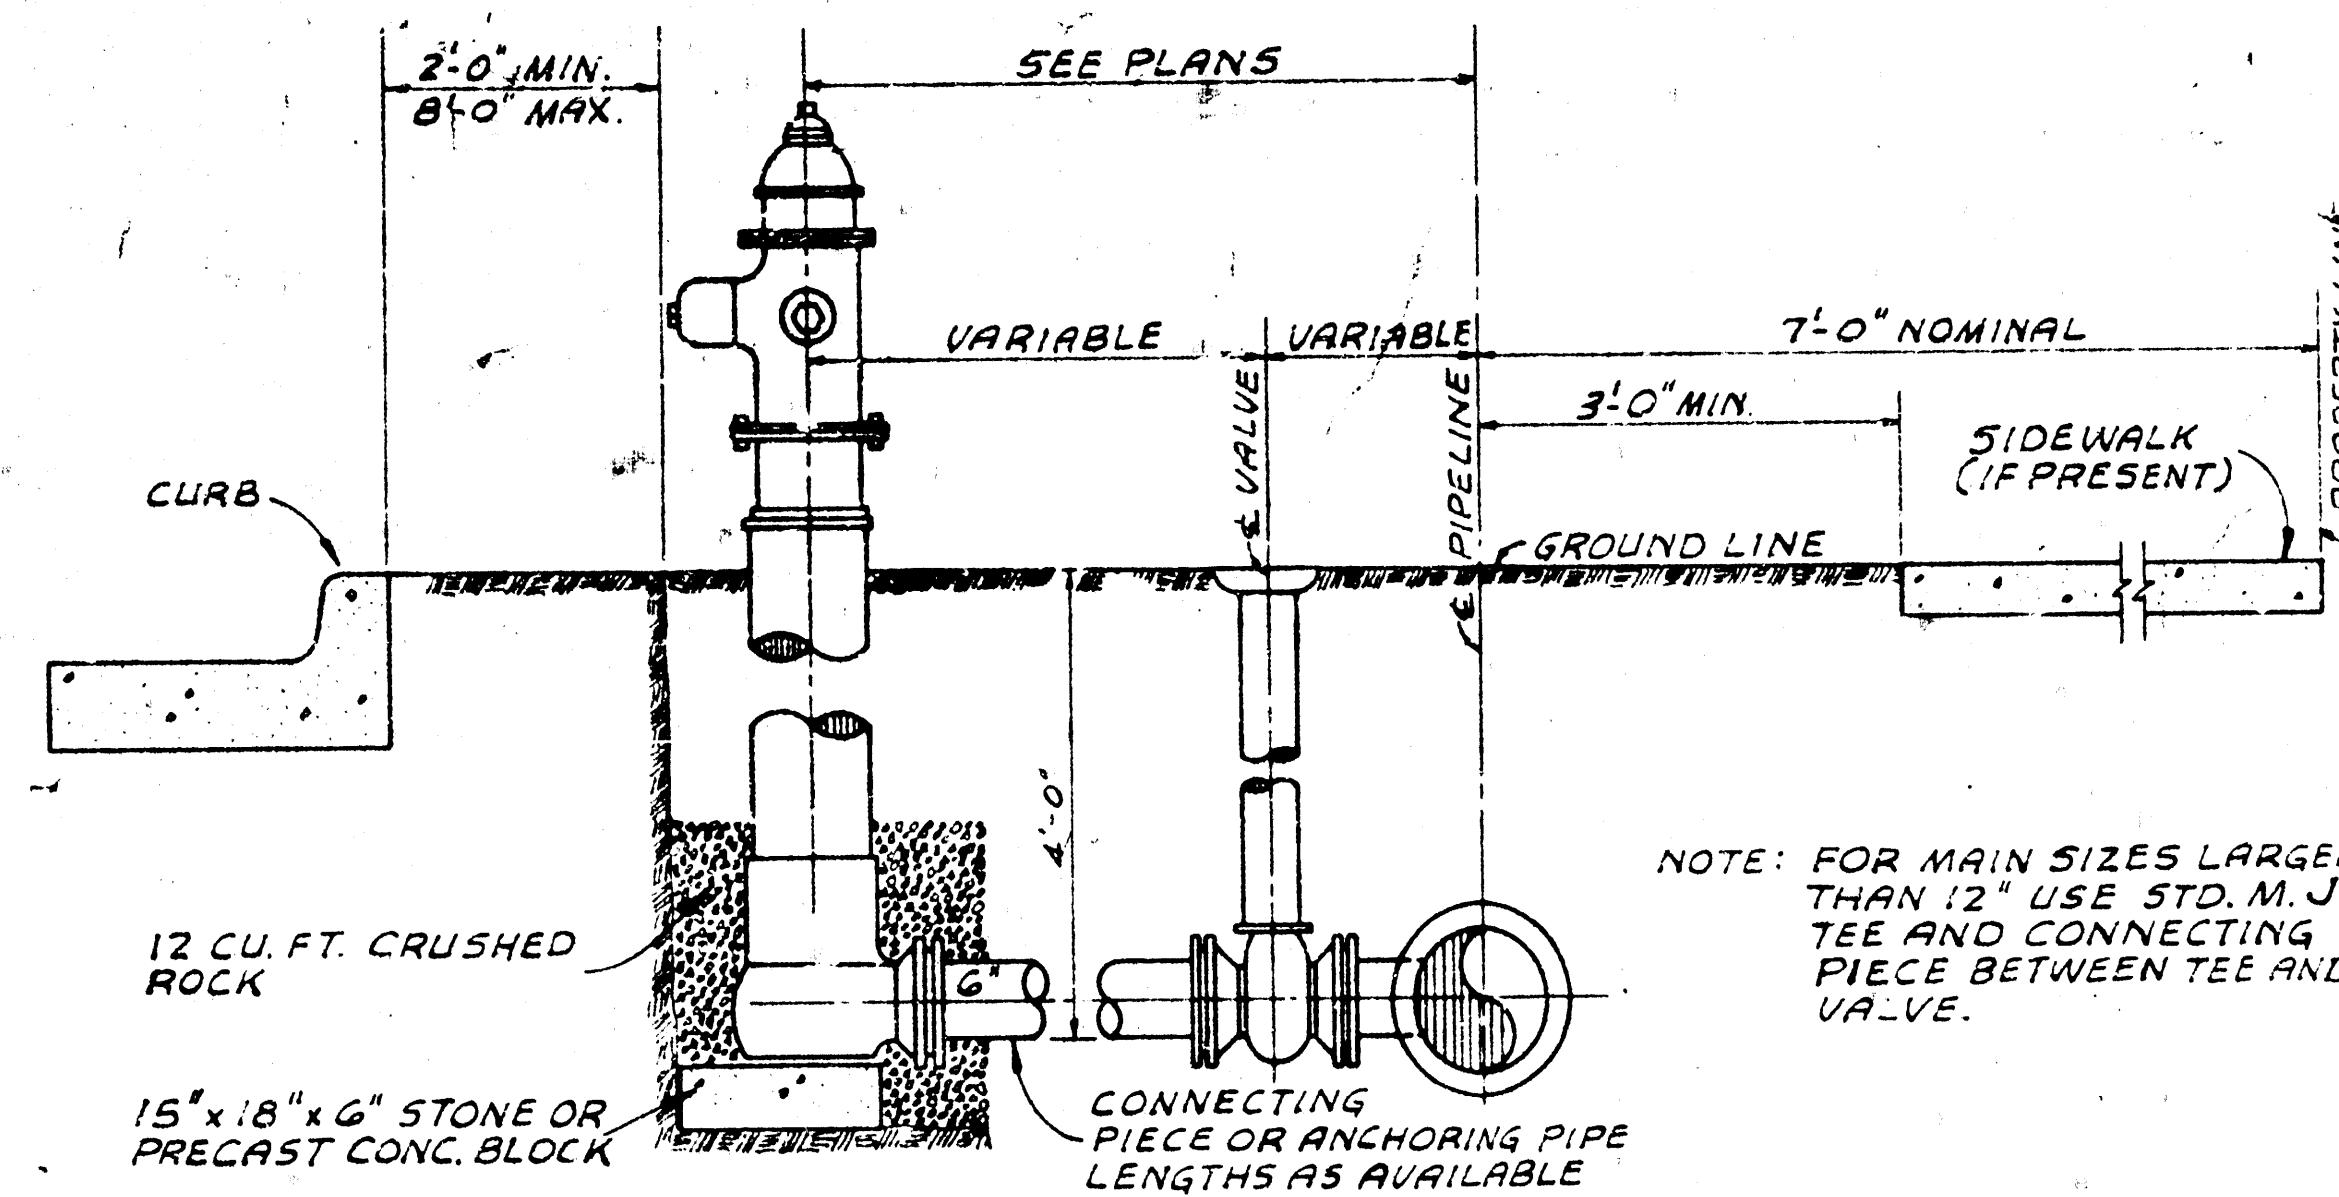


TYPICAL ANCHORED FIRE HYDRANT SETTING

NOT TO SCALE
NOTE: AT THE CONTRACTOR'S OPTION, LONG HYDRANT STUBS MAY BE CONSTRUCTED WITH RESTRAINED JOINT PIPE OR HYDRANT AND TEE AND MAY BE BLOCKED.

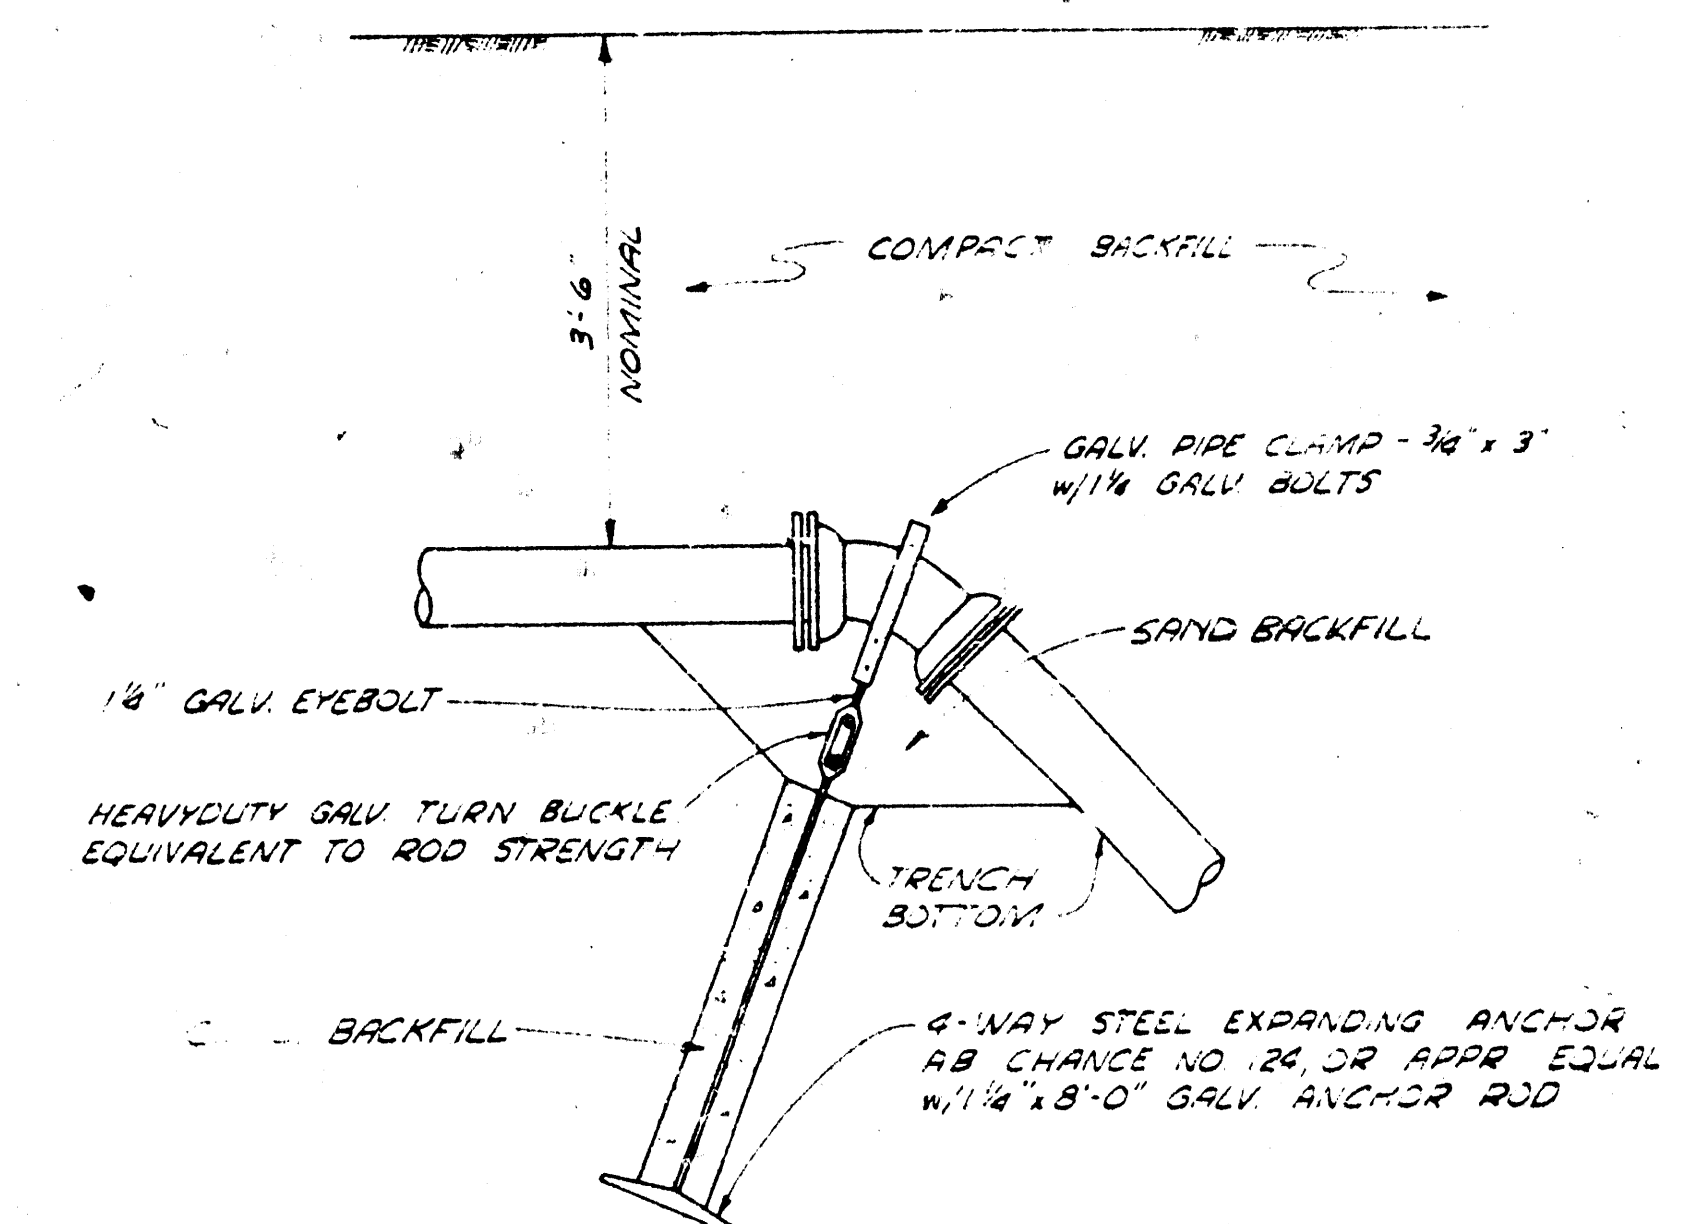


TYPICAL ANCHORAGE FOR 45°, 22-1/2° AND 11-1/4° VERTICAL BENDS

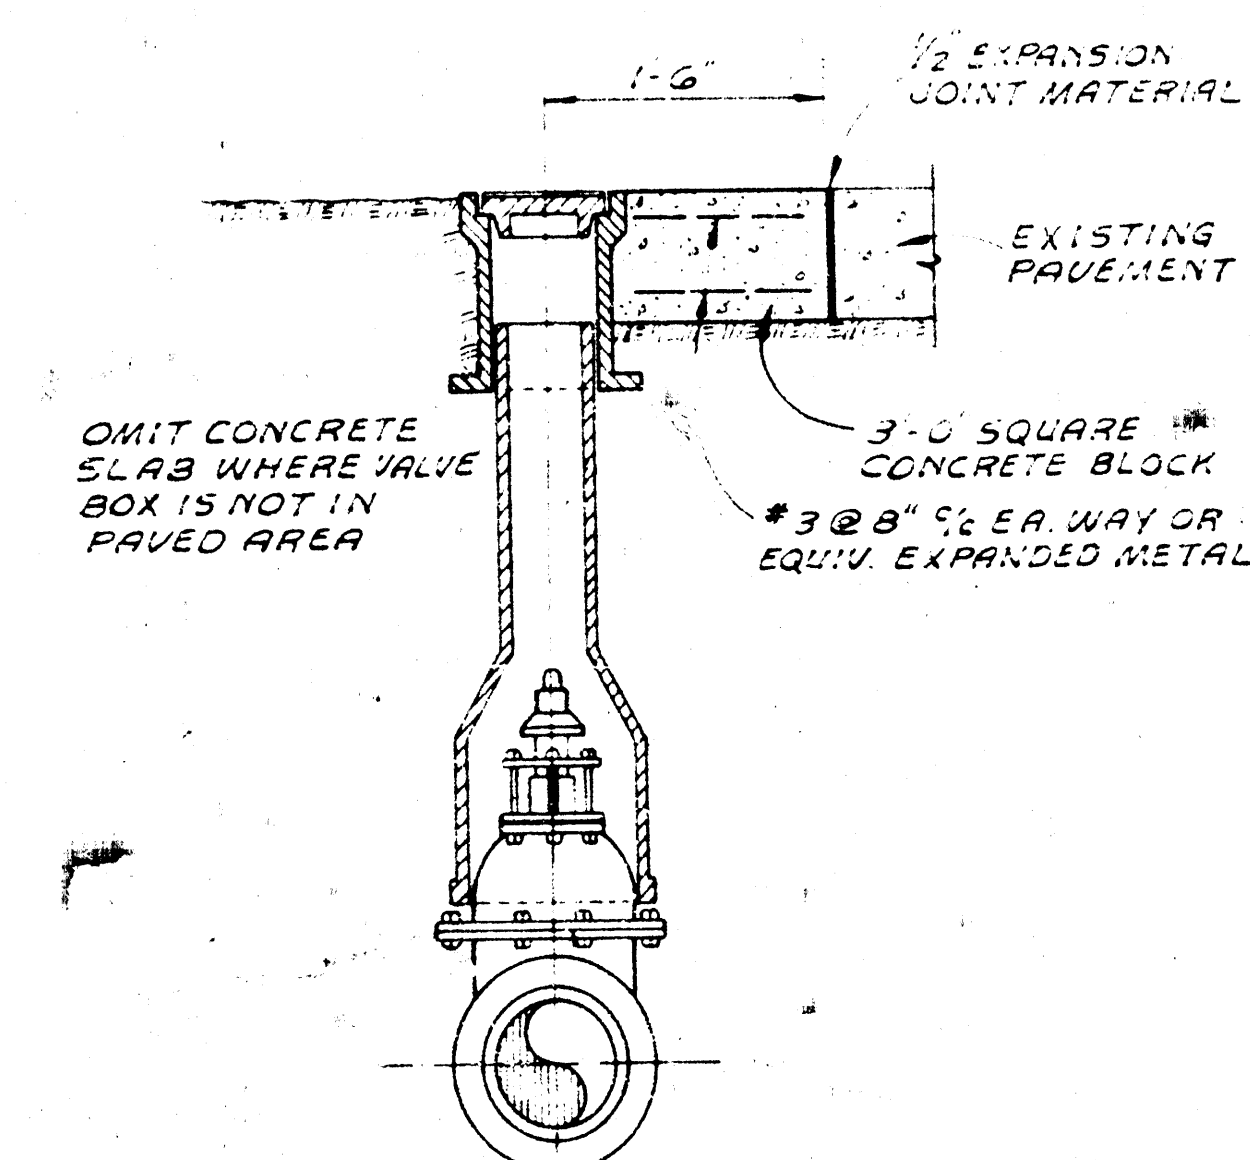


VALVE BOX DETAIL
NOT TO SCALE

RECORD DRAWING
OR GENERAL REFERENCE USE ONLY.
INDICATED INFORMATION MUST BE
VERIFIED BY SITE MEASUREMENTS.

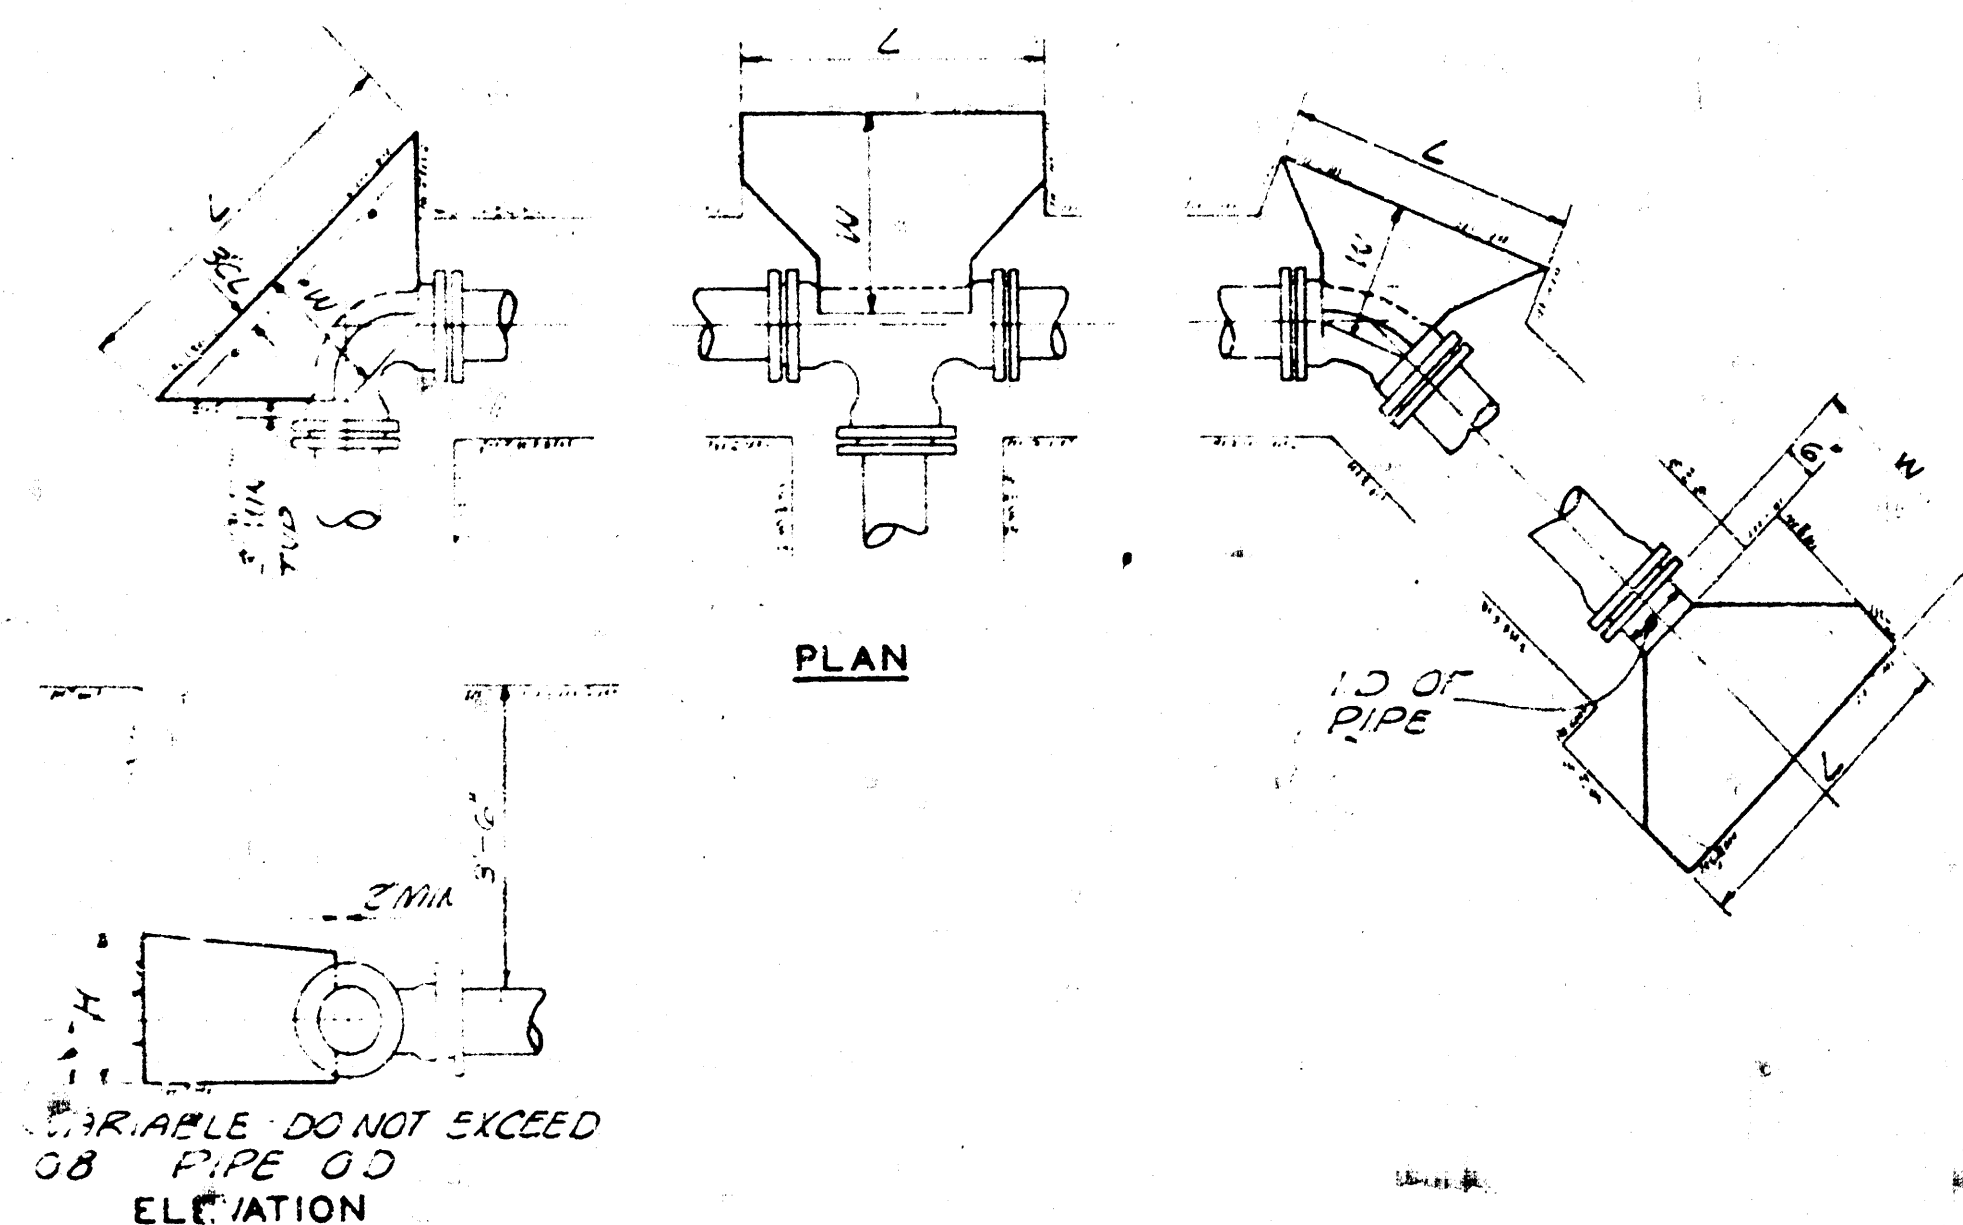


TYPICAL BLOCKING DETAIL
FOR CAST IRON FITTING
NOT TO SCALE

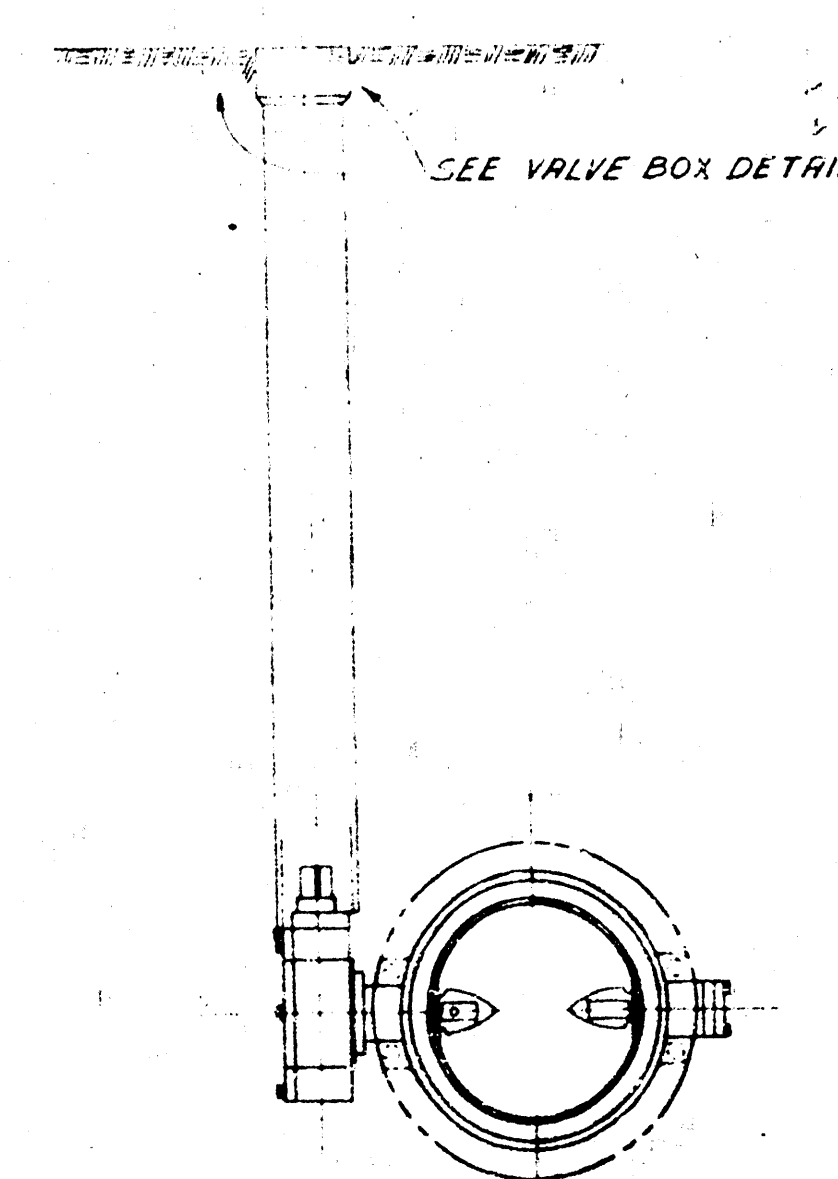


VALVE SETTING DETAIL
12' AND LARGER VALVES
(EXCEPT AS INDICATED)


REVISION	DATE	BY	CHKD
REVISED ADDENDUM NO. 1	9 APR 69	PGO	
THE URBAN RENEWAL AGENCY WICHITA, KANSAS METROPOLITAN AREA UTILITY RELOCATIONS PARK PLANNING PROJECT KANSAS R-17 WATER MAIN DETAILS			
WILSON & COMPANY ENGINEERS & ARCHITECTS WICHITA, KANSAS			MARCH 1969 69-6 114

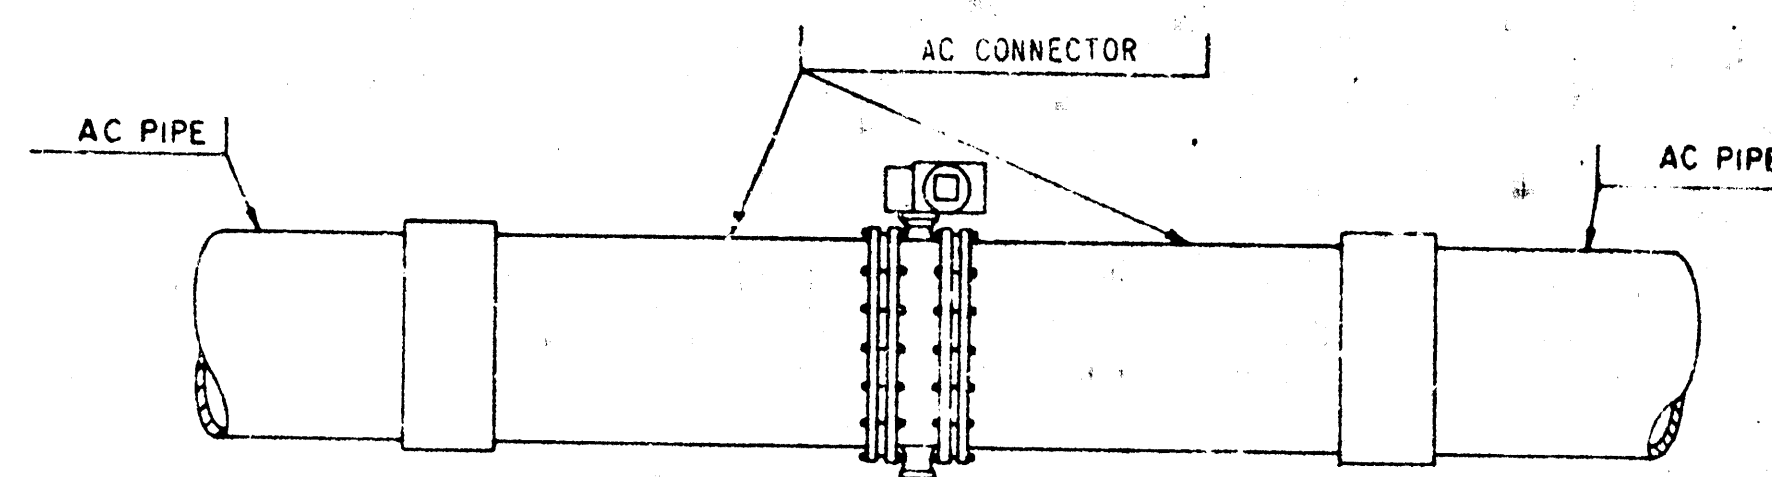


TYPICAL VALVE SETTING DETAIL IN AC PIPE LINE

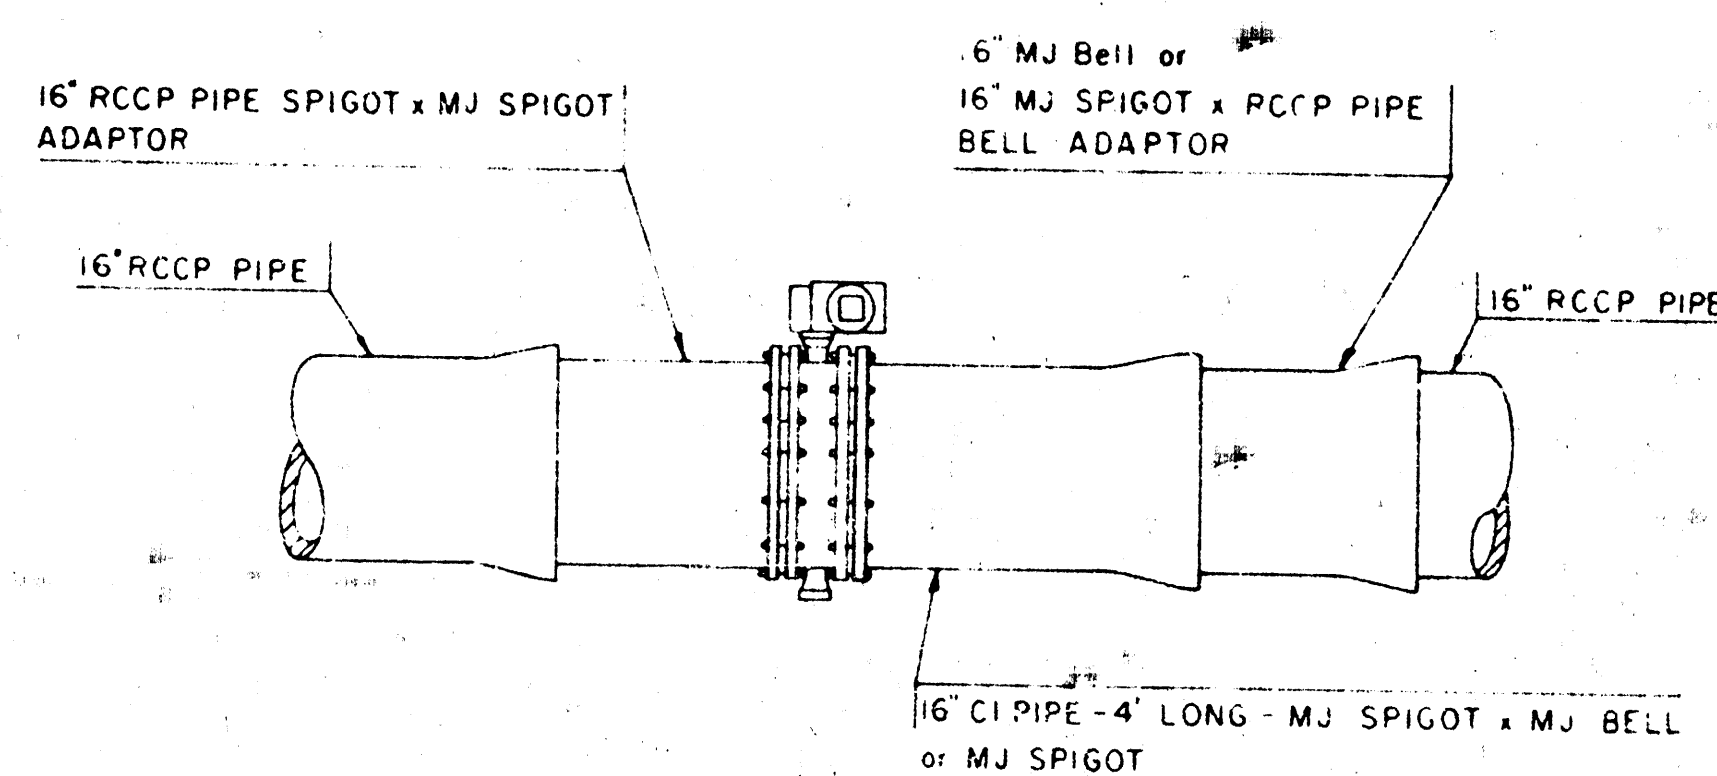


TYPICAL VALVE SETTING DETAIL IN RCCP PIPE LINE

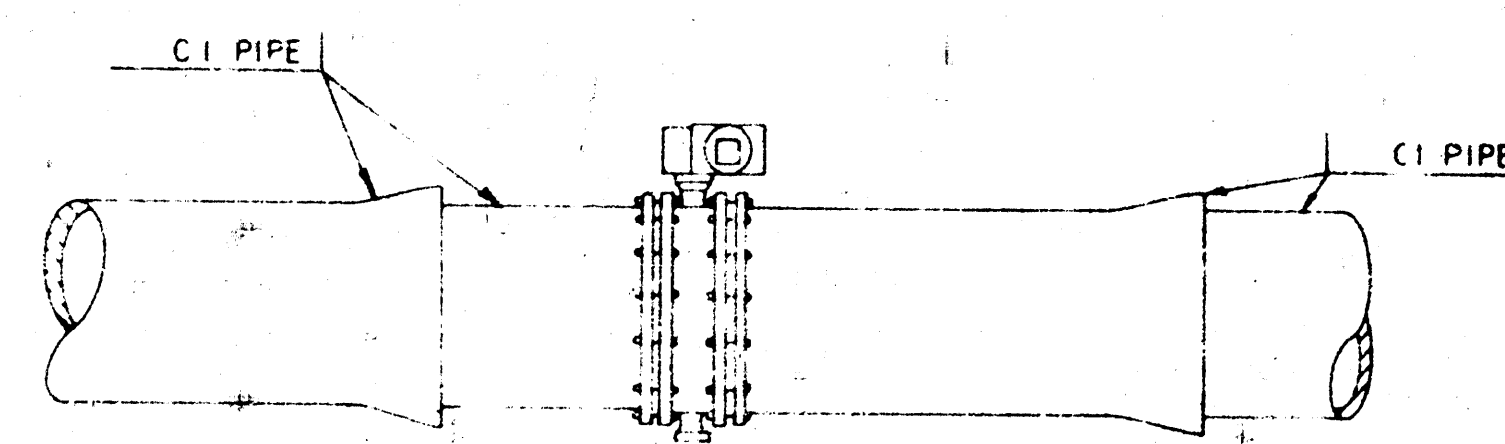

TYPICAL VALVE SETTING DETAIL IN CI PIPE LINE

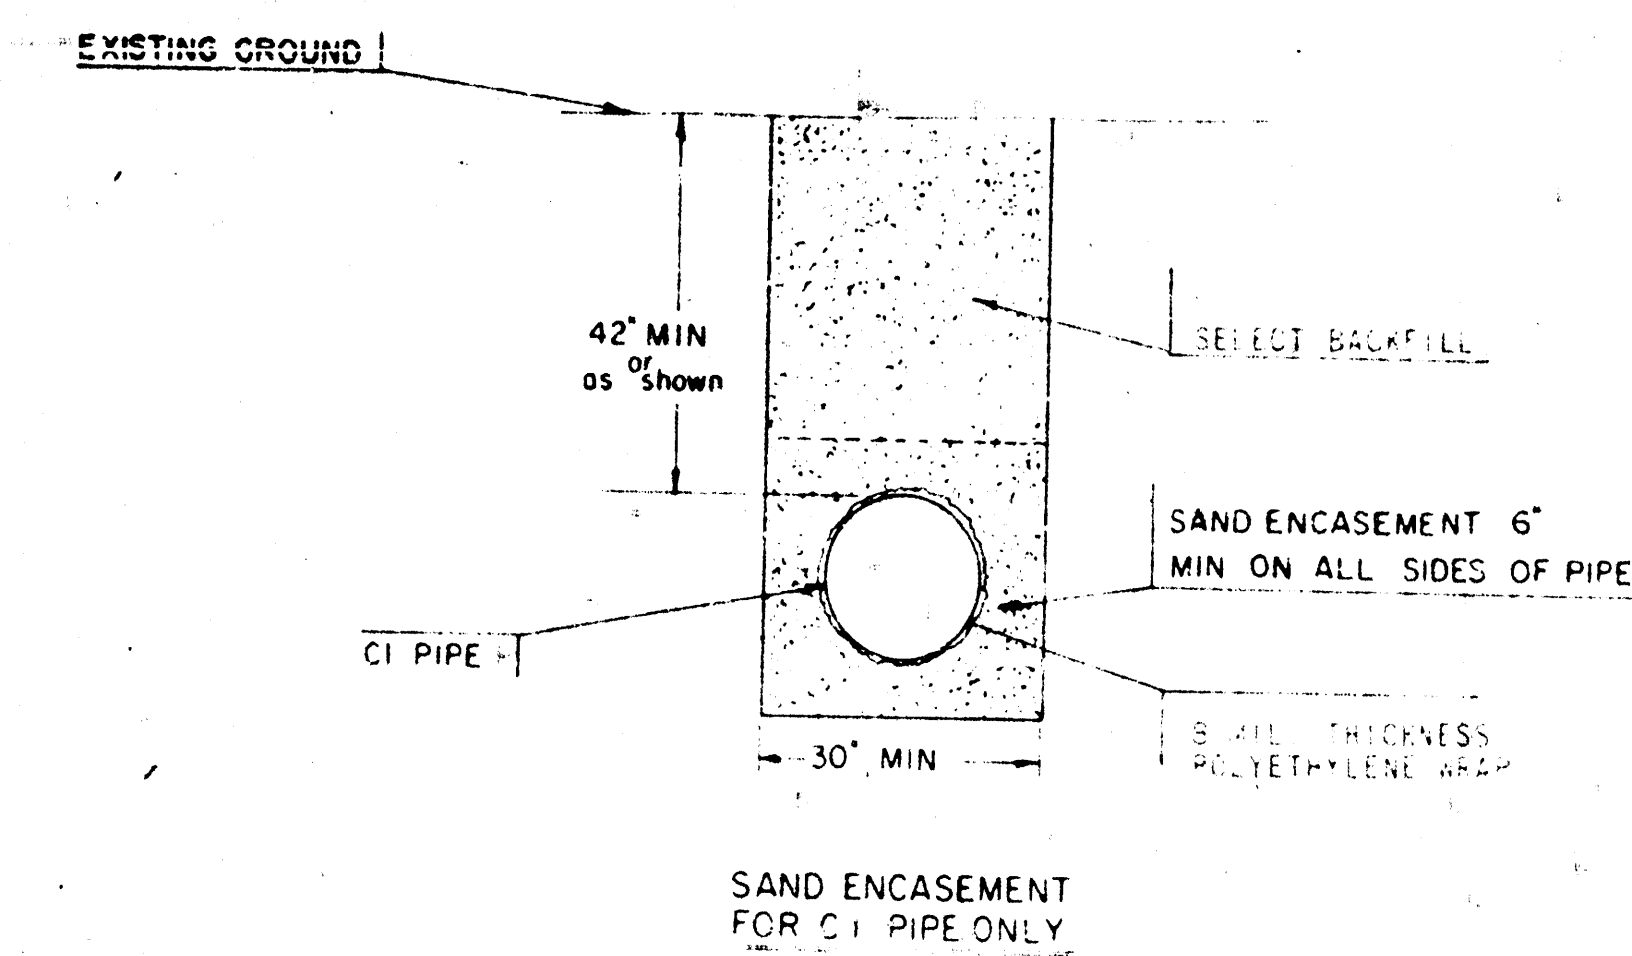

SAND ENCASMENT FOR CI PIPE ONLY

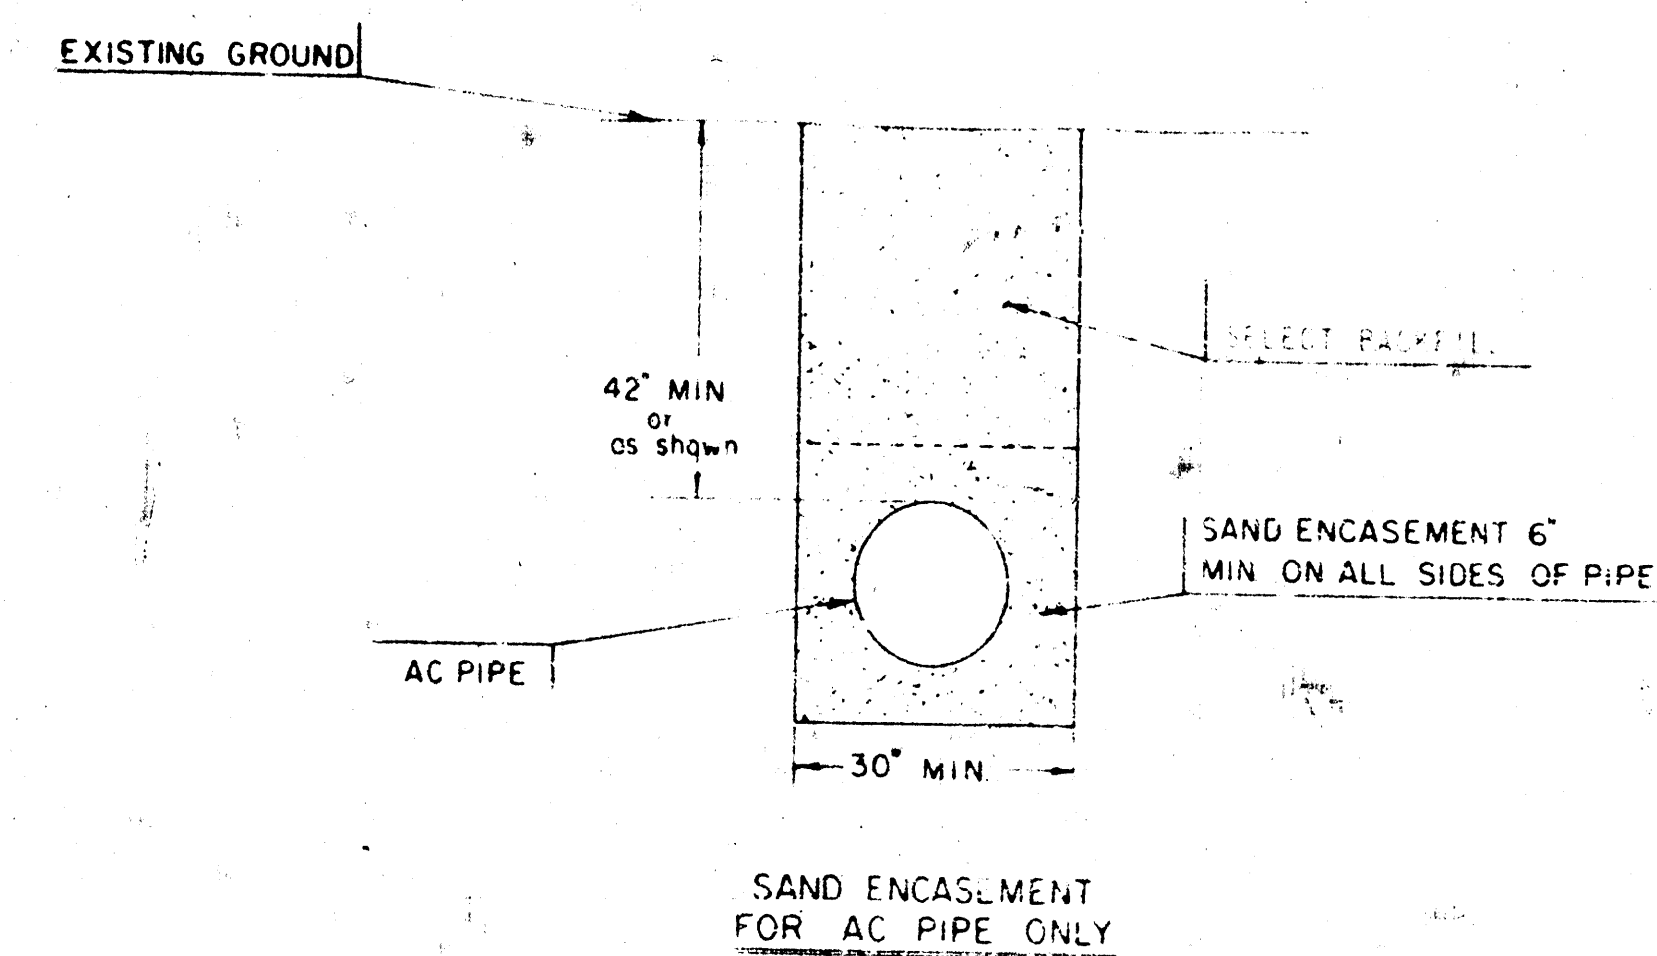

SAND ENCASMENT FOR AC PIPE ONLY


RECORD DRAWING
FOR GENERAL REFERENCE USE ONLY.
ADDITIONAL INFORMATION MUST BE
OBTAINED BY SITE MEASUREMENTS.


THE URBAN RENEWAL AGENCY
WICHITA, KANSAS METROPOLITAN -RCA
UTILITY RELOCATIONS
PARK PLAZA "A" PROJECT KANS. R-17
WATER MAIN DETAILS




WILSON
& COMPANY
ENGINEERS
ARCHITECTS
WICHITA KANSAS

MARCH 1969
NO.
69-6
10-8


REVISION	DATE	BY	CHKD

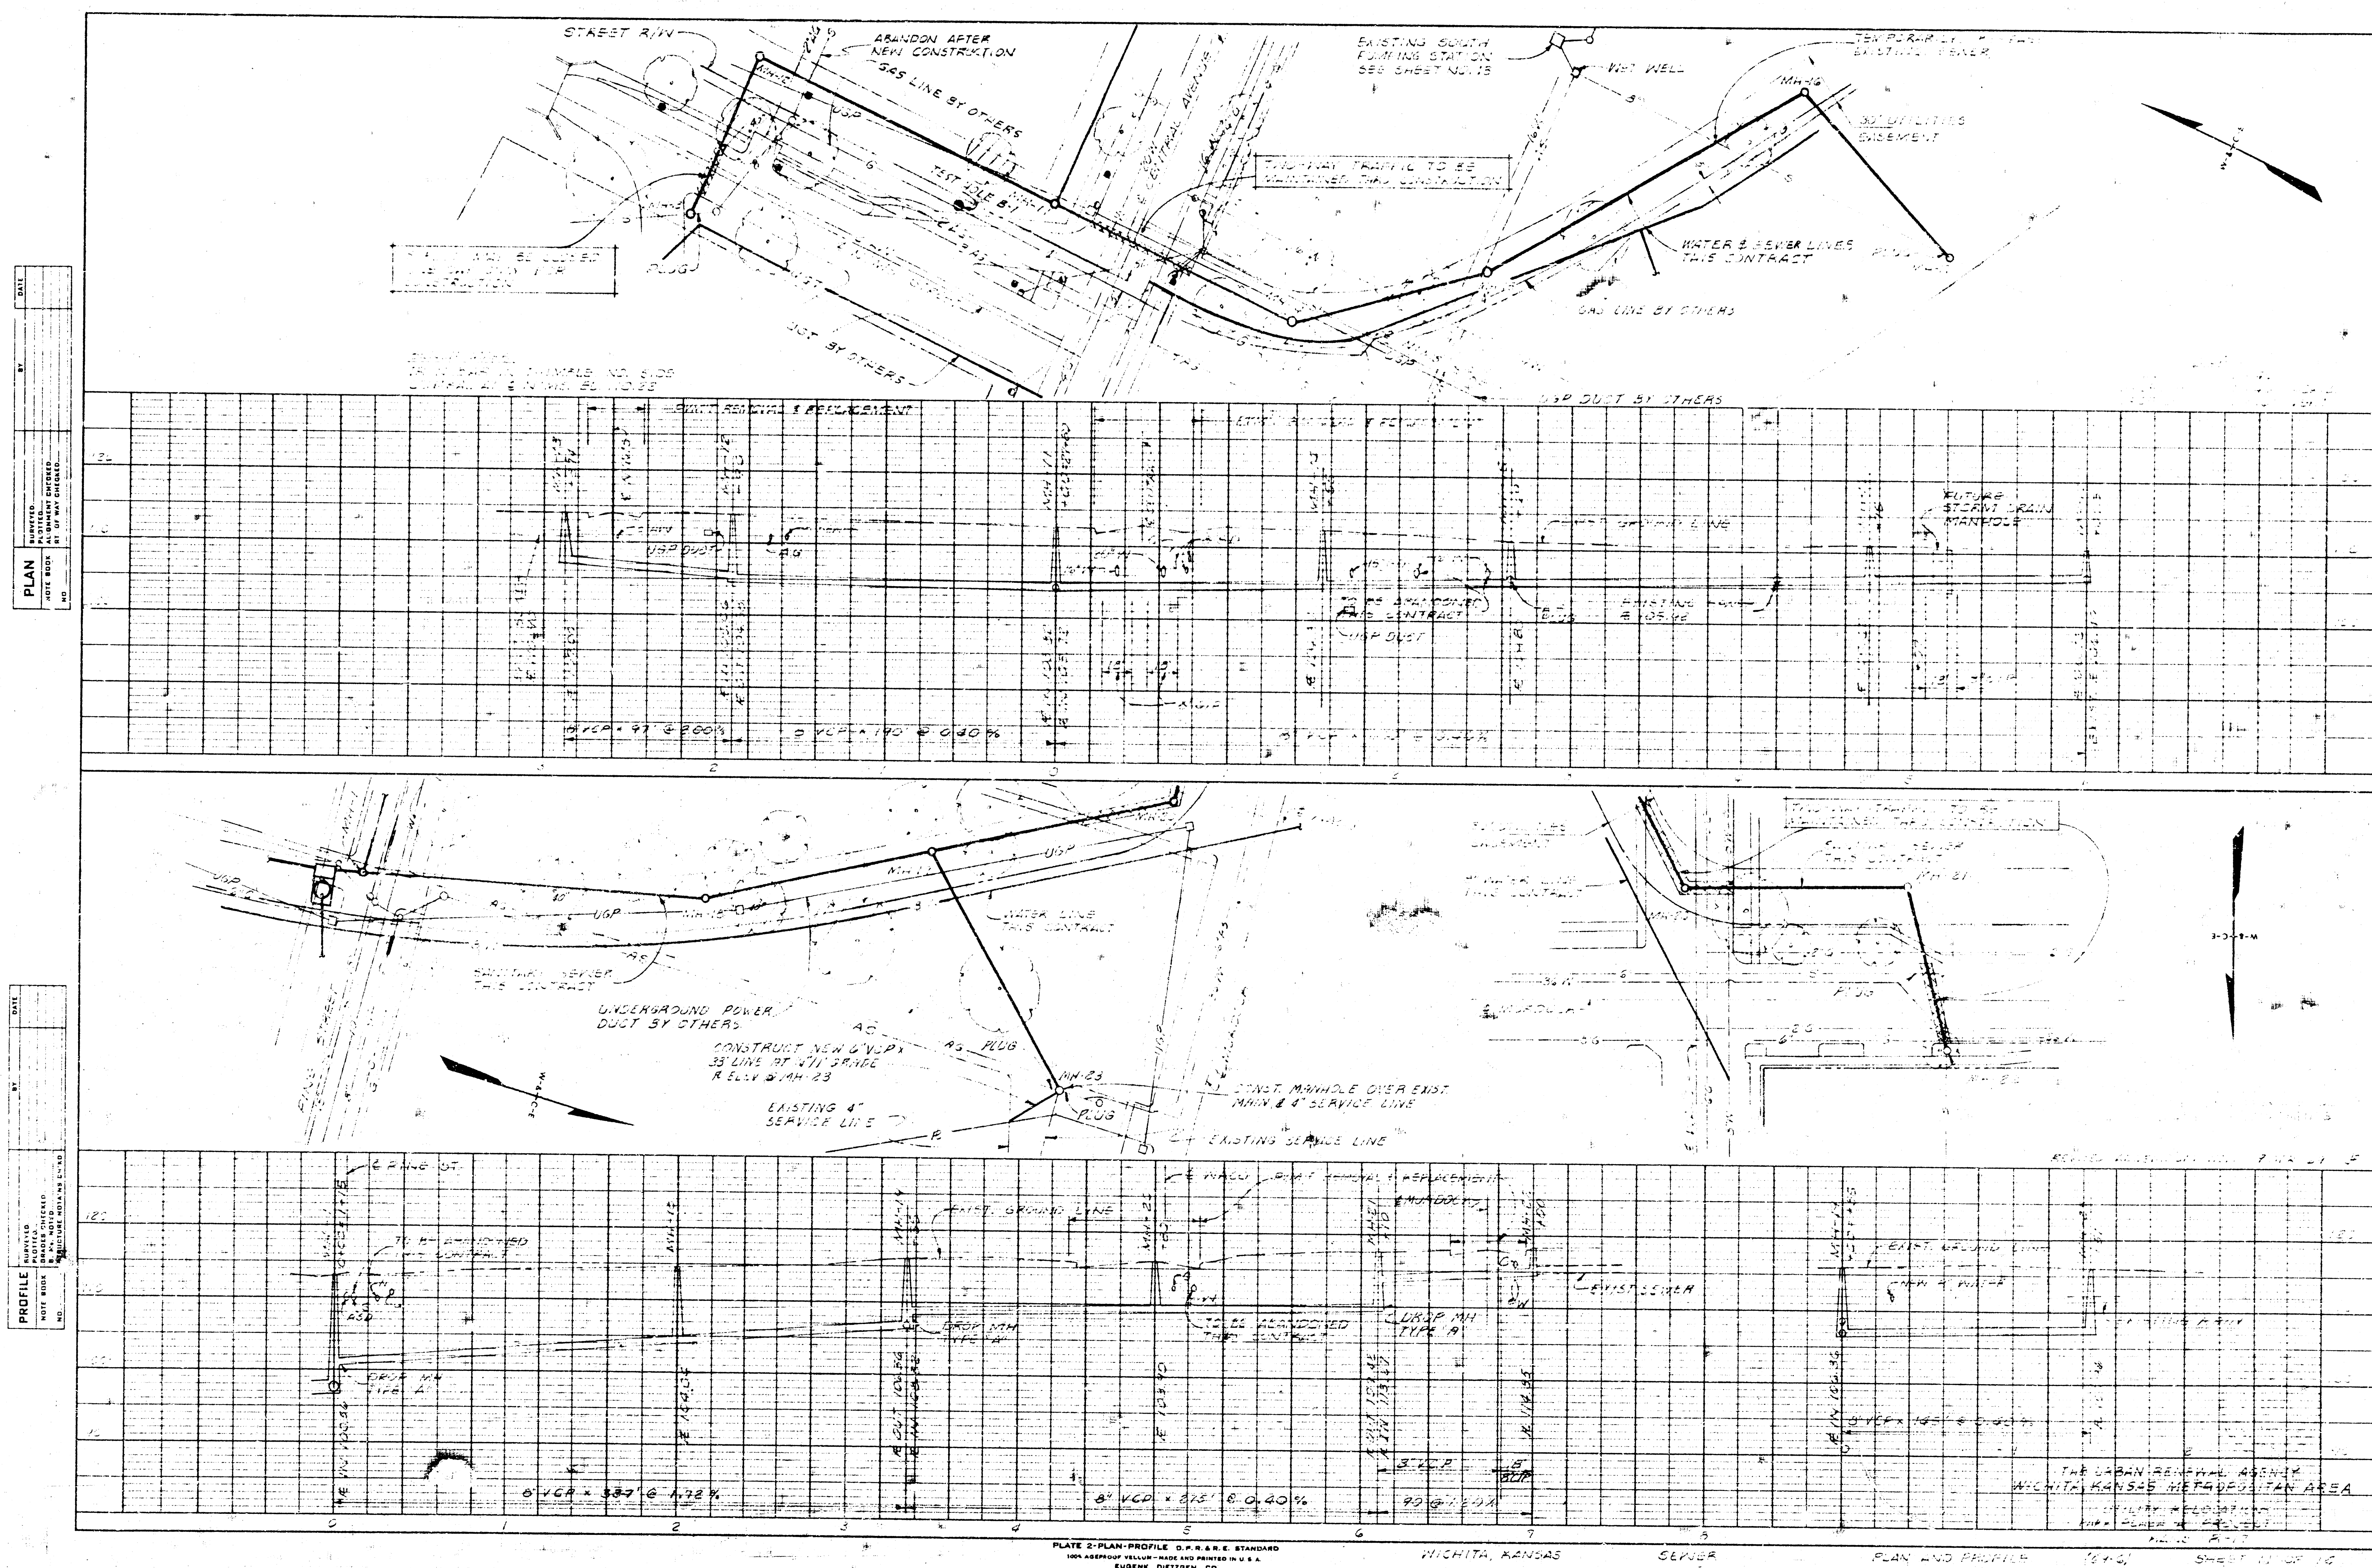

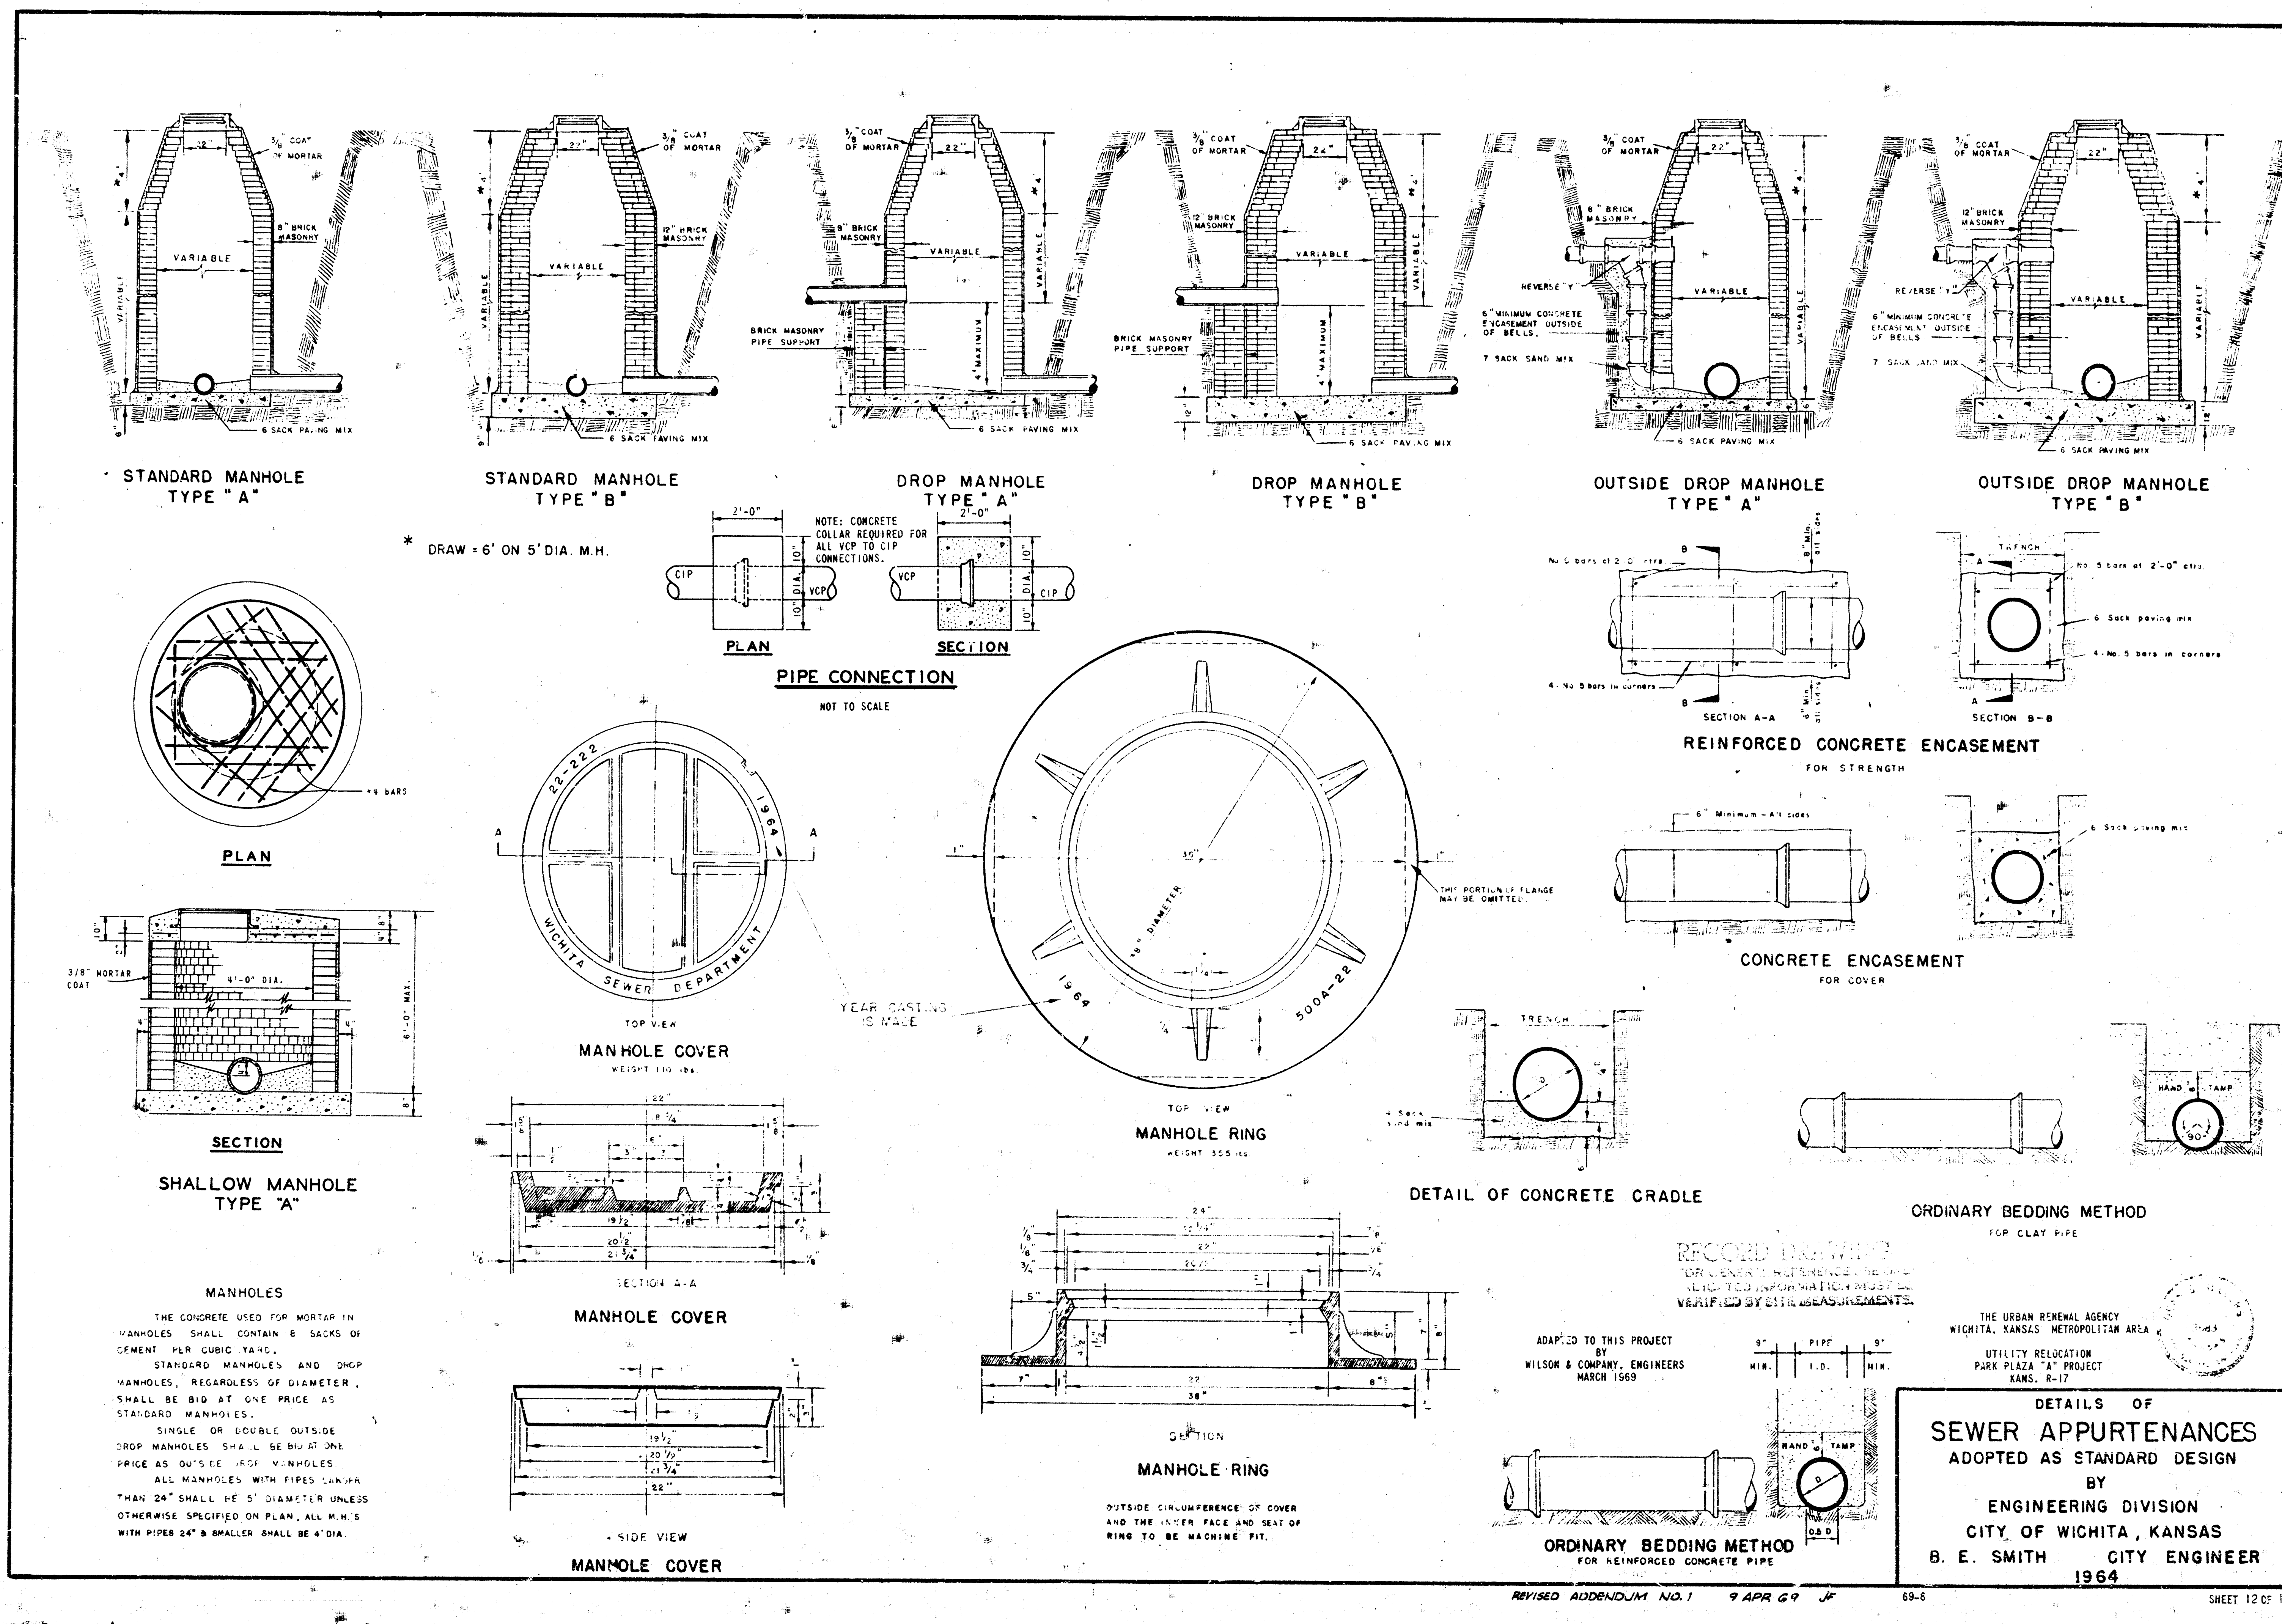

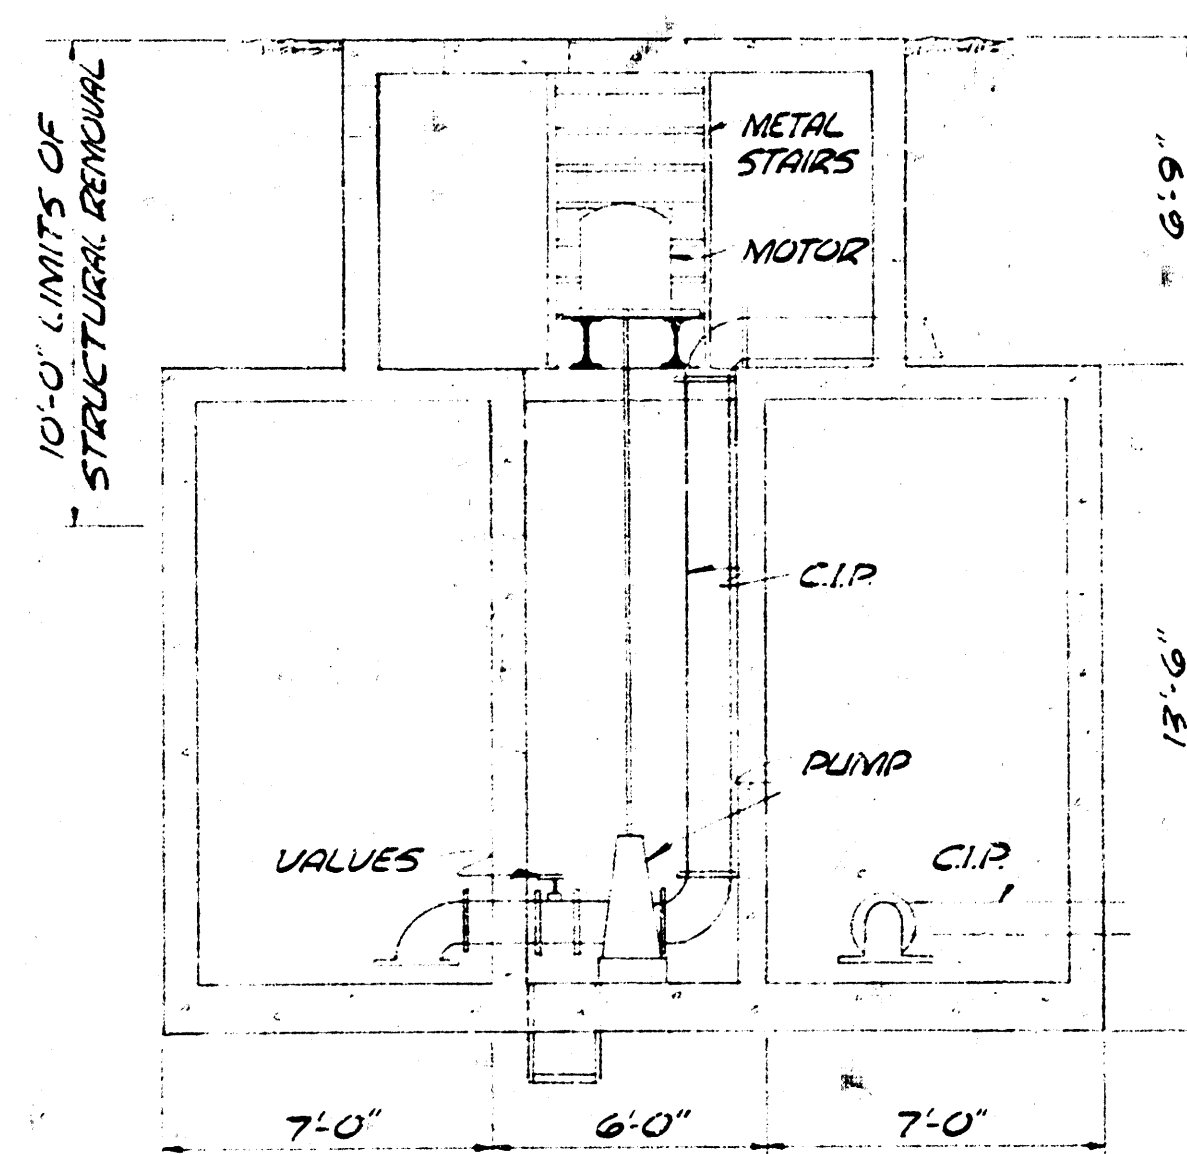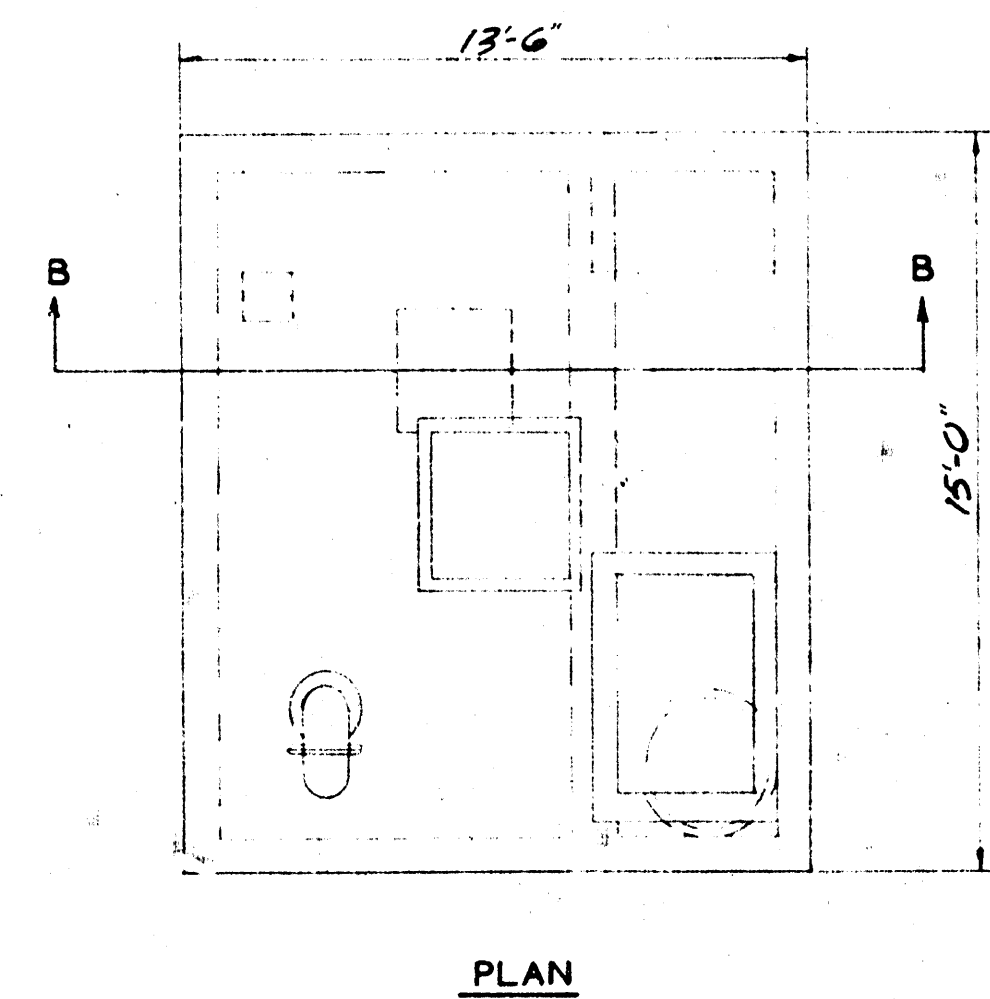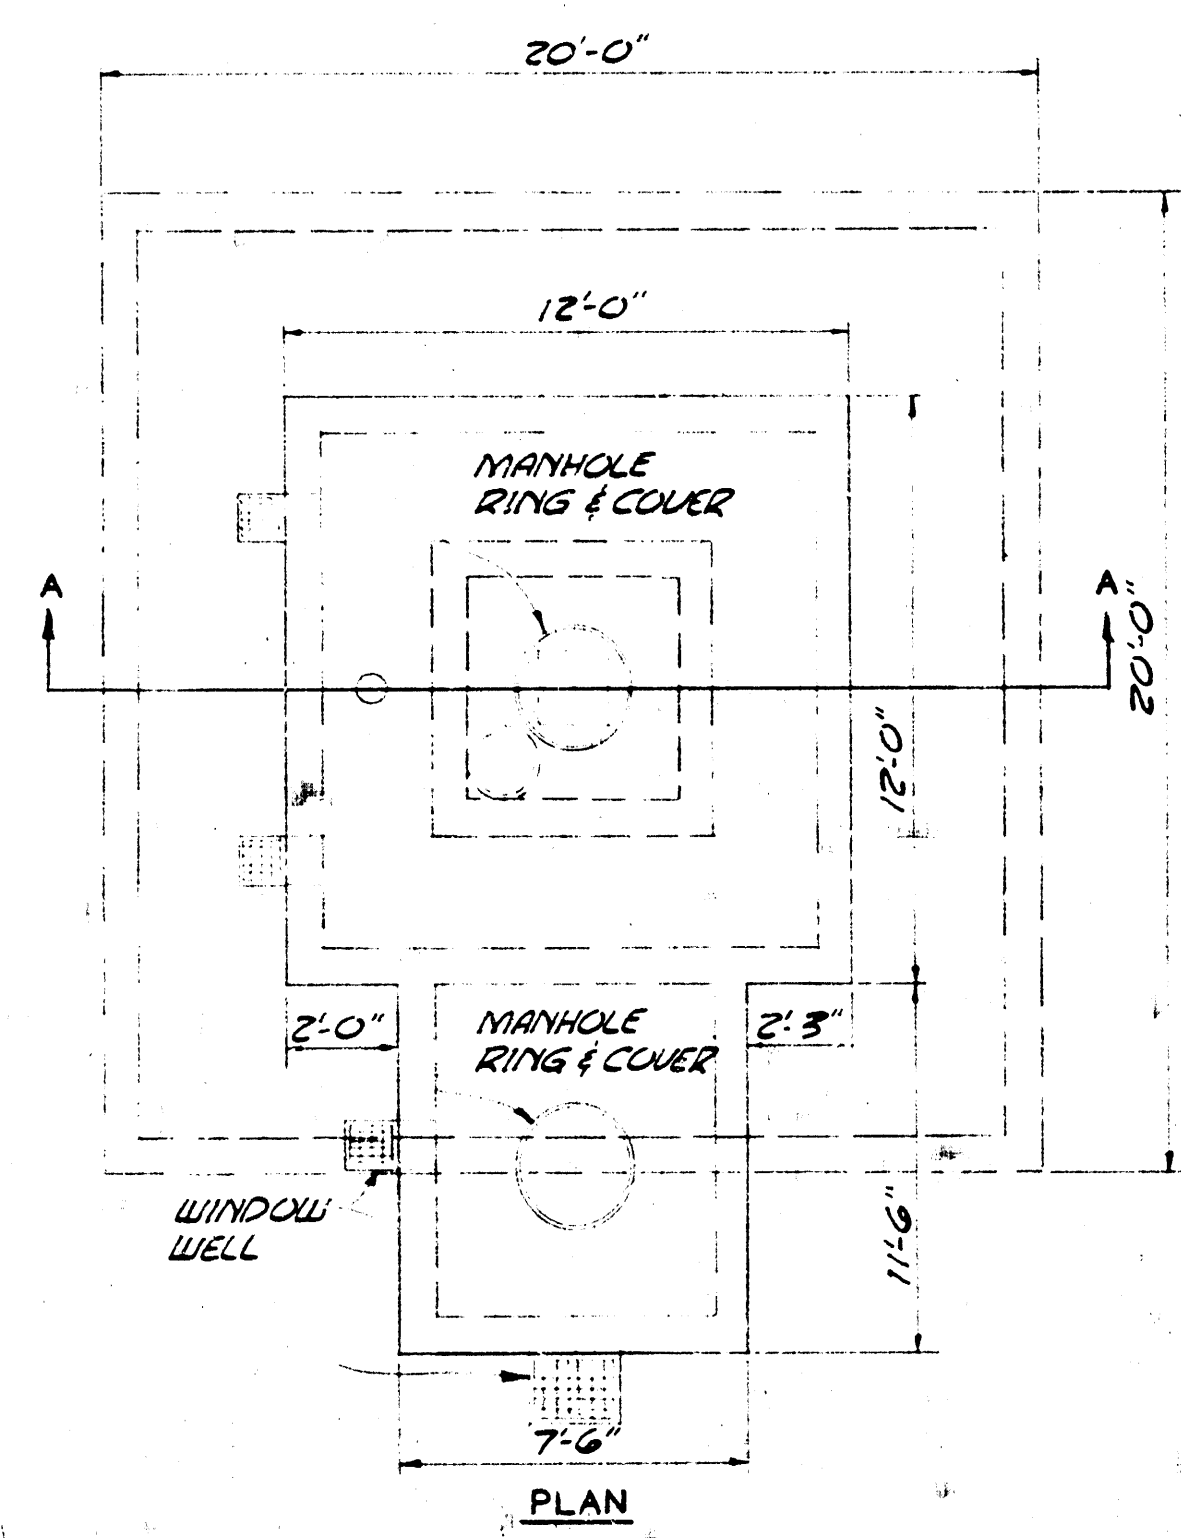


SECTION A-A
WEST PART

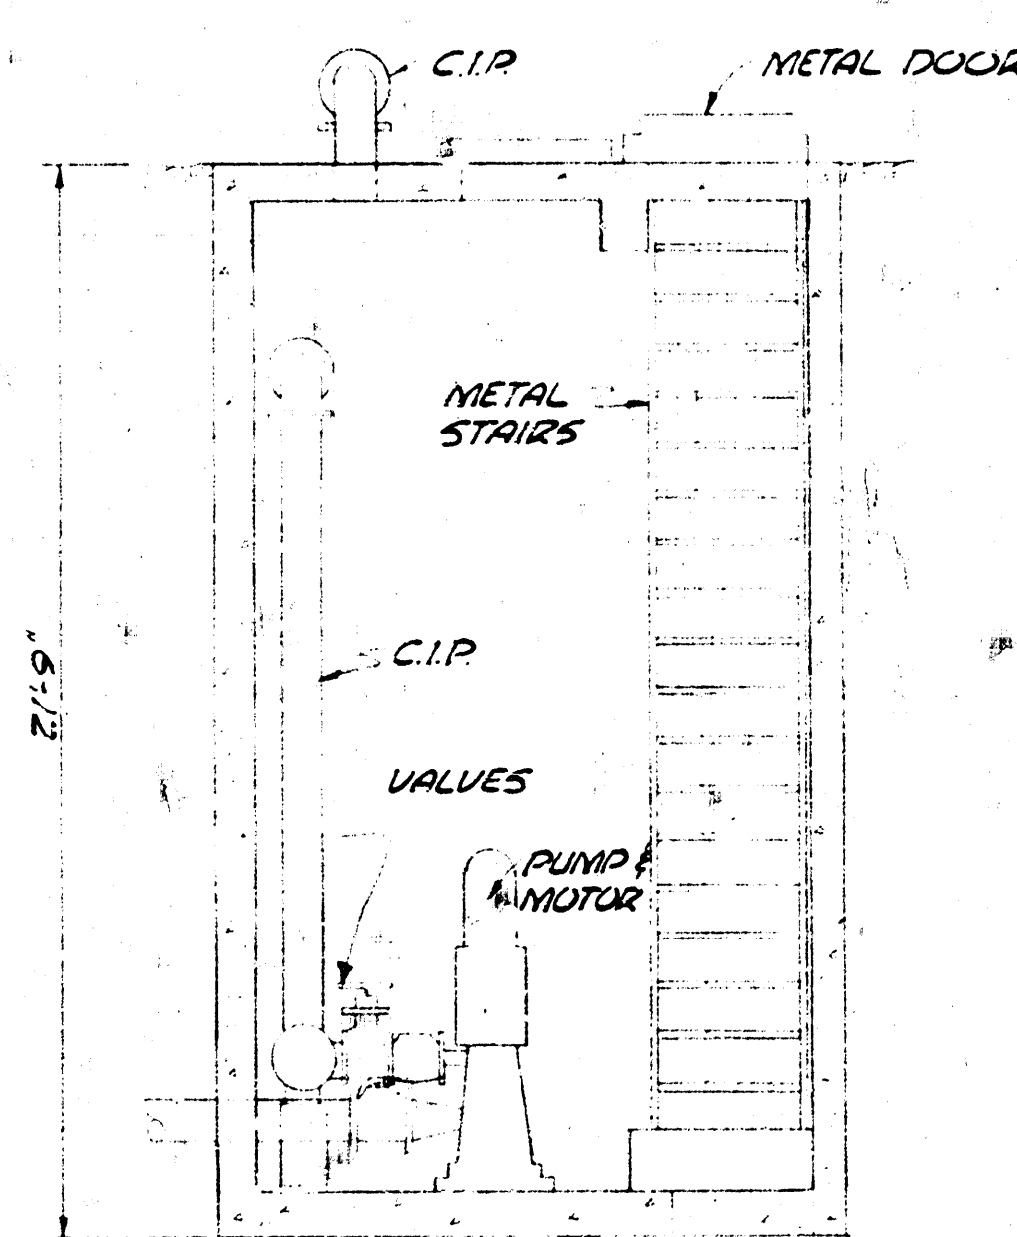


SECTION B-B
EAST PART

NORTH PUMPING STATION
NOT TO SCALE
FOR DEMOLITION

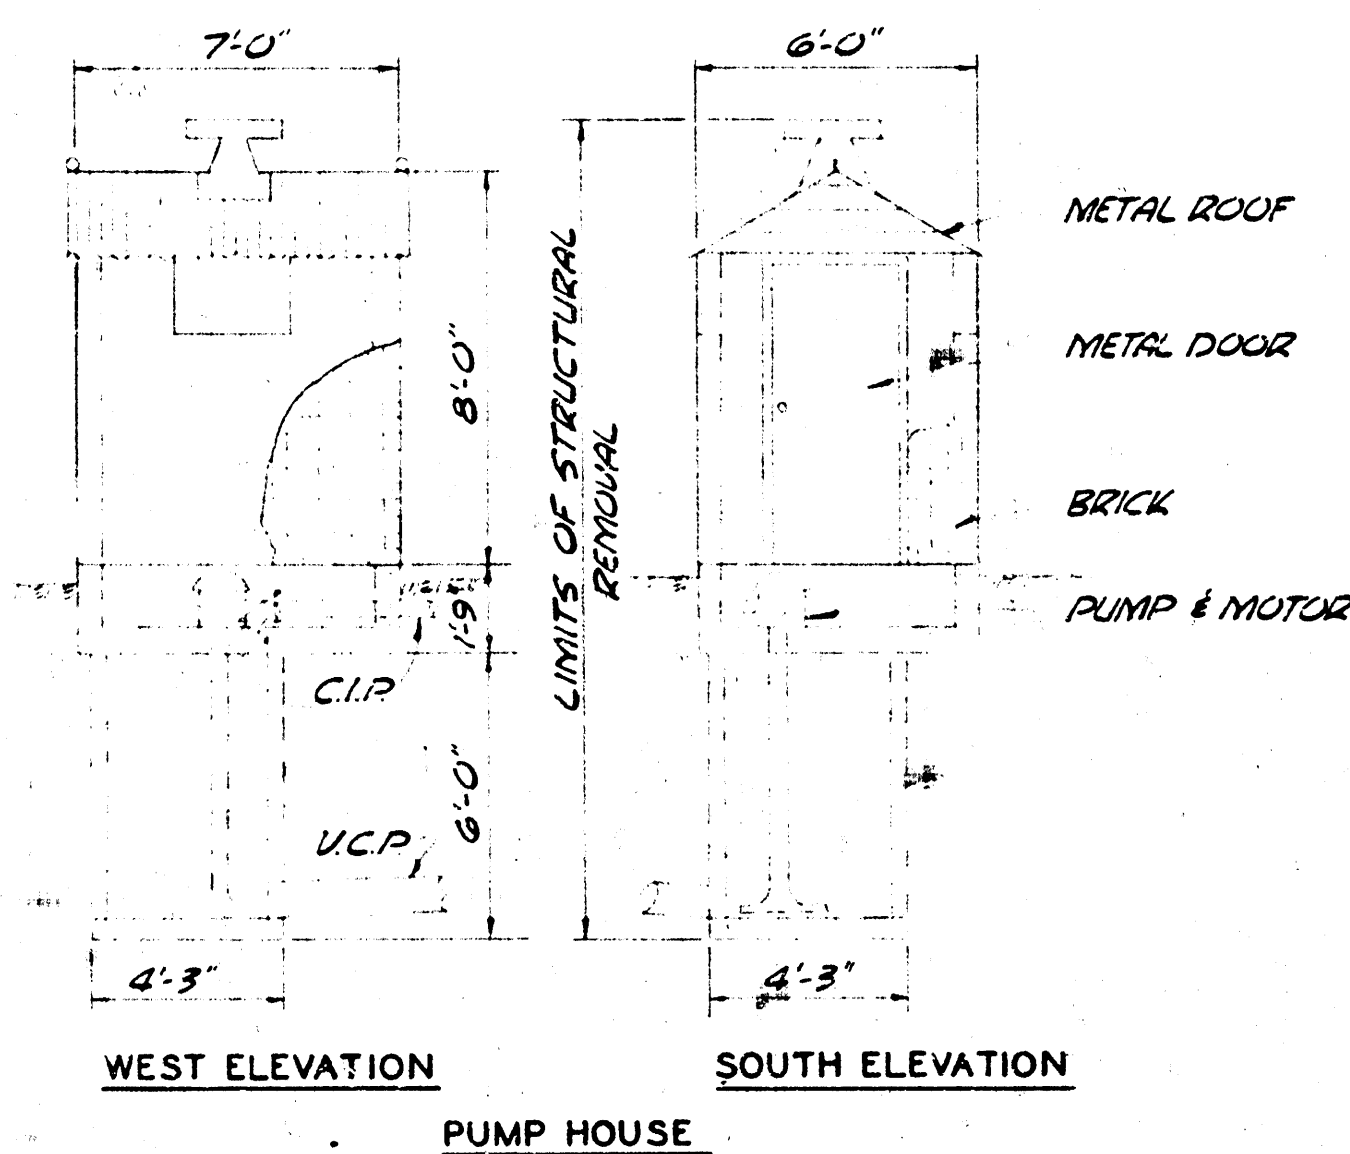

WEST ELEVATION SOUTH ELEVATION
PUMP HOUSE

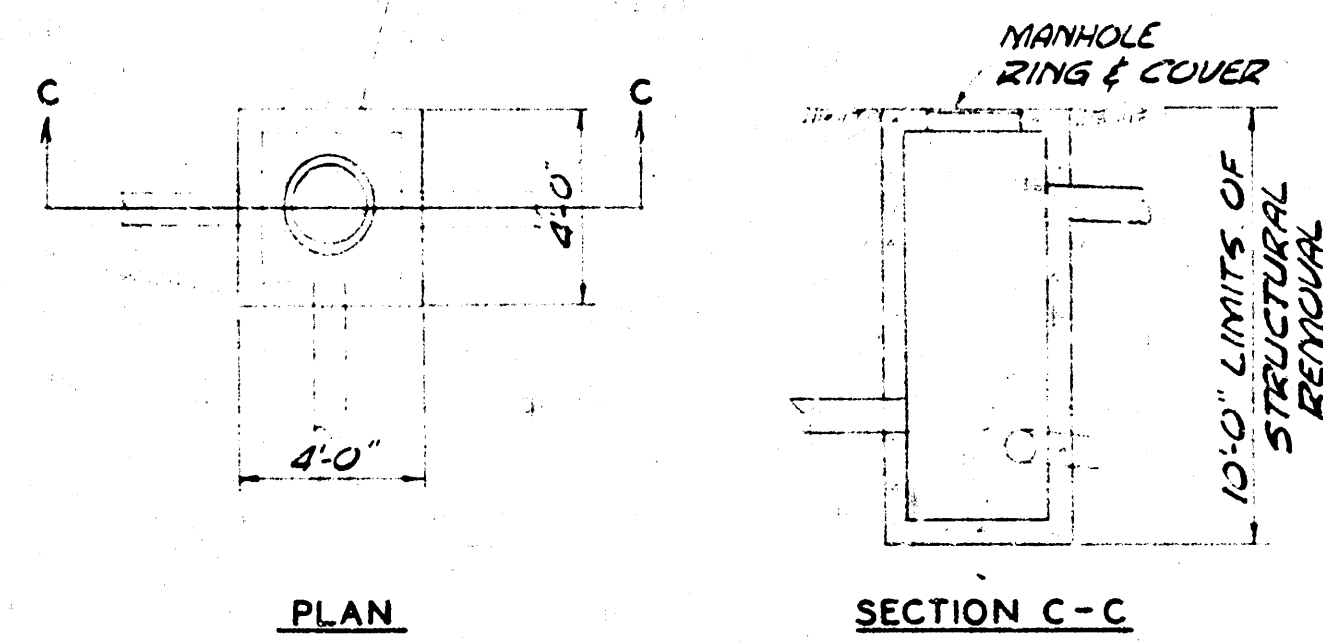

PLAN SECTION C-C
WET WELL
SOUTH PUMPING STATION
NOT TO SCALE
FOR DEMOLITION

NOTE: ALL DIMENSIONS SHOWN
ARE APPROXIMATE.

REVISION	DATE	BY

THE URBAN RENOVATION AGENCY WICHITA, KANSAS METROPOLITAN AREA UTILITY RELOCATIONS PARK PLAZA 1ST PROJECT KANS. R-17 SEWER DETAILS	
DESIGN	DATE: MARCH 1969
DRAWN	FILE NO. 69-8
WILSON & COMPANY ENGINEERS & ARCHITECTS WICHITA — KANSAS	
SHEET NO. 12 OF 14	

