


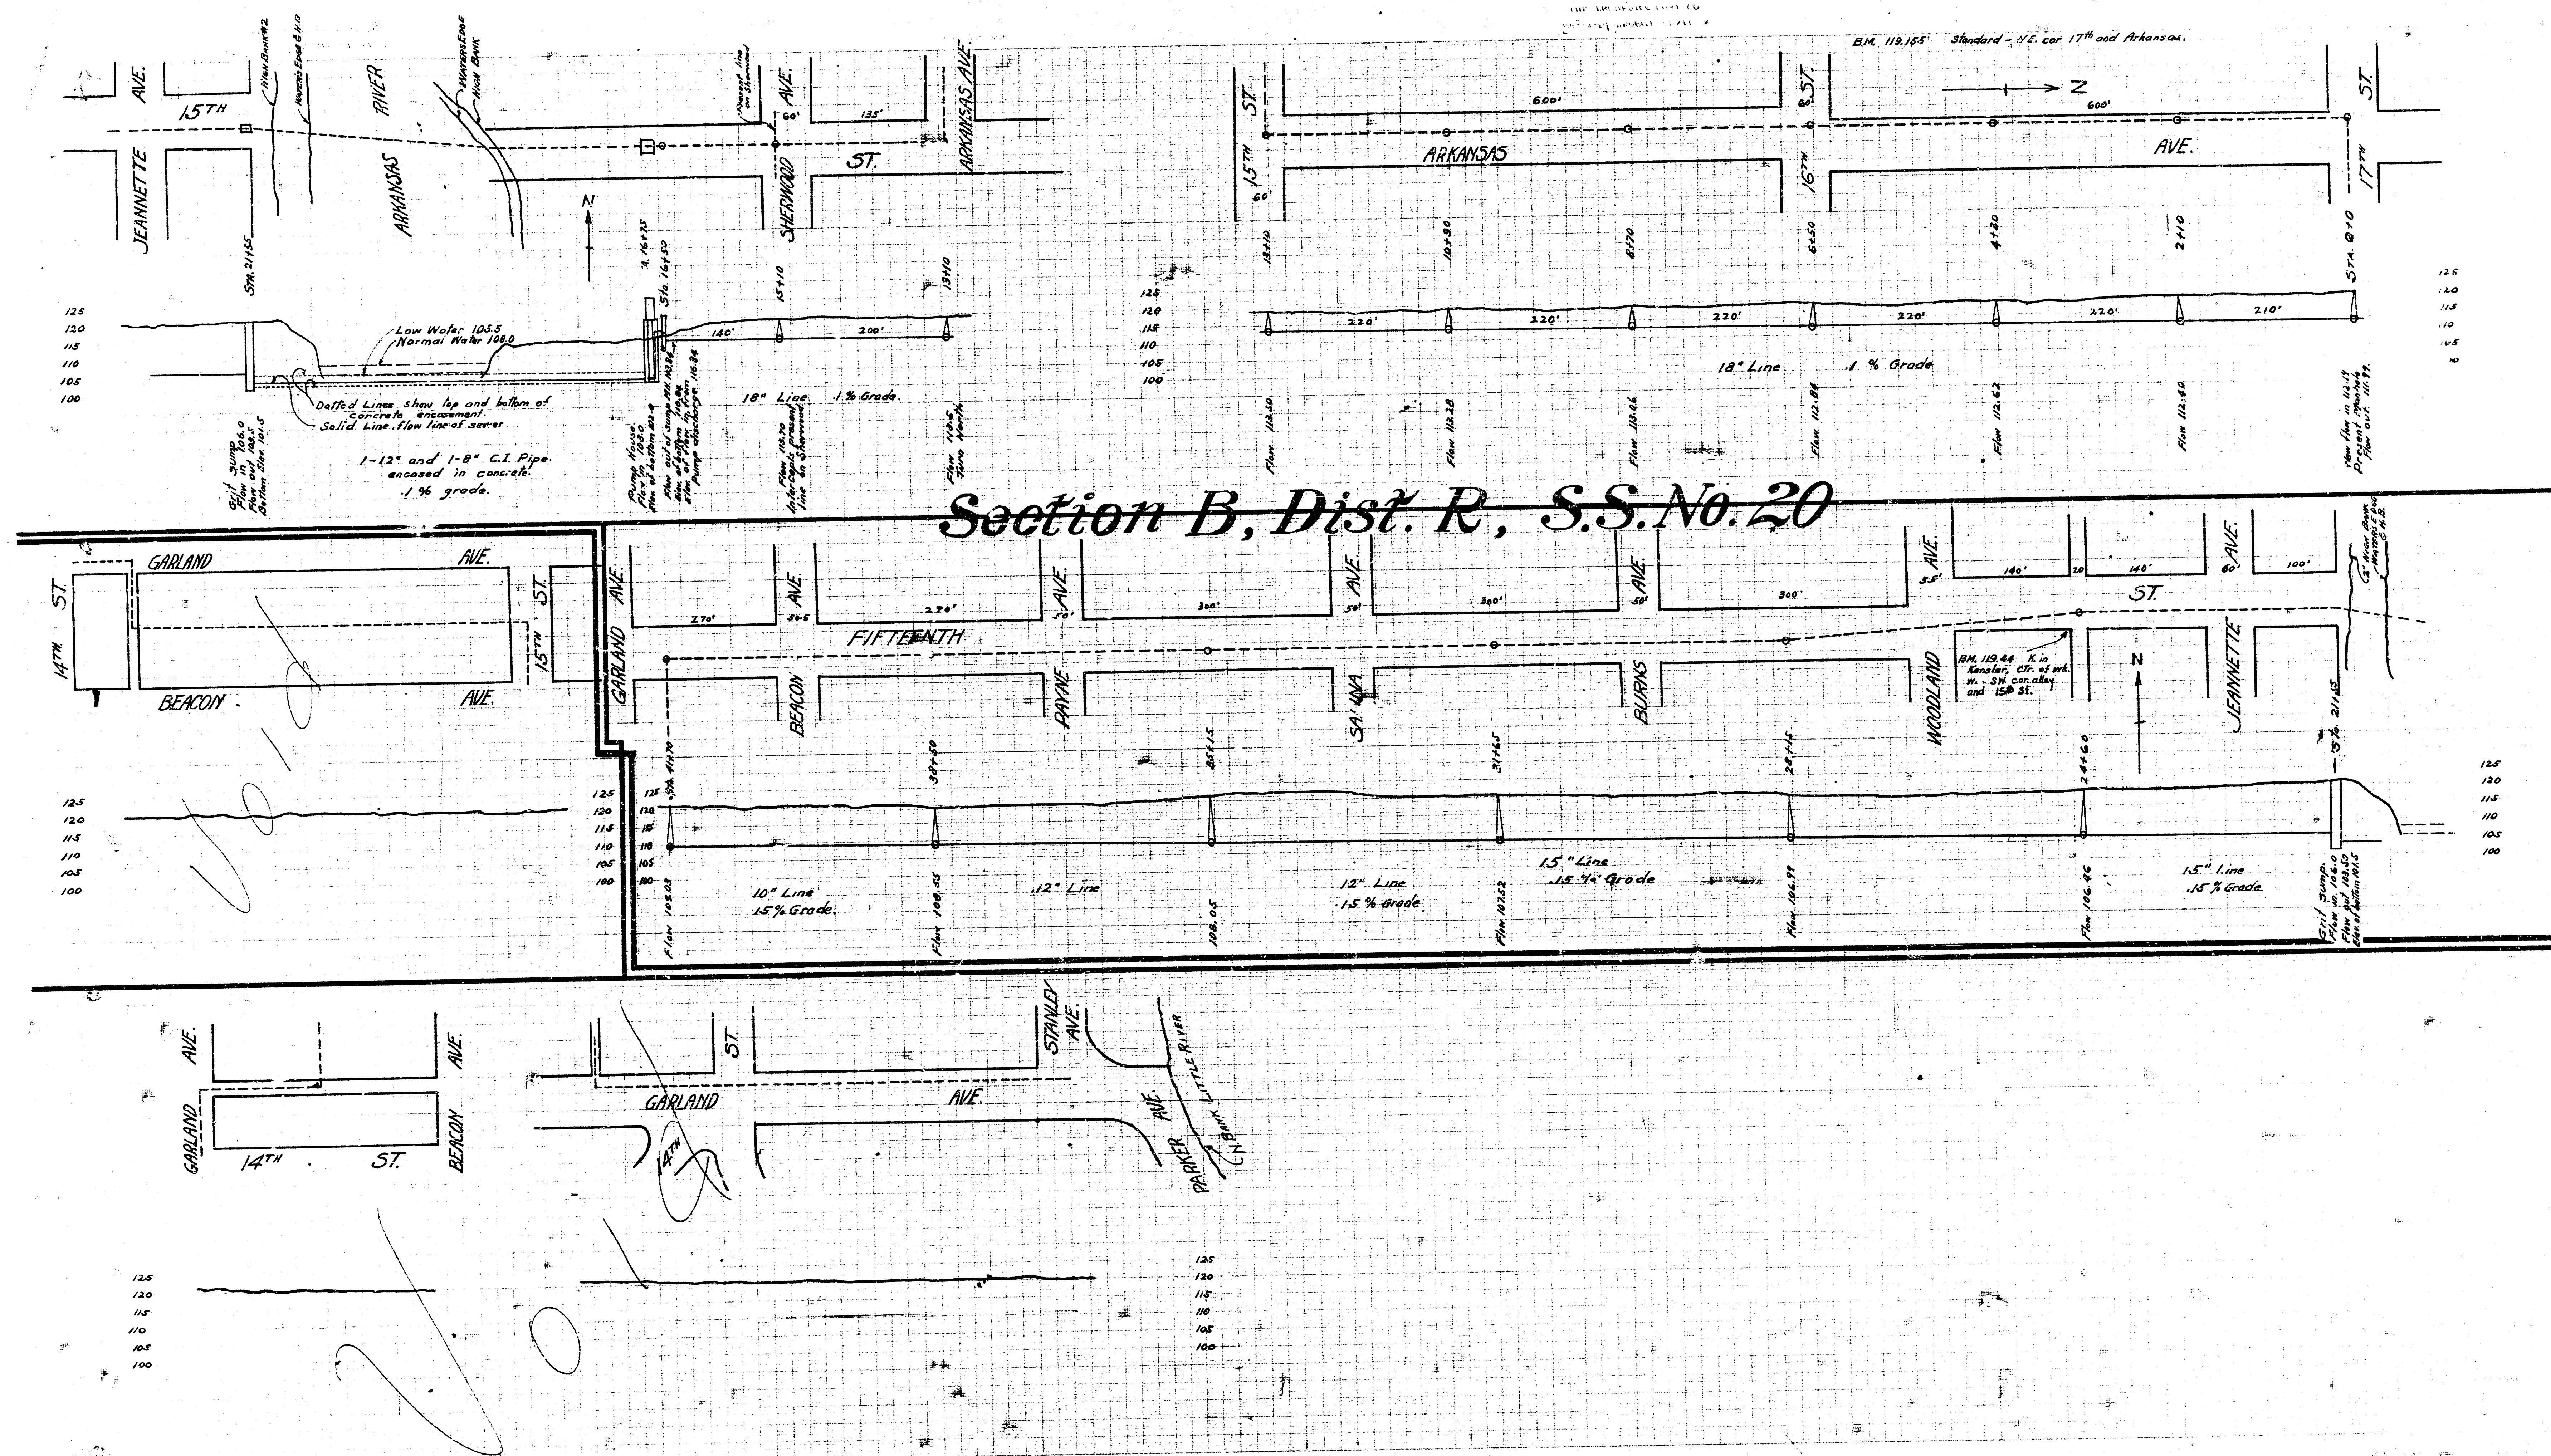


[illegible]


Typical Door Section


Section of Doorway
Scale: 1" = 1'-0"


• POWER LAYOUT
SCALE 1/4" = 1'-0"

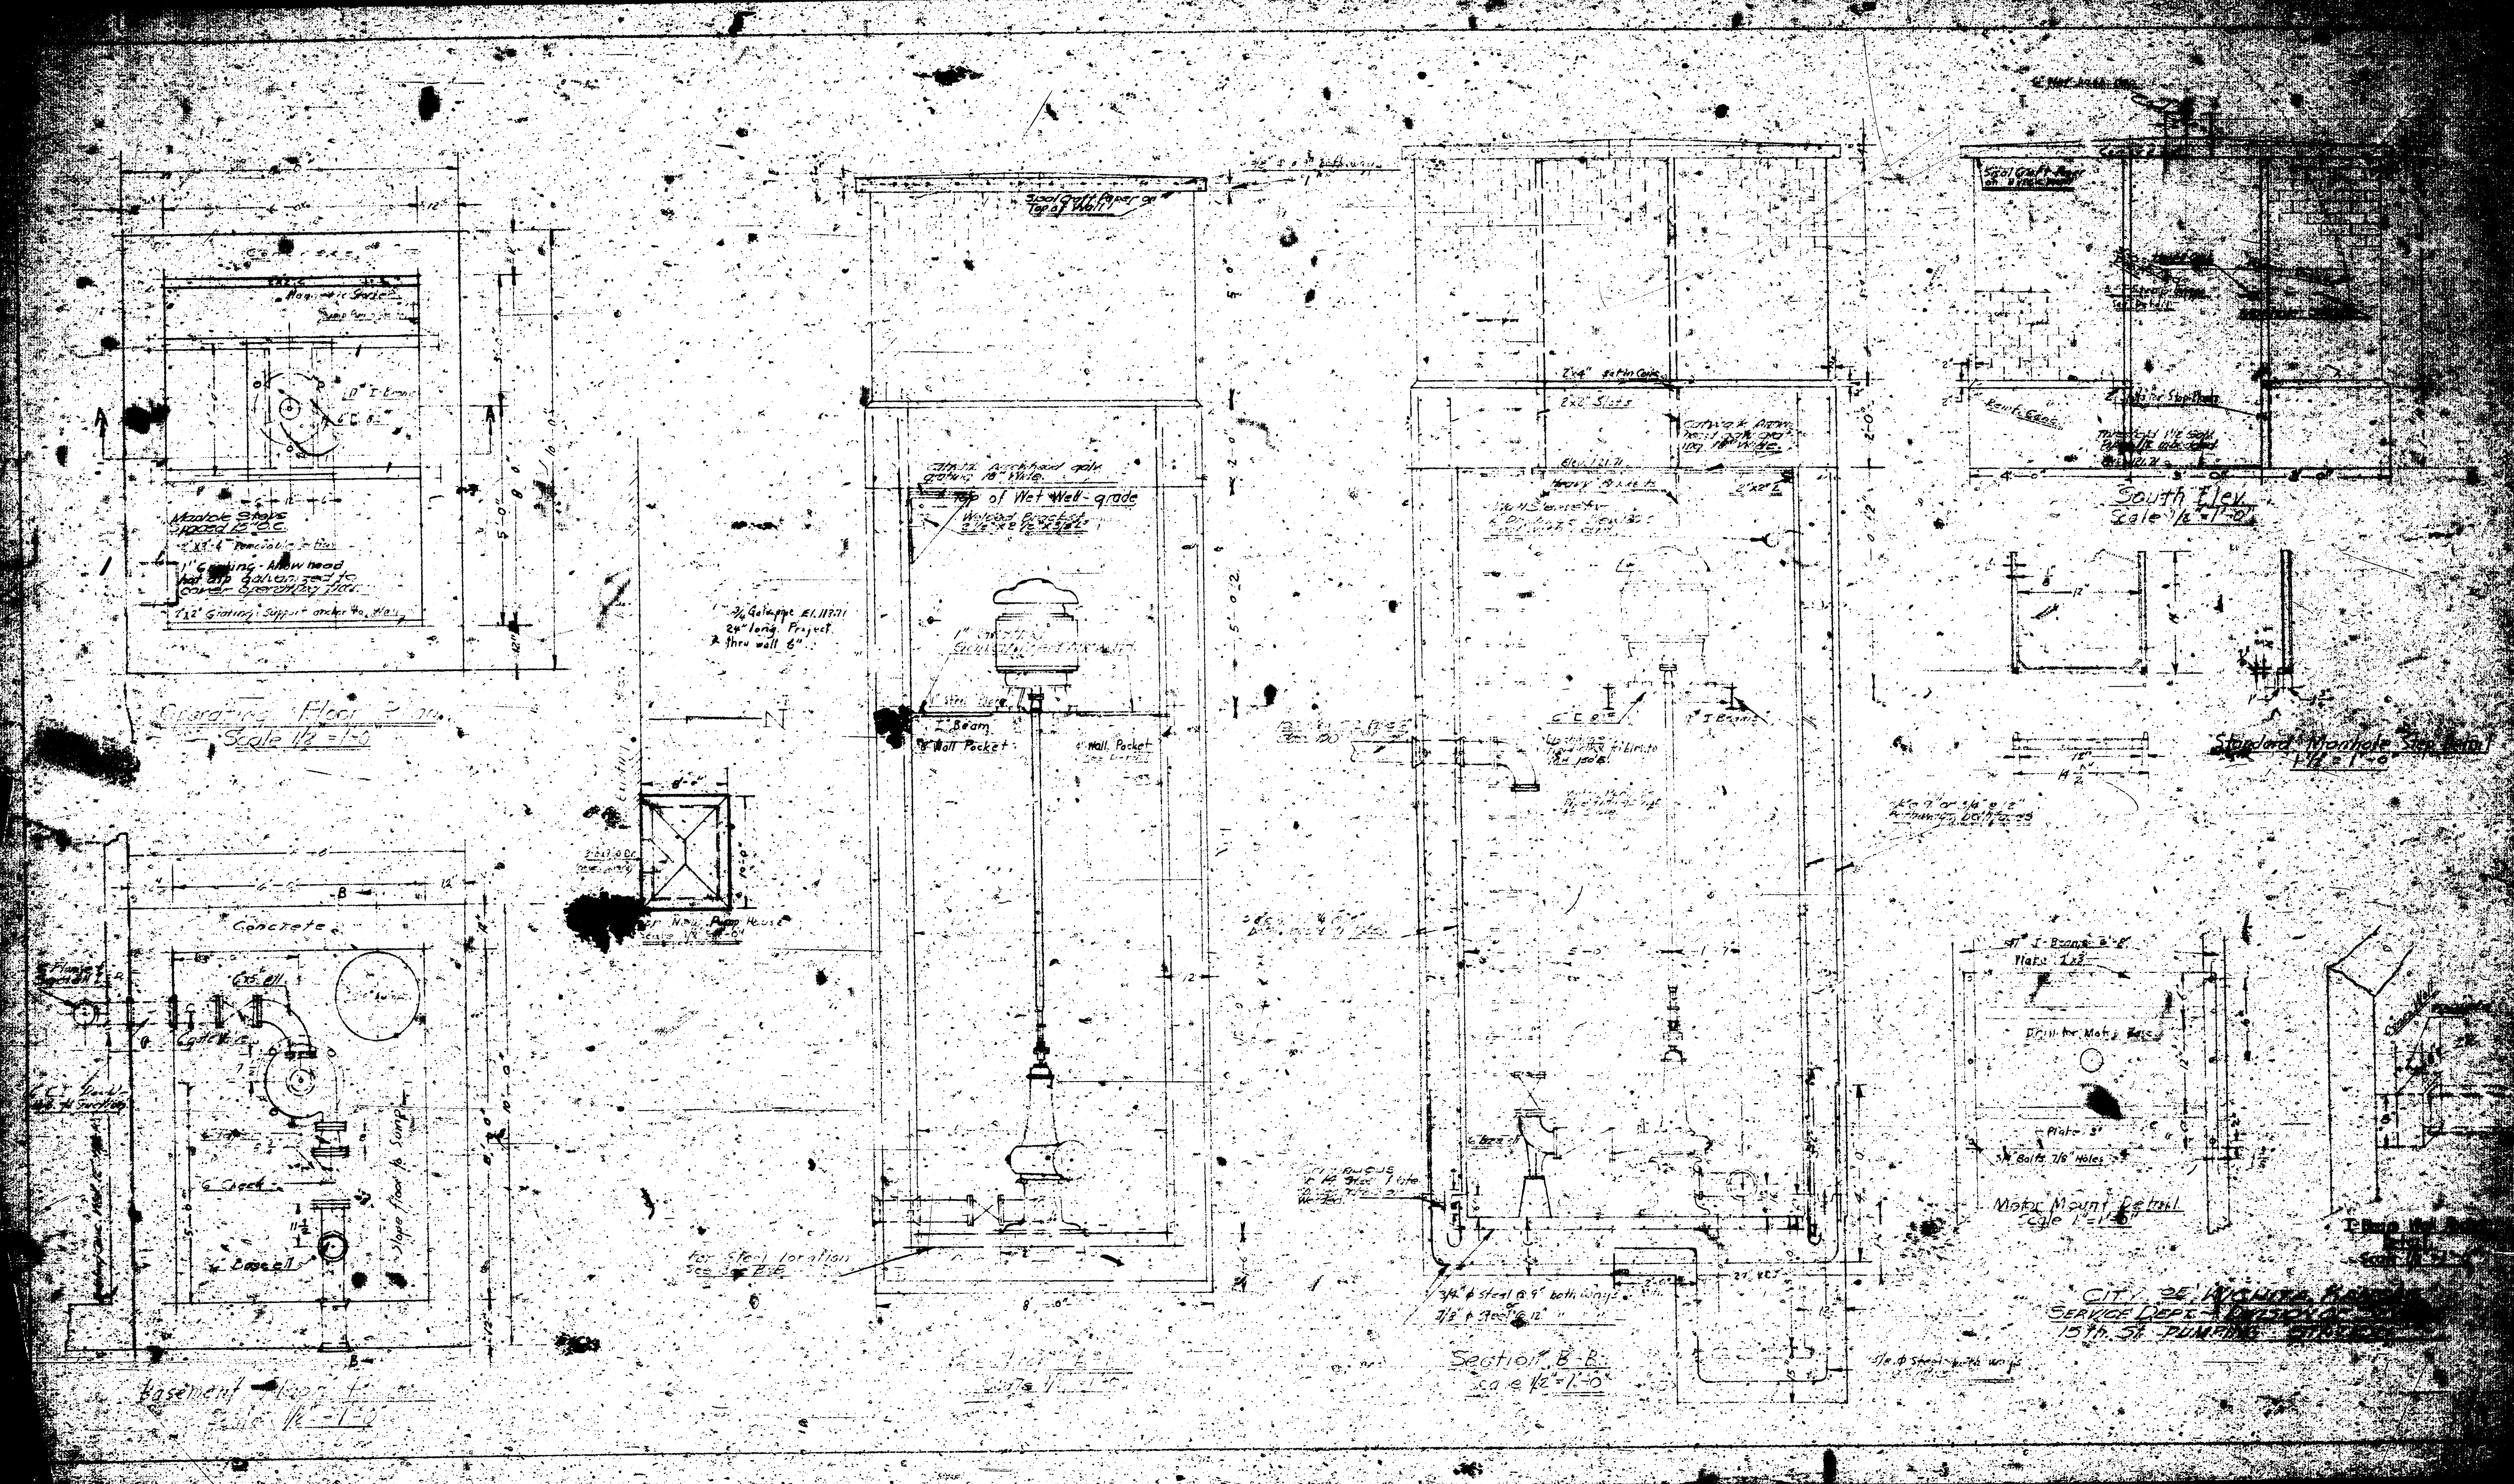


CITY OF WICHITA, KANSAS
SERVICE DEPT. DIVISION OF ENGINEERS
12th ST. PUMPING STATION

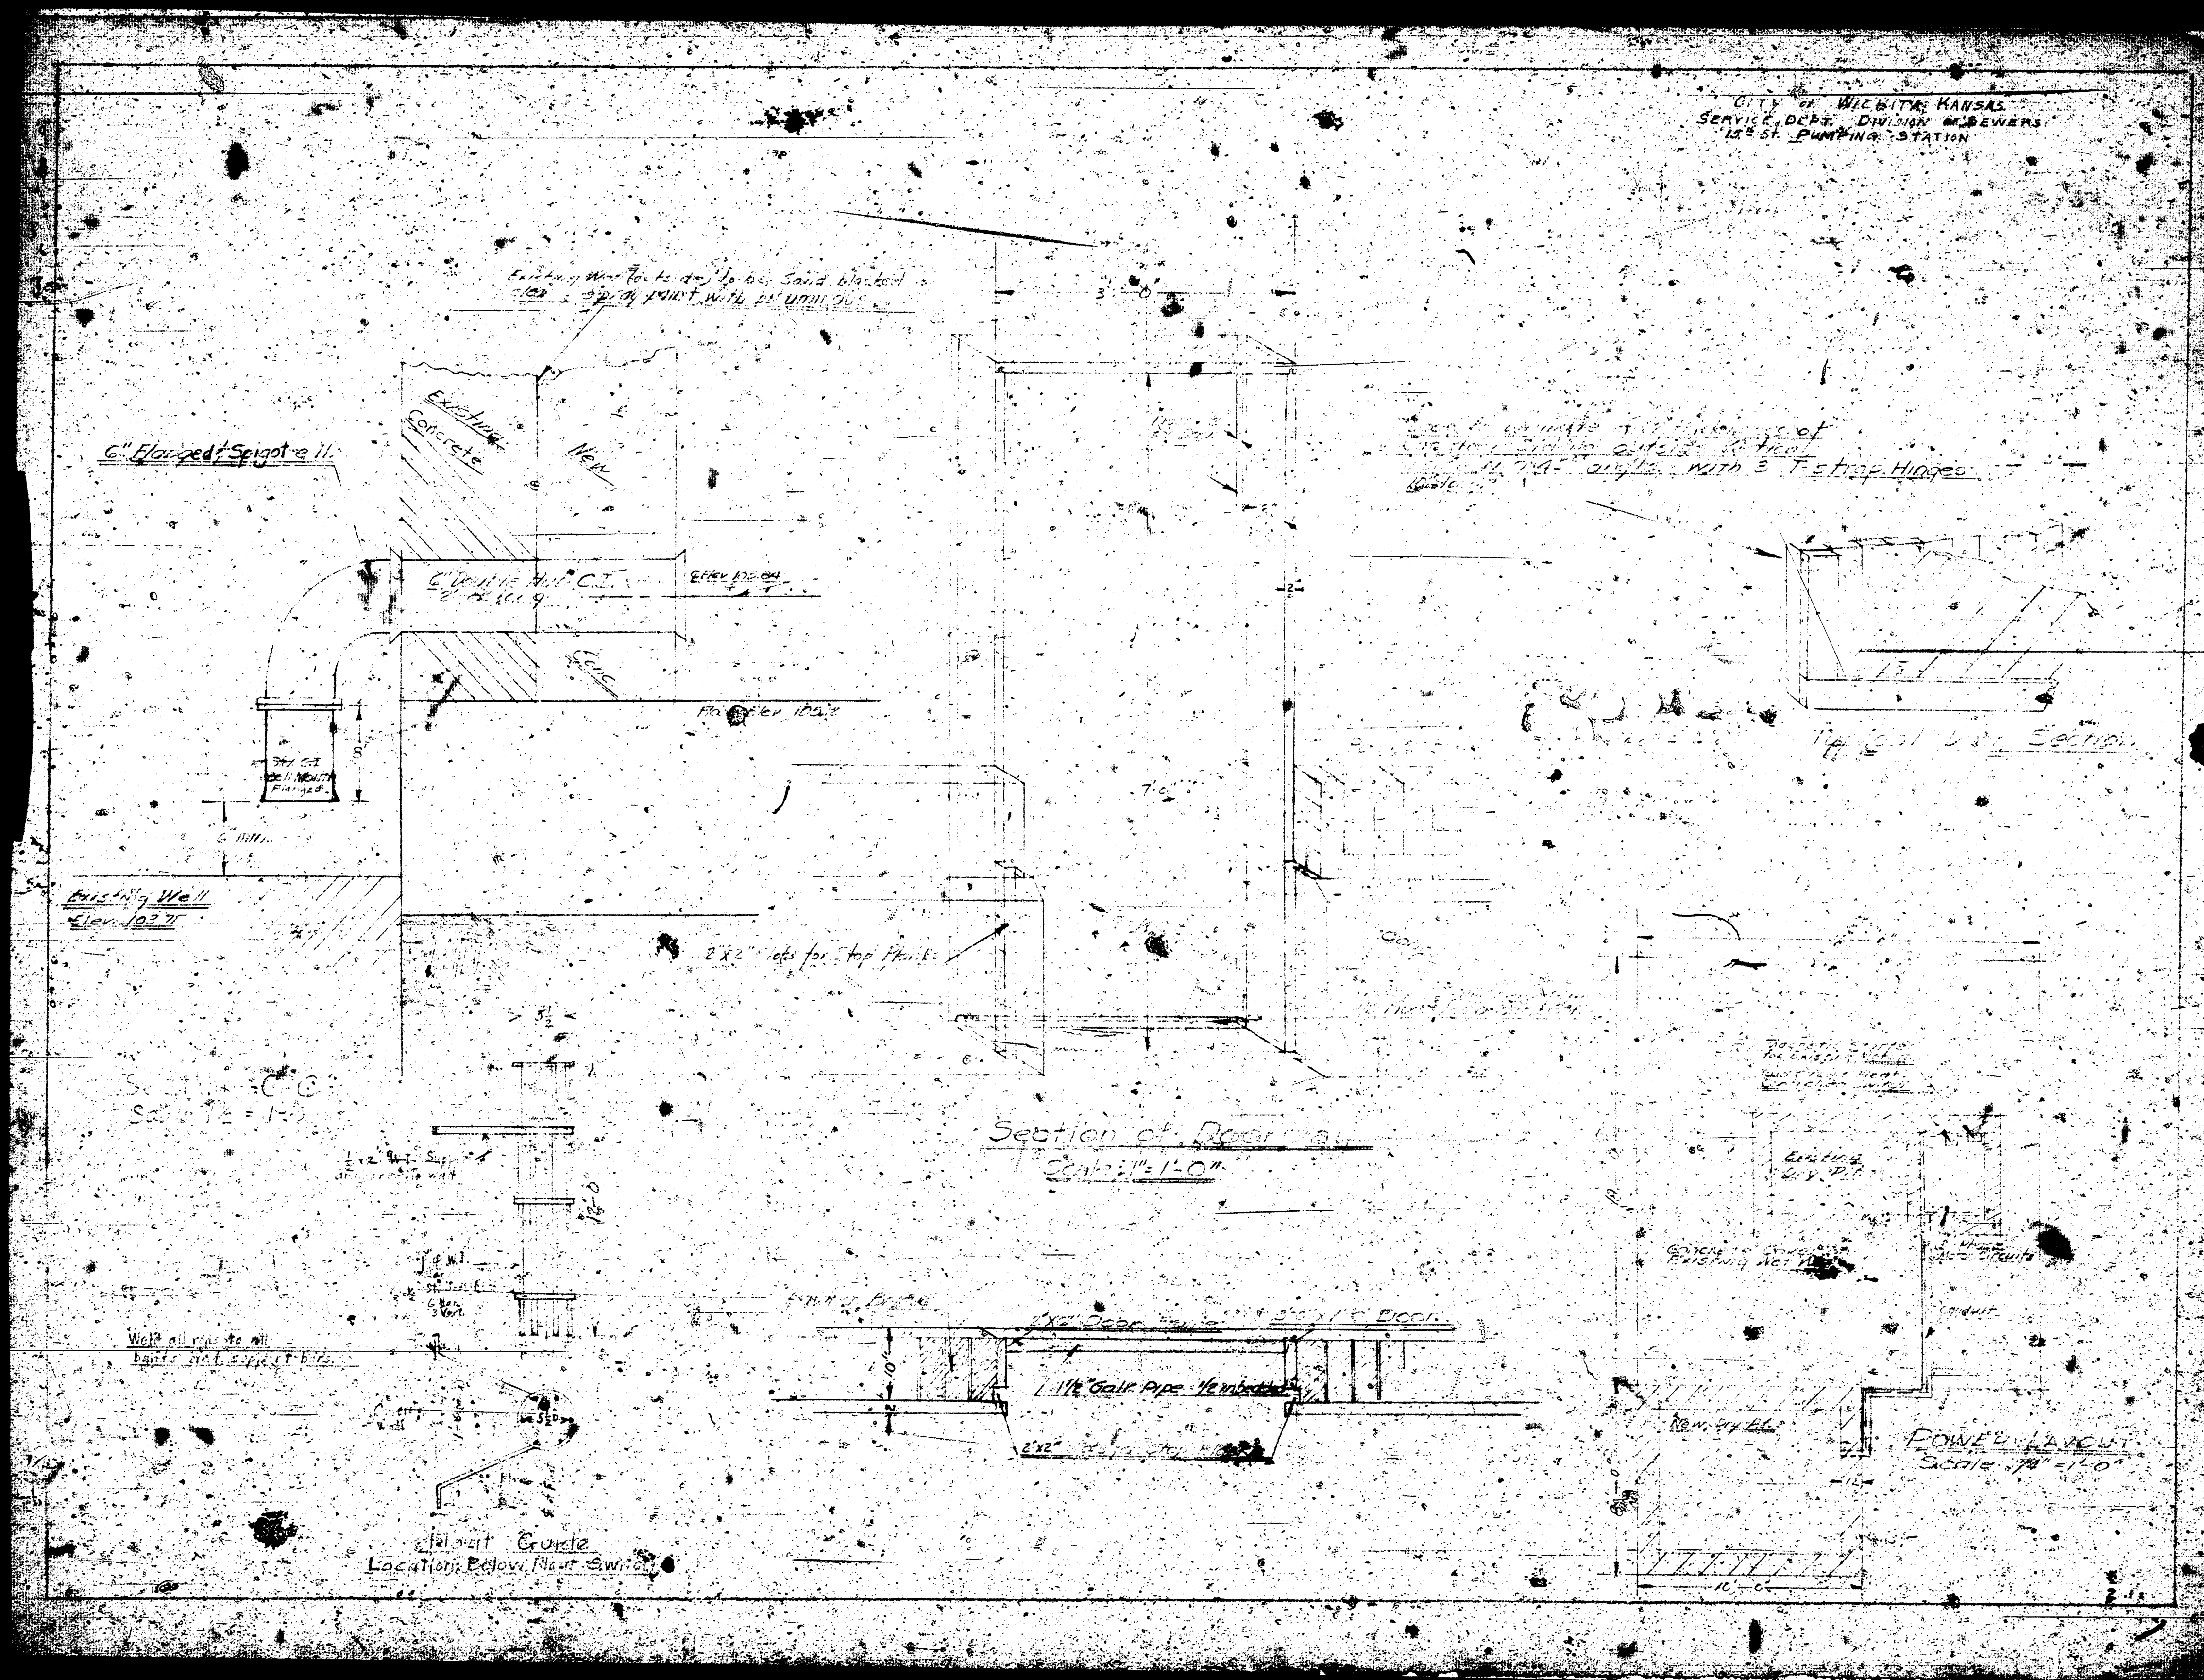

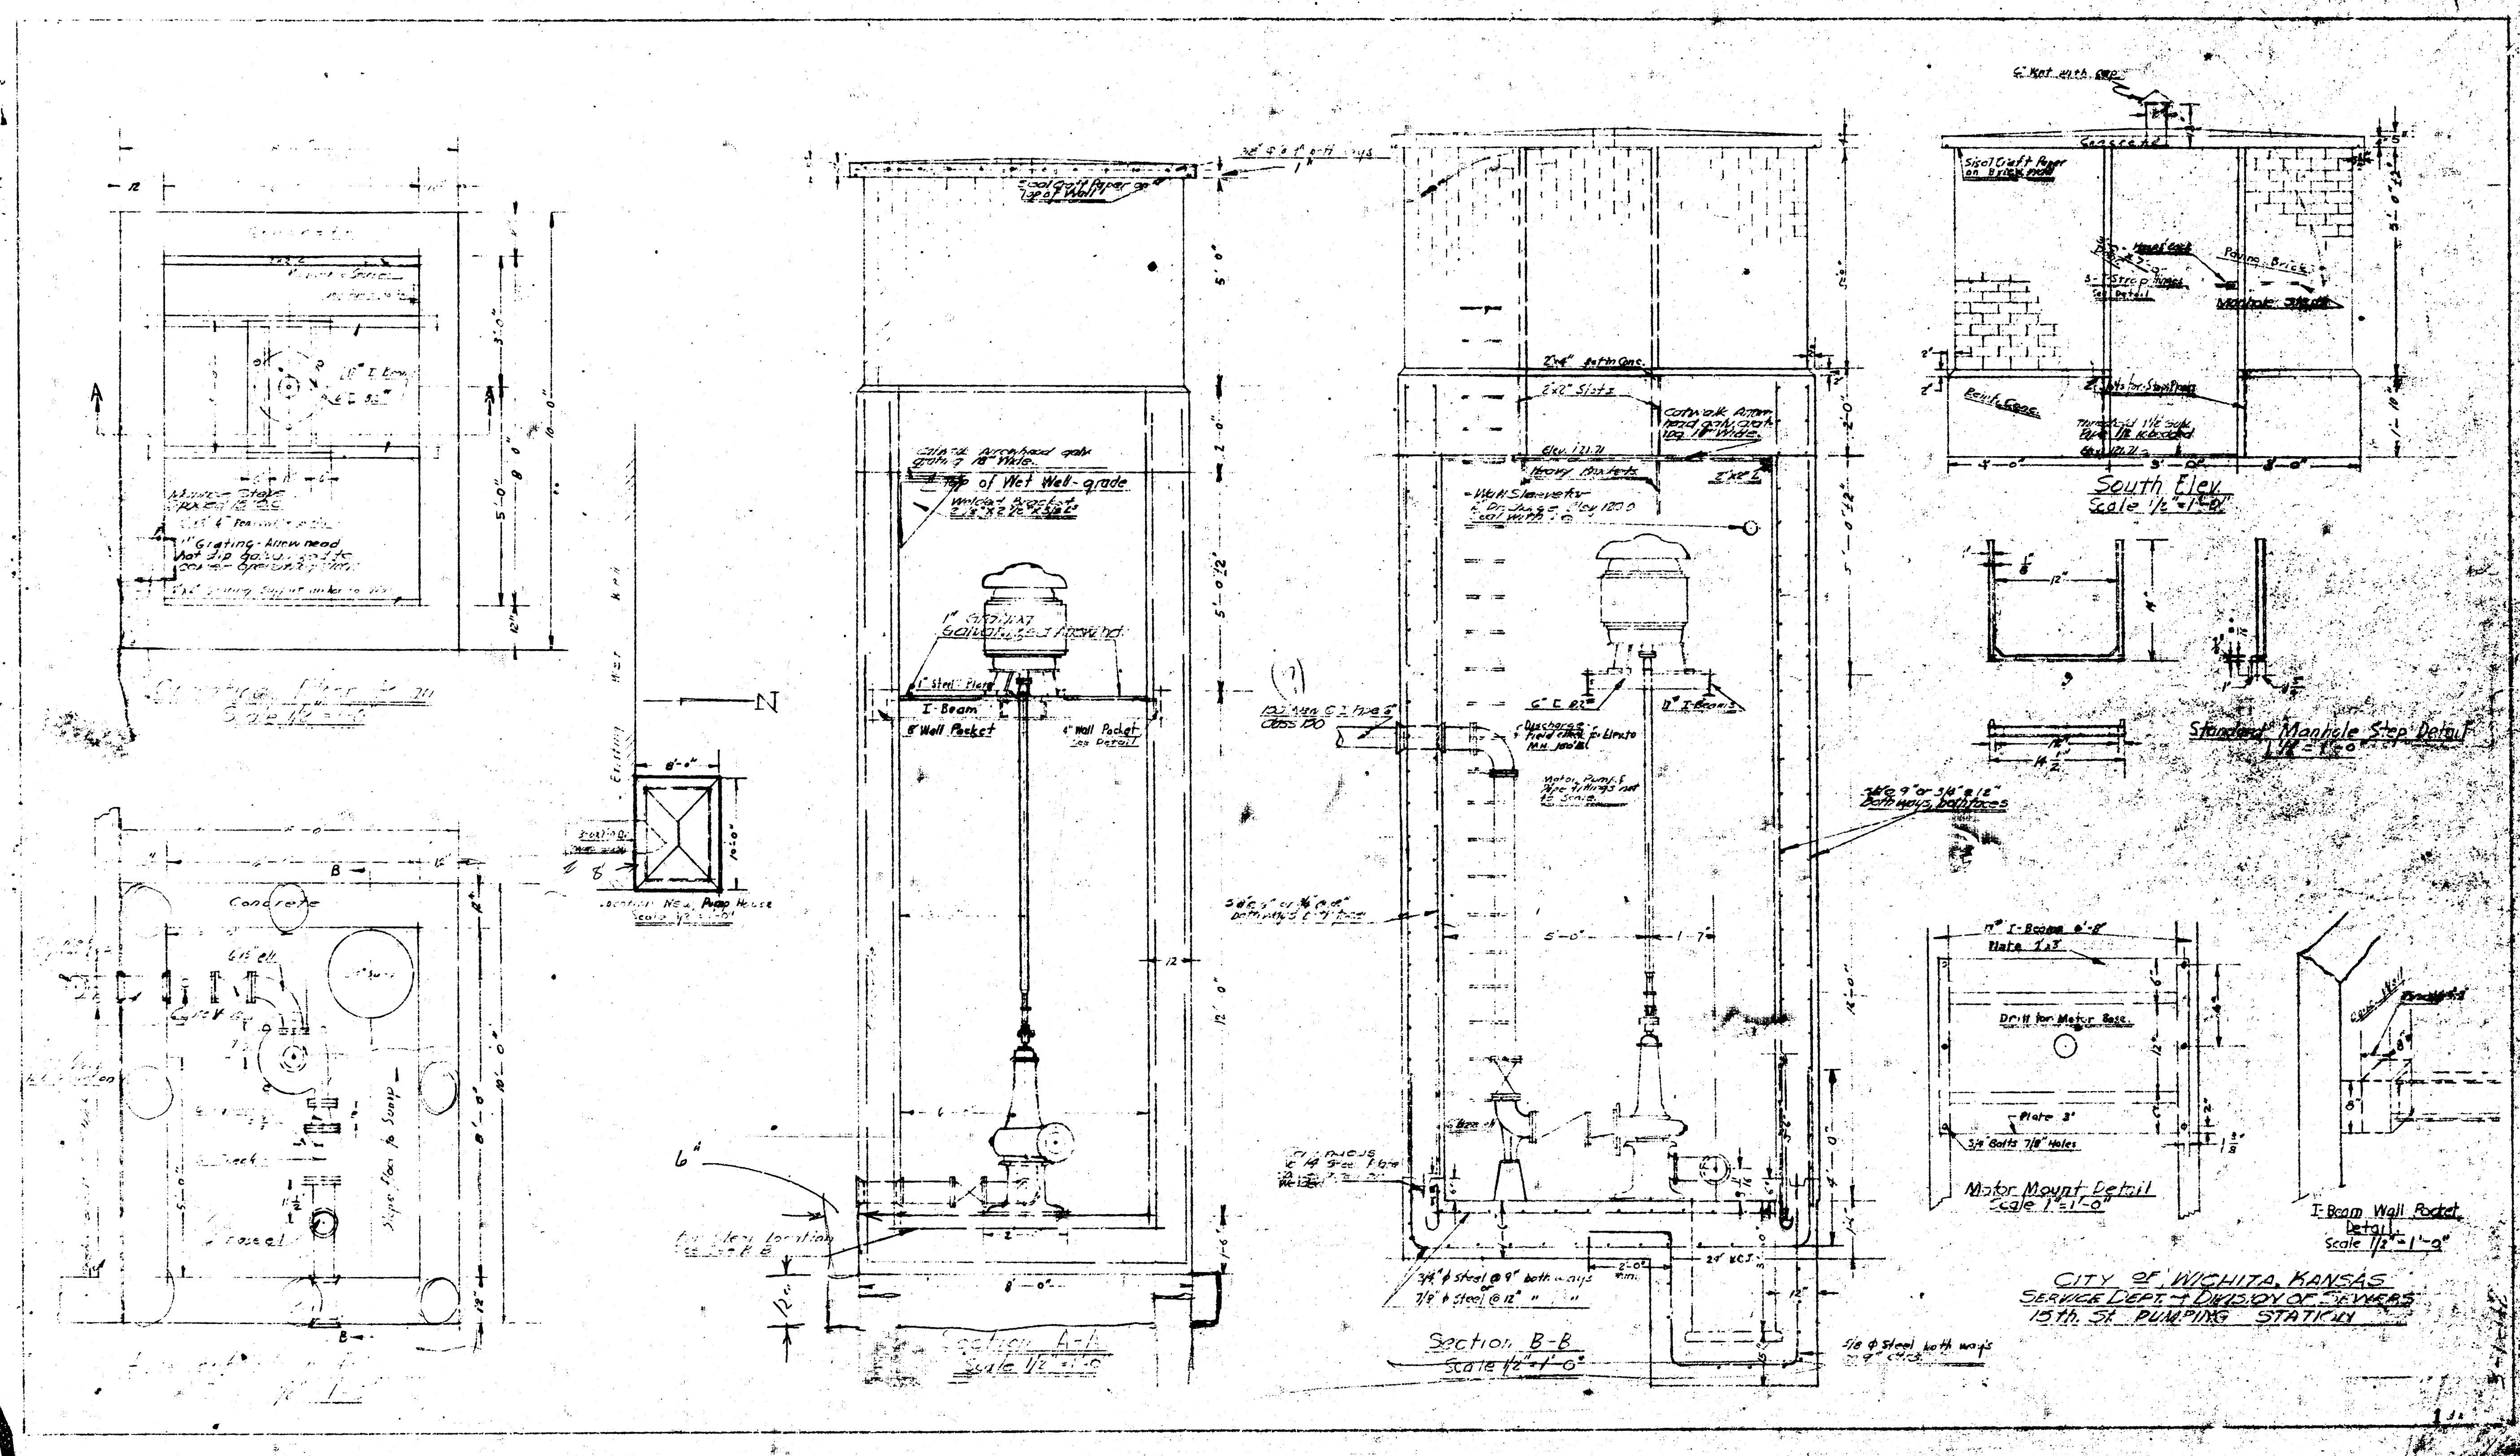

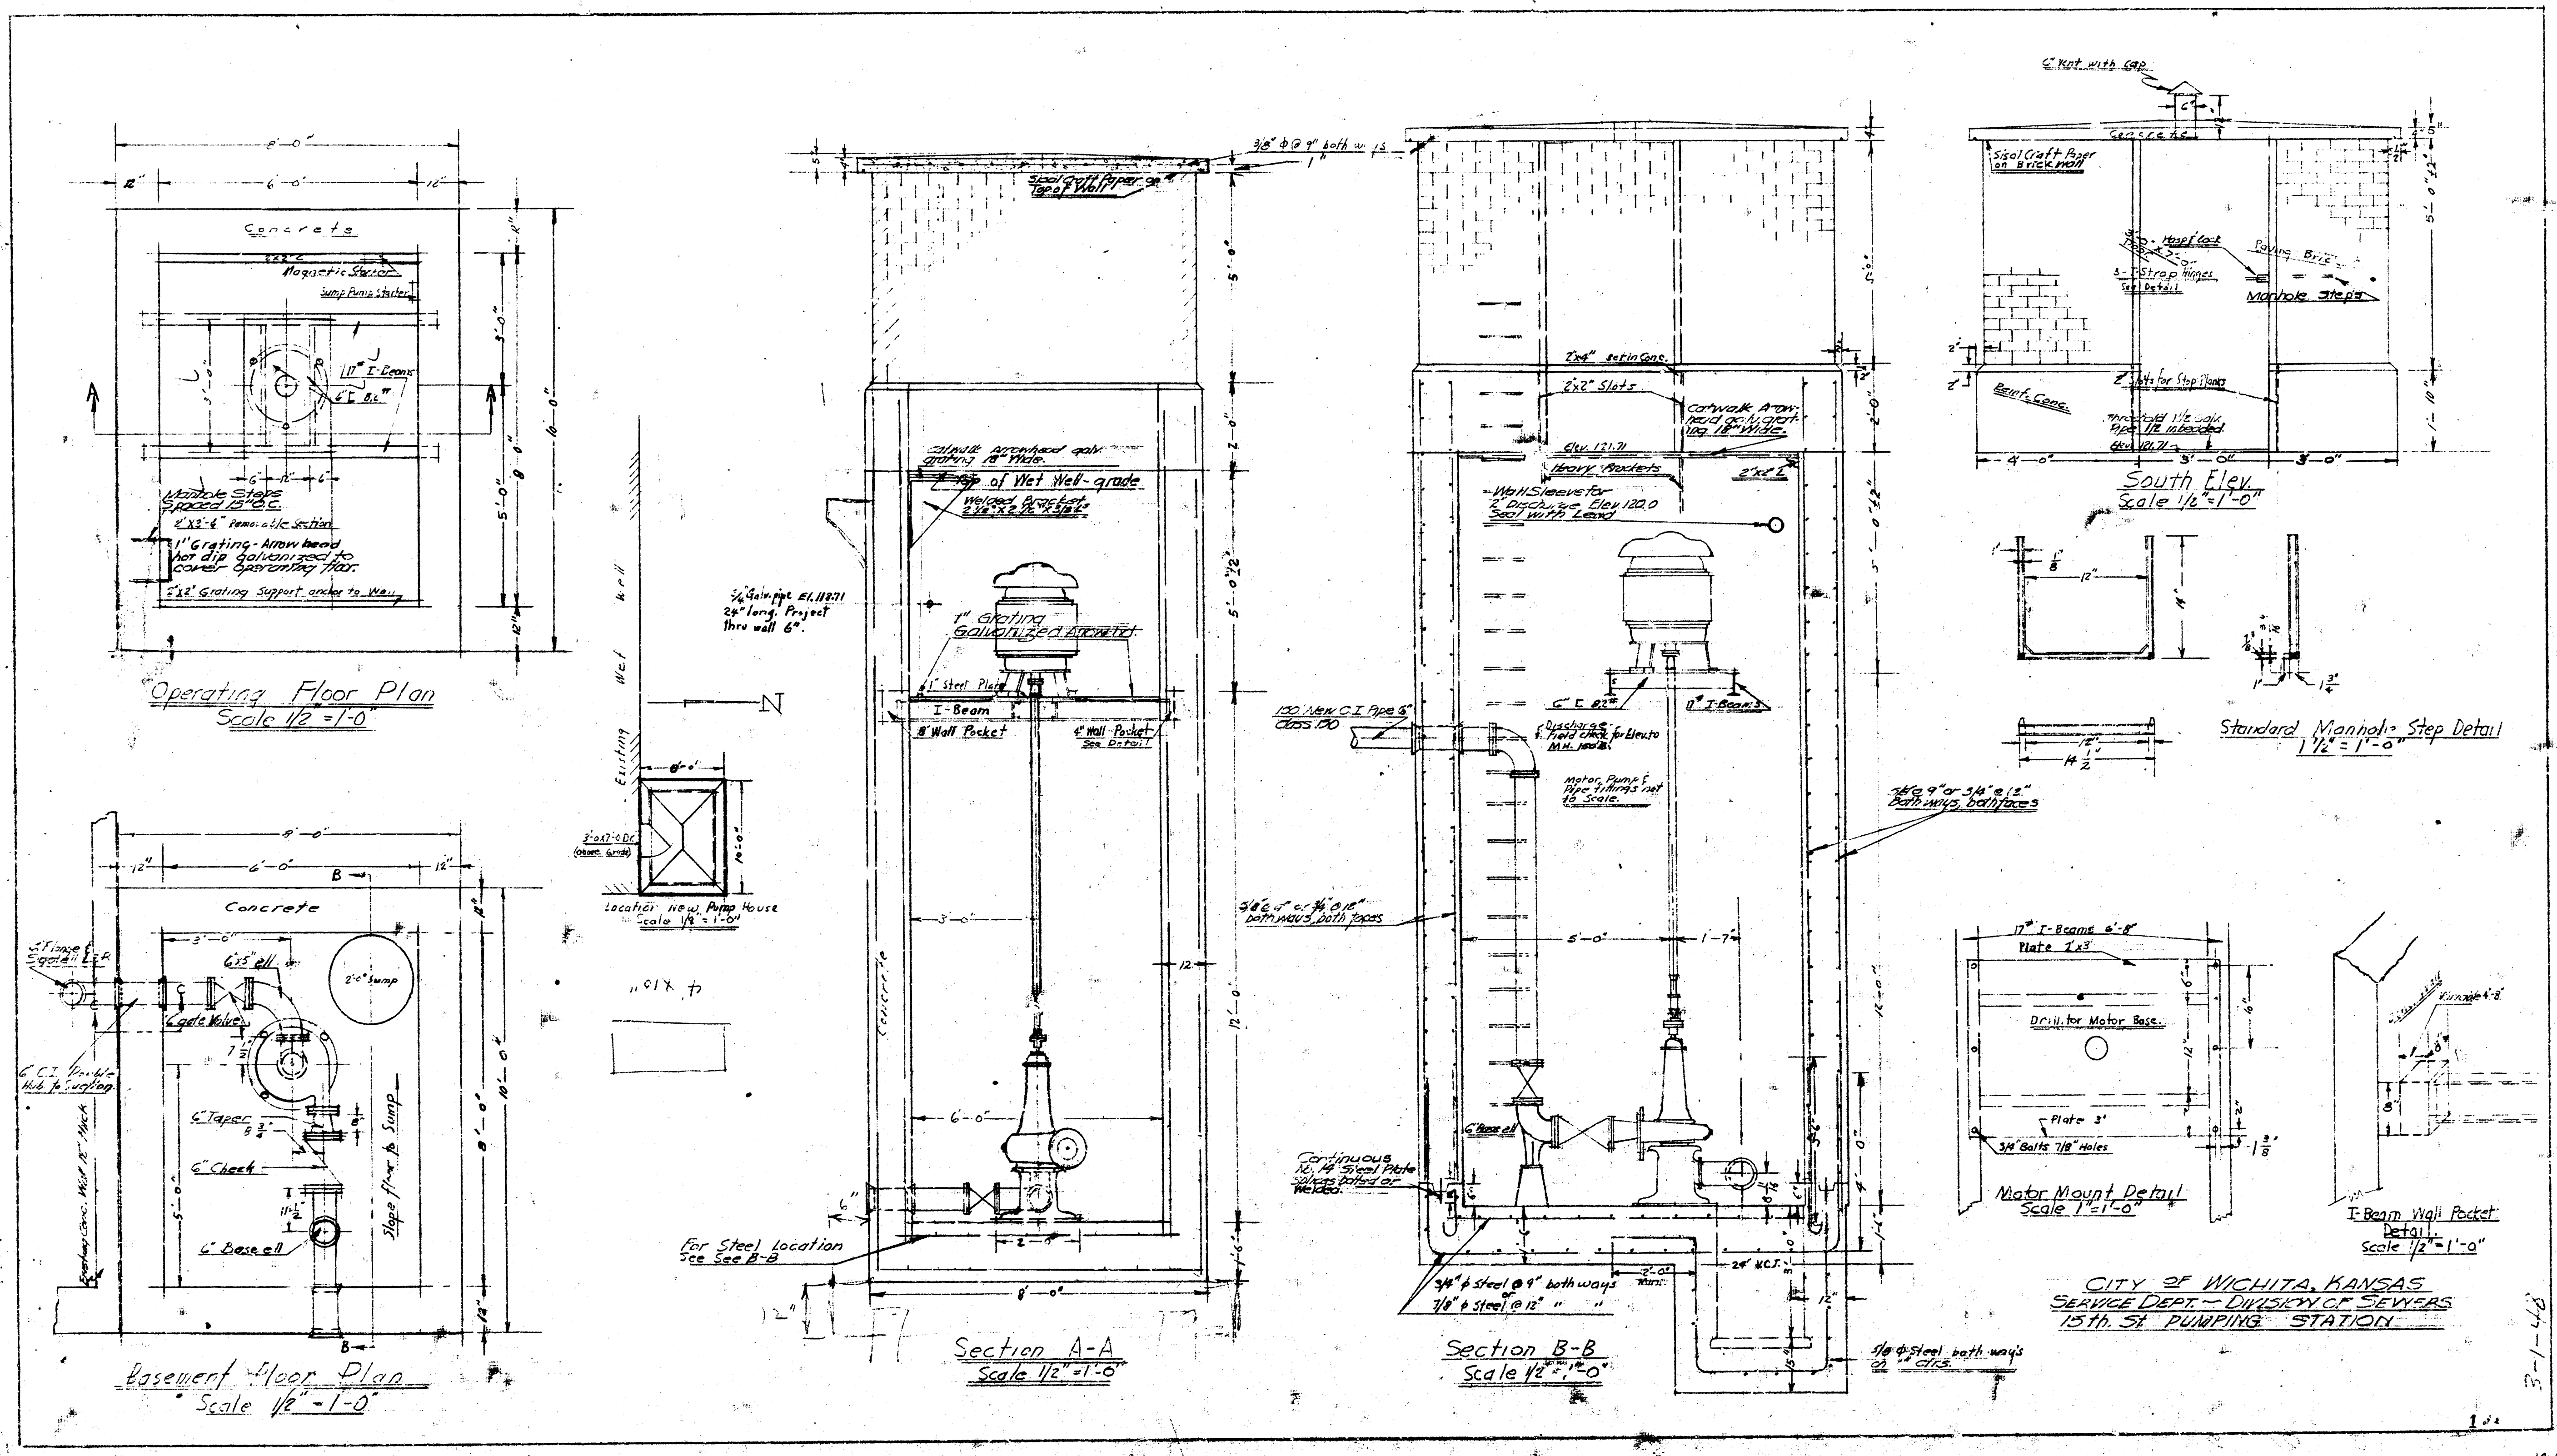

[illegible]

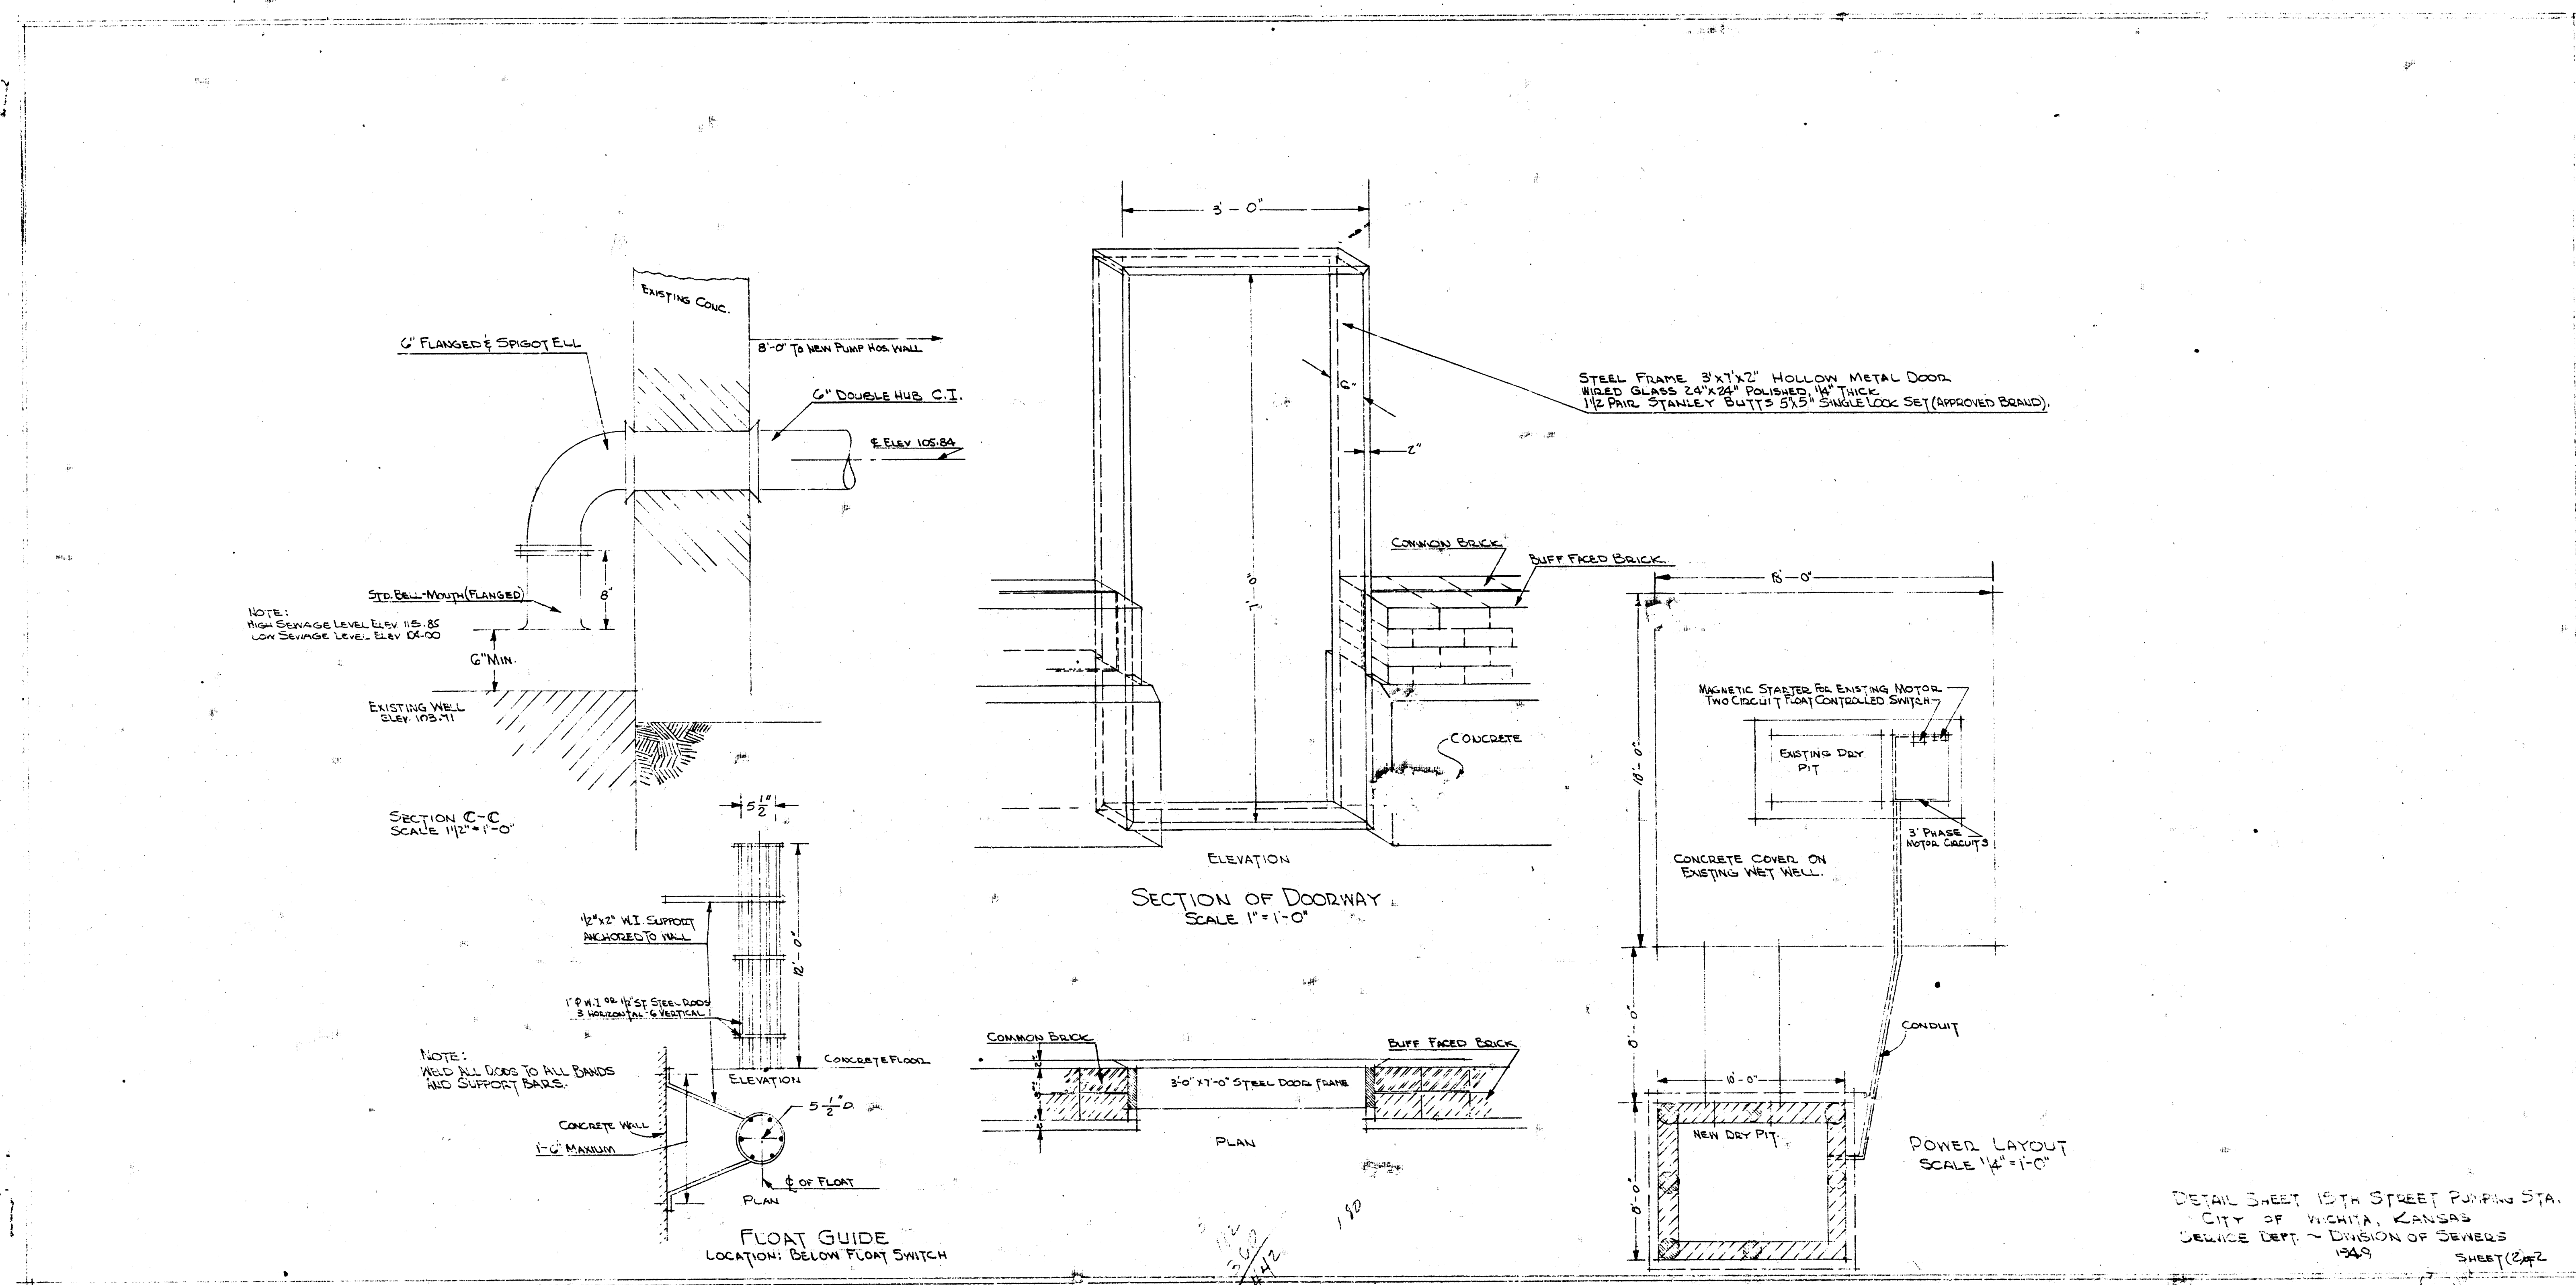

DETAIL SHEET 15TH STREET PUMPING STA.
CITY OF WICHITA, KANSAS
SERVICE DEPT. - DIVISION OF SEWERS
1949
SHEET 2 OF 2

