 



PLAN - BASELINE #1



PROFILE - BASELINE #1

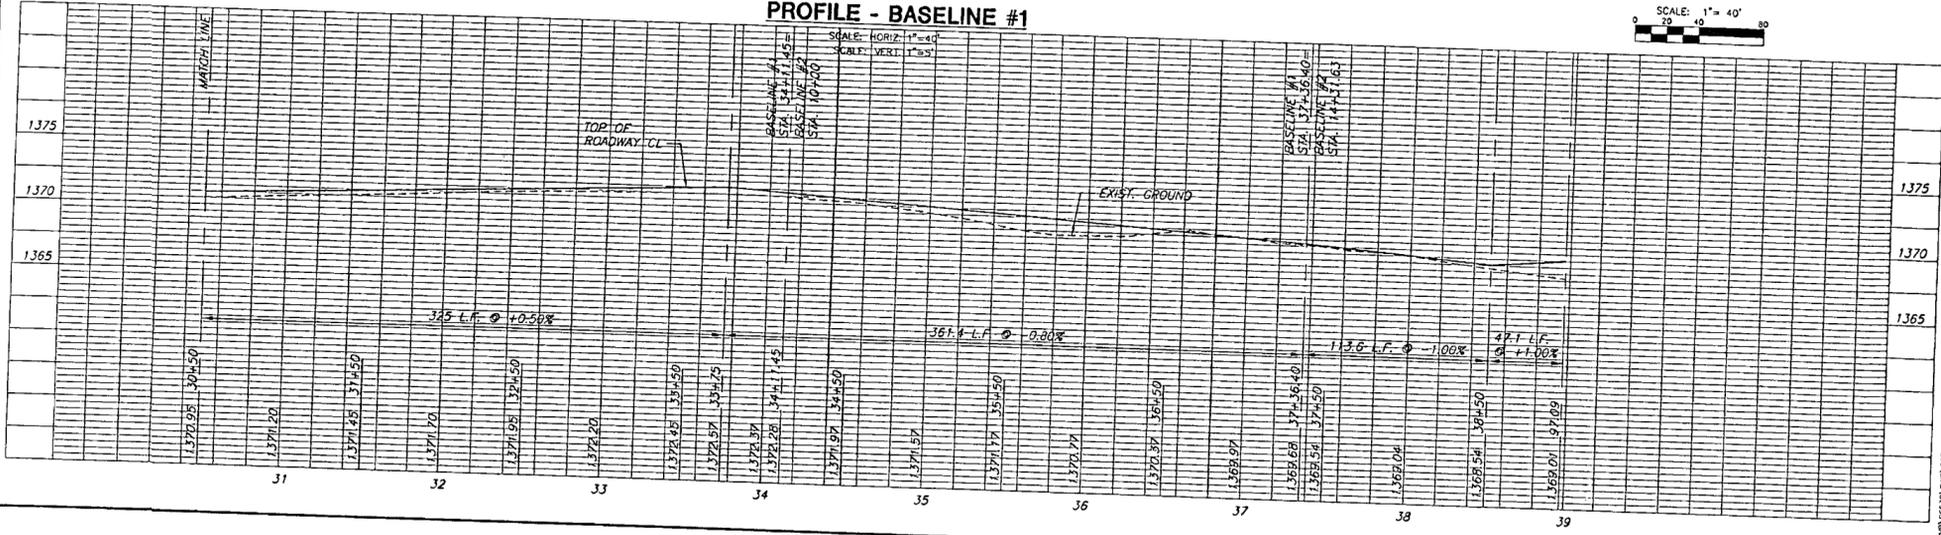

**MKEC**  
ENGINEERING  
CONSULTANTS, INC.  
411 N. WEBB ROAD  
WICHITA, KS. 67206  
316-684-9600

**EOD DISPOSAL FACILITY**

**SITE PLAN**  
SHEET TITLE  
06530  
PROJECT NUMBER

DLM / MKEC / DLM  
DESIGNED / DRAWN / CHECKED

ISSUED  
November 2006

SHEET NO.  
5 of 7