





NOTICE
THIS PLAN IS A PRELIMINARY DESIGN AND IS NOT TO BE USED FOR CONSTRUCTION OR FOR ANY OTHER PURPOSE WITHOUT THE WRITTEN CONSENT OF THE ARCHITECTS.

ADDITION TO	
ST. JOSEPH'S HOSPITAL SISTERS OF ST. JOSEPH WICHITA, KANSAS	
SITE PLAN	
MAQUOLO AND QUICK ARCHITECTS ENGINEERS	548 B P-1
WICHITA, KANSAS	ST. JOSEPH, MO. CINCINNATI, OHIO
APPROVED	DATE
2-4-52	

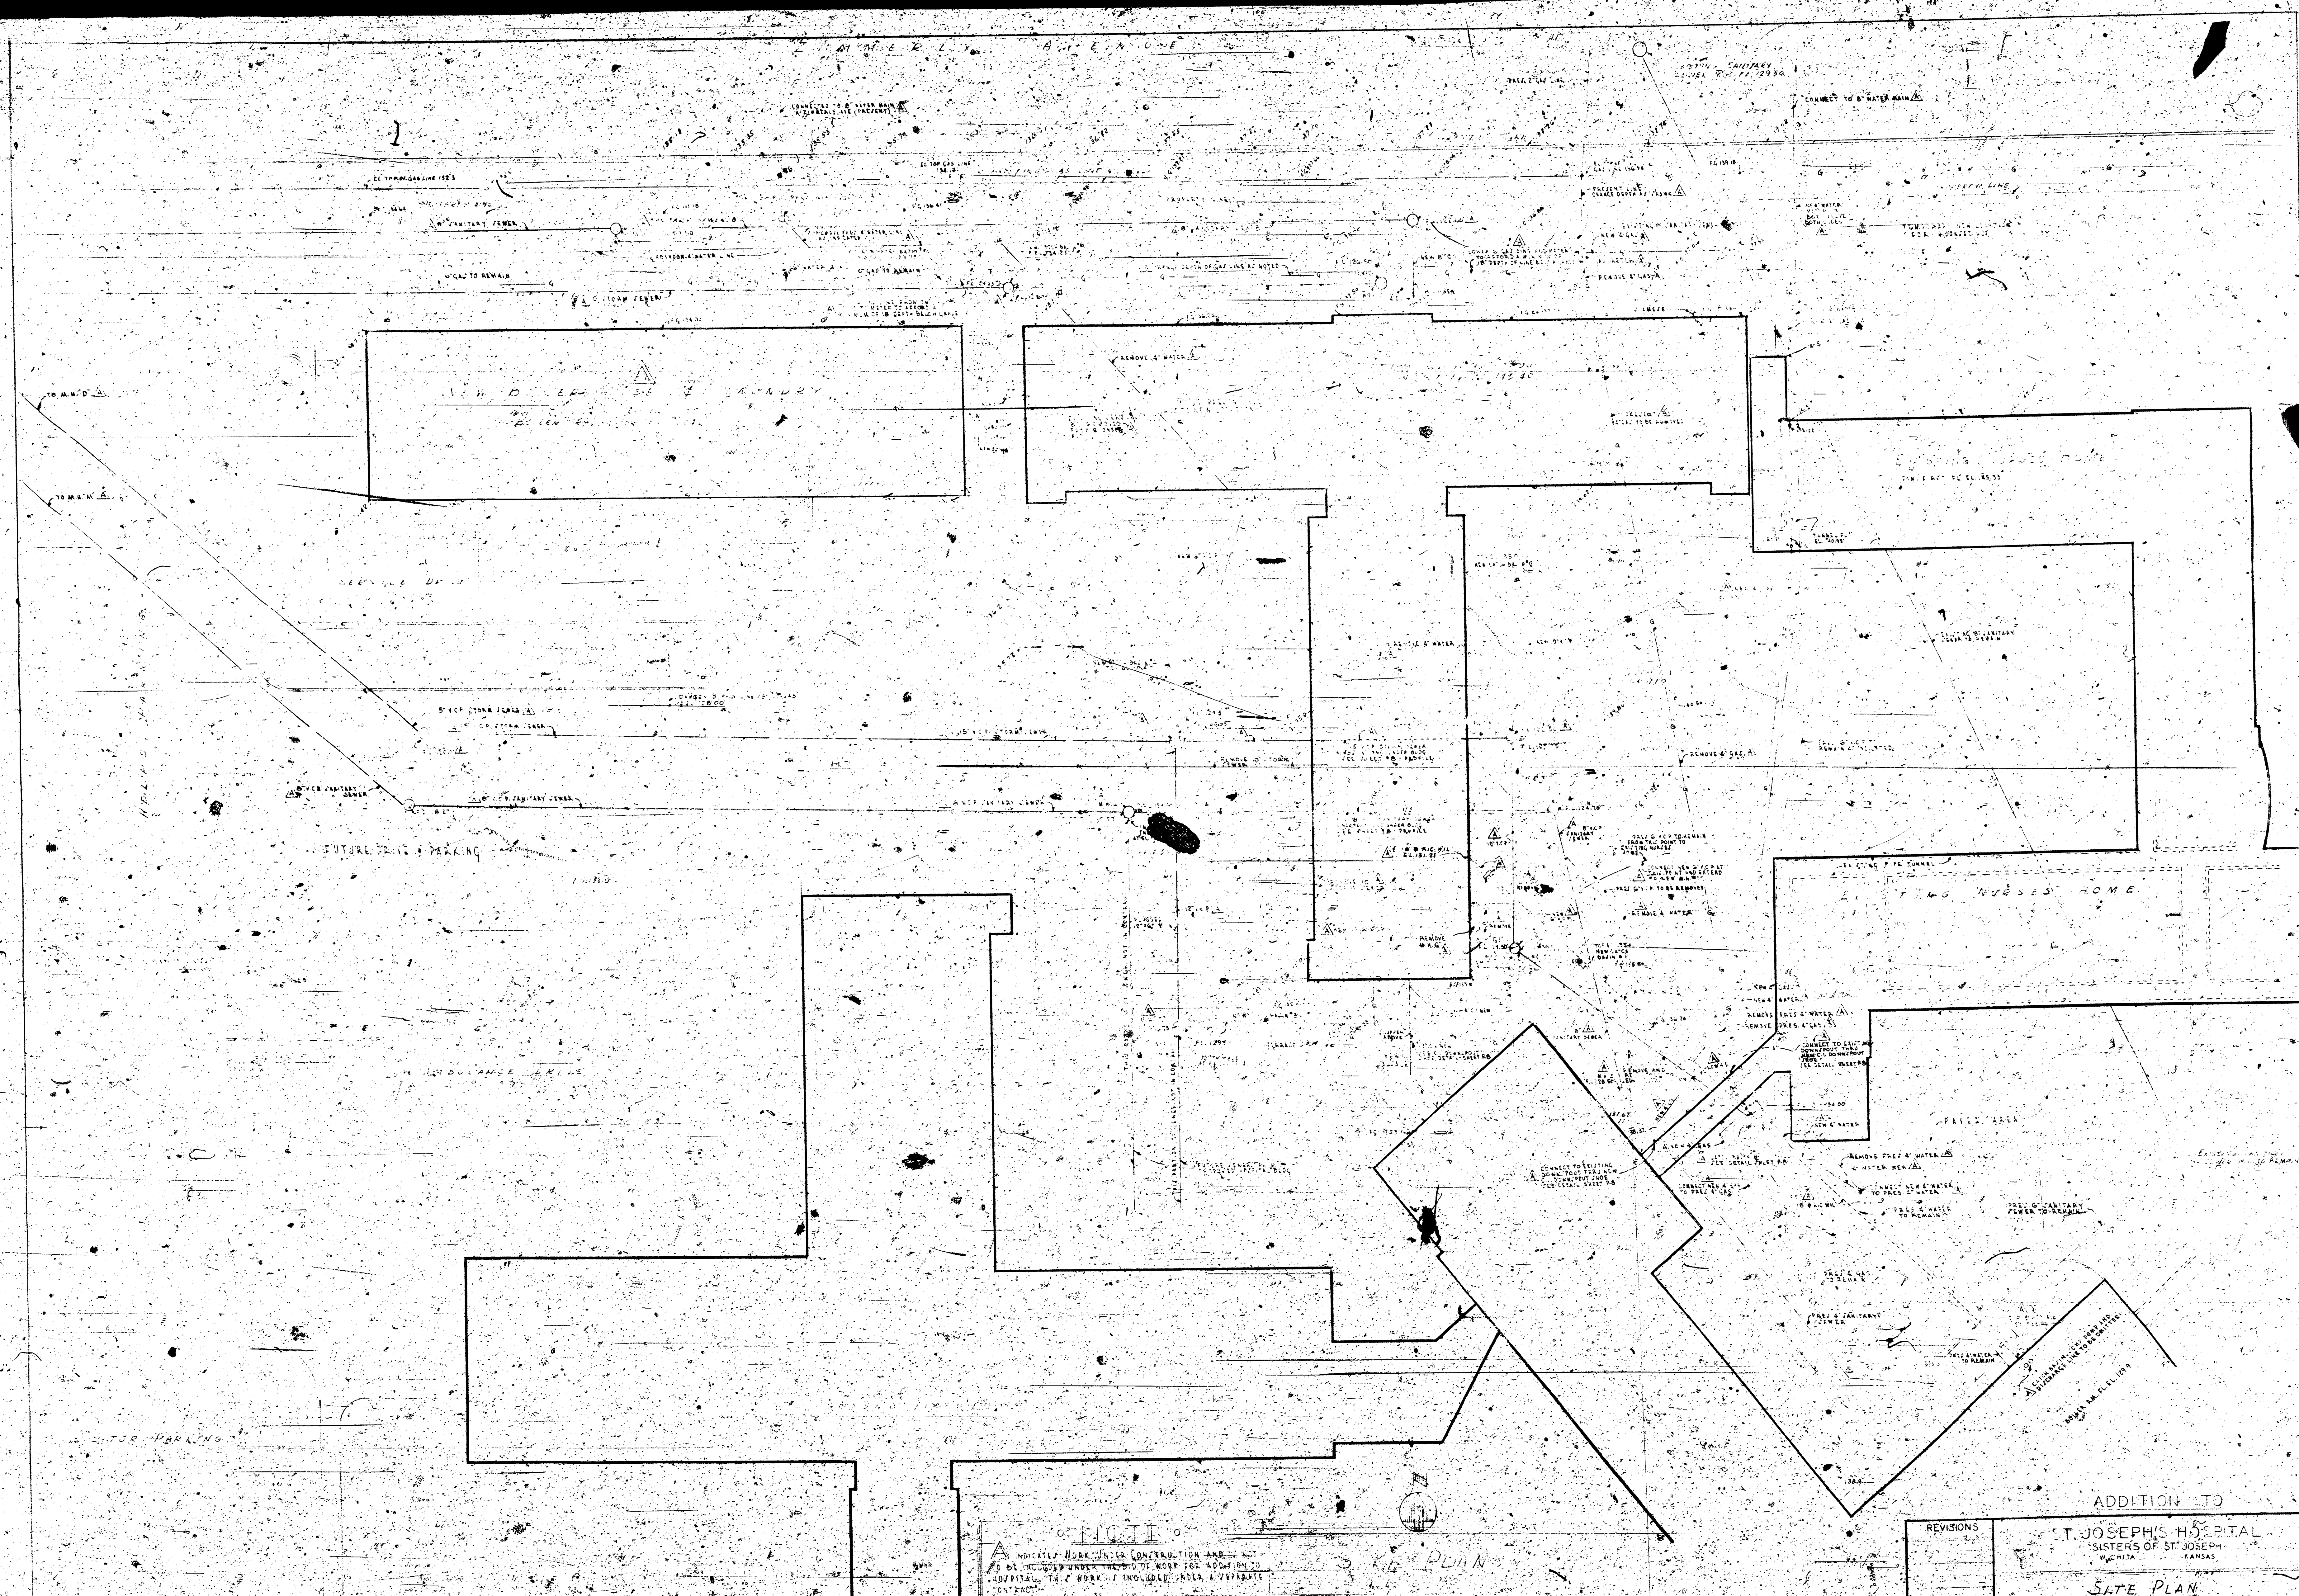


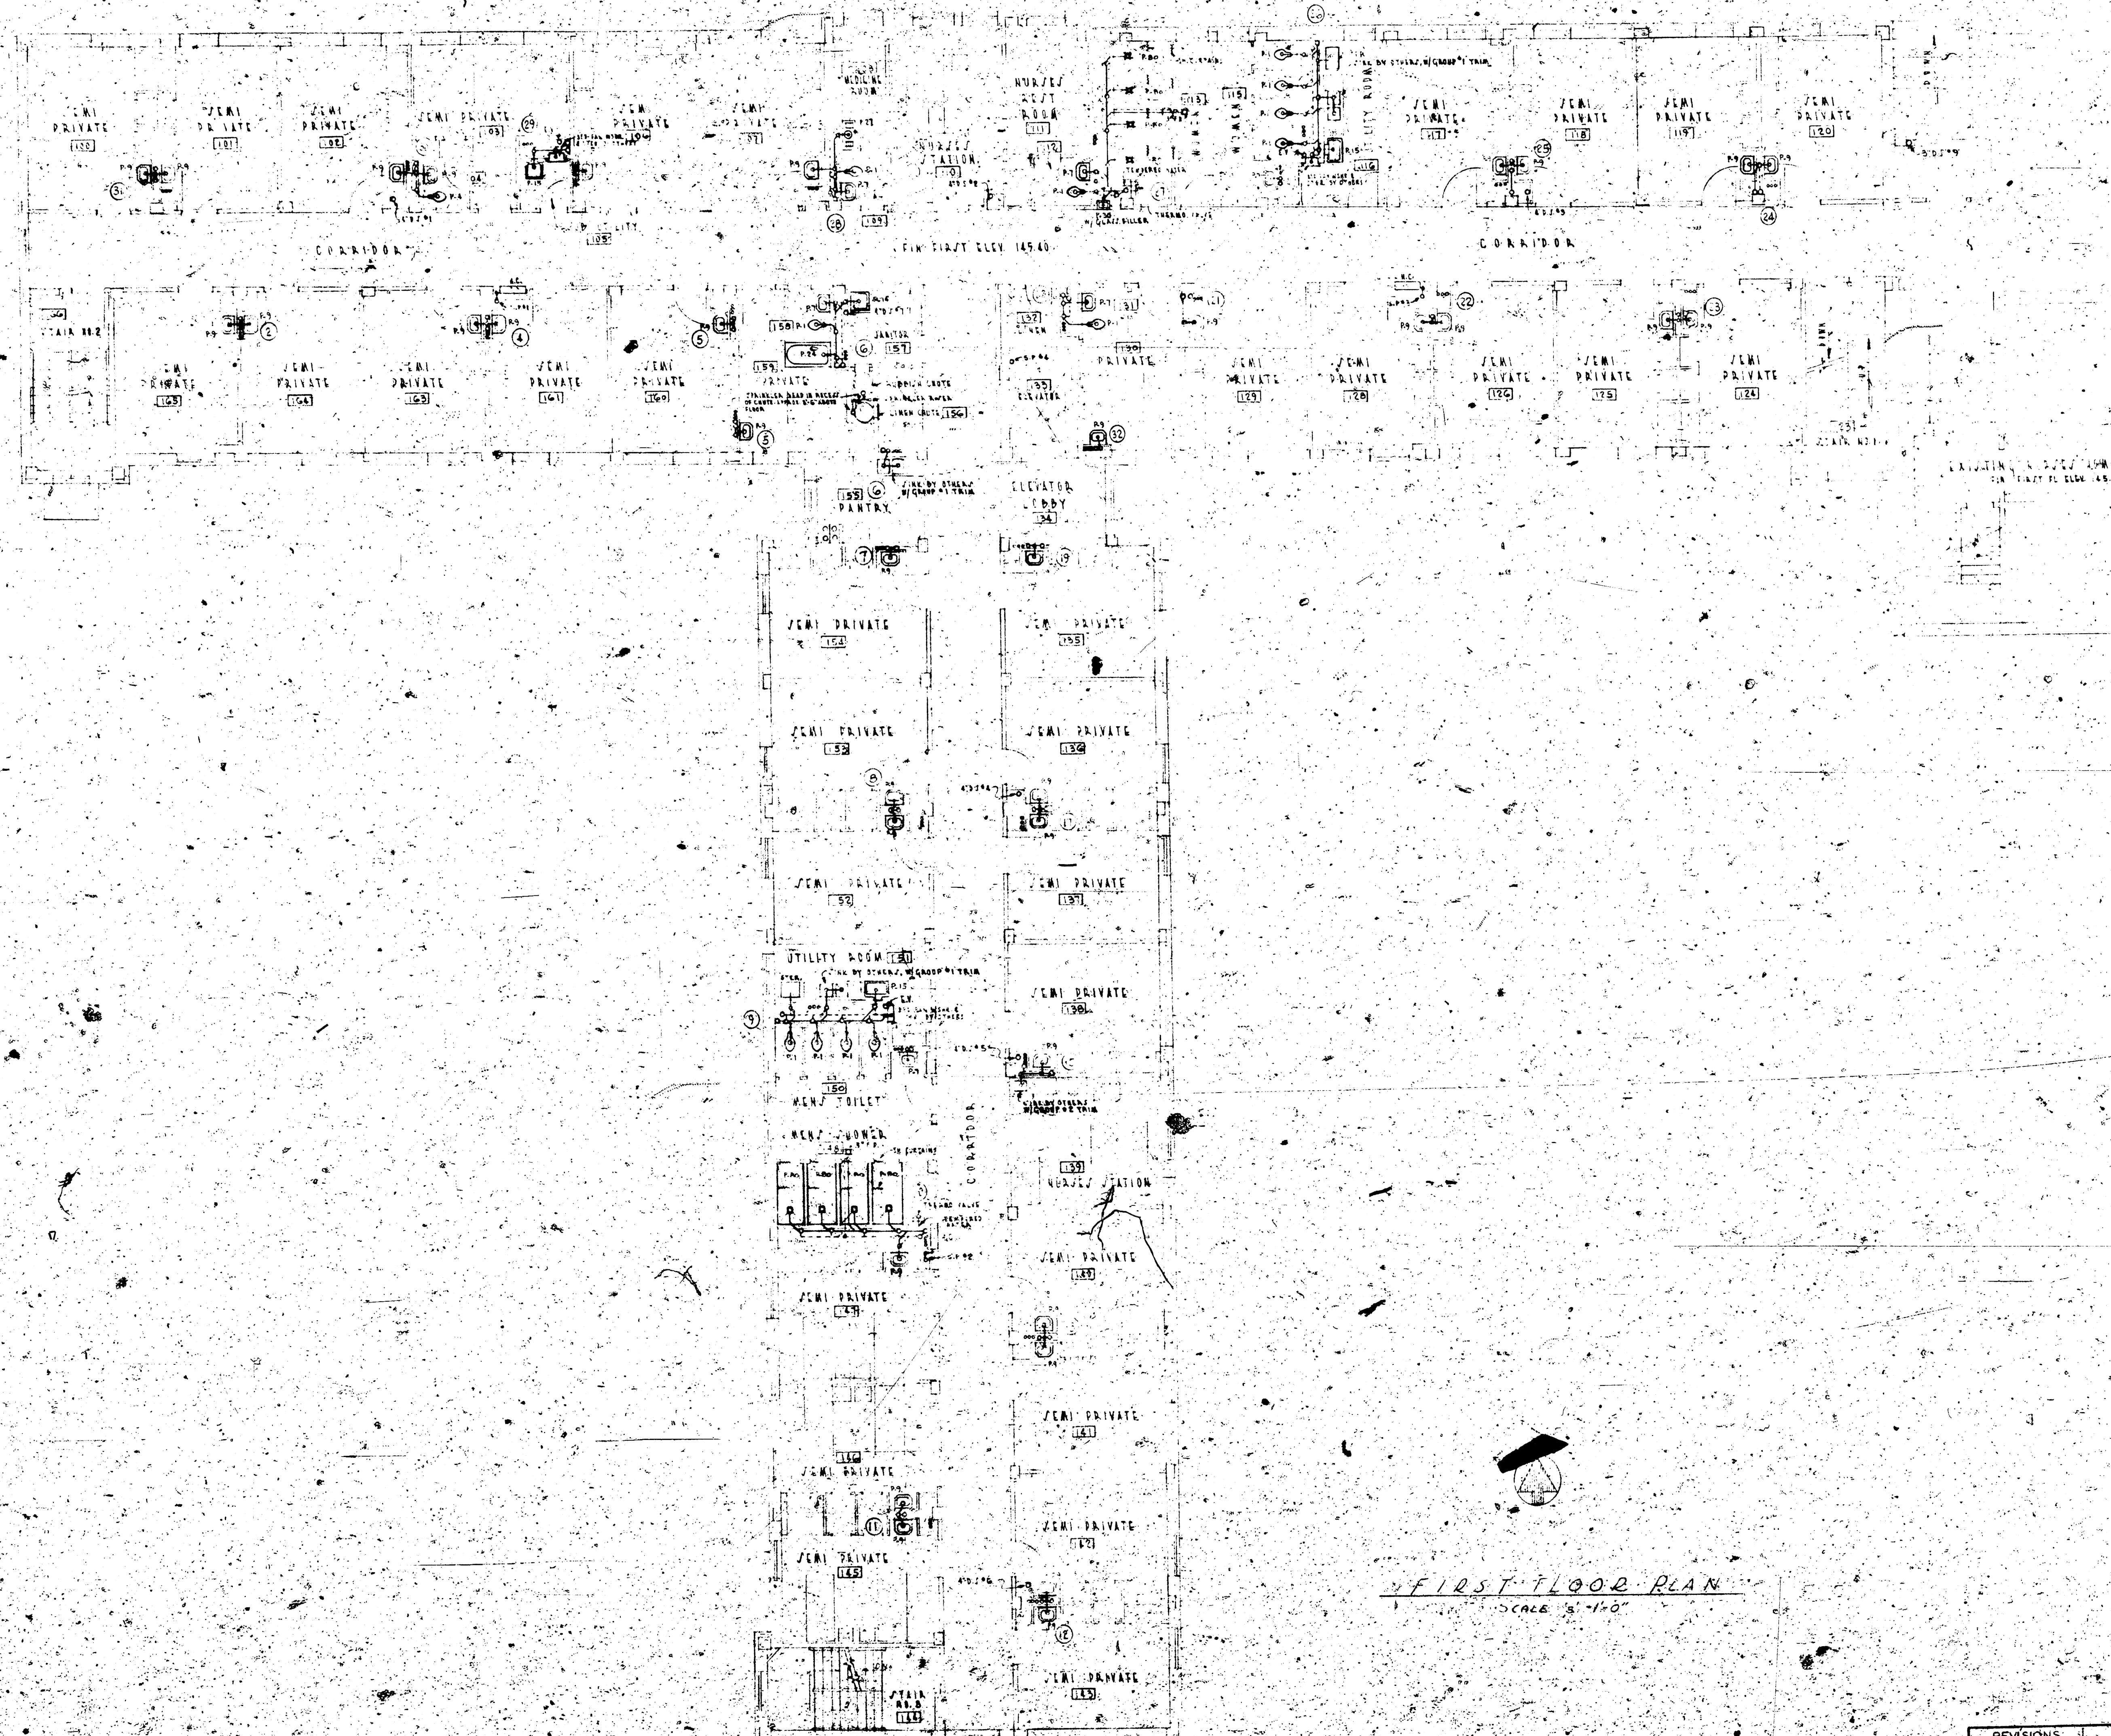


FIRST FLOOR PLAN
SCALE 1/8" = 1'-0"

PASSAGE TO EXISTING HOSPITAL
AT CORNER FLUSH 181
SEE FLOOR PLAN SET 1-1 FOR DETAILS
CONCERNING SHOP DRAWINGS AT 181-182

REVISIONS		ADDITION TO	
		ST. JOSEPH'S HOSPITAL	
		SISTERS OF ST. JOSEPH	
		ST. LOUIS, MO.	
		FIRST FLOOR PLAN	
DR. T.A.B.	MAGUOLO AND QUICK	548	
TR. C.A.A.	ARCHITECTS	B	
ENR.	ENGINEERS	P-4	
DESIGNED BY	ST. LOUIS, MO.		
DRAWN BY	CONCATON		
CHECKED			
APPROVED			
DATE	4-1-50		

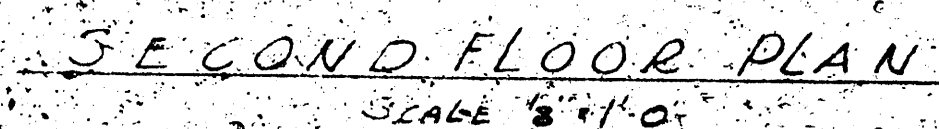

REVISIONS	ST. JOSEPH'S HOSPITAL SISTERS OF ST. JOSEPH WEHITA KANSAS		548 B DRAWING P-5
	SECOND FLOOR PLAN		
DATE	MAGUILO AND QUICK ARCHITECTS - ENGINEERS	DETROIT, MICH.	ST. LOUIS, MO.
TA 548		MANNECAPULU, KIRIBI	C. H. HINNATLOND
CH			
	ISSUED	APPROVED	SCALE
	2-4-62		1/4" = 1'-0"

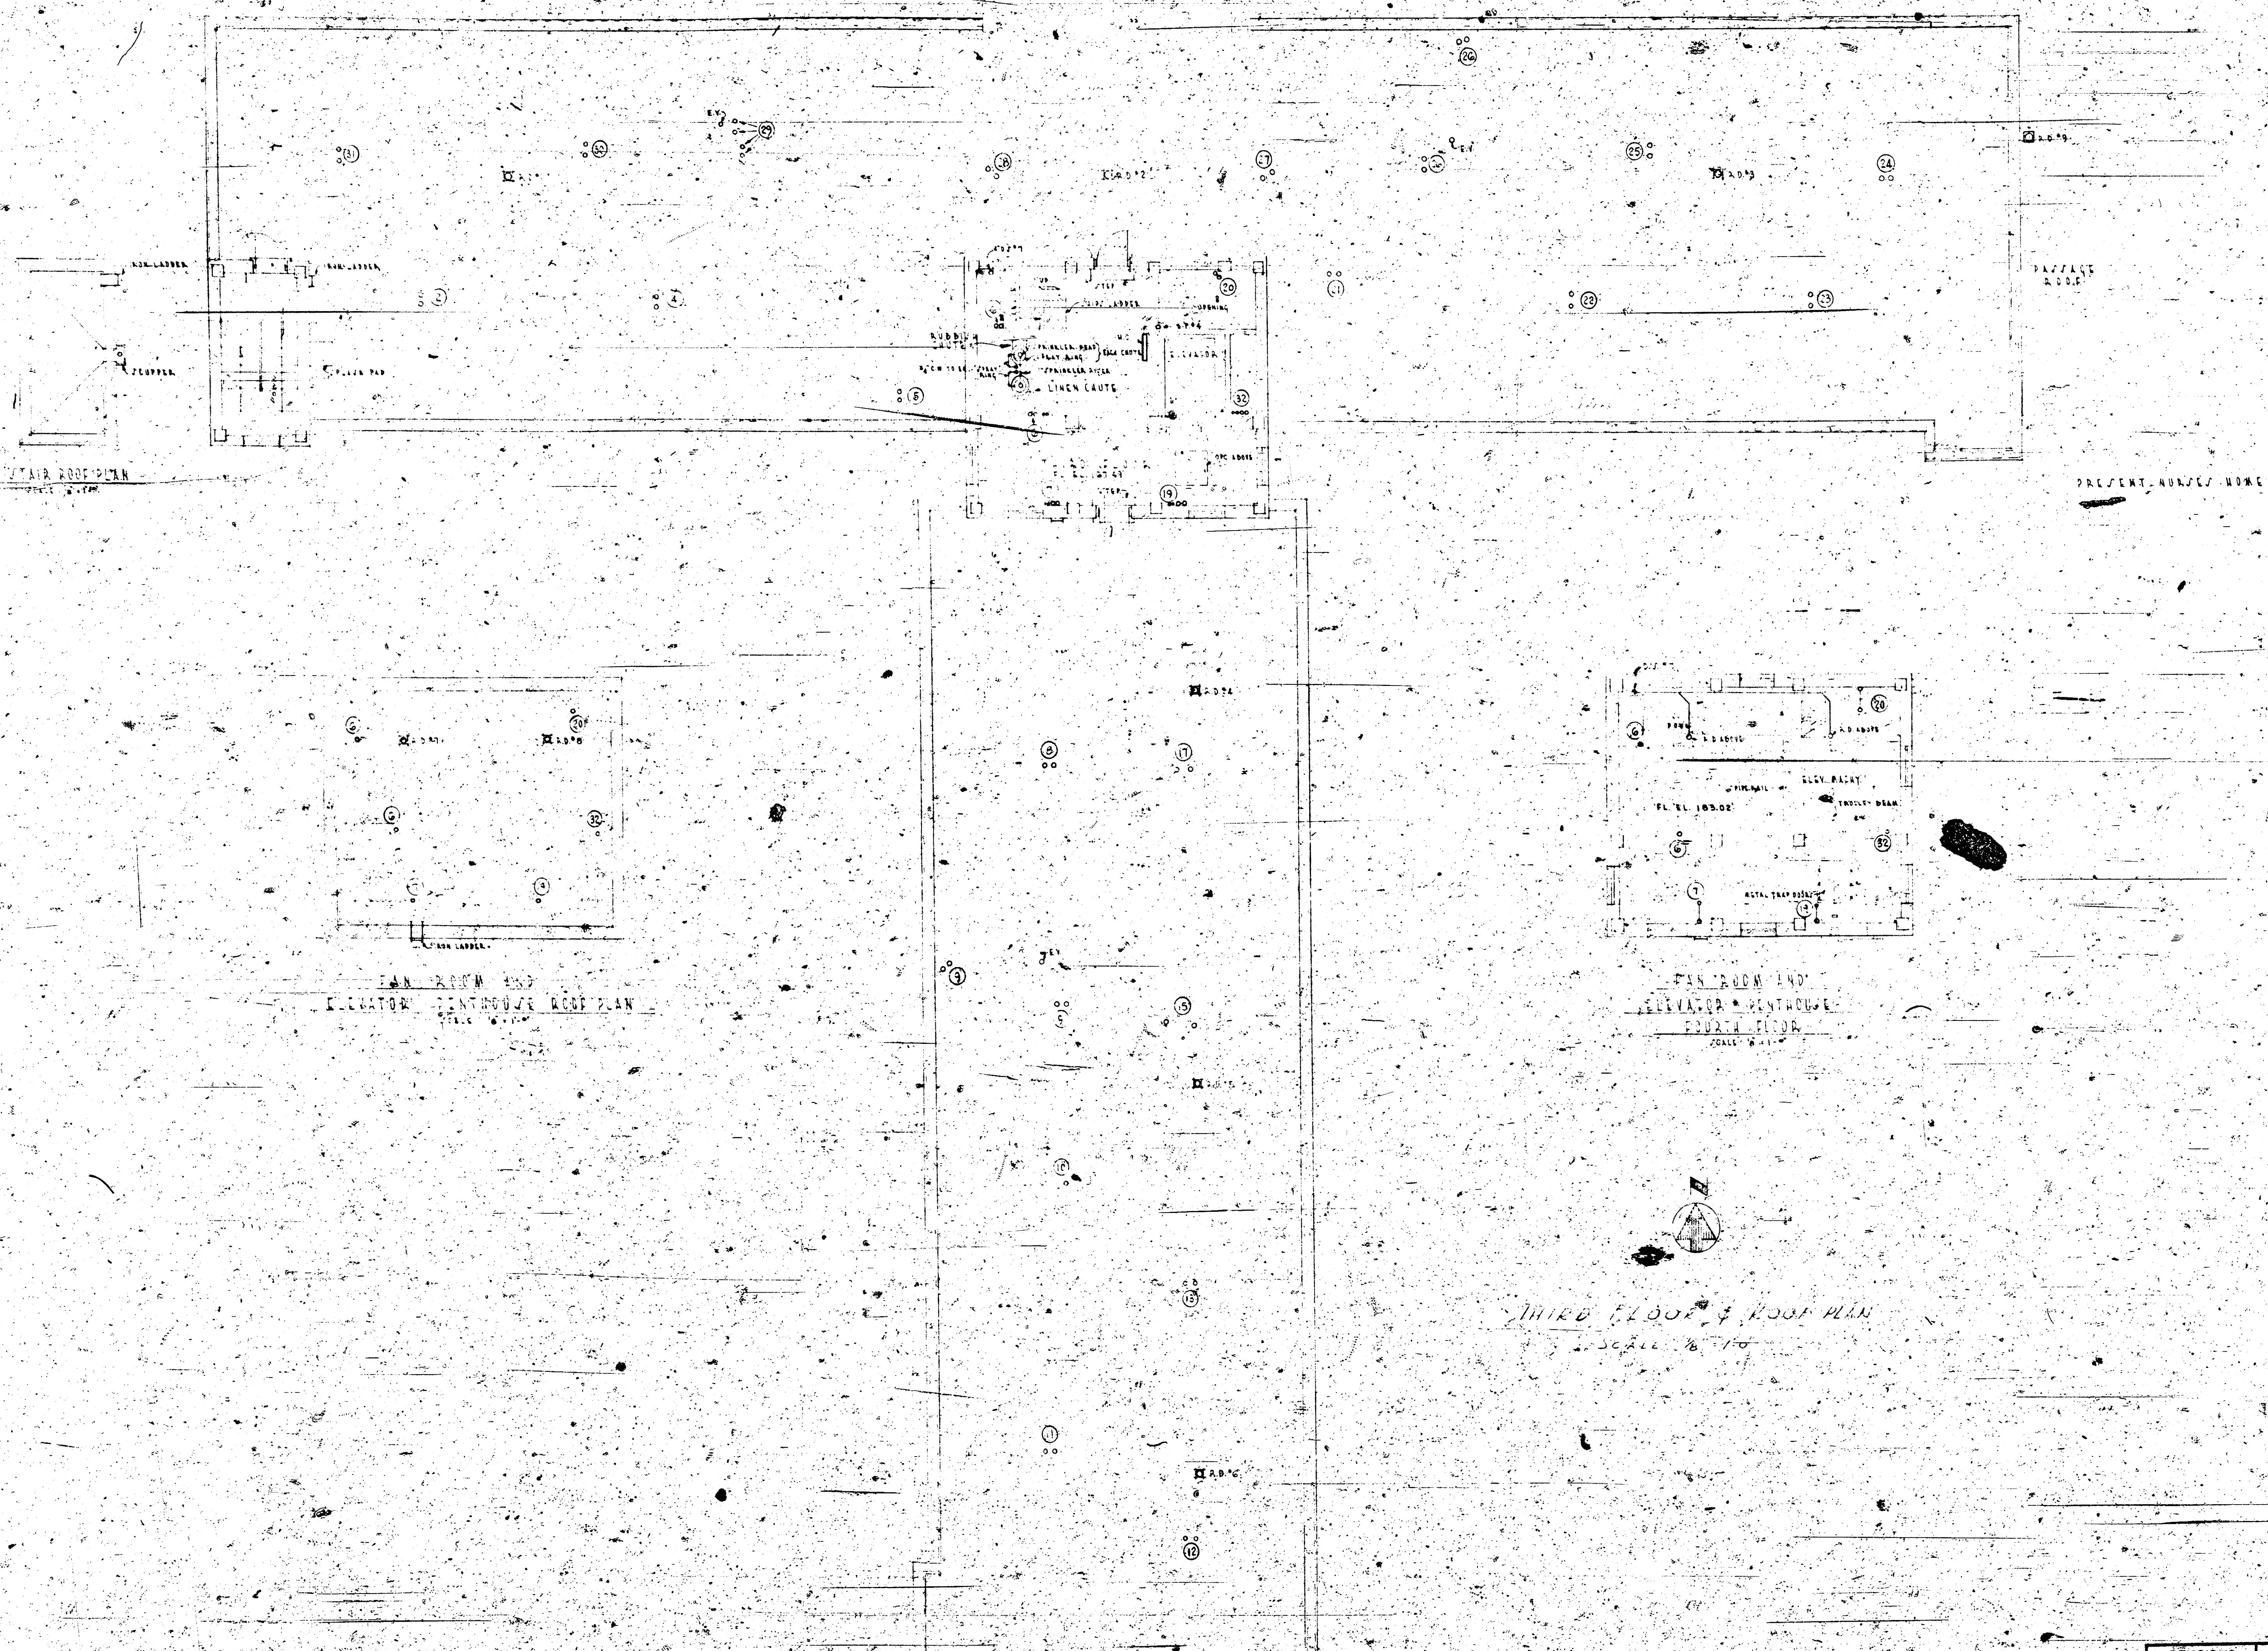

ADDITION TO

ST. JOSEPH'S HOSPITAL
SISTERS OF ST. JOSEPH
KANSAS

THIRD FLOOR & ROOF PLAN

MAGUOLO AND QUICK
ARCHITECTS - ENGINEERS


DETROIT, MICH. ST. LOUIS, MO.
MINNEAPOLIS, MINN. CINCINNATI, OHIO.


ISSUED 7-4-52

548

P-6


As Made

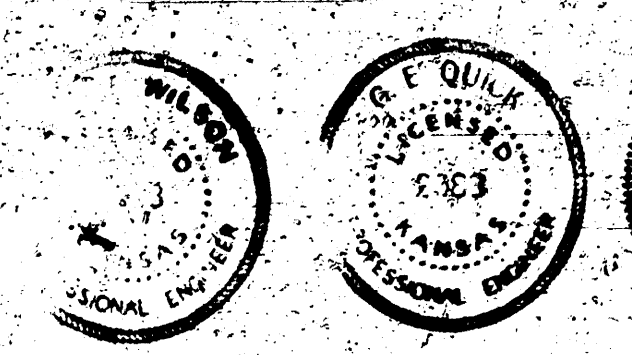

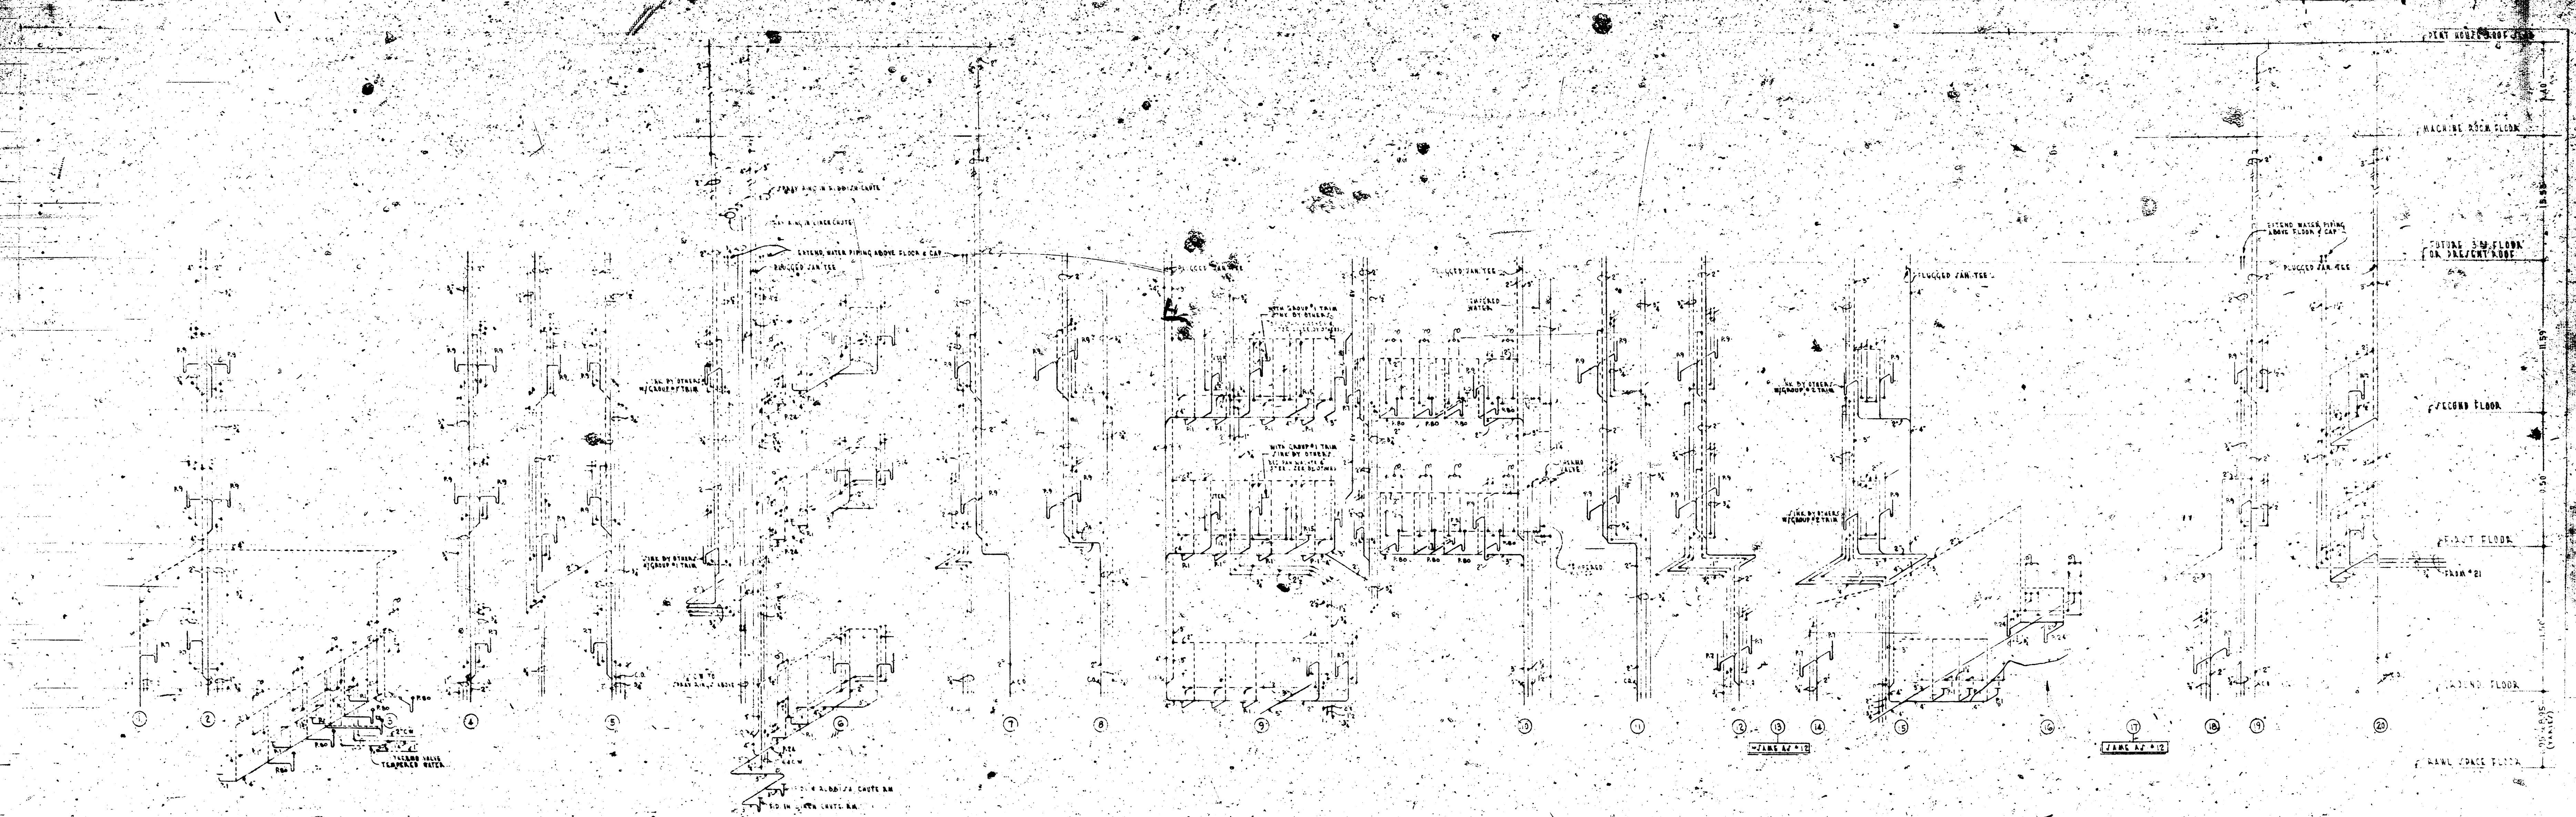

PLUMBING RISER DIAGRAMS

- (1) EXTEND ALL WASTE AND VENT PIPING INDIVIDUALLY THRU FUTURE 5TH FLOOR OR PRESENT ROOF, AND AT TURN WASTE PIPING EXTENDING THRU PENT HOUSE.
- (2) PROVIDE SCHEDULED OPENING ON FLOOR FOR WASTE STACKS FOR FUTURE INSTALLATION OF FLOORING ON 5TH FLOOR, AS INDICATED.
- (3) TERMINATE WATER RISER AT 2ND FLOOR, CEILING OR IN PENT HOUSE, 1ST FLOOR IN FUTURE 5TH FLOOR OR PRESENT ROOF FOR FUTURE EXTENSION OF WATER RISER.

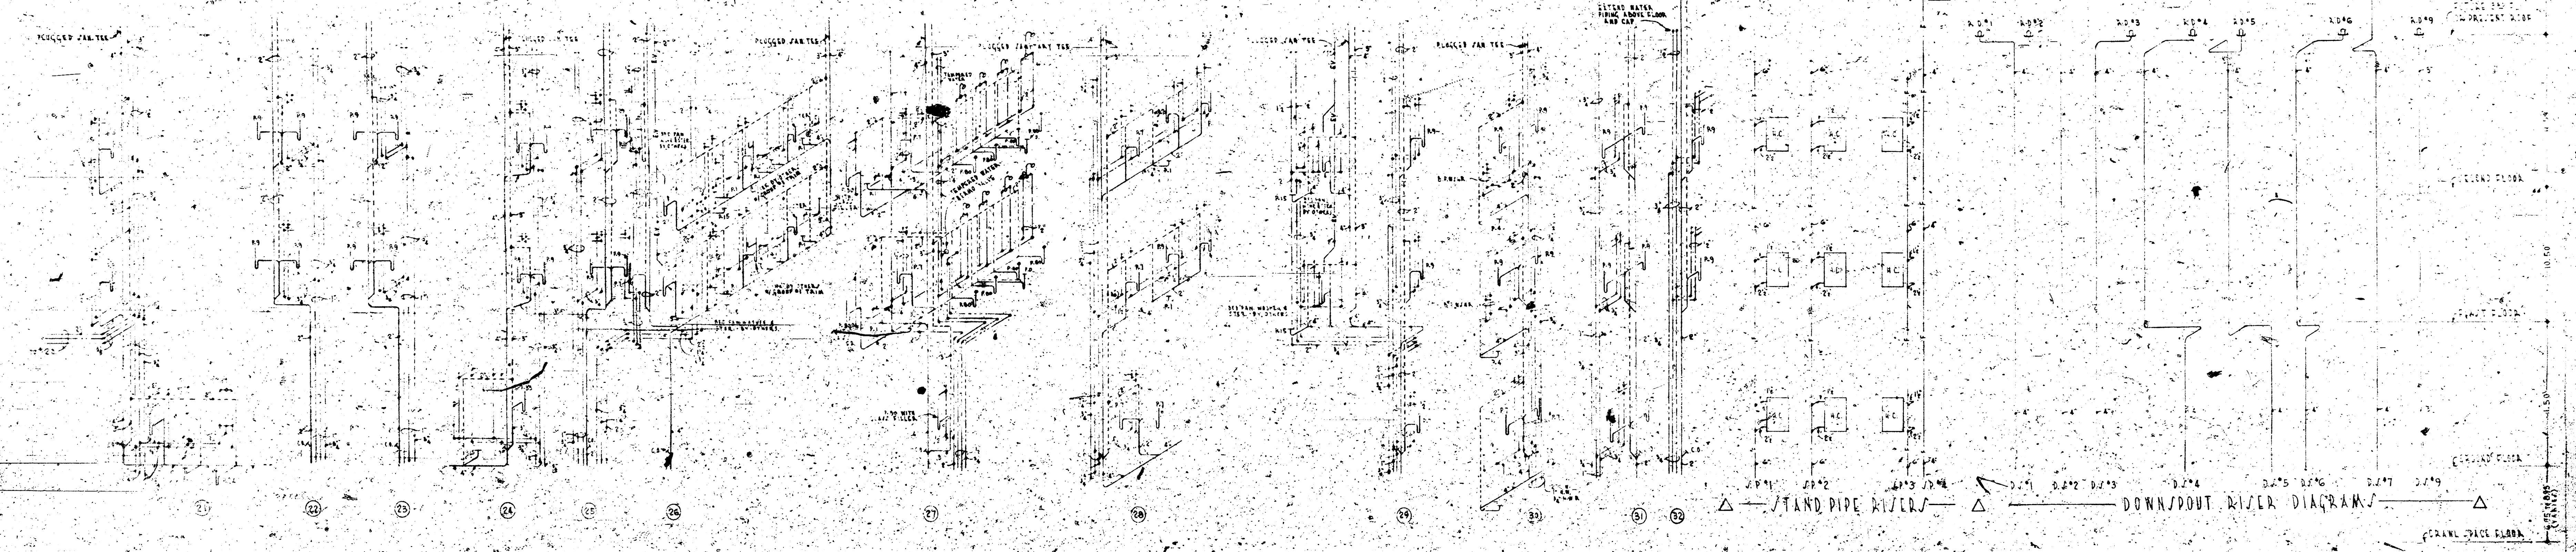

STAND PIPE RISER DOWN/OUT RISER DIAGRAM

ADDITION TO

ST. JOSEPH'S HOSPITAL
SISTERS OF ST. JOSEPH





PIEL DIAGRAM

MAGUILO AND QUICK
ARCHITECTS ENGINEERS

ST. LOUIS, MO.
INDIANAPOLIS, IND.

548
P-7

SCALE
AS SHOWN

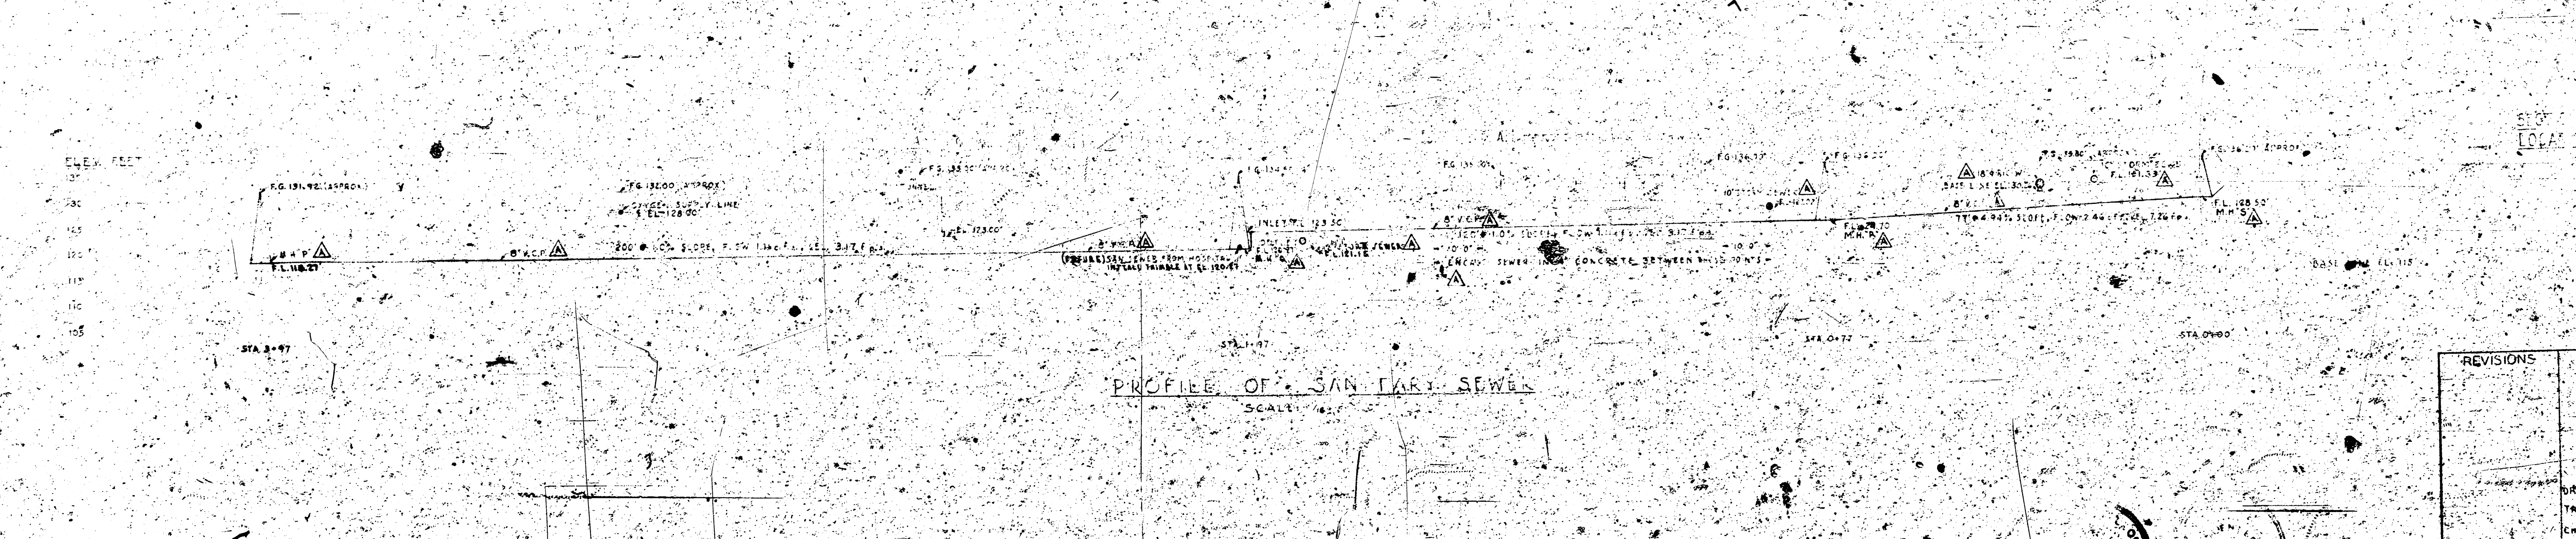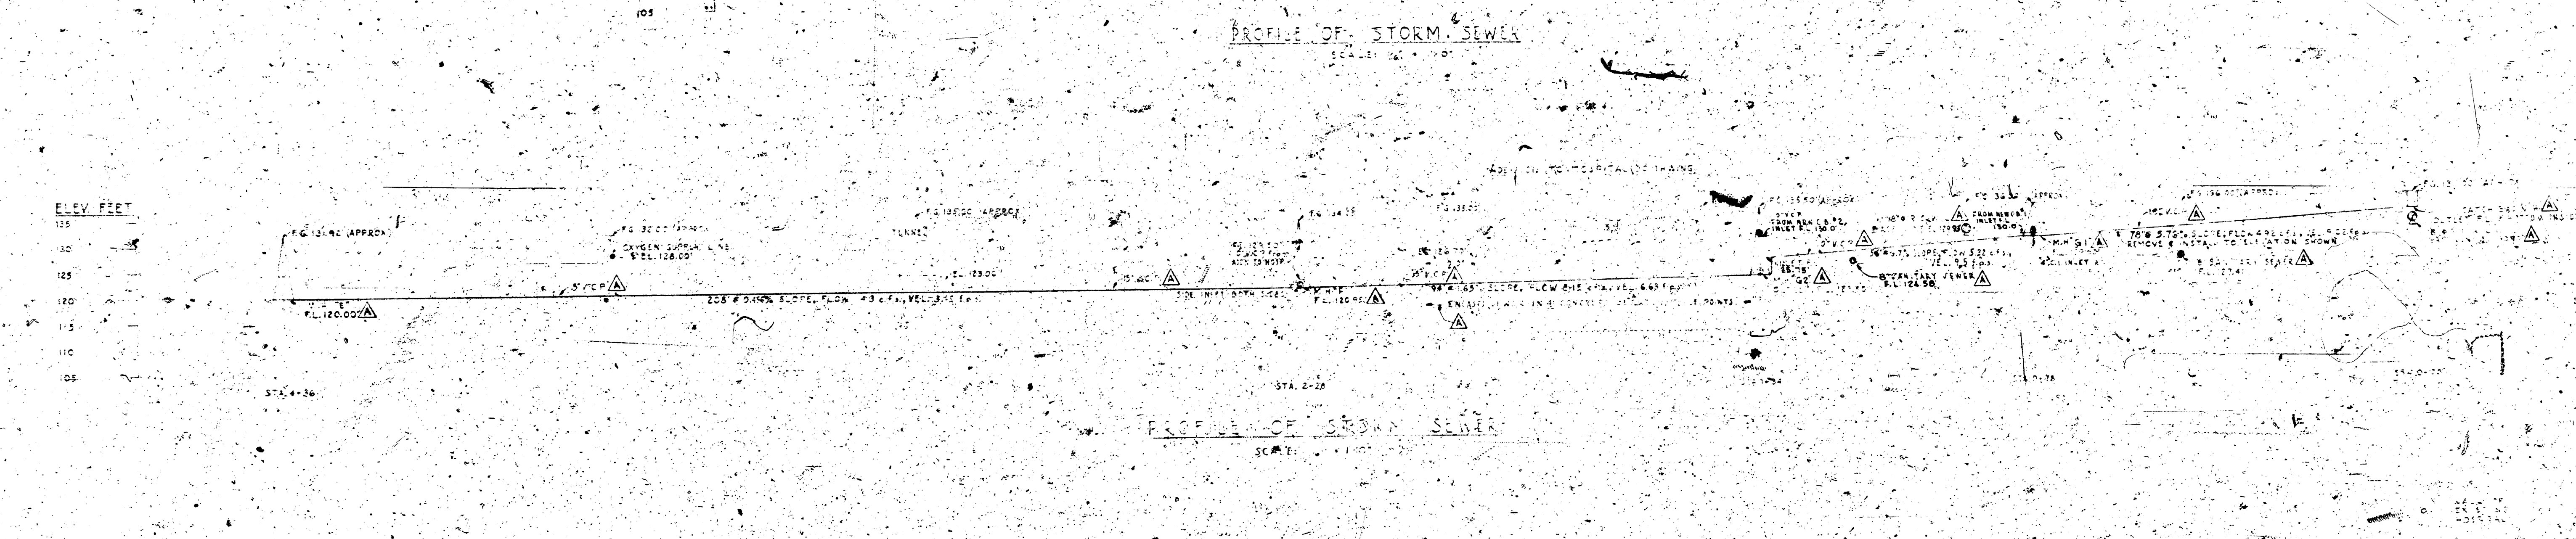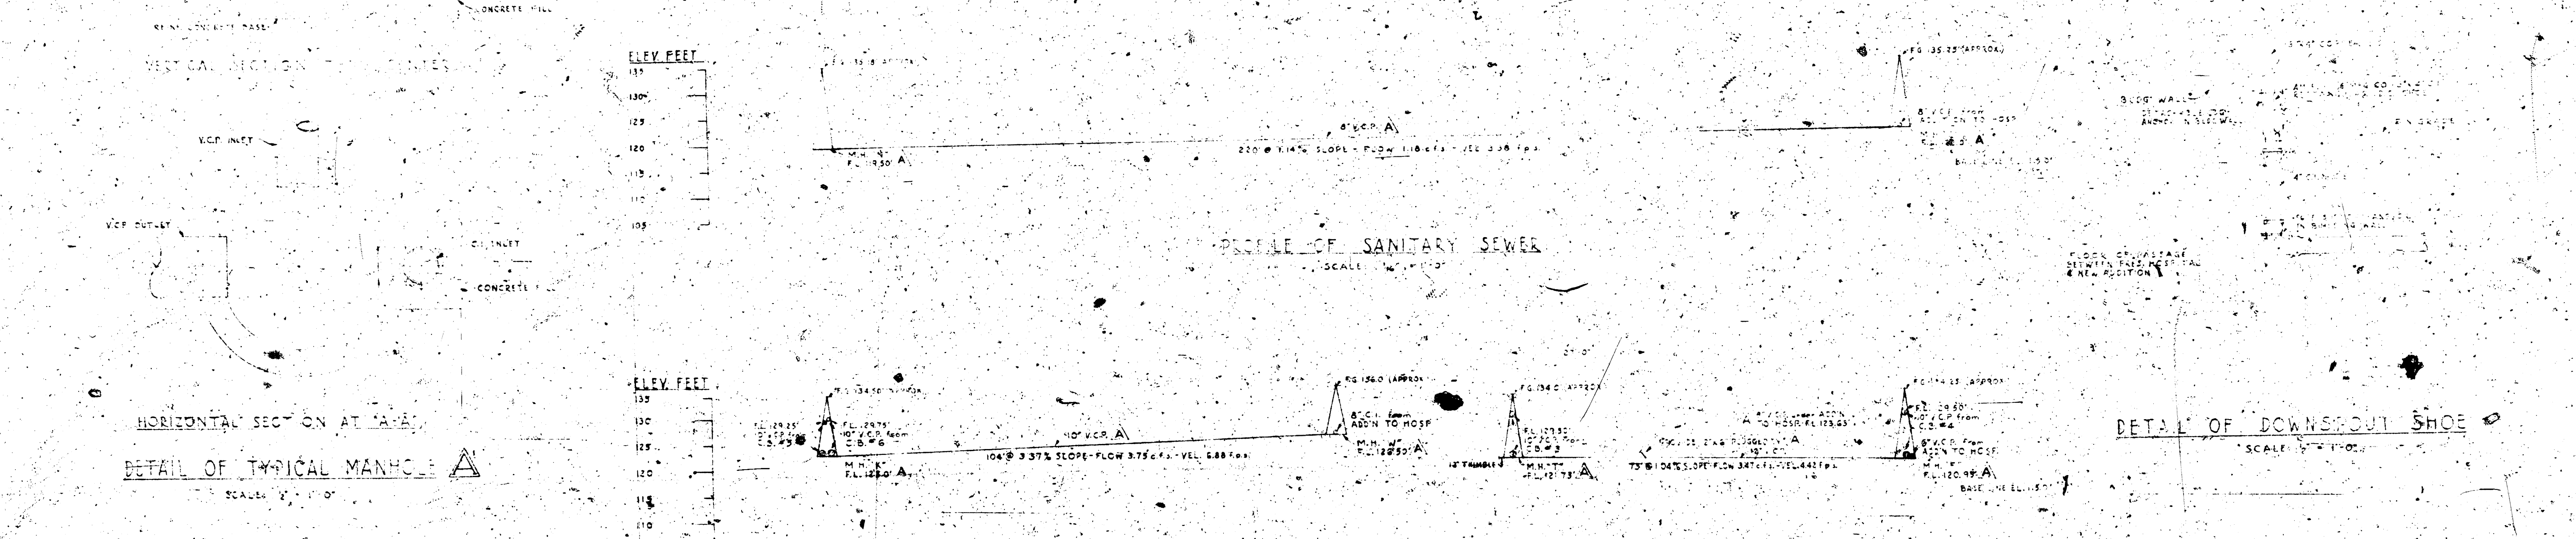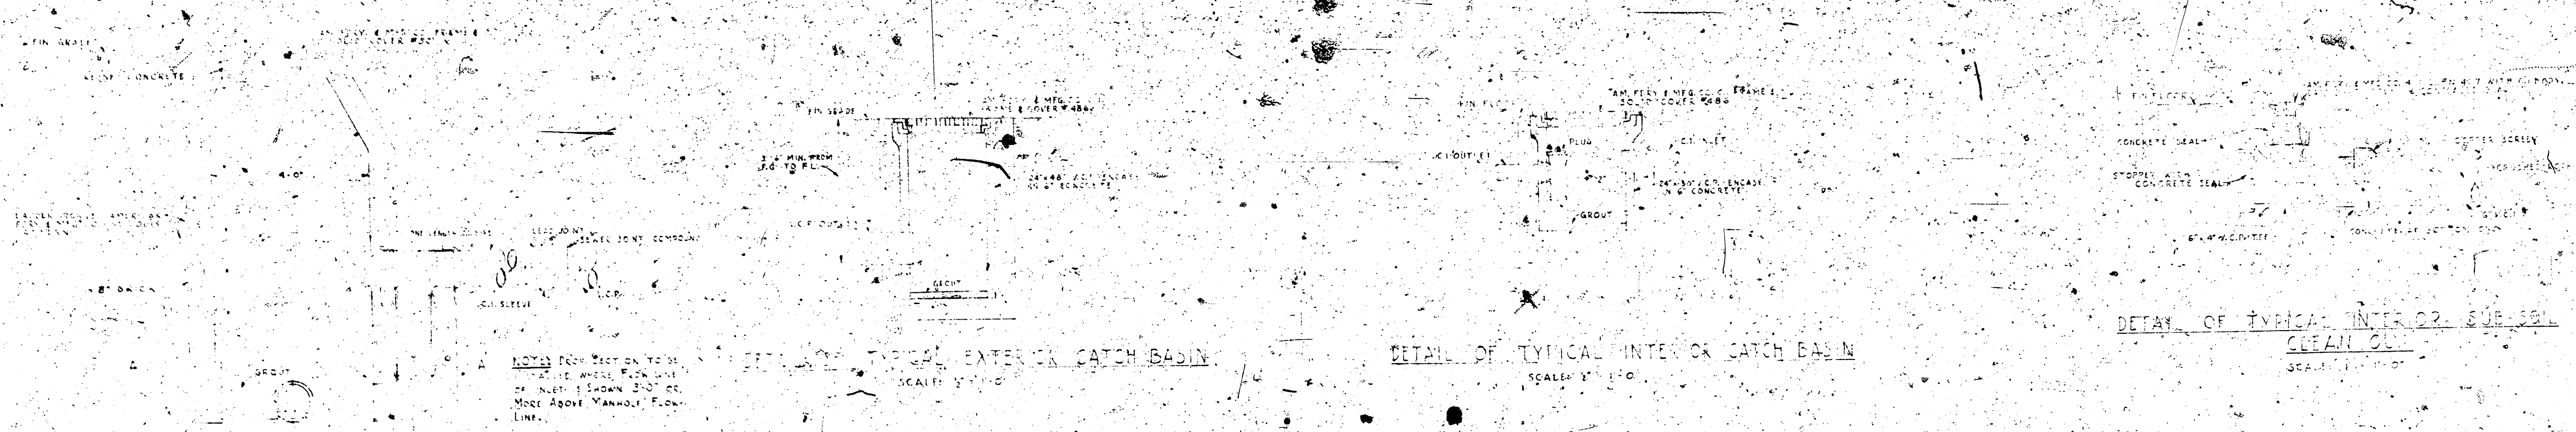

REVISIONS	ST. JOSEPH'S HOSPITAL SISTERS OF ST. JOSEPH MICHIGAN
1	PROFILES & DETAILS
2	MAGUOLO AND QUICK ARCHITECTS - ENGINEERS
3	DETROIT, MICH. MINNEAPOLIS, MINN.
4	ST. JOSEPH'S HOSPITAL CINCINNATI, OHIO
5	P-8