



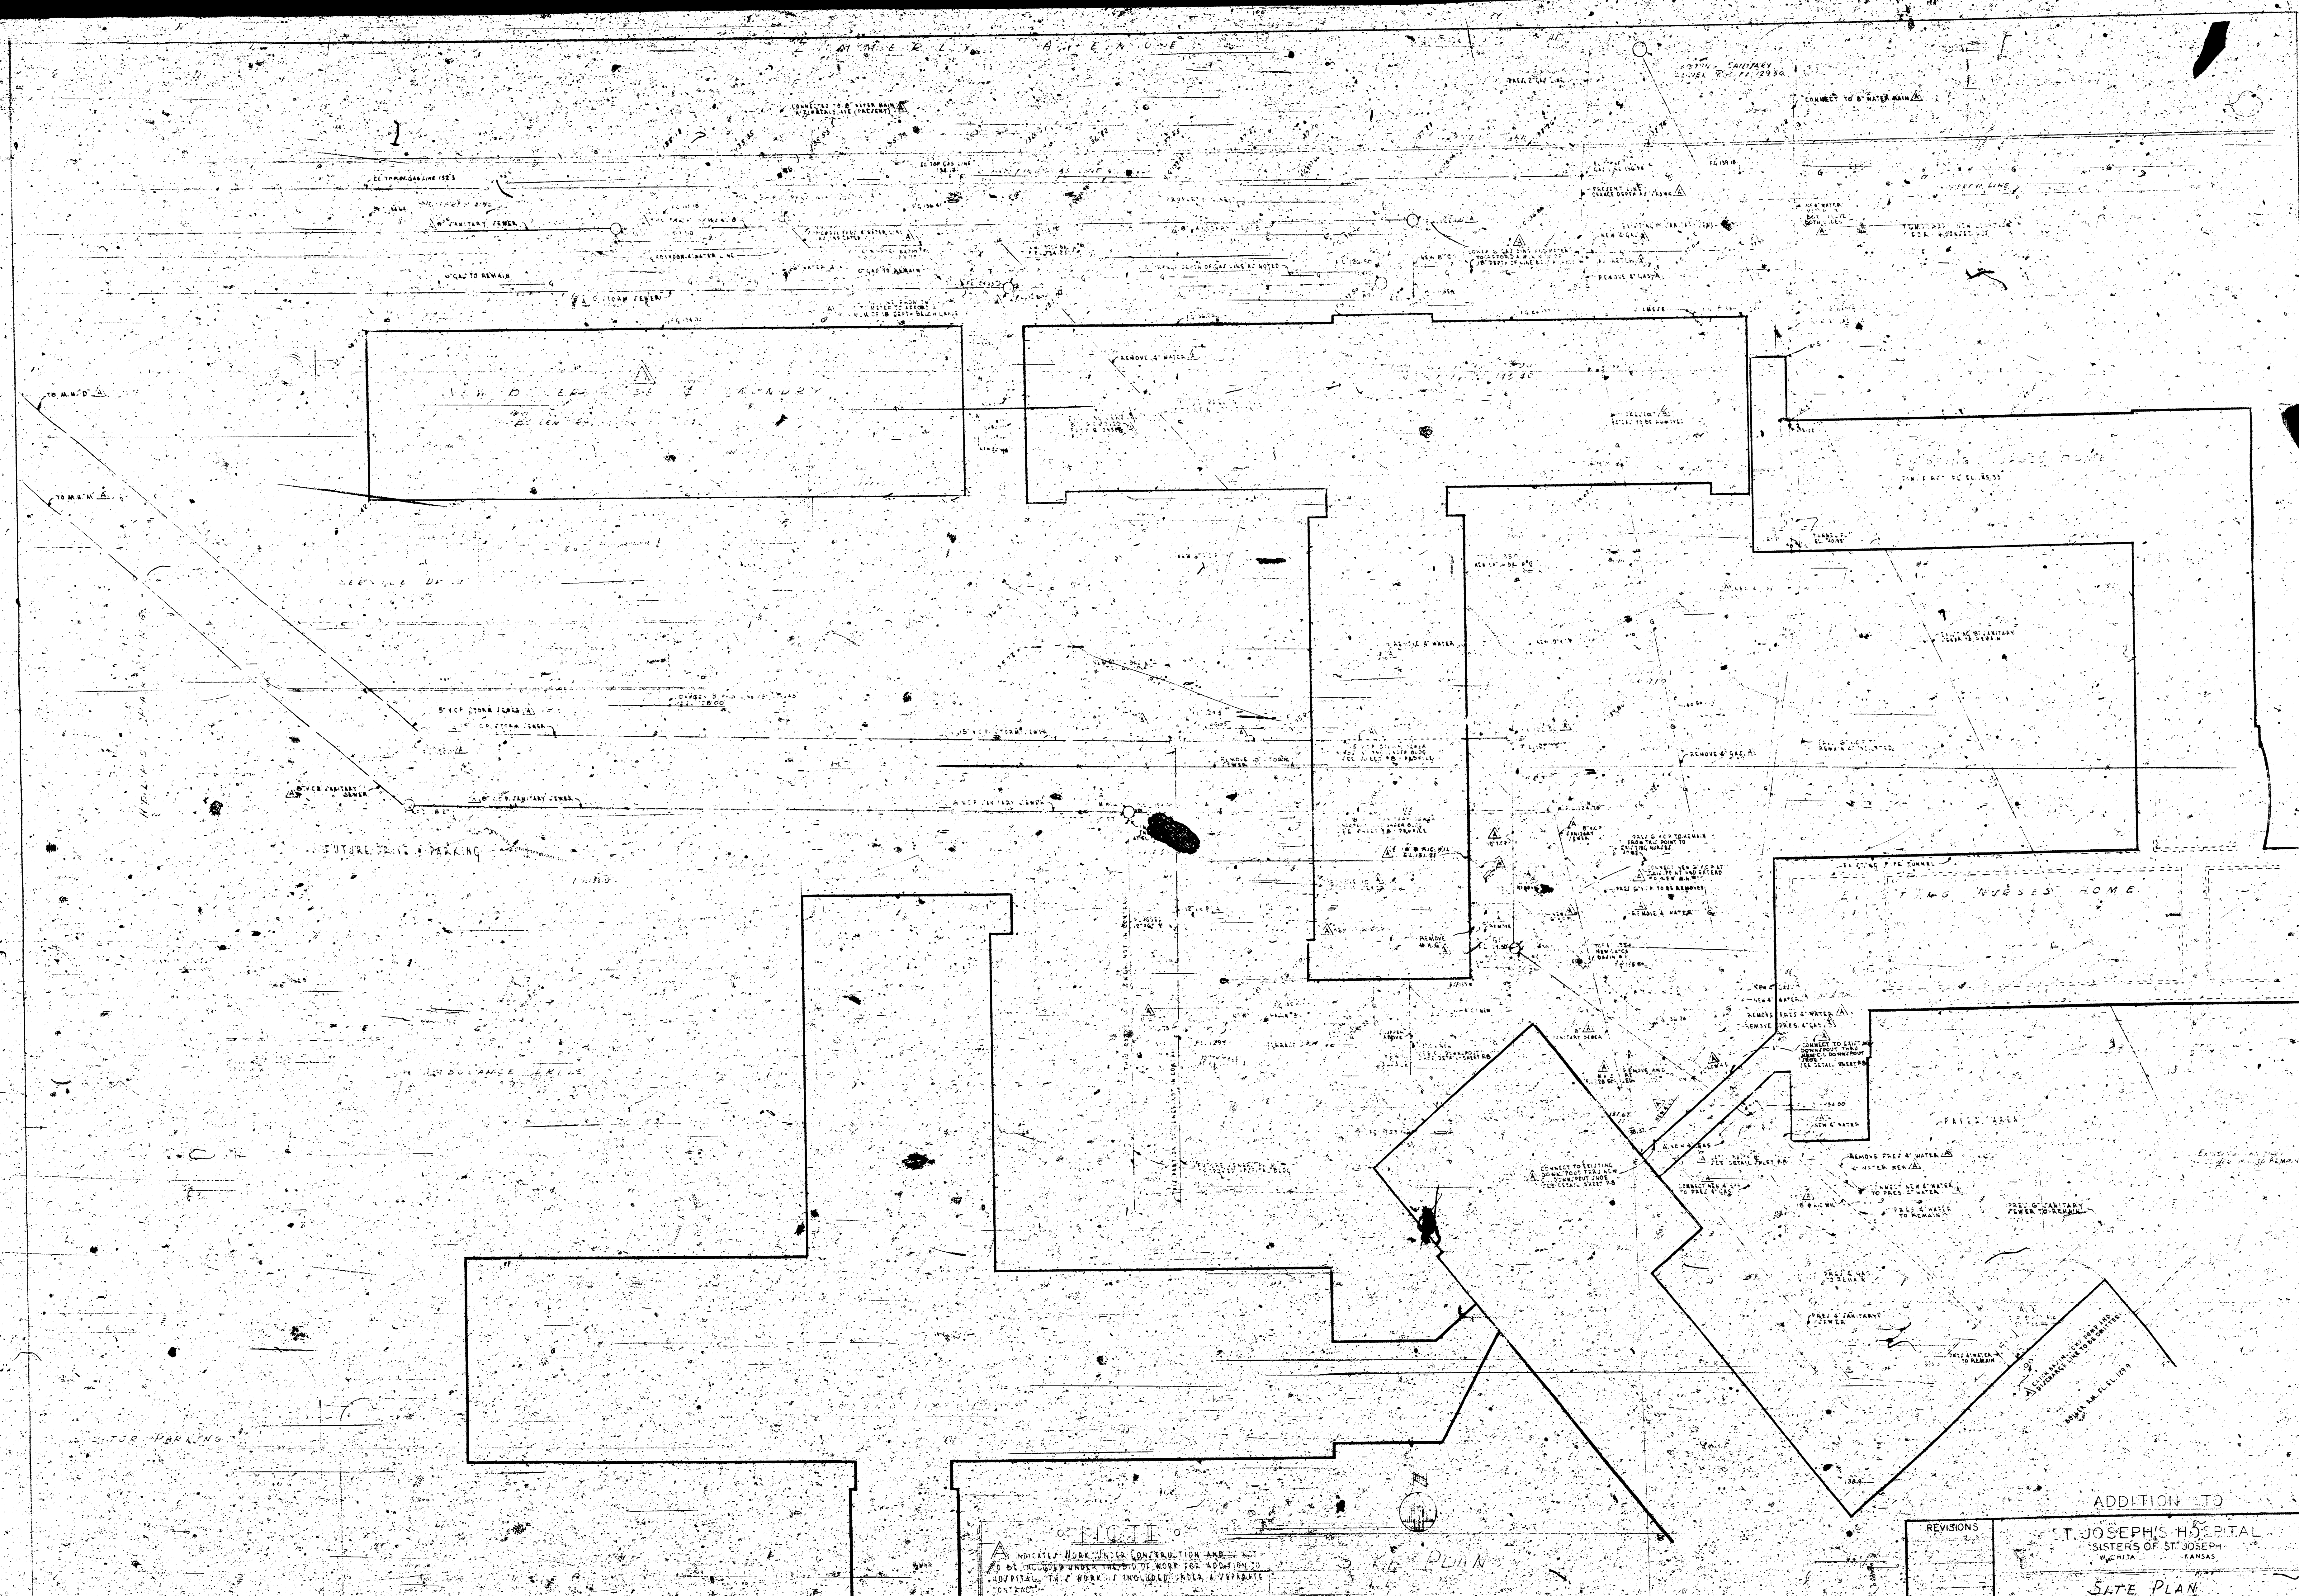

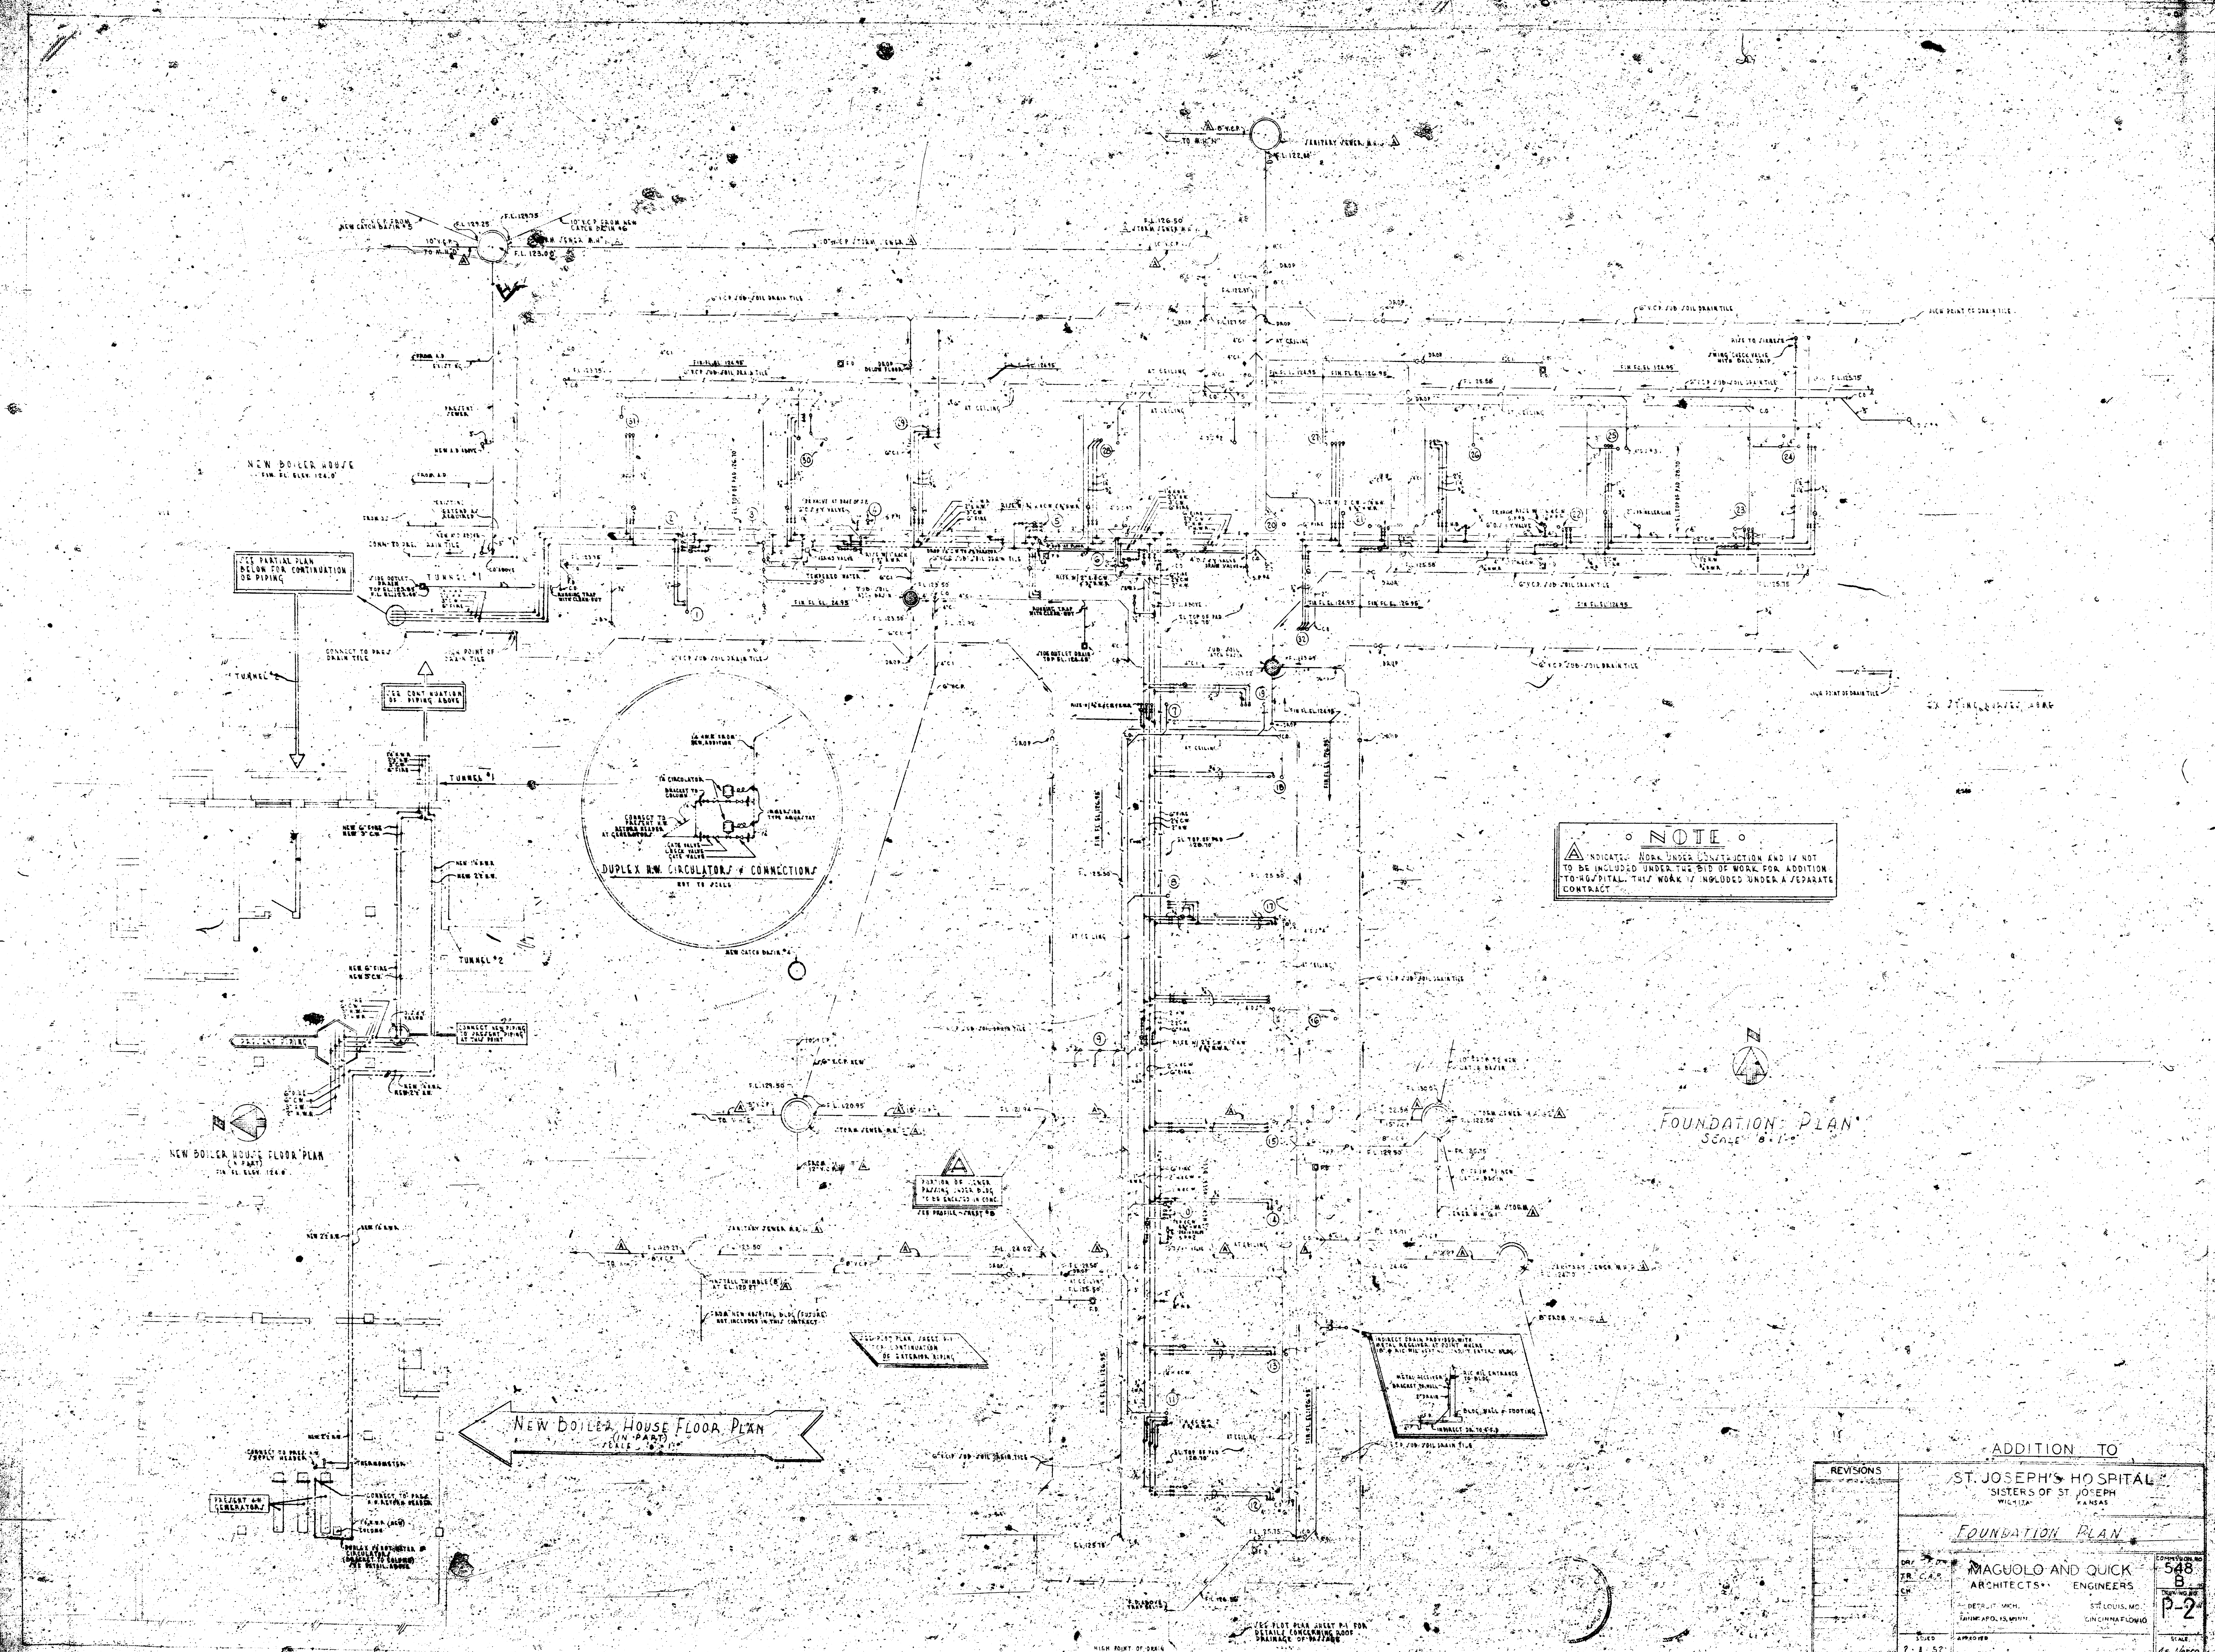



NOTE
 Δ INDICATES WORK UNDER CONSTRUCTION AND IS NOT TO BE INCLUDED UNDER THE BID OF WORK FOR ADDITION TO HOSPITAL. THIS WORK IS INCLUDED UNDER A SEPARATE CONTRACT.

FOUNDATION PLAN
 Scale: 1/4" = 1'-0"

NEW BOILER HOUSE FLOOR PLAN
 (IN PART)
 Scale: 1/4" = 1'-0"

REVISIONS		ADDITION TO	
		ST. JOSEPH'S HOSPITAL	
		SISTERS OF ST. JOSEPH	
		KANSAS	
		FOUNDATION PLAN	
DATE	BY	MAGUOLO AND QUICK	
		ARCHITECTS & ENGINEERS	
		548	
		P-2	
		SIGNED BY	
		DATE	
		APPROVED	
		DATE	

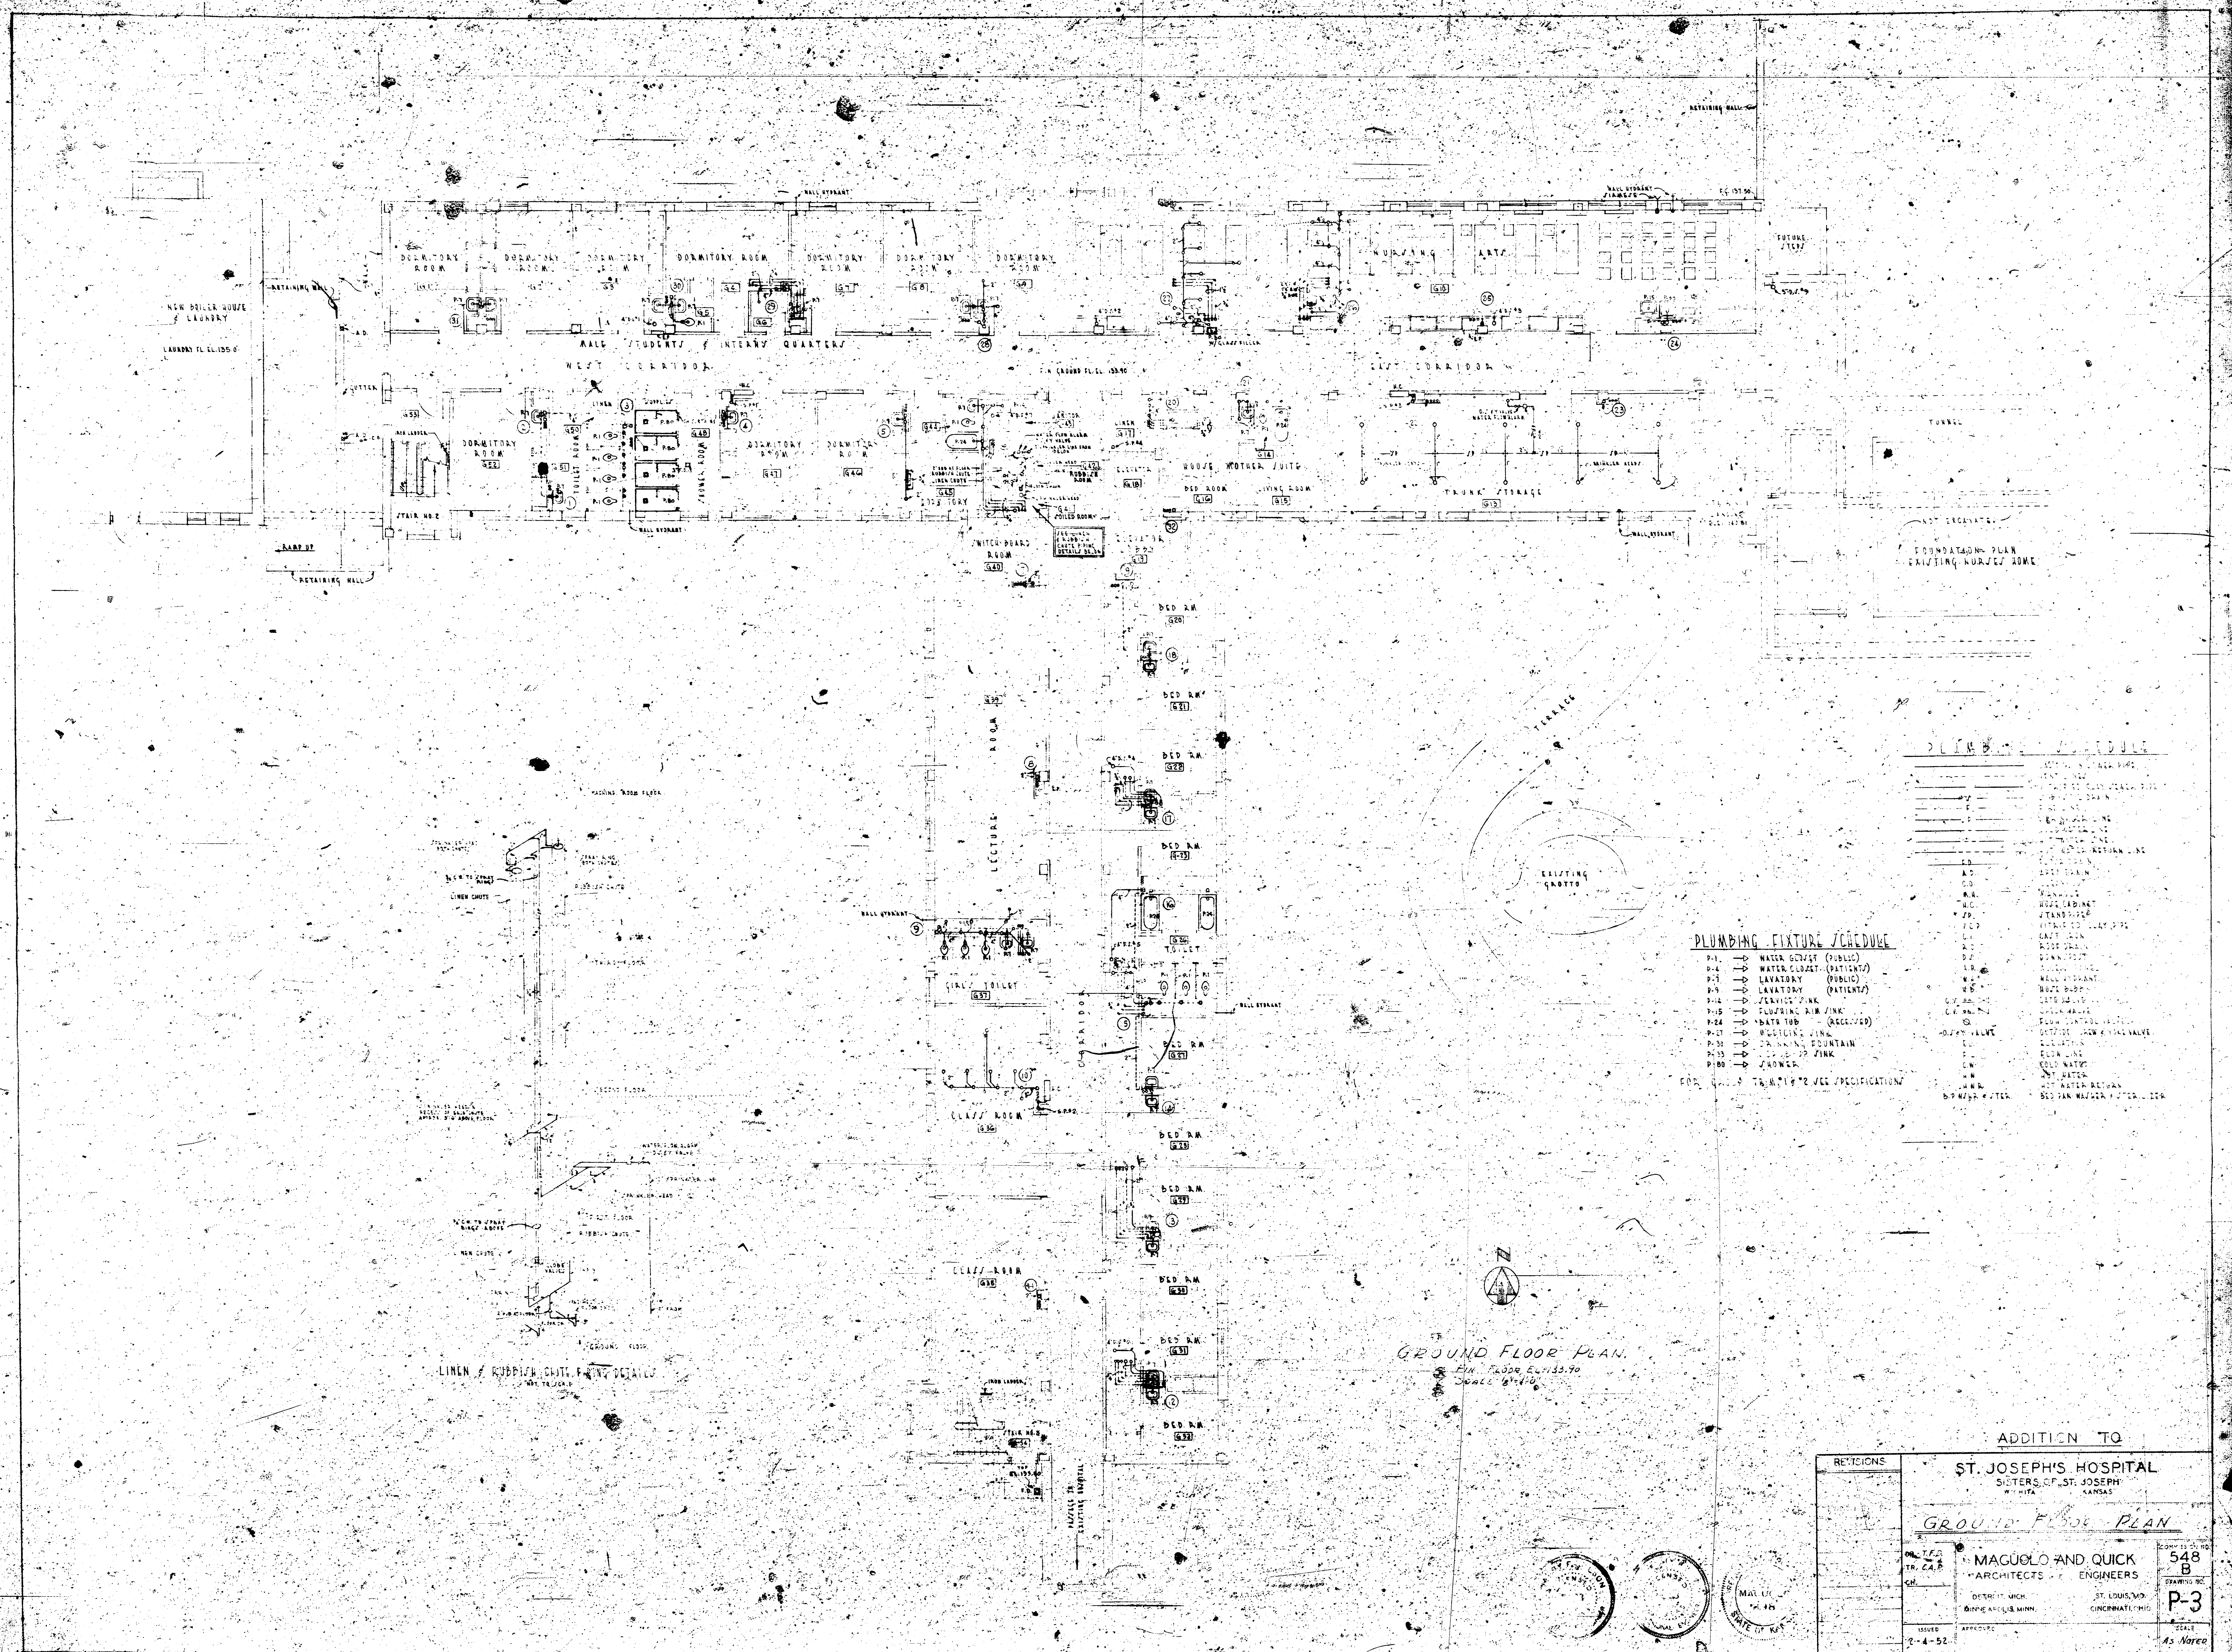


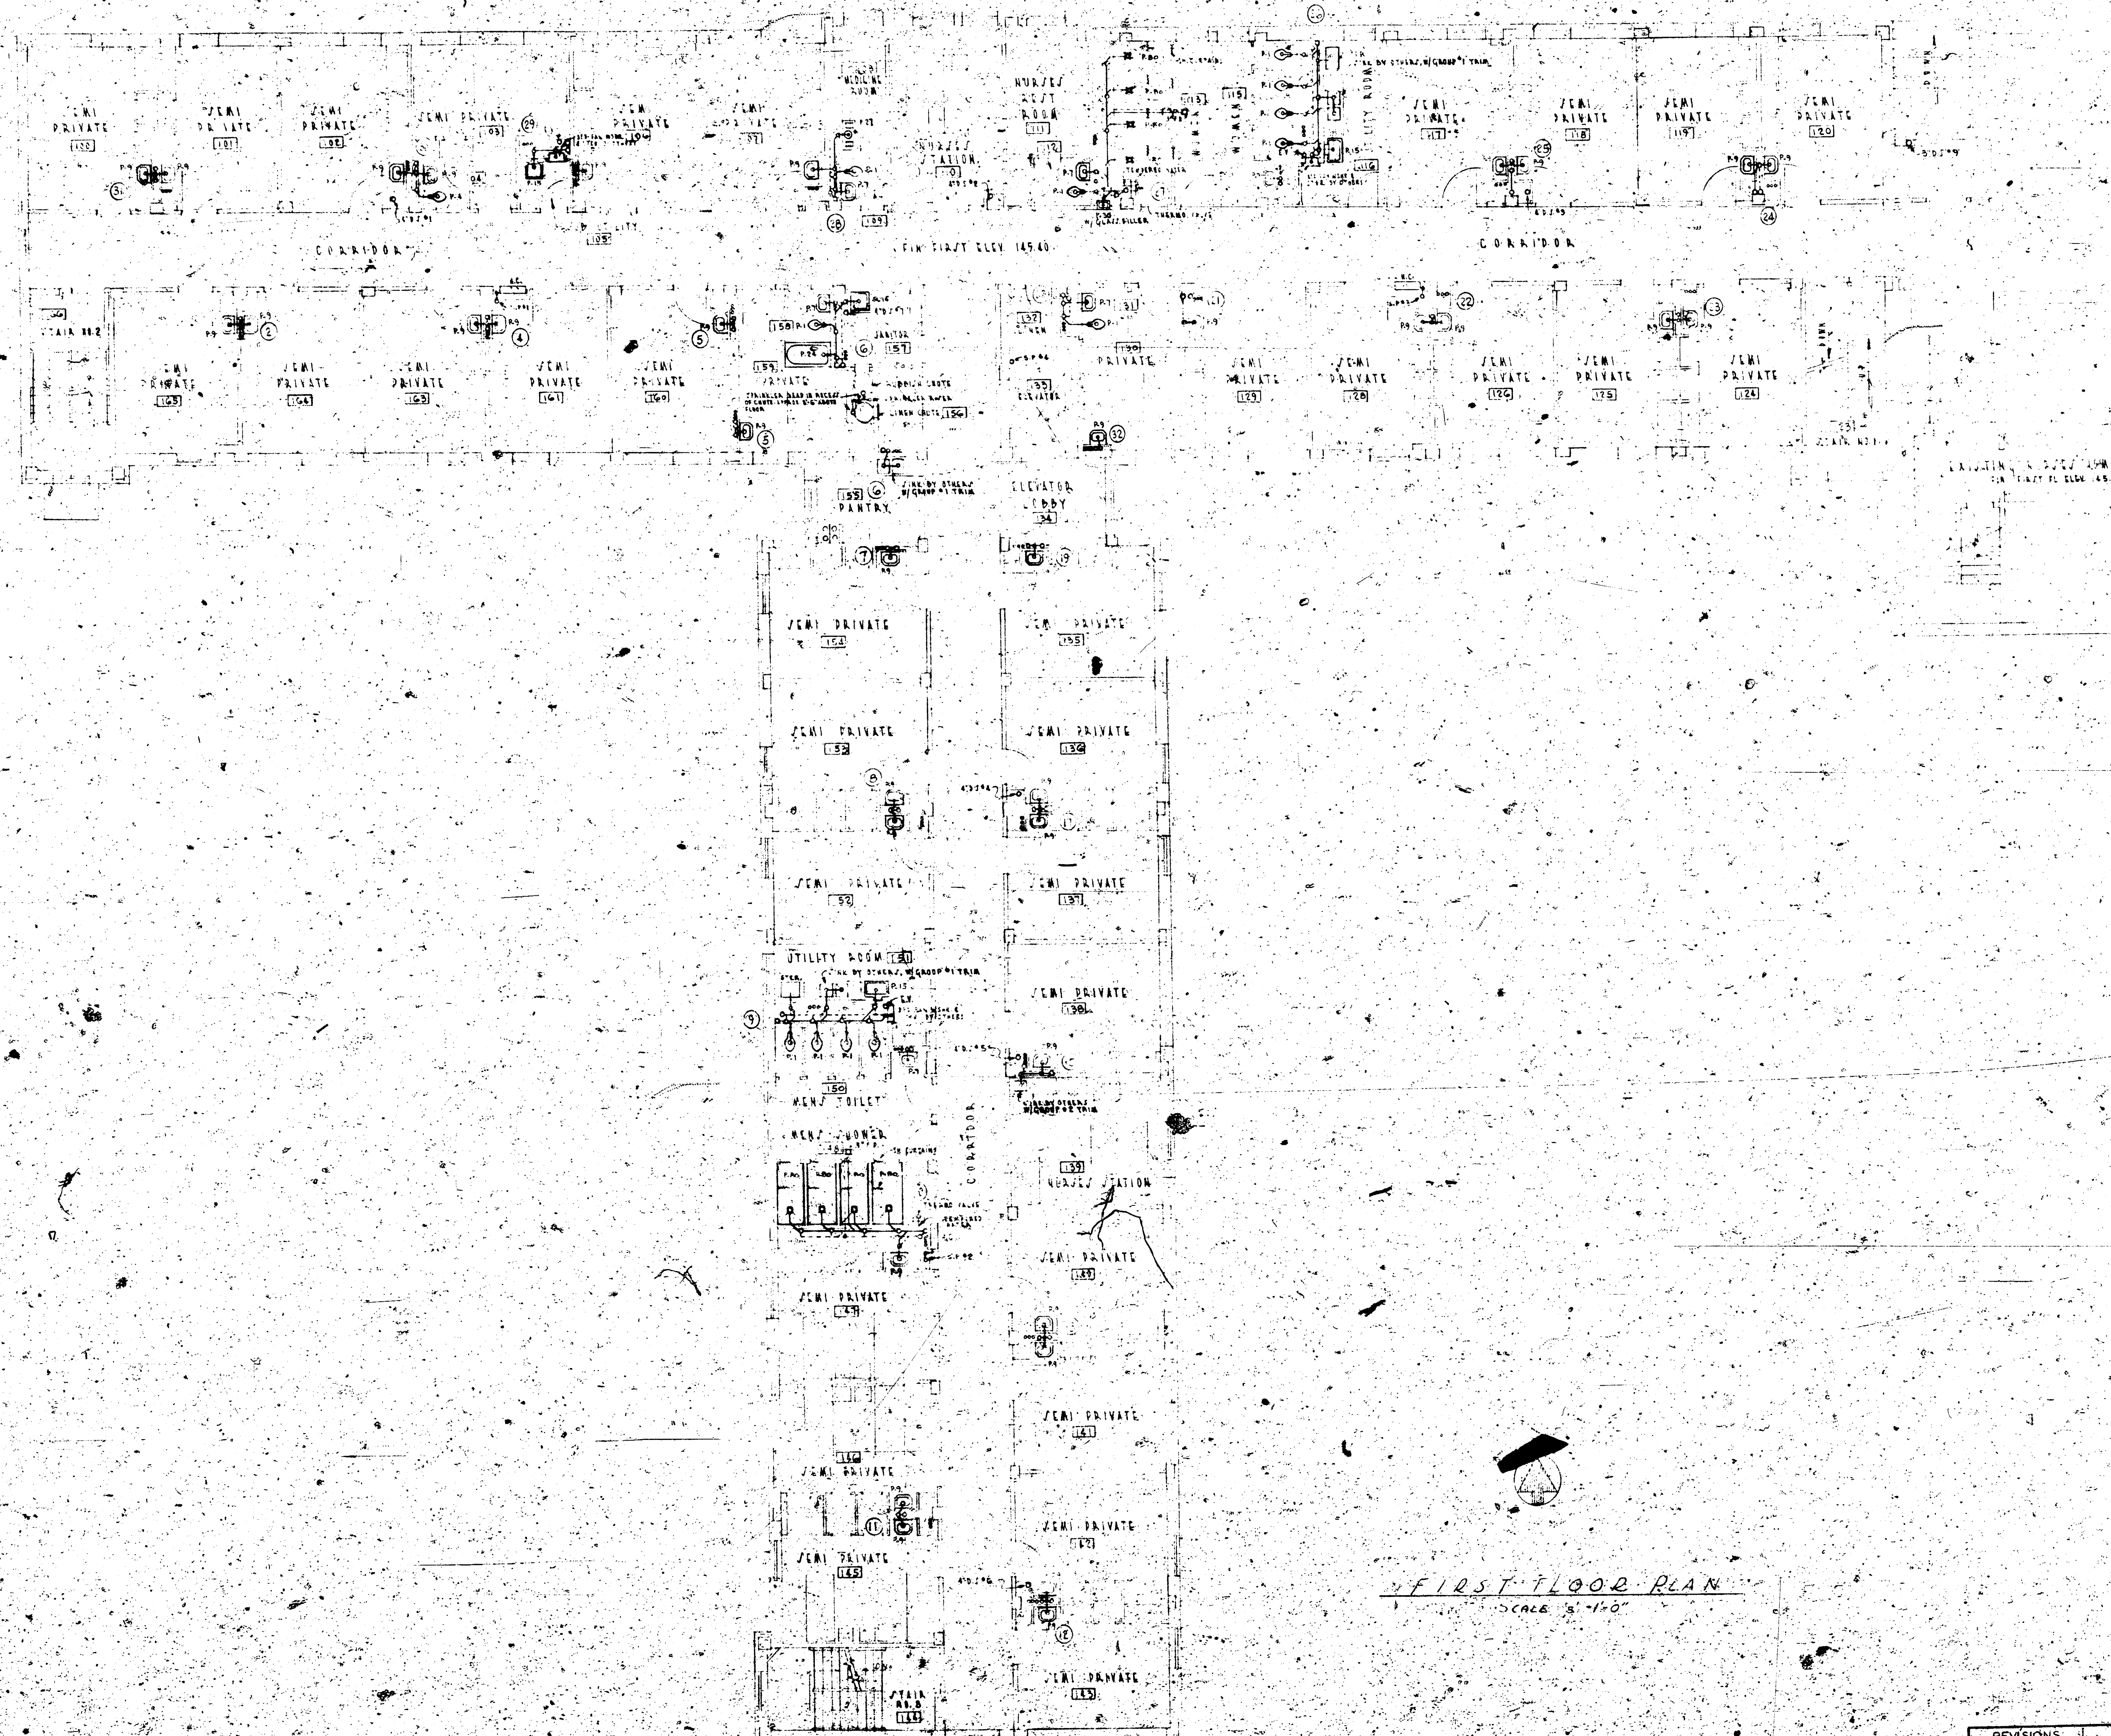


FIRST FLOOR PLAN
SCALE 1/8" = 1'-0"

PASSAGE TO EXISTING BUILDING
AT CORNER FLUSH WITH
EXISTING WALL. SEE DETAIL
CONCERNING SHOP DRAWING AT 11-11-11

REVISIONS		ADDITION TO	
		ST. JOSEPH'S HOSPITAL	
		SISTERS OF ST. JOSEPH	
		ST. LOUIS, MO.	
		FIRST FLOOR PLAN	
DR. T.A.B.	MAGUOLO AND QUICK	548	
TR. C.A.A.	ARCHITECTS	B	
ENR.	ENGINEERS	P-4	
ST. LOUIS, MO.	ST. LOUIS, MO.		
MINNEAPOLIS, MINN.	MINNEAPOLIS, MINN.		
ISSUED	APPROVED		
2-4-50			

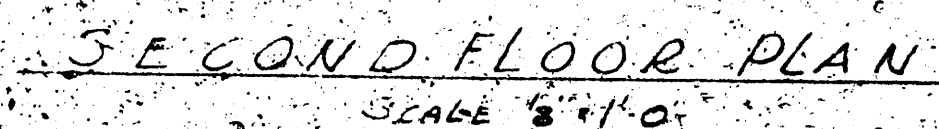

REVISIONS	ST. JOSEPH'S HOSPITAL SISTERS OF ST. JOSEPH WEHITA KANSAS		548 B DRAWING P-5	
	SECOND FLOOR PLAN		DETROIT MICH ST. LOUIS, MO. MANNECAPULU, KIRRI C. IN INTERNATIONAL	
	DR. T. G. TR. C. R. CH	MAGUILO AND QUICK ARCHITECTS - ENGINEERS		
	ISSUED 2-4-62	APPROVED	SCALE	1" = 8'

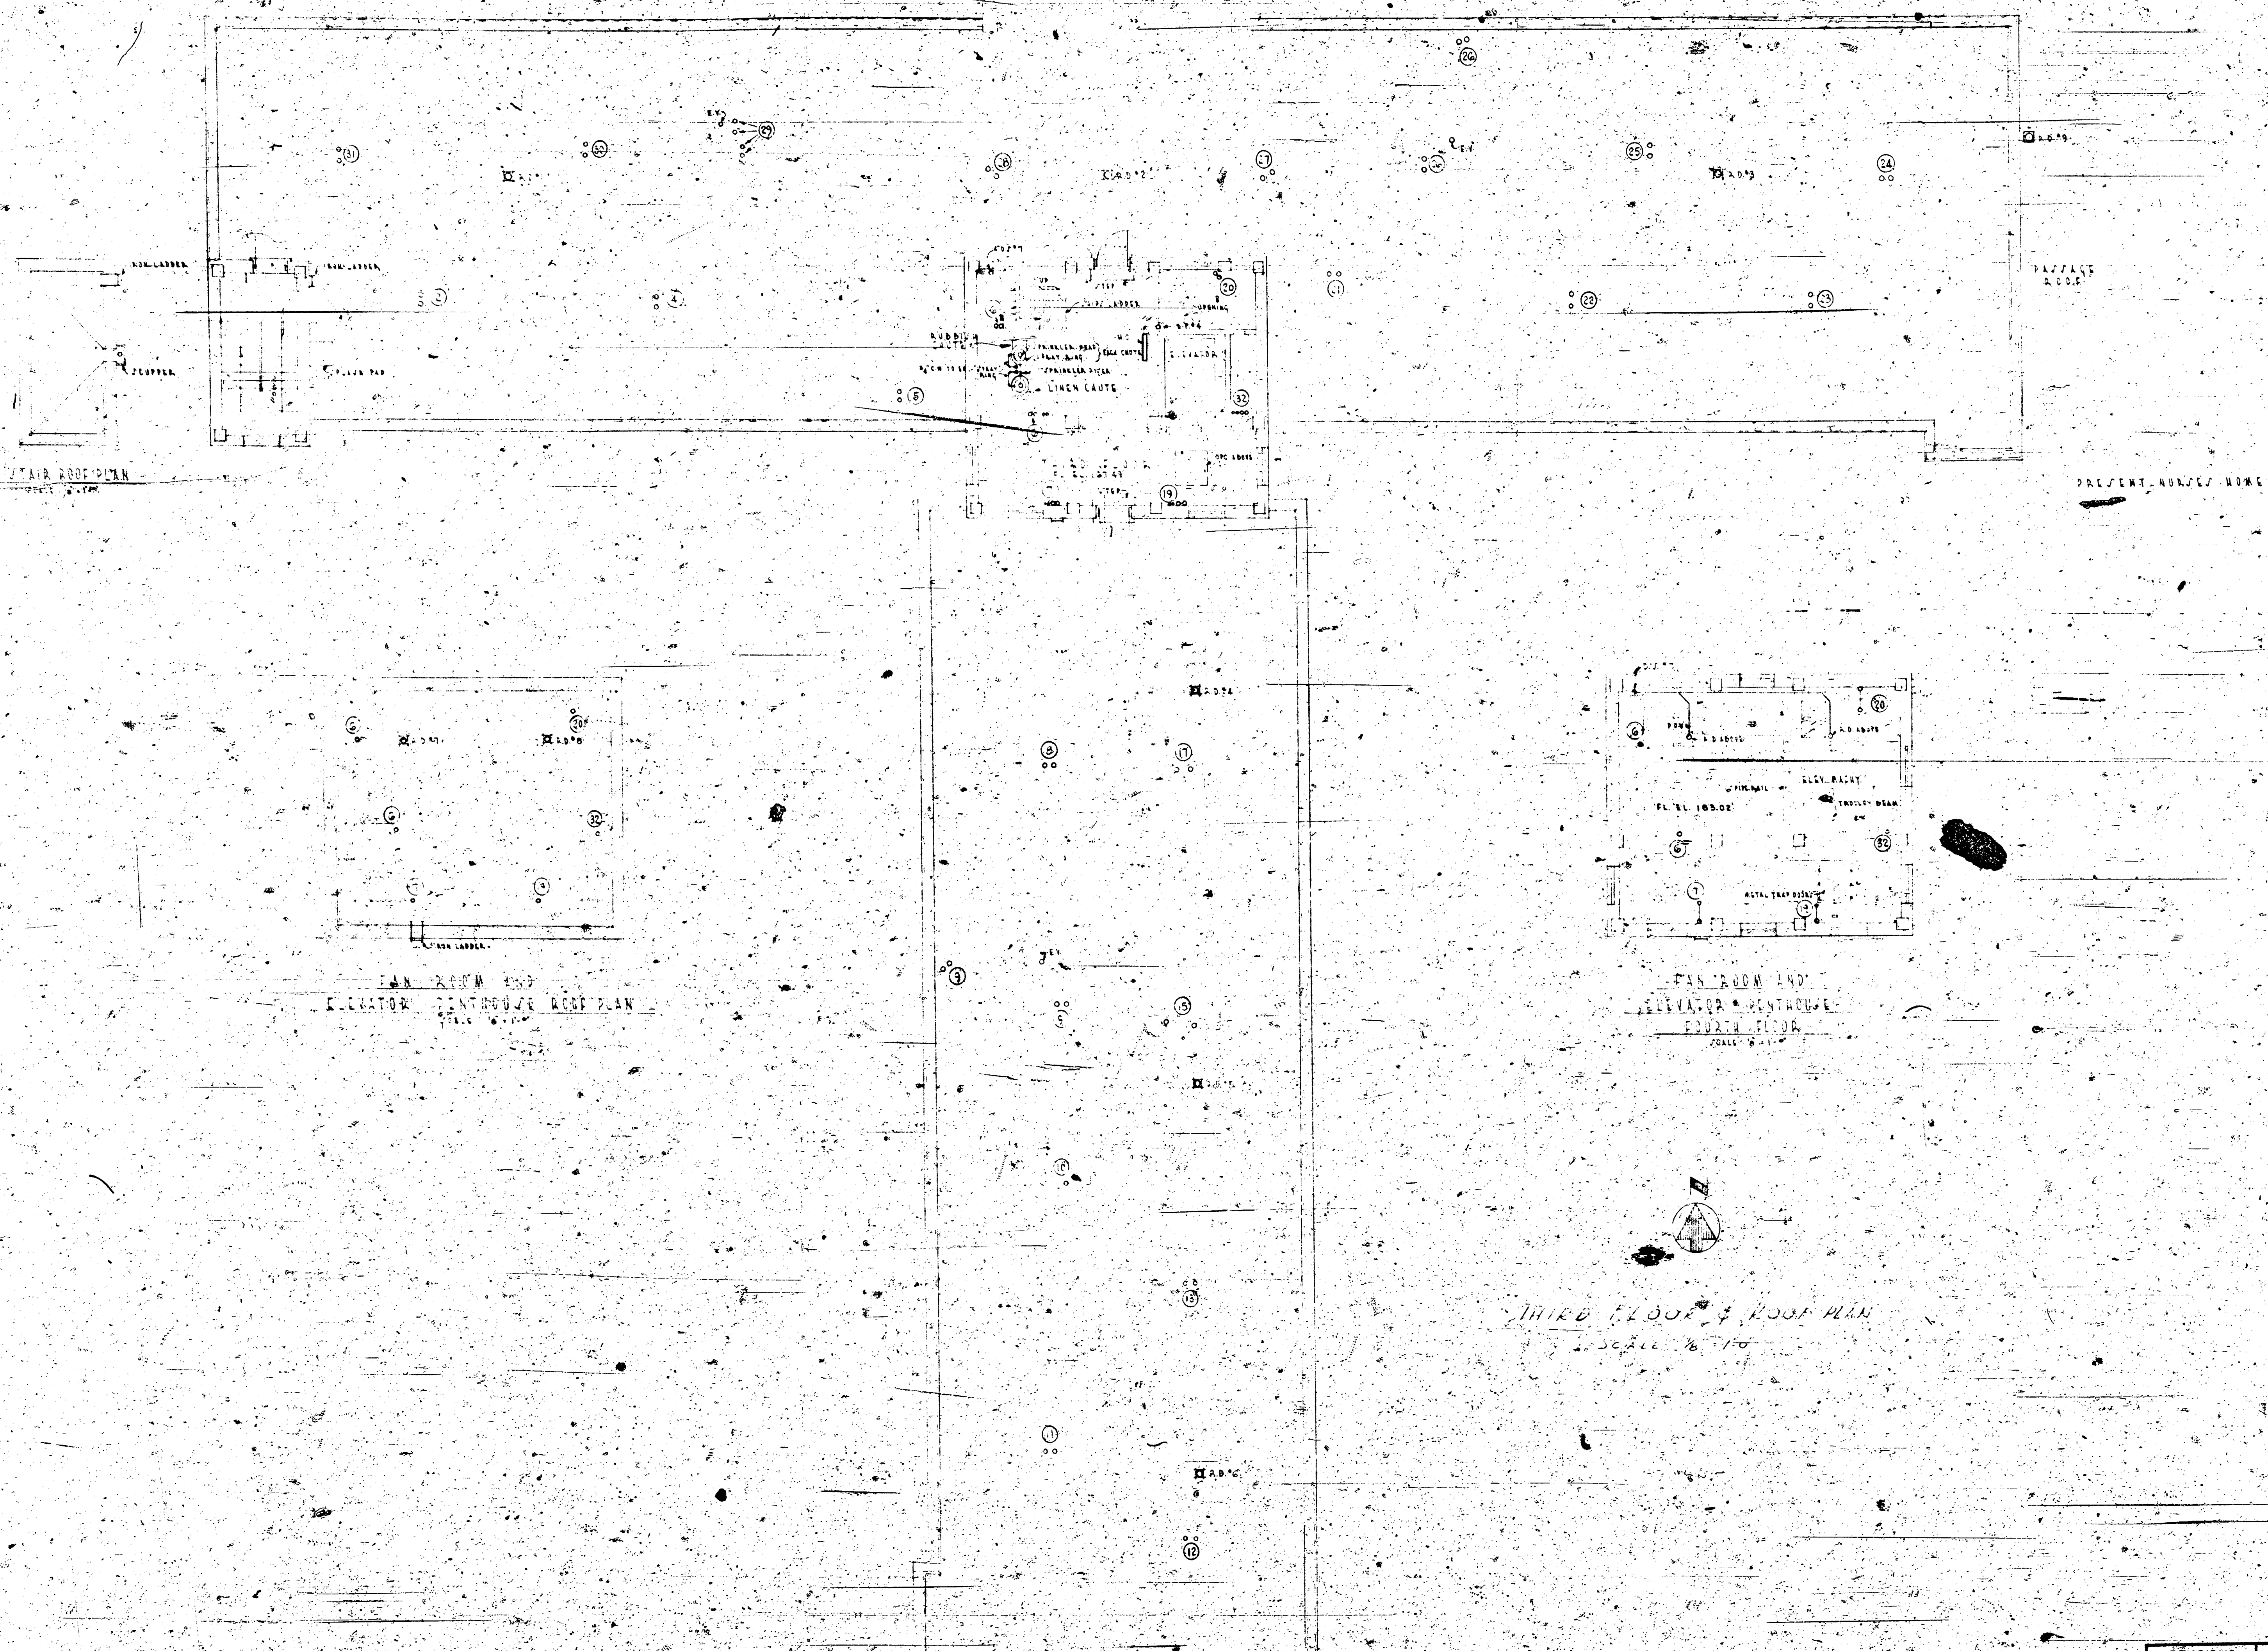

THIRD FLOOR & ROOF PLAN
SCALE 1/8" = 1'-0"

ADDITION TO

ST. JOSEPH'S HOSPITAL
SISTERS OF ST. JOSEPH
KANSAS CITY, MISSOURI

THIRD FLOOR & ROOF PLAN

DR. T. B. B.
TR. C. A. A.
CH. S.

MAGUOLO AND QUICK
ARCHITECTS - ENGINEERS


DETROIT, MICH.
MINNEAPOLIS, MINN.
ST. LOUIS, MO.
CINCINNATI, OHIO.


ISSUED 7-4-52
REVISED
SCALE
As Shown

548

P-6


As Shown

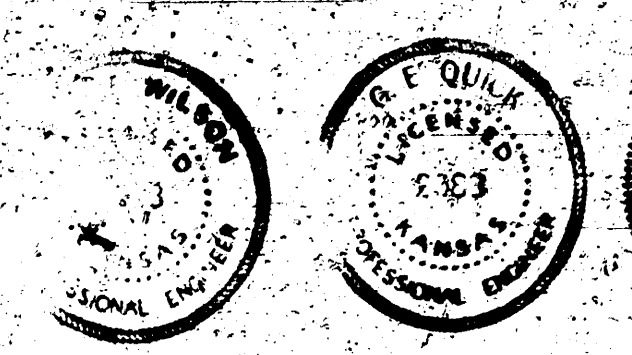




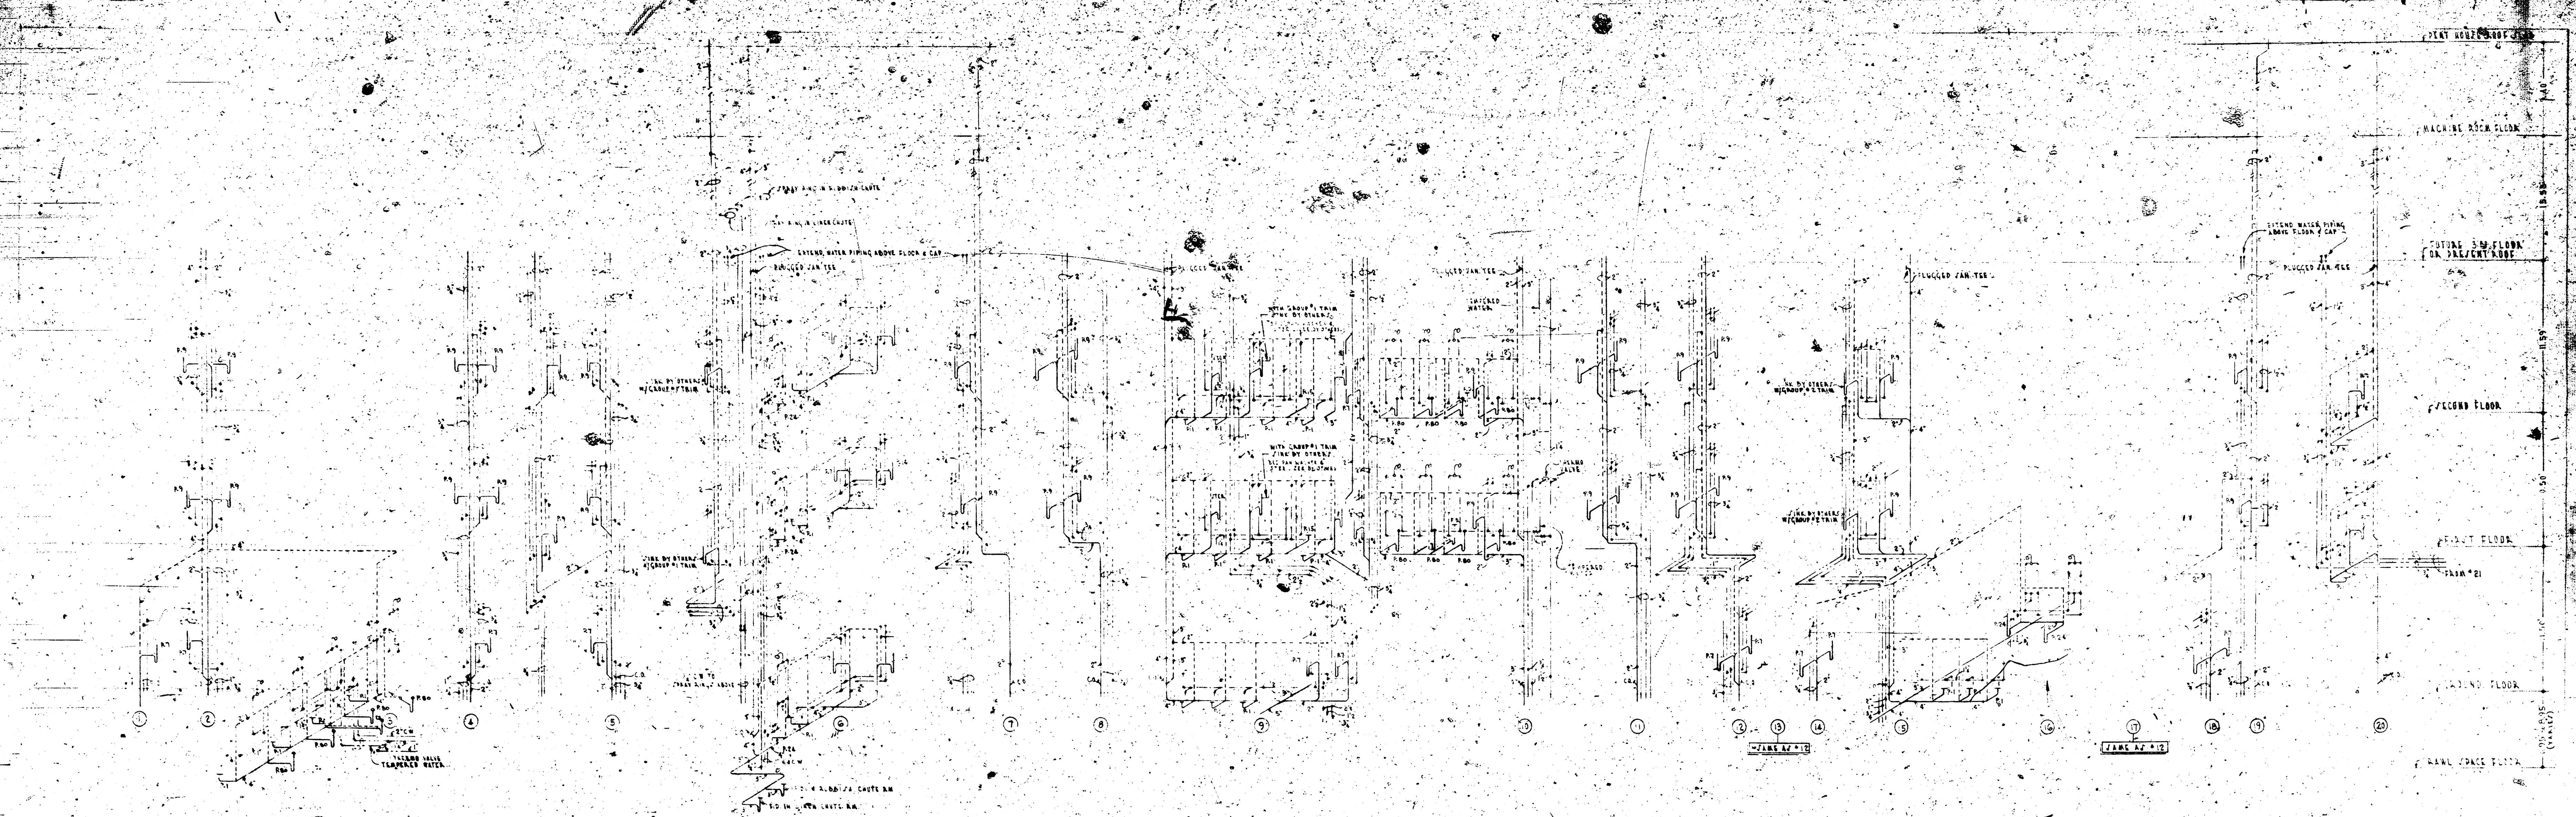


PLUMBING RISER DIAGRAMS

- (1) EXTEND ALL WASTE AND VENT PIPING INDIVIDUALLY THRU FUTURE 5TH FLOOR OR PRESENT ROOF, AND AT TURN WASTE PIPING EXTENDING THRU PENT HOUSE.
- (2) PROVIDE SCHEDULED OPENING ON FLOOR FOR WASTE STACKS FOR FUTURE INSTALLATION OF FLOORING ON 5TH FLOOR, AS INDICATED.
- (3) TERMINATE WATER RISER AT 2ND FLOOR, CEILING OR IN PENT HOUSE, 1ST FLOOR IN FUTURE 5TH FLOOR OR PRESENT ROOF FOR FUTURE EXTENSION OF WATER RISER.

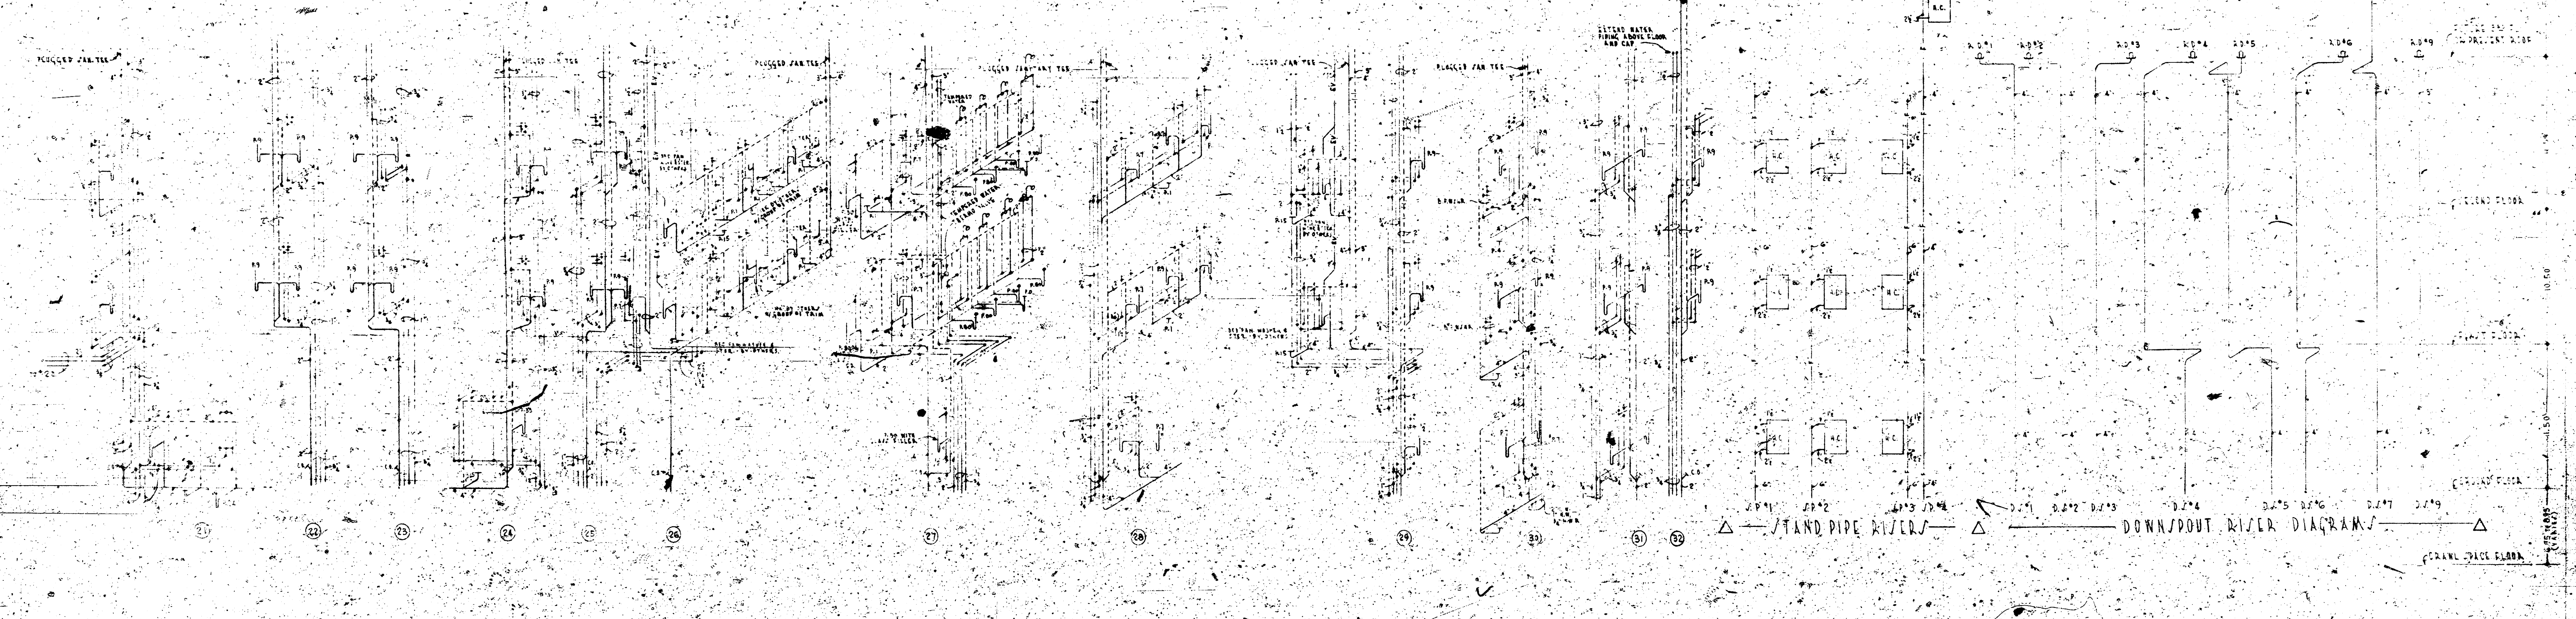

REVISIONS		ADDITION TO	
		ST. JOSEPH'S HOSPITAL SISTERS OF ST. JOSEPH KANSAS CITY, MO.	
		P-7	
		548	
		P-7	
		ARCHITECTS	
		ENGINEERS	
		ST. LOUIS, MO.	
		INDIANAPOLIS, IND.	
		SCALE	
		AS SHOWN	

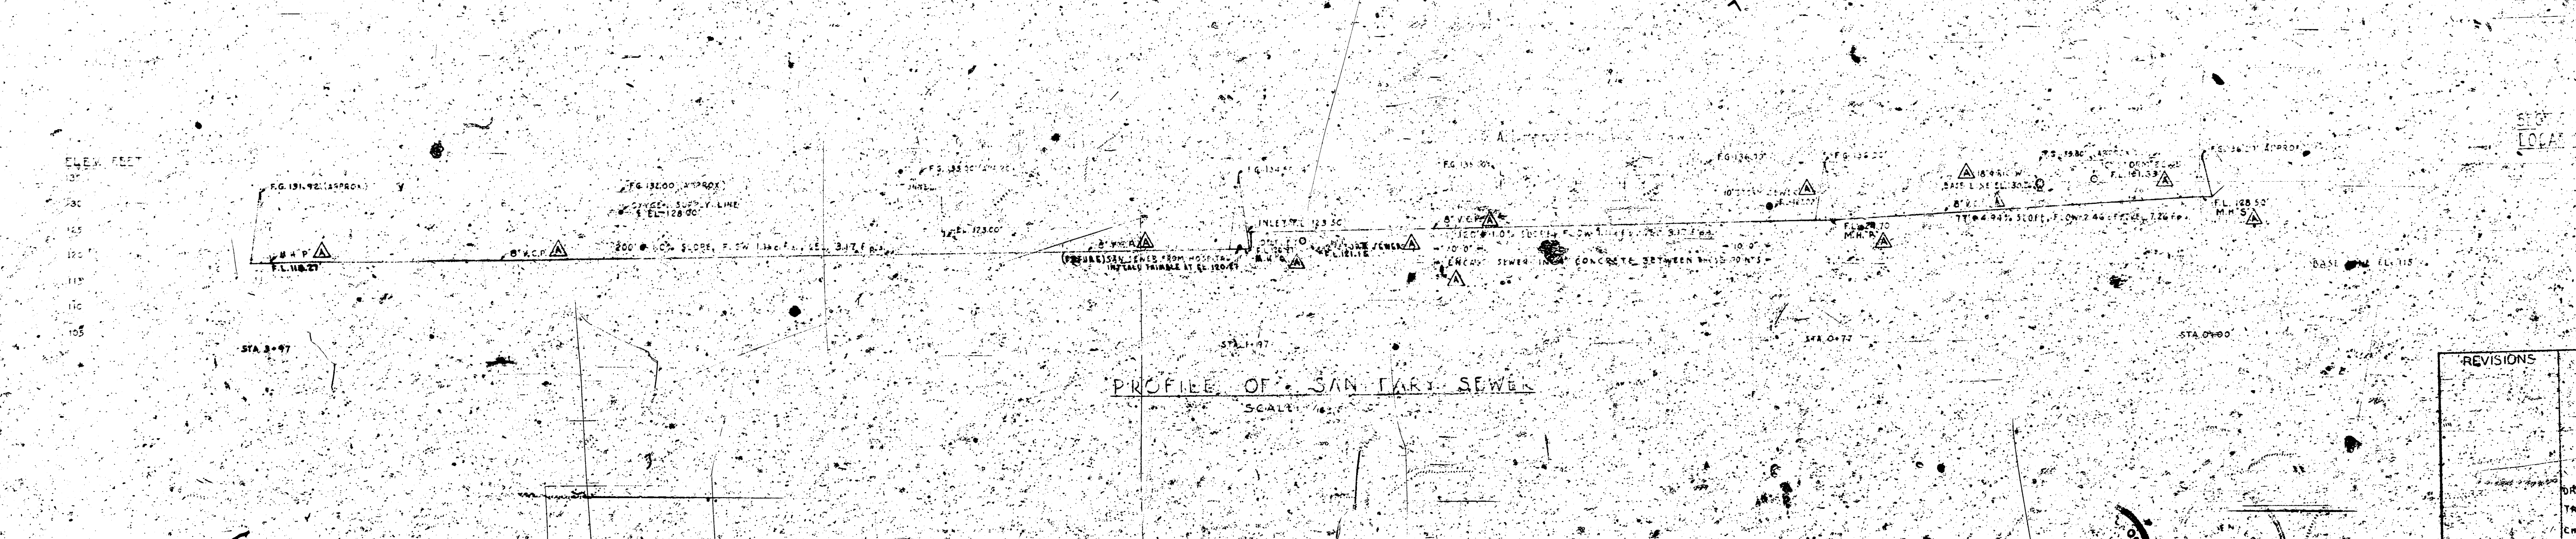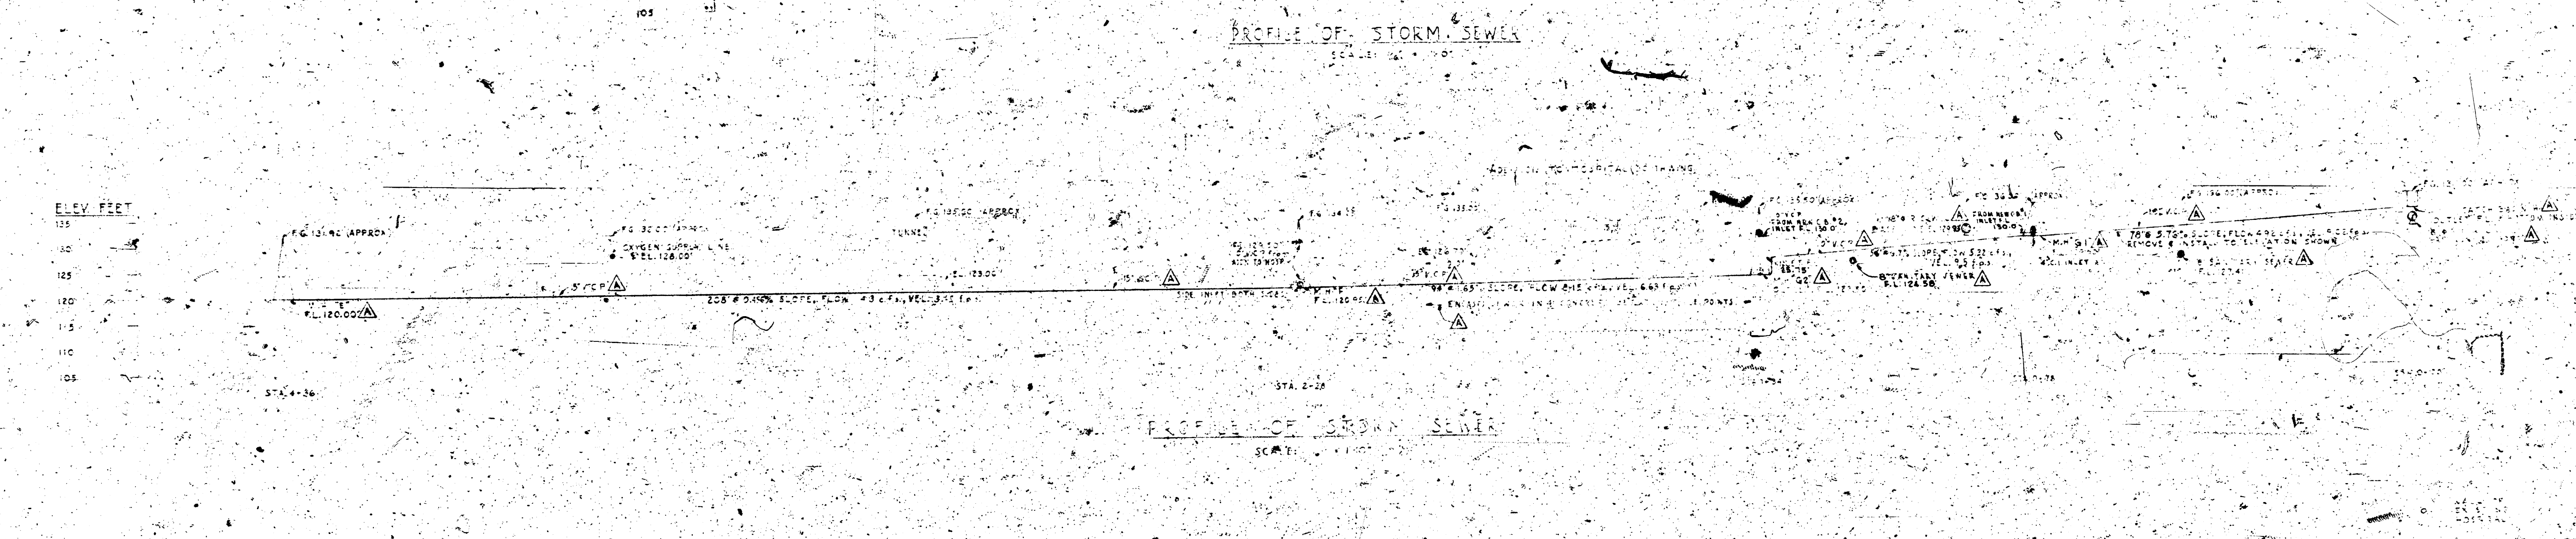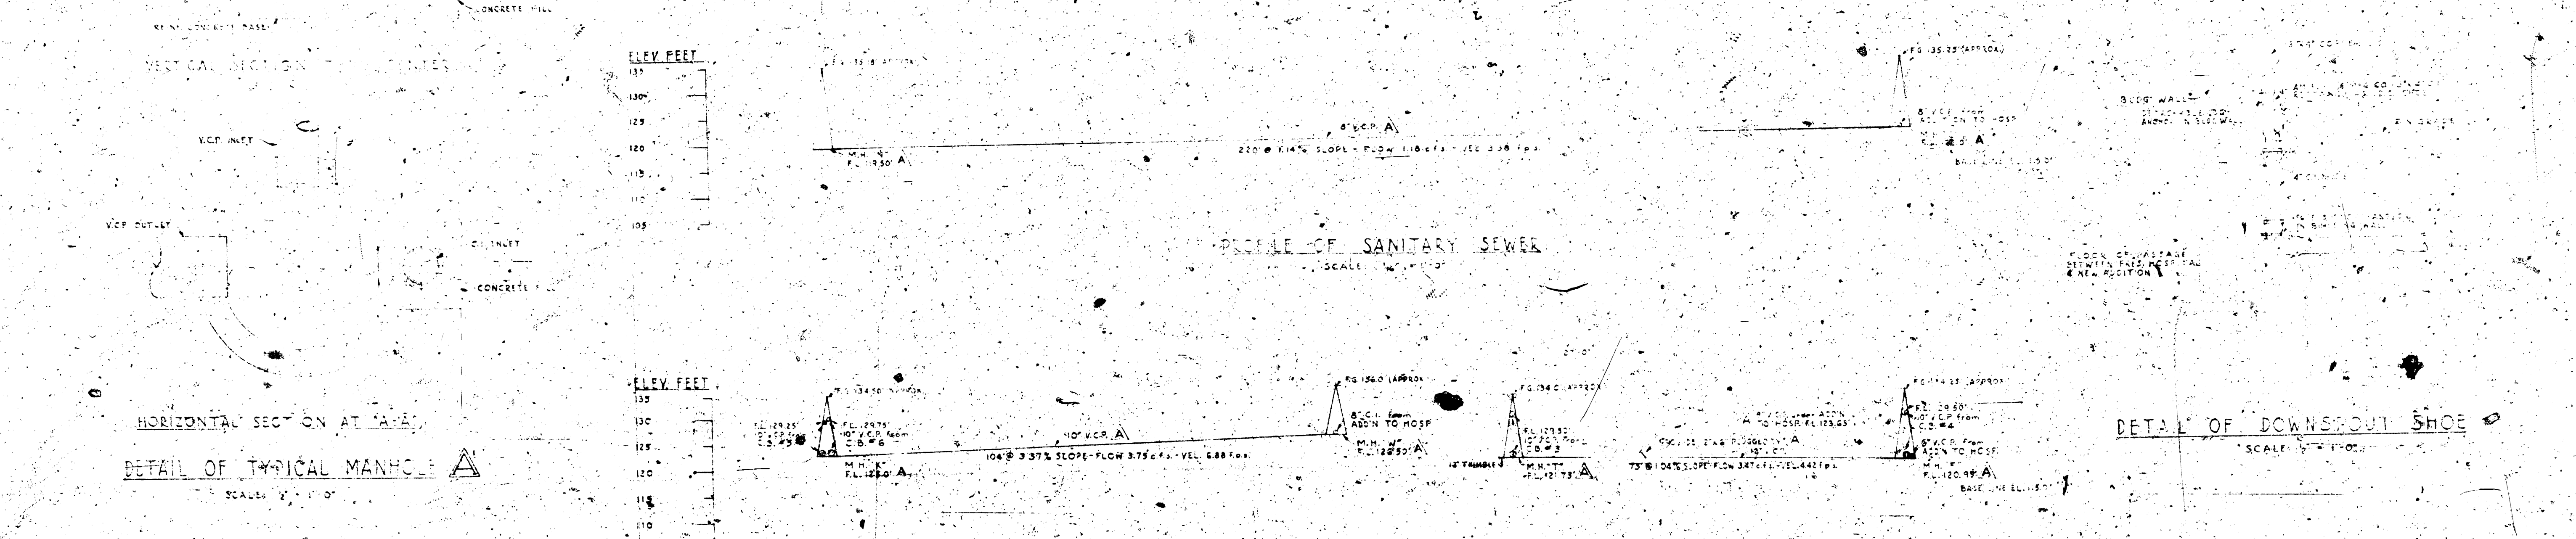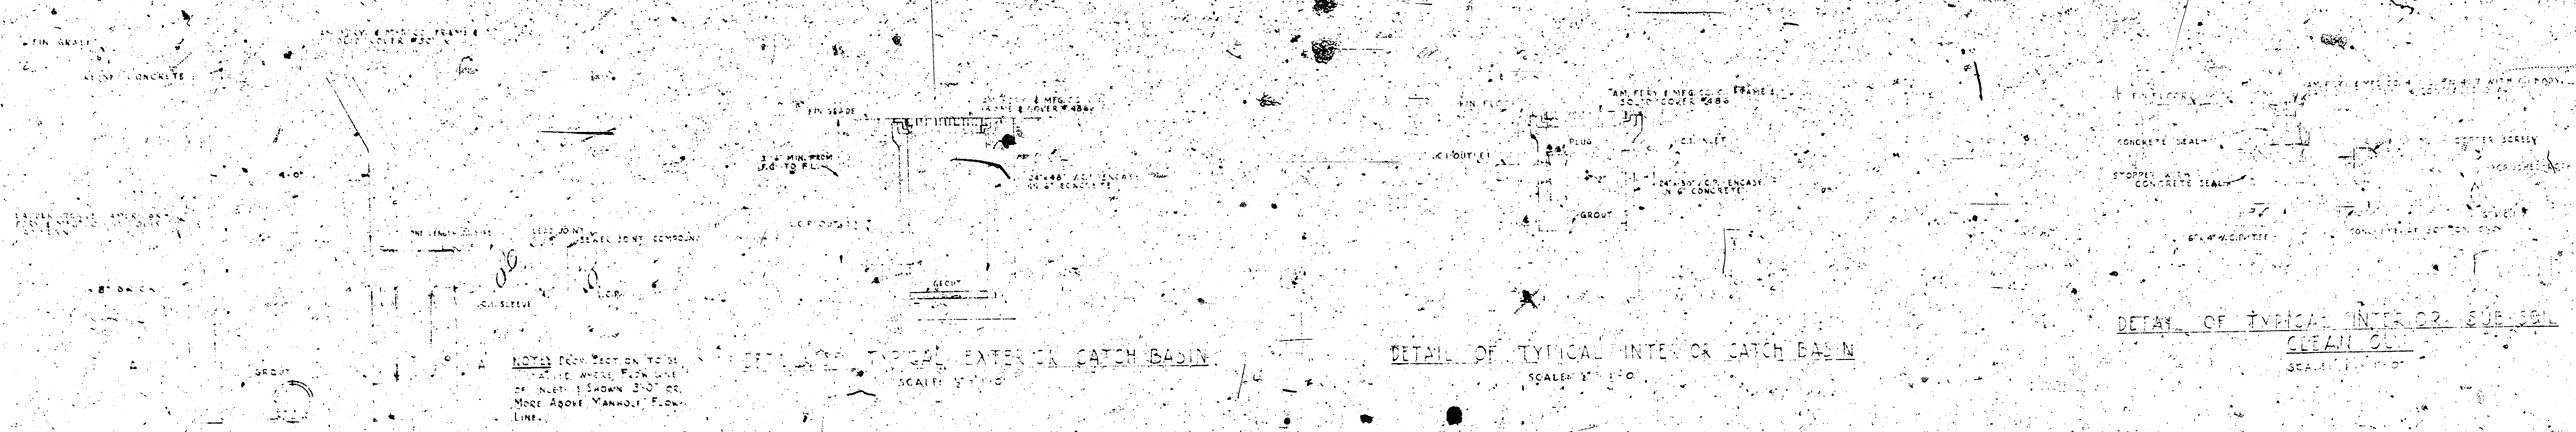

REVISIONS		ST. JOSEPH'S HOSPITAL	
		SISTERS OF ST. JOSEPH	
		MICHIGAN	
		PROFILES & DETAILS	
		MAGUOLO AND QUICK	
		ARCHITECTS - ENGINEERS	
		DETROIT, MICH.	
		MINNEAPOLIS, MINN.	
		CINCINNATI, OHIO	
		P-8	