





PLAN
 DATE: 8/27/78
 BY: [Signature]
 CHECKED: [Signature]
 NO. 1 OF 1

PROFILE
 DATE: 8/27/78
 BY: [Signature]
 CHECKED: [Signature]
 NO. 1 OF 1

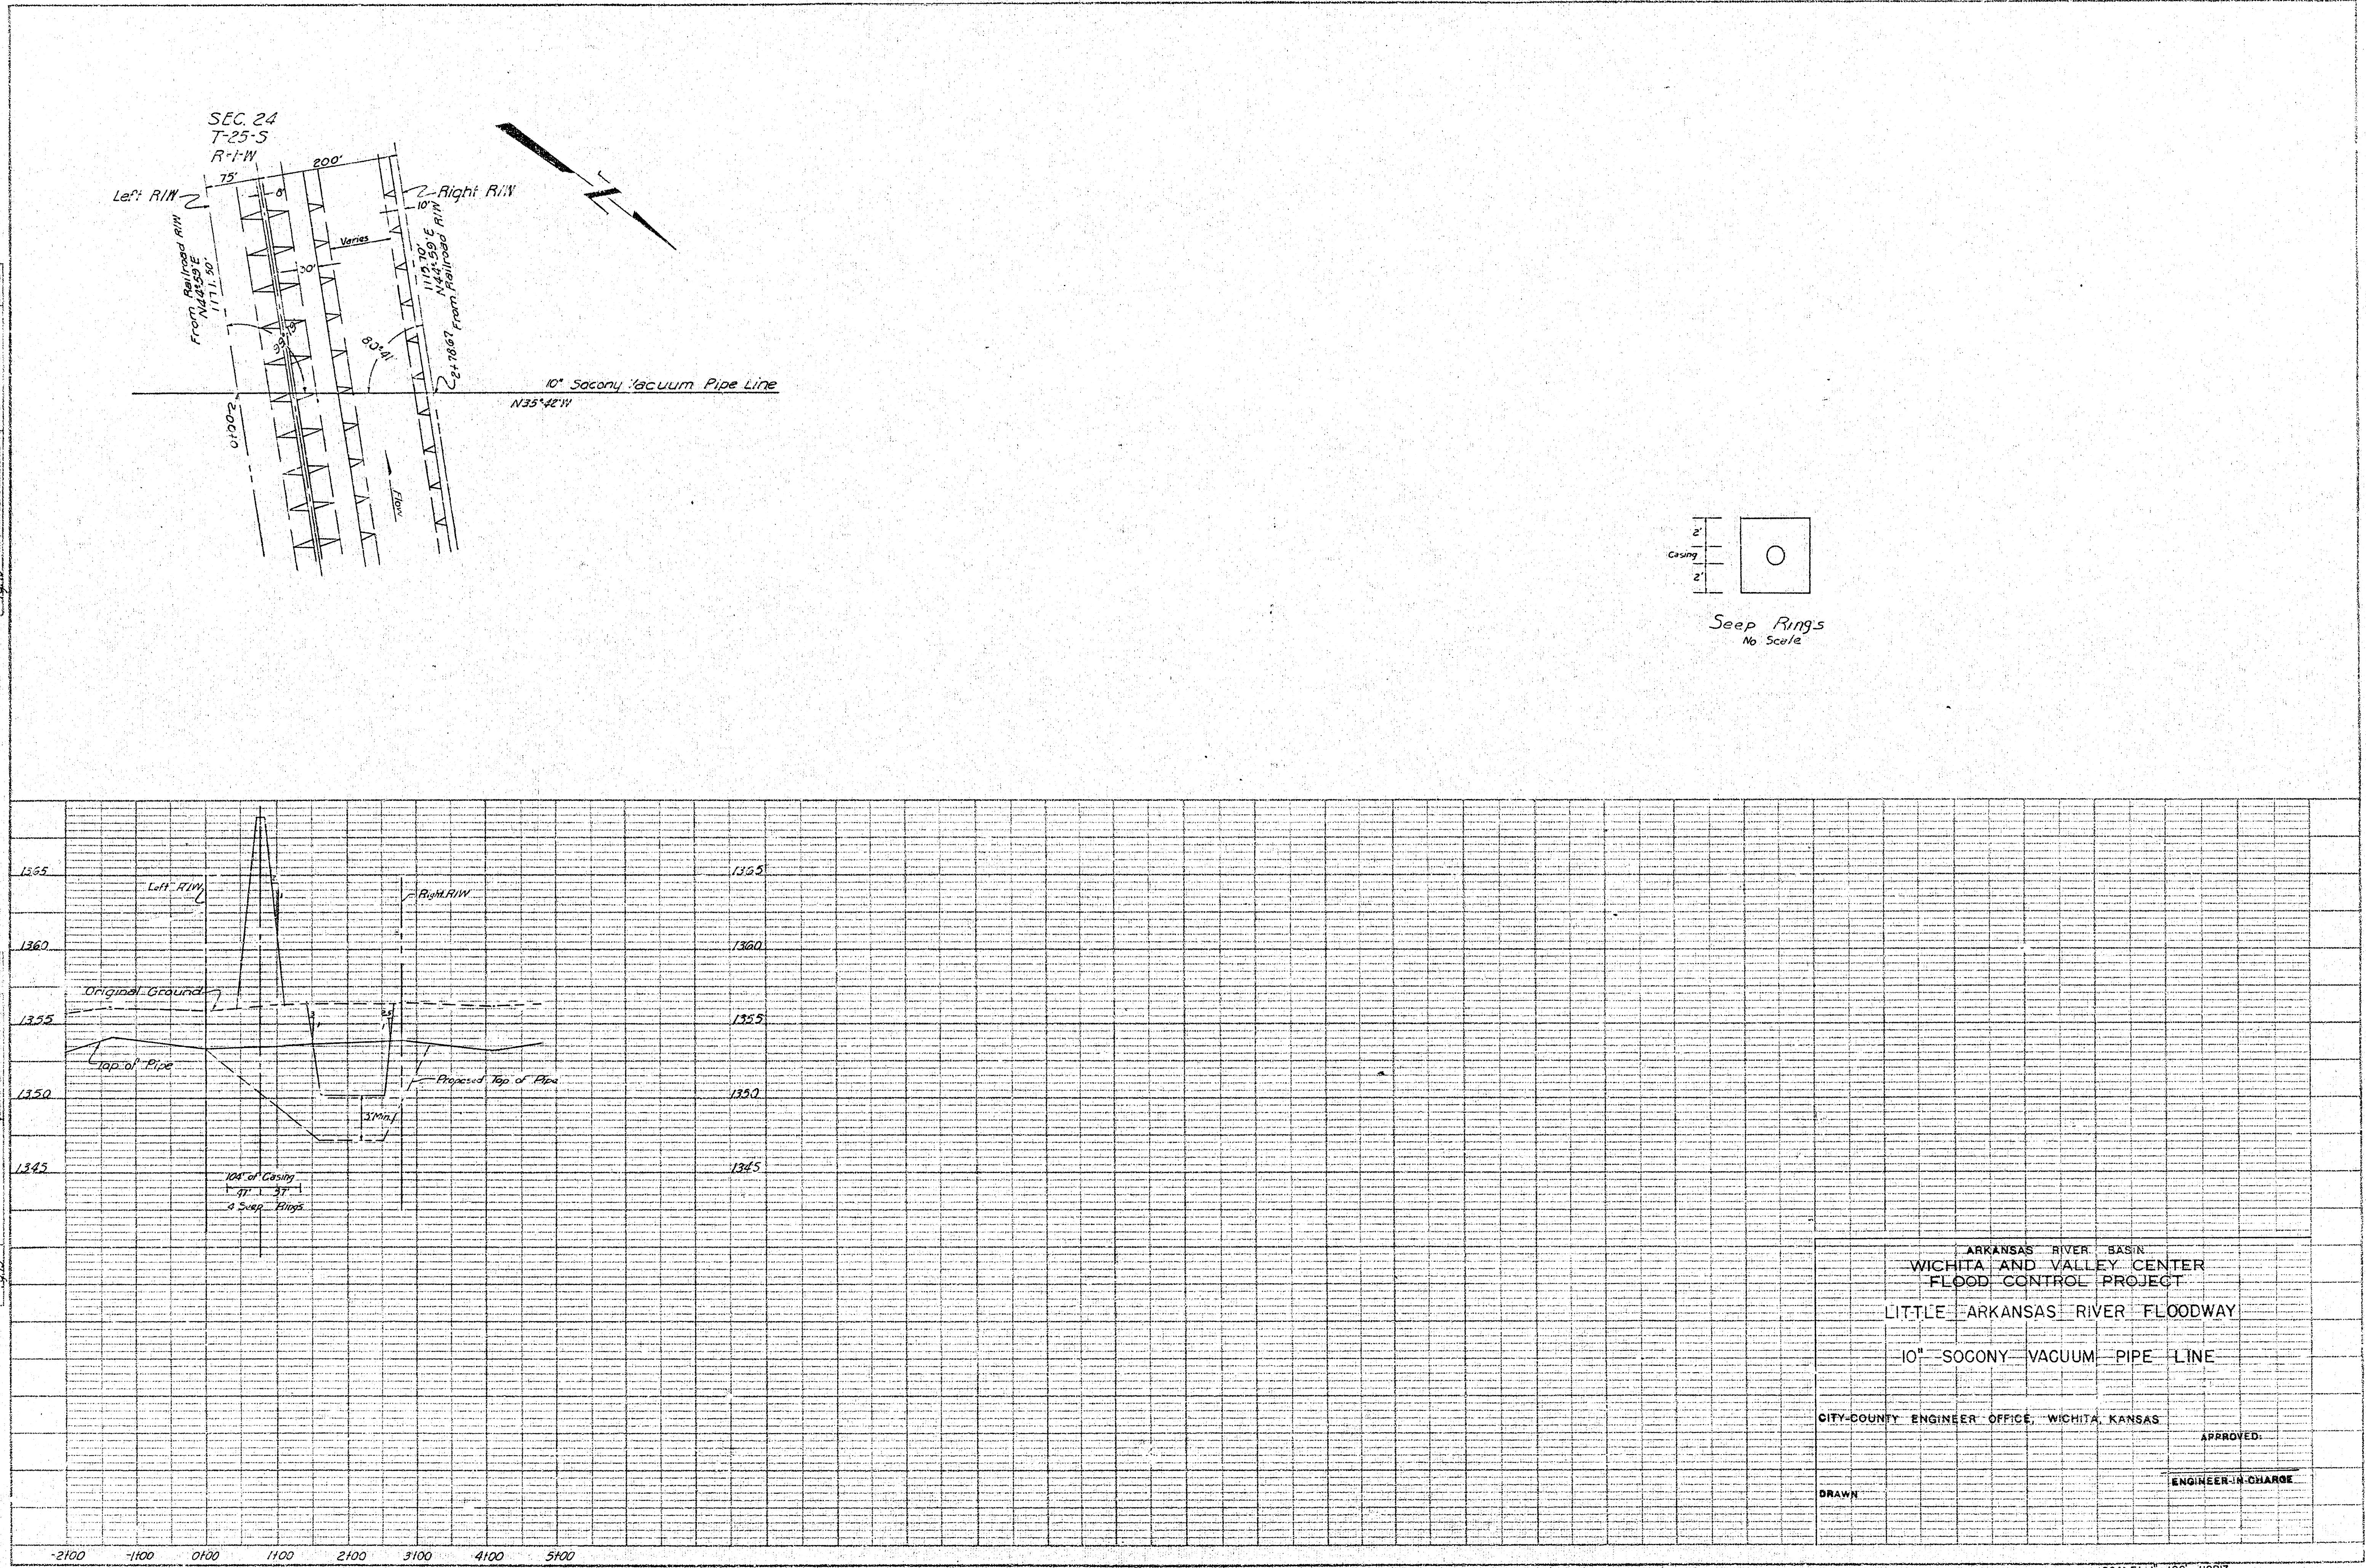




Bench Mark:
City of Wichita Brass Cap
in NE corner of bridge at
lateral A and 93rd street
Elev. 1356.34

 NOTE:
Pipe line crosses 93rd street
1573.0 east of Section corner
2+19
25/30 1:25-S R-L & R-I-W

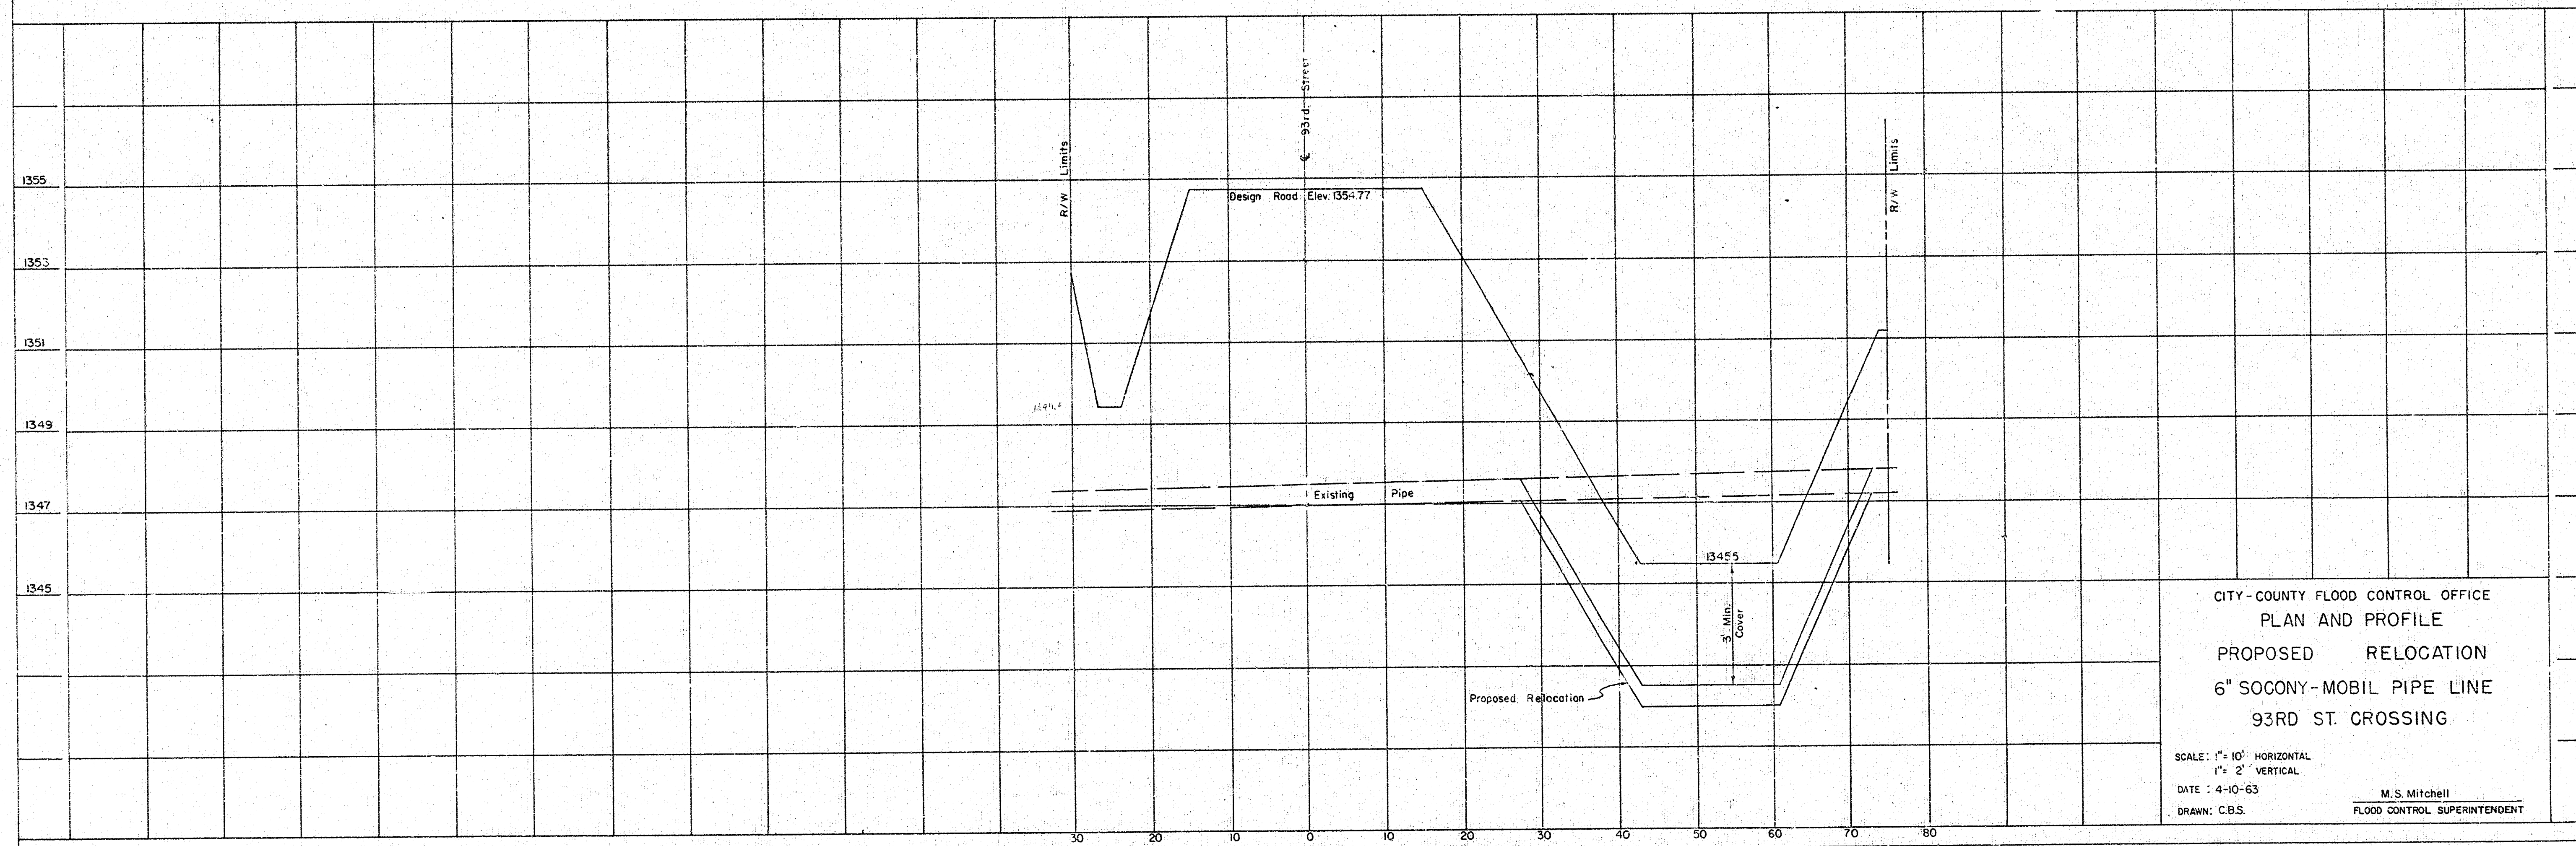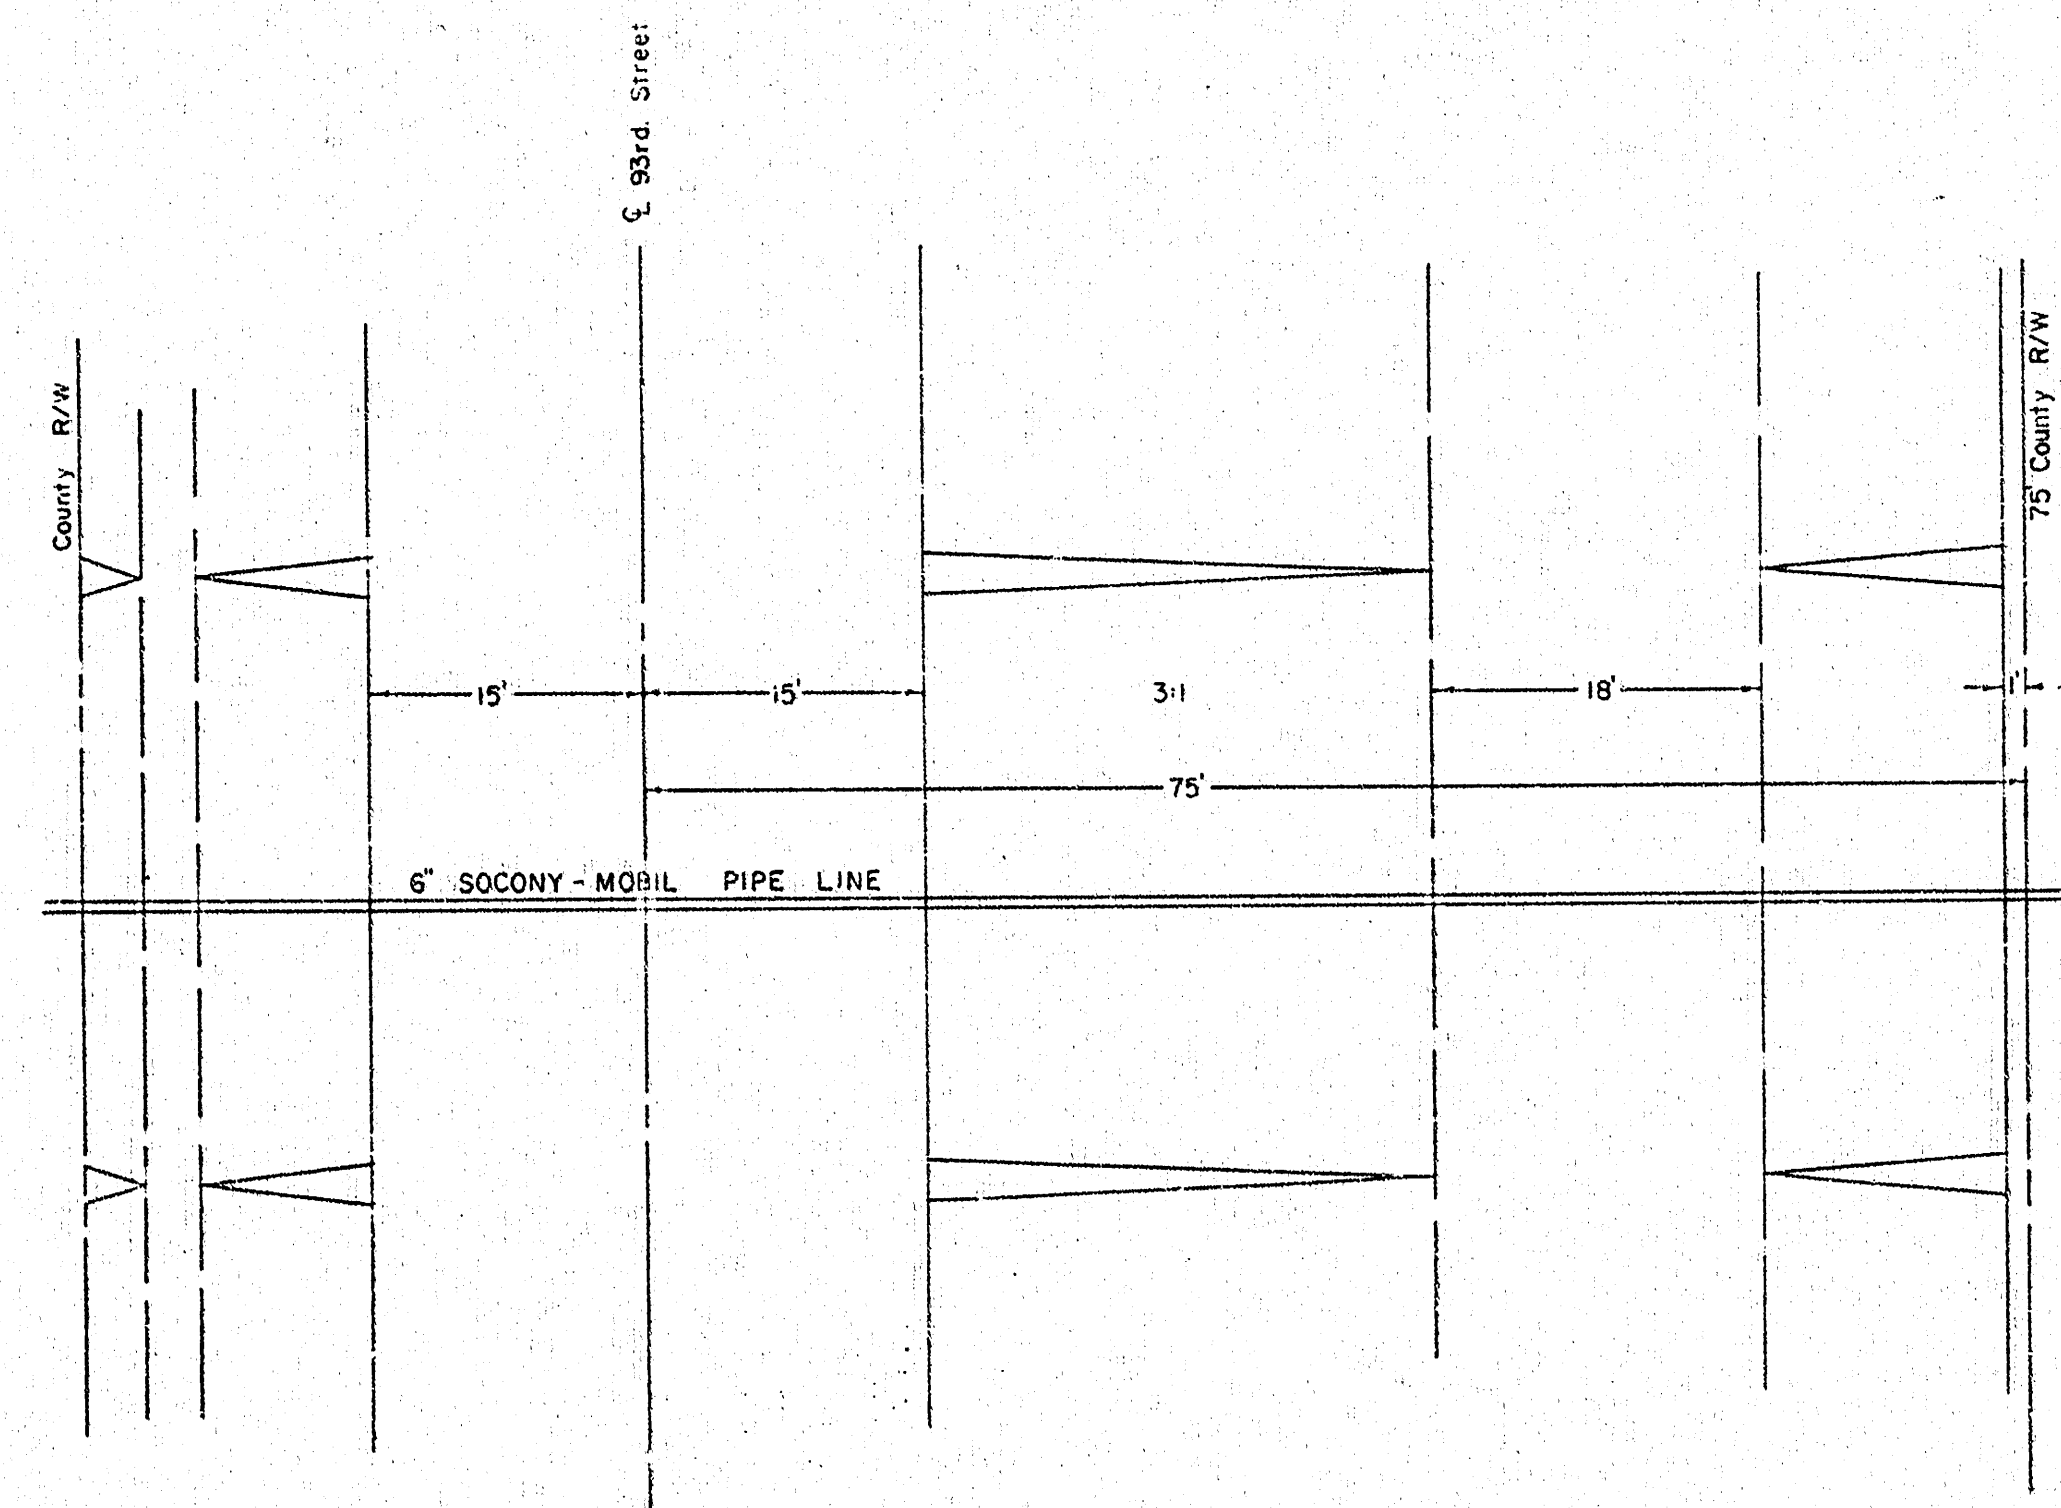




Bench Mark:
City of Wichita Brass Cap
in NE corner of bridge at
to 93rd St and 93rd Street
Elev. 1356.34

 NOTE:
Pipe line crosses 93rd street
1580.0' east of Section corner
2419 T-25-S R-1-E & R-1-W
25130

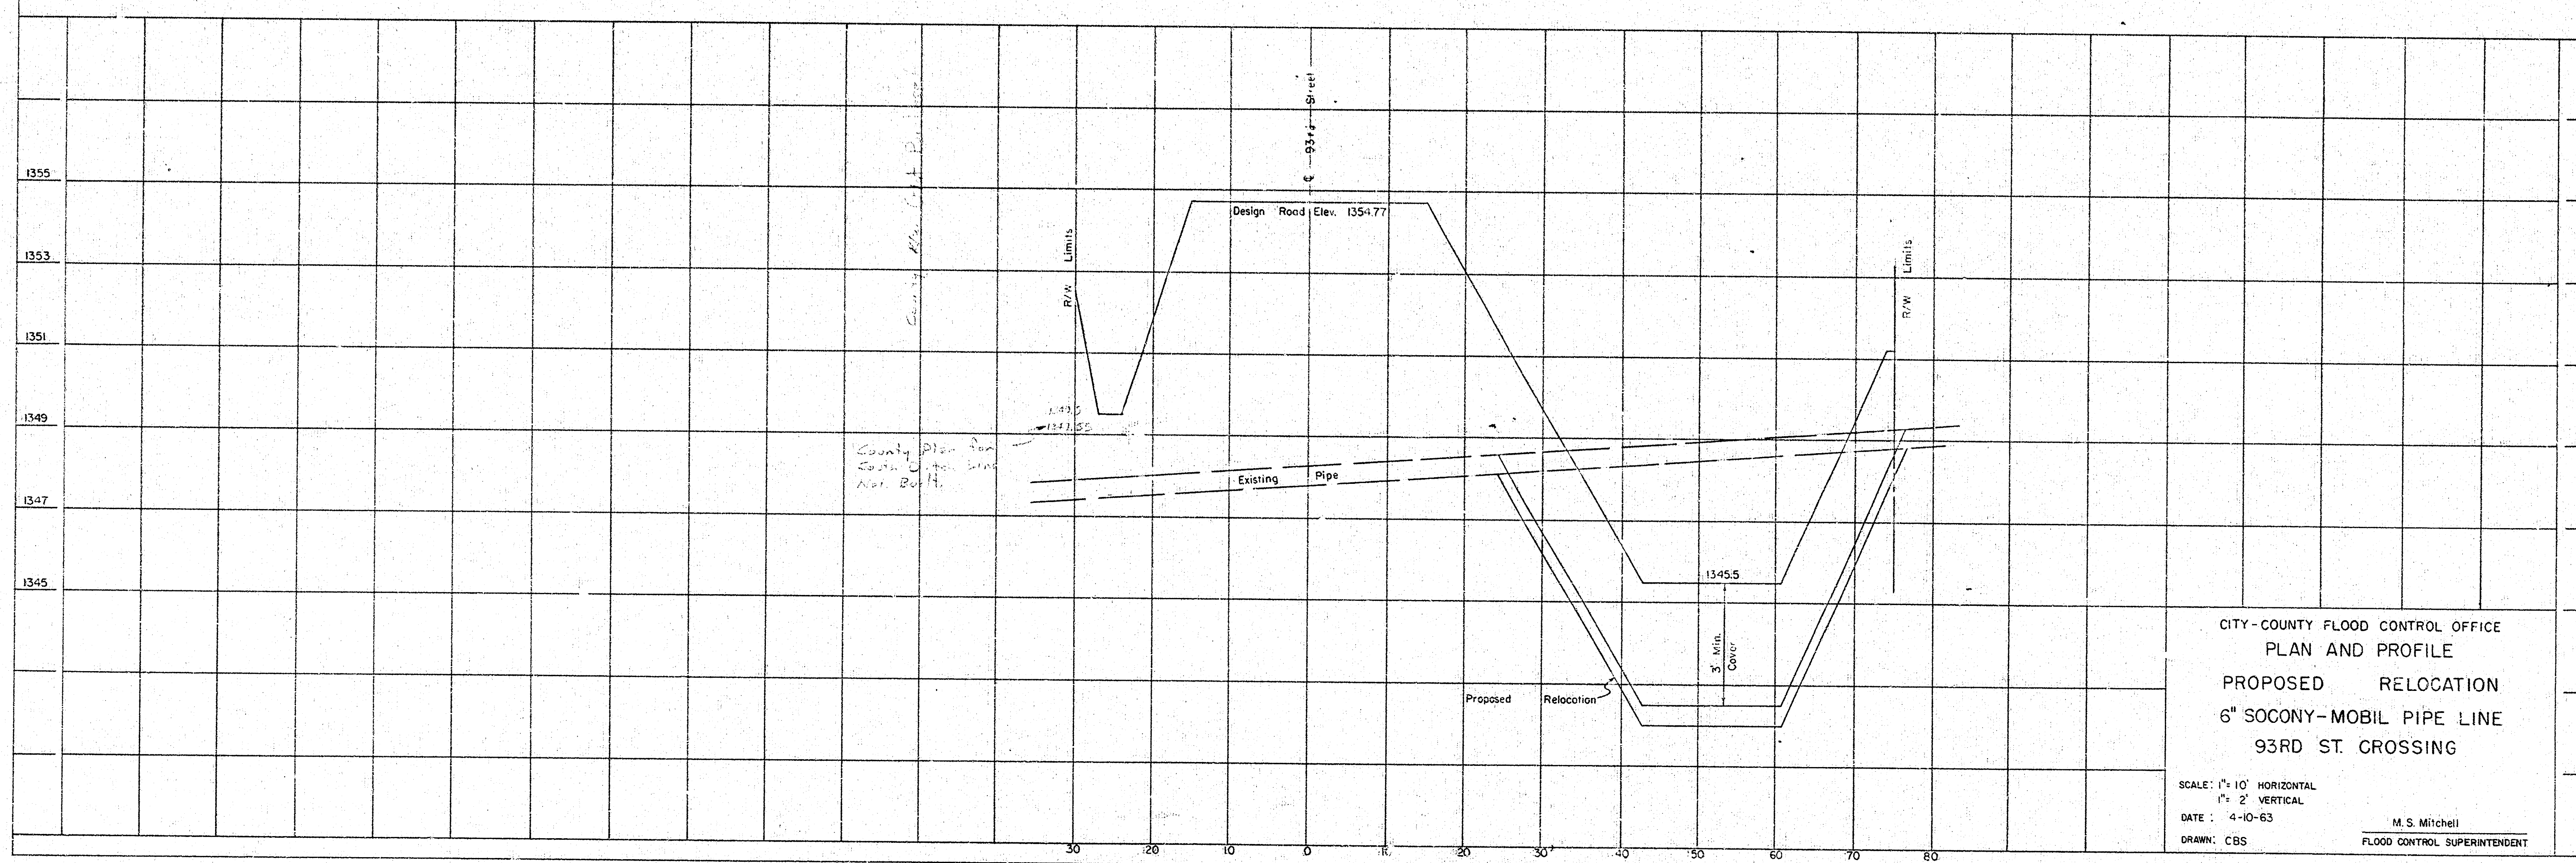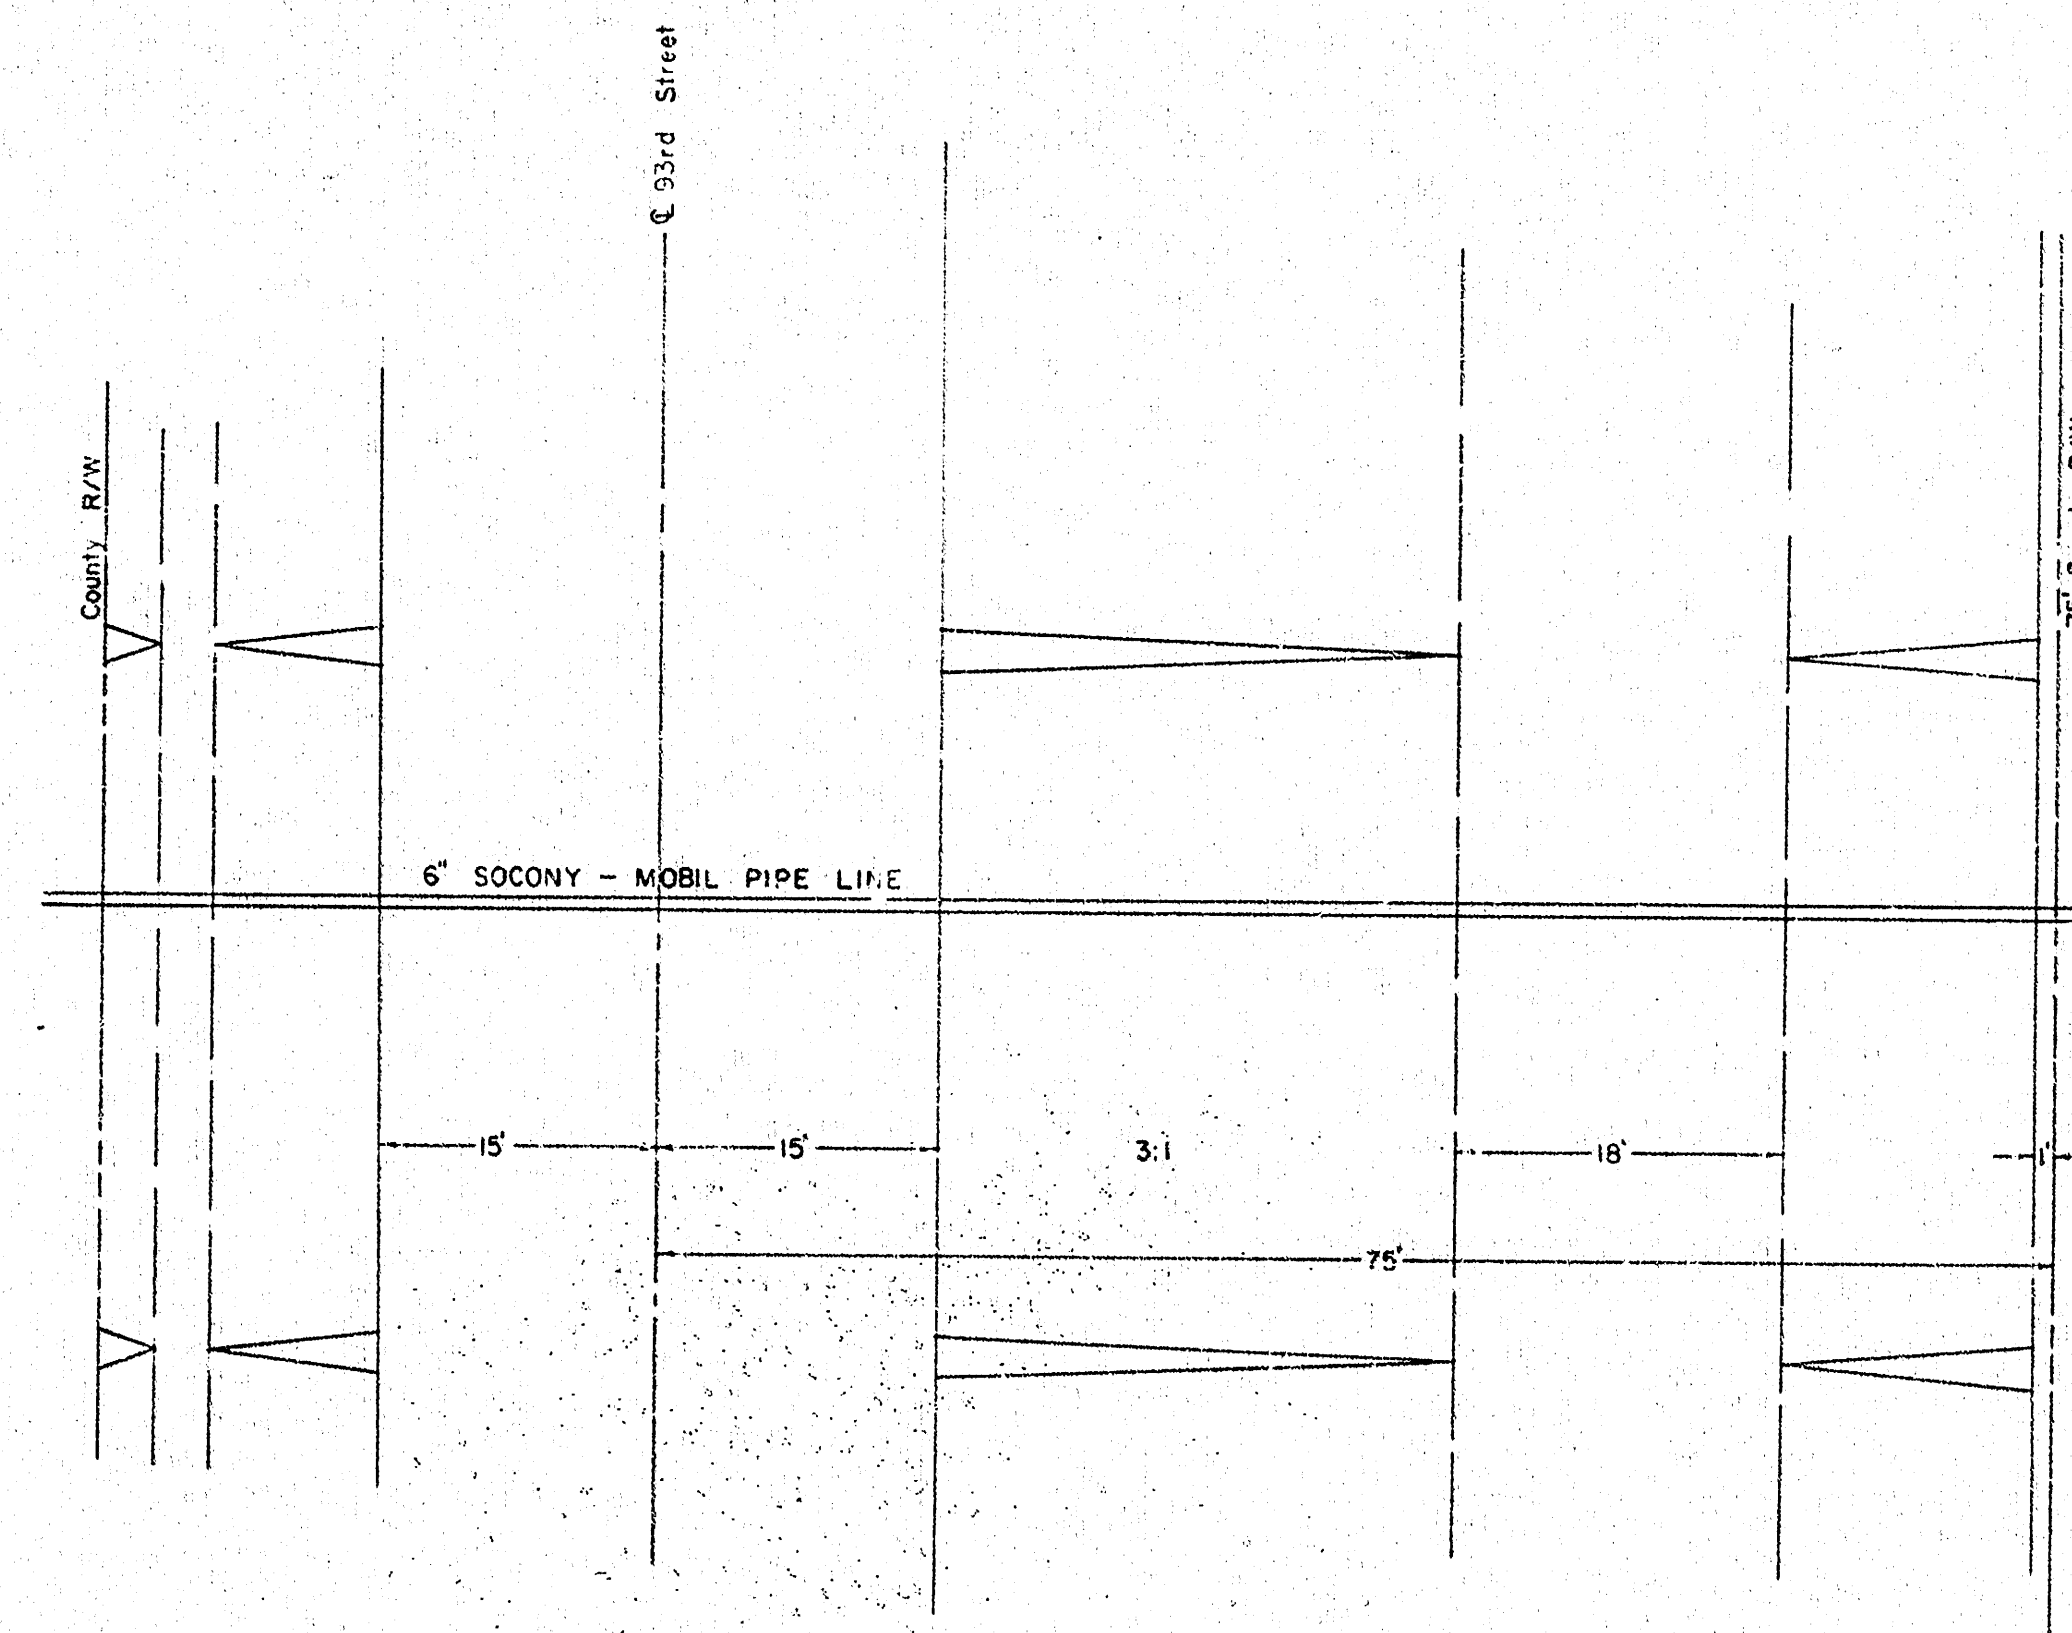

CITY-COUNTY FLOOD CONTROL OFFICE
PLAN AND PROFILE
PROPOSED RELOCATION
6" SOCONY-MOBIL PIPE LINE
93RD ST. CROSSING


 

SCALE: 1" = 10' HORIZONTAL
1" = 2' VERTICAL
DATE: 4-10-63
DRAWN: CBS
M. S. Mitchell
FLOOD CONTROL SUPERINTENDENT

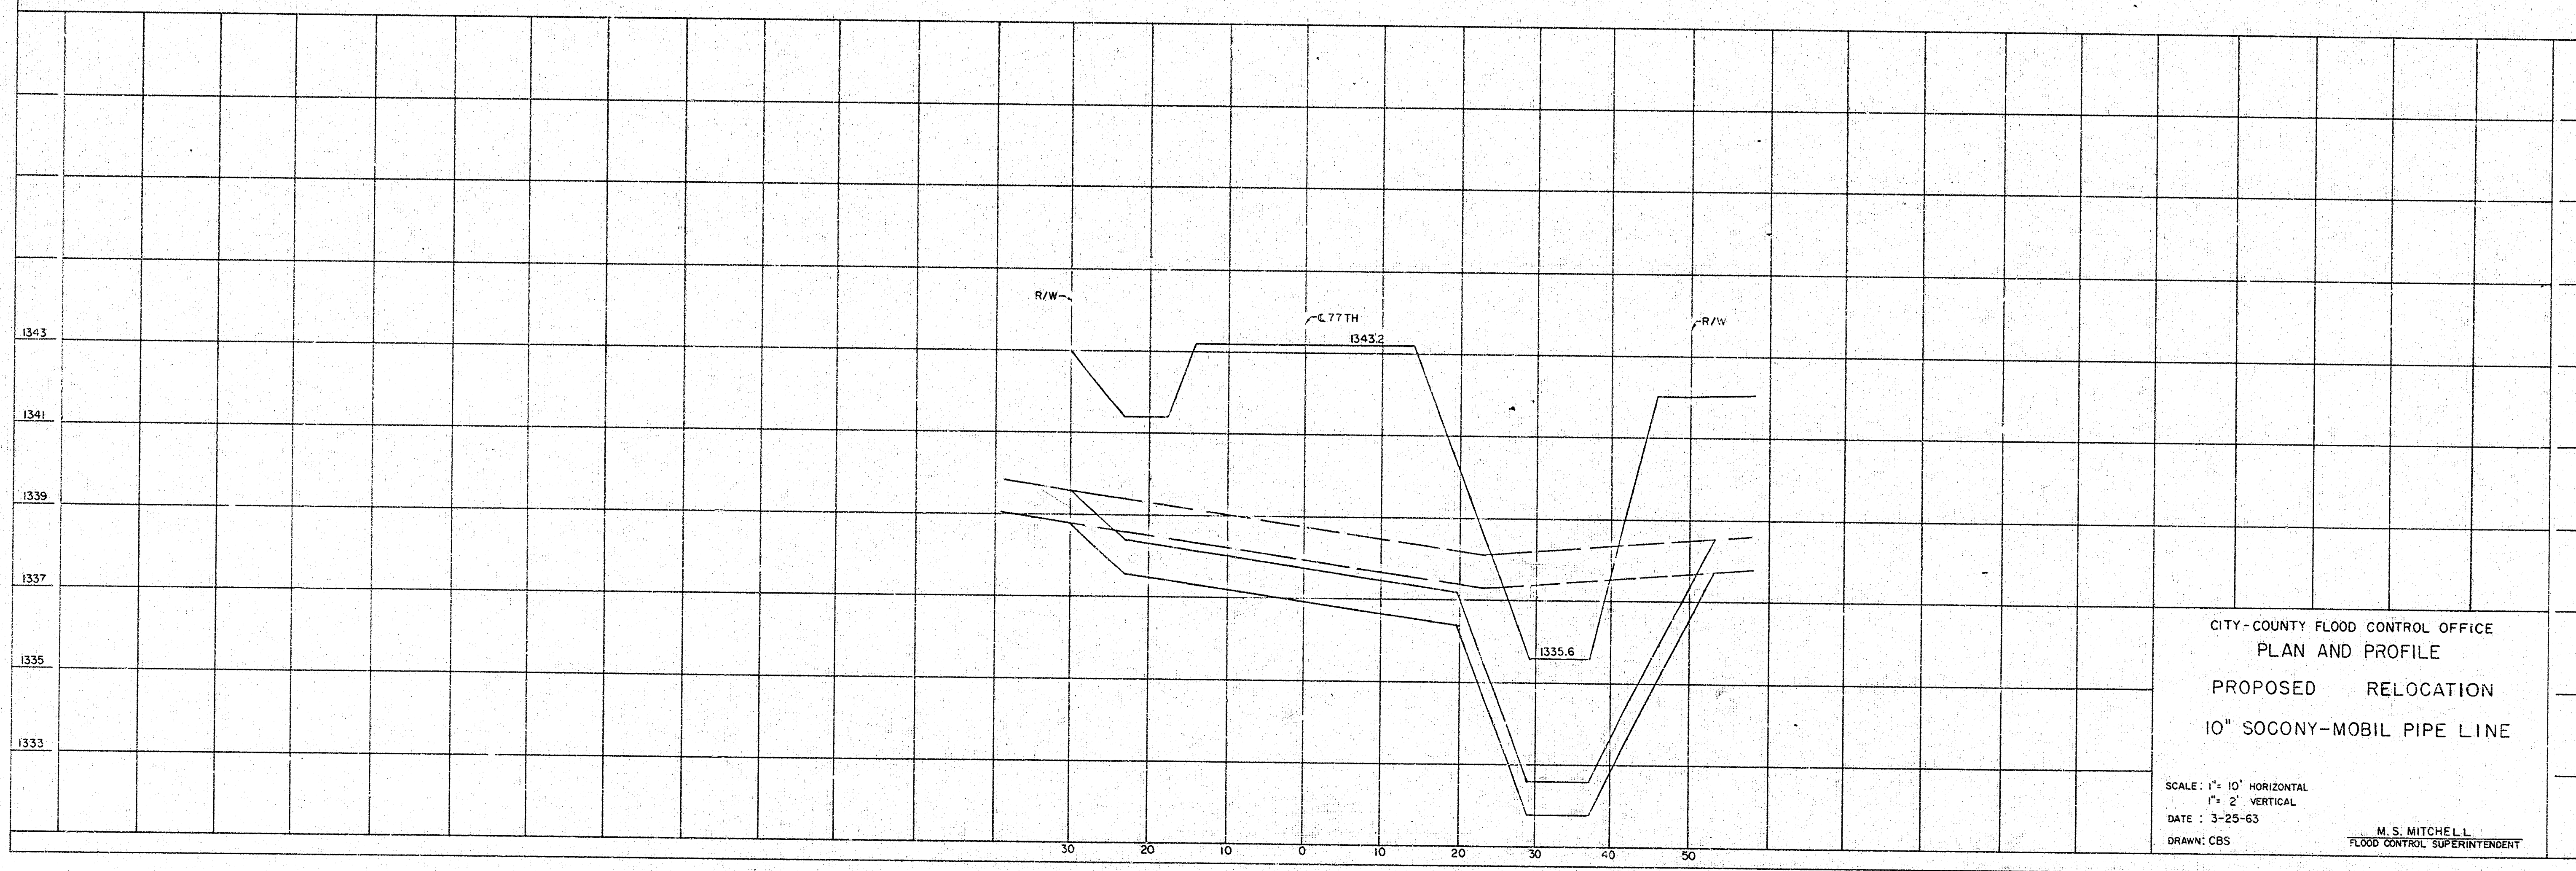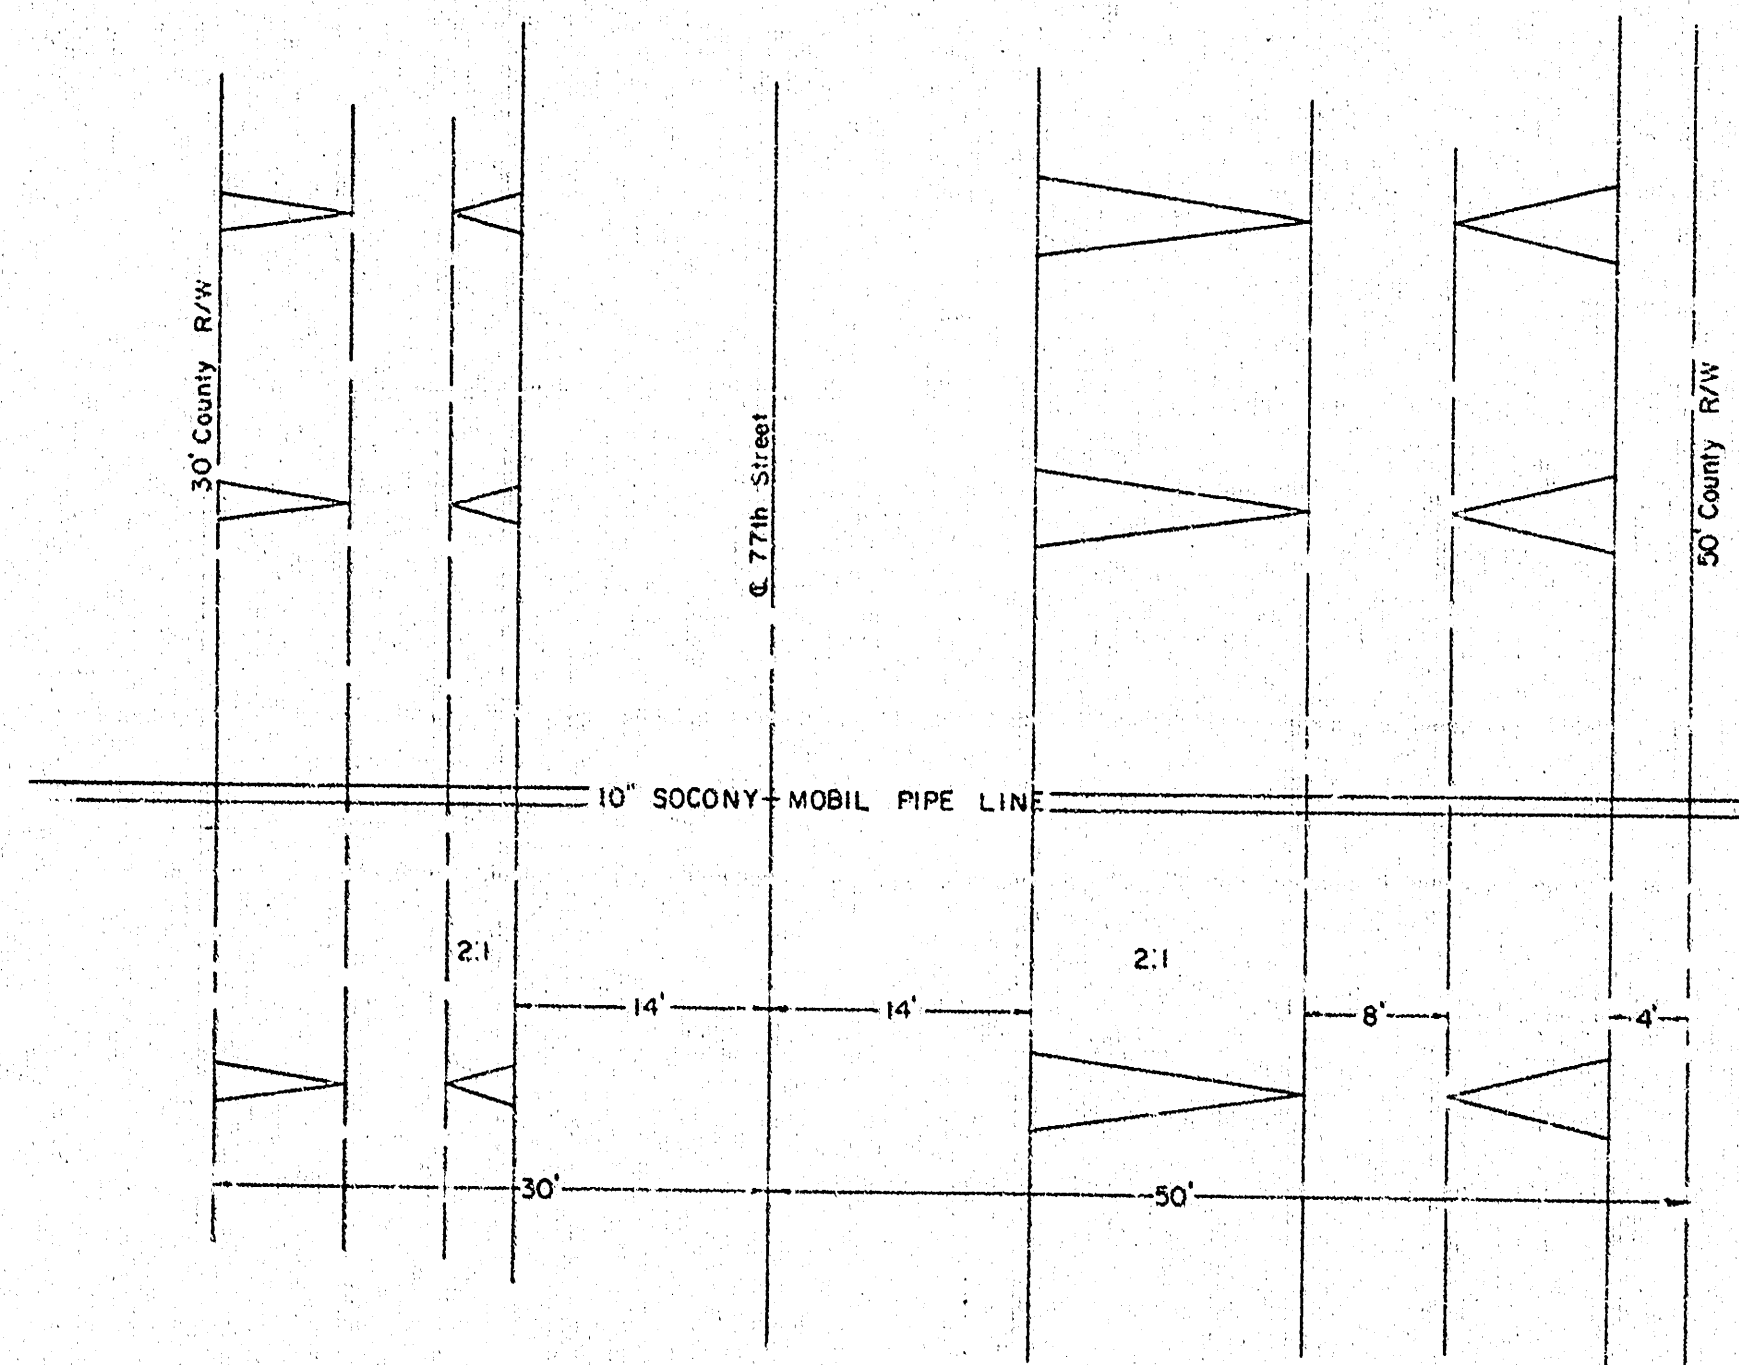

CITY-COUNTY FLOOD CONTROL OFFICE
PLAN AND PROFILE
PROPOSED RELOCATION
10" SOCONY-MOBIL PIPE LINE

SCALE: 1" = 10' HORIZONTAL
1" = 2' VERTICAL
DATE: 3-25-63
DRAWN: CBS

M. S. MITCHELL
FLOOD CONTROL SUPERINTENDENT

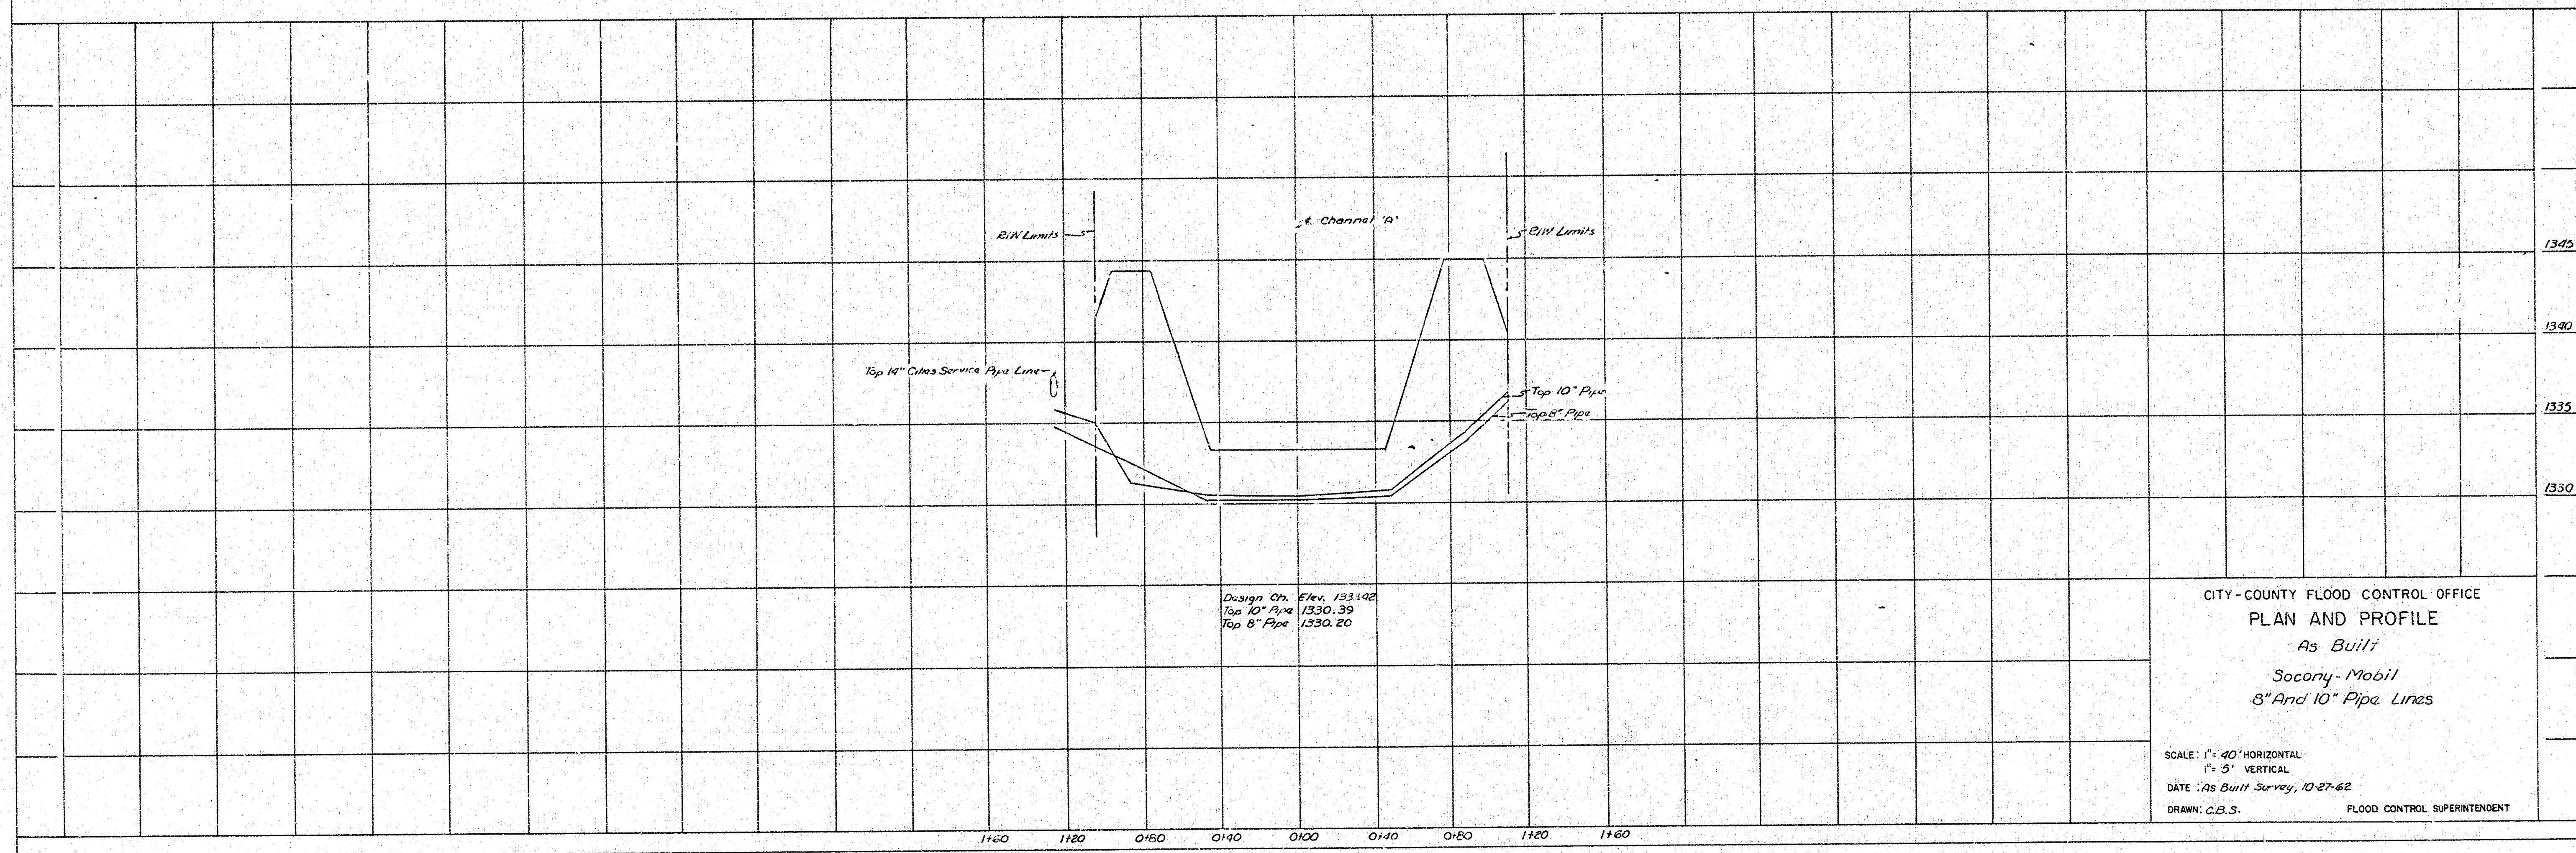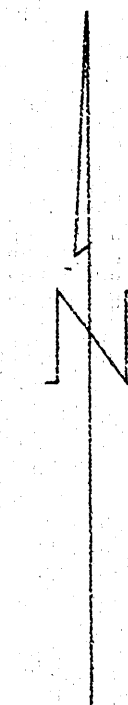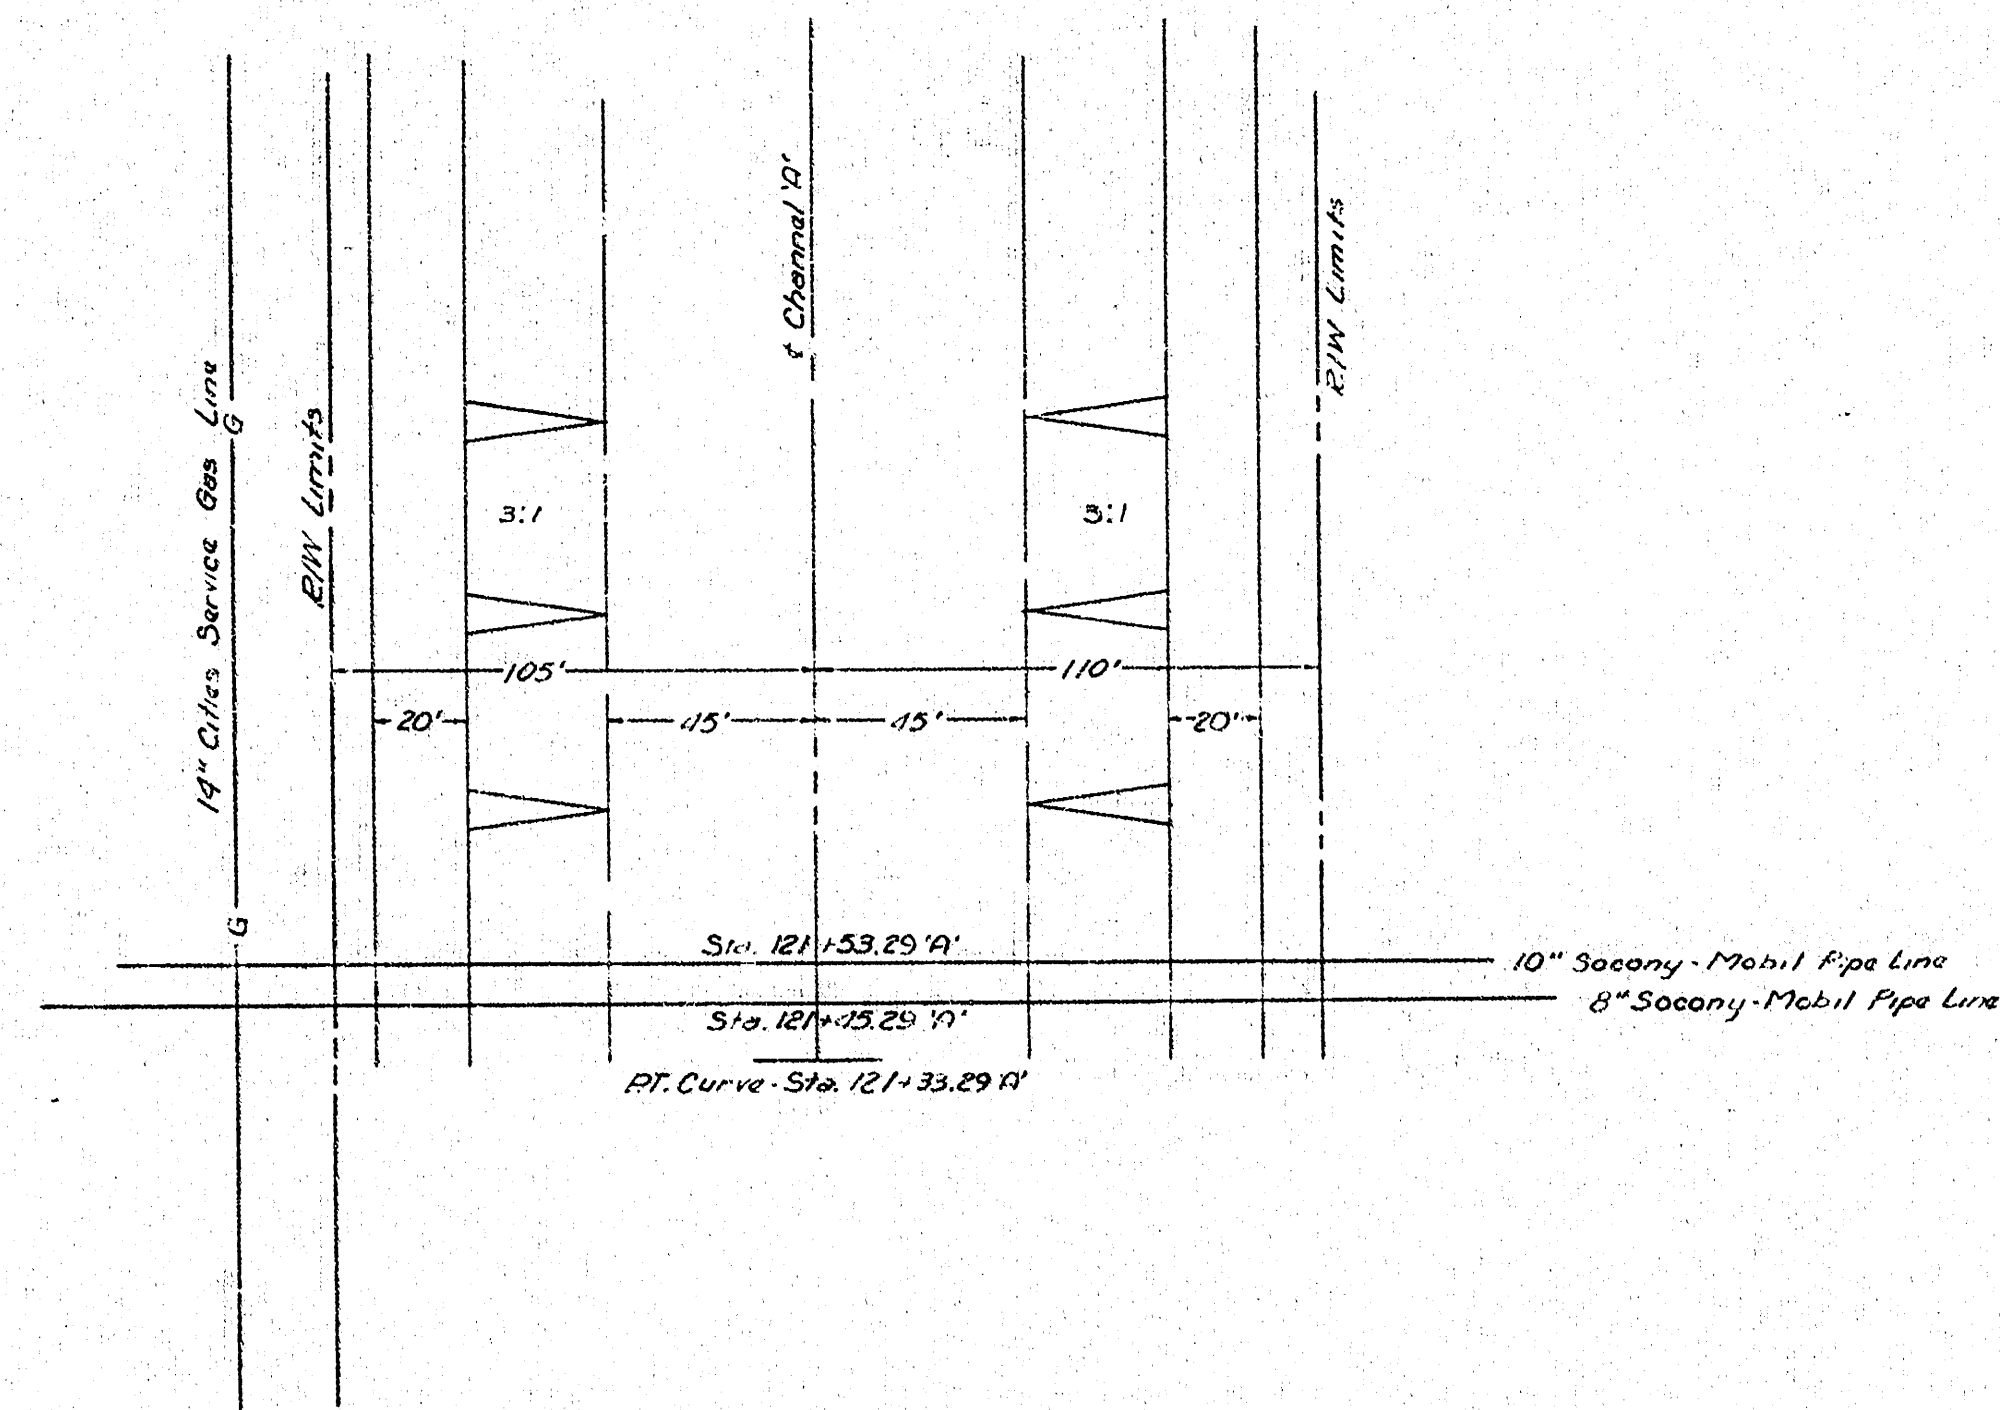

CITY-COUNTY FLOOD CONTROL OFFICE
 PLAN AND PROFILE
 As Built
 Socony-Mobil
 8" And 10" Pipe Lines

SCALE: 1" = 40' HORIZONTAL
 1" = 5' VERTICAL
 DATE: As Built Survey, 10-27-62
 DRAWN: C.B.S. FLOOD CONTROL SUPERINTENDENT

