


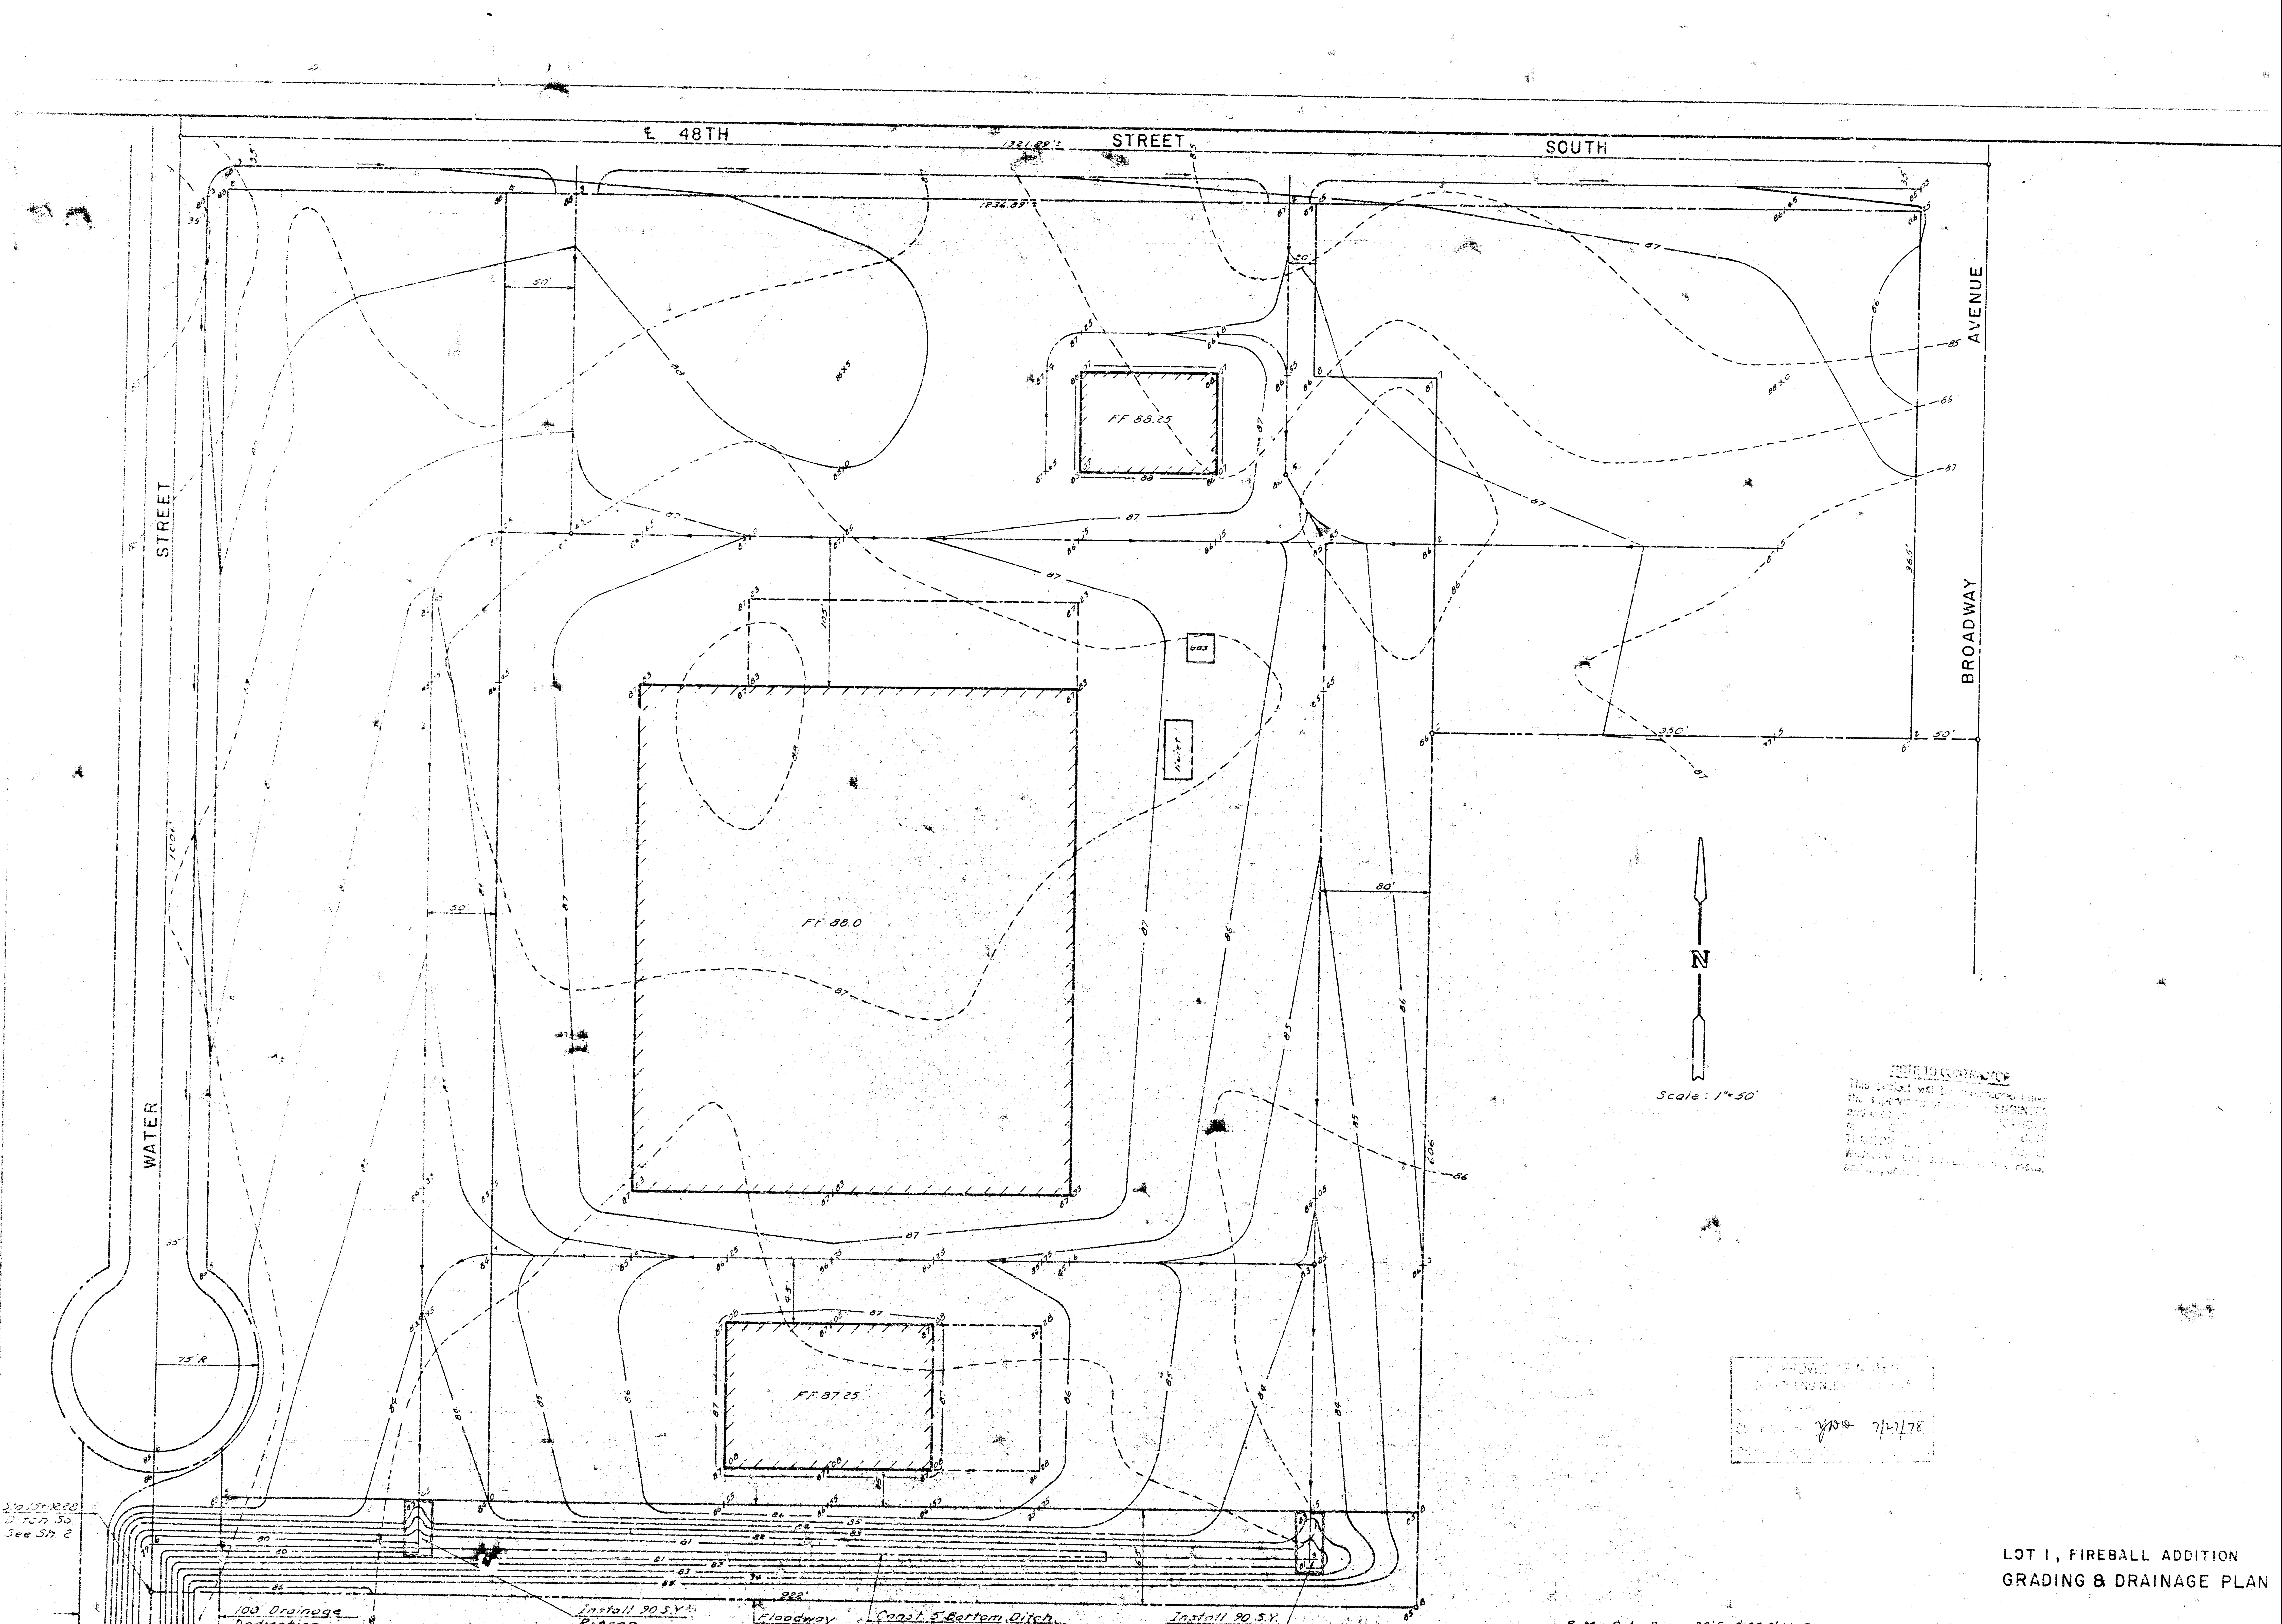

E 48TH

STREET

SOUTH

AVENUE

BROADWAY

STREET

WATER





N

Scale: 1"=50'

NOTE TO CONTRACTOR
This plan was prepared by the
ENGINEER
and is subject to the approval of the
CITY ENGINEER. The CONTRACTOR
shall be responsible for the accuracy
of the field data and the construction
of the work.


RECEIVED
7/17/78

LOT 1, FIREBALL ADDITION
GRADING & DRAINAGE PLAN

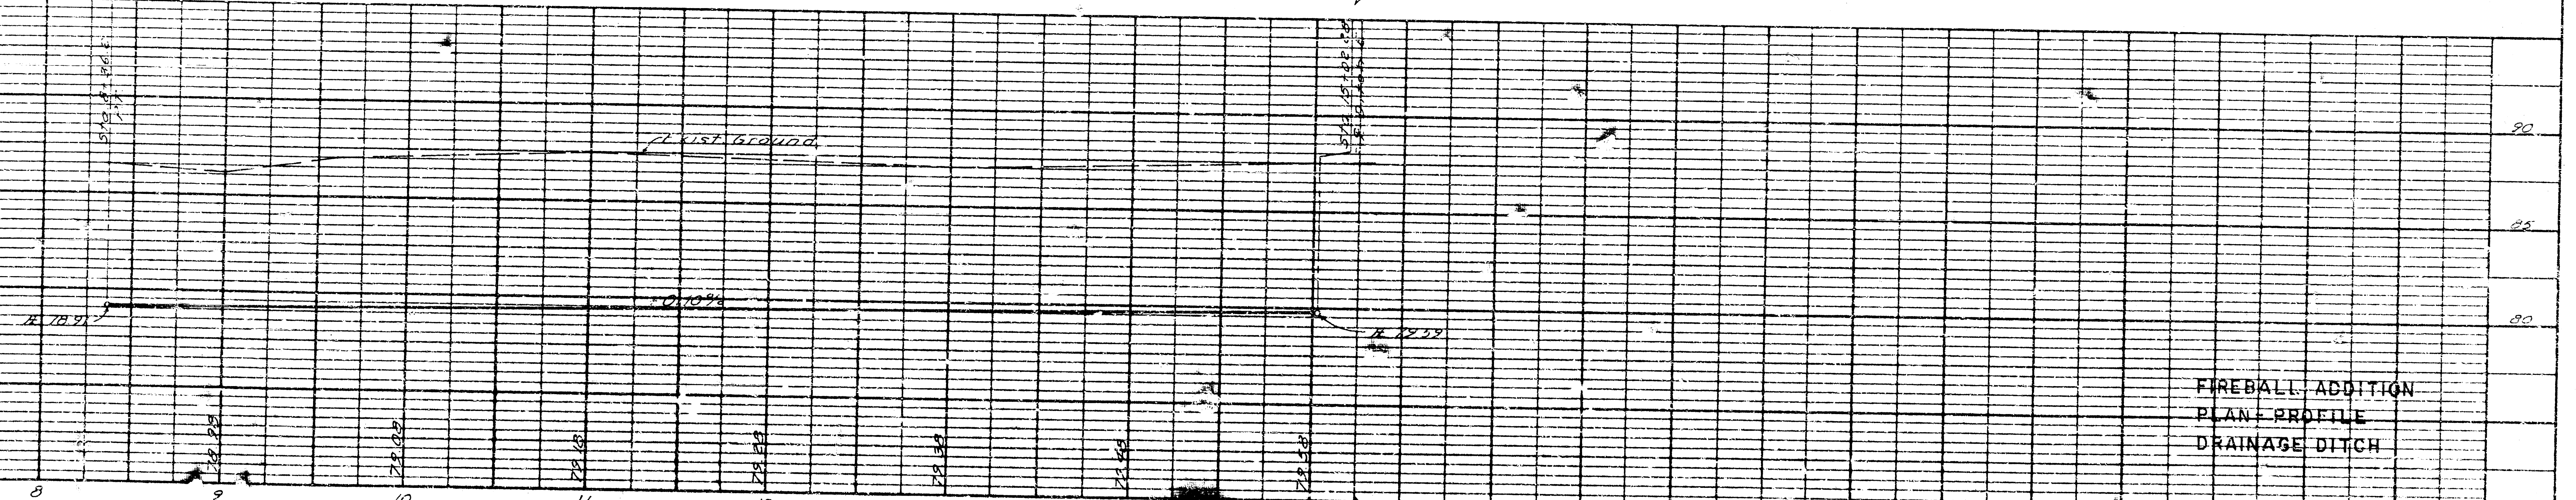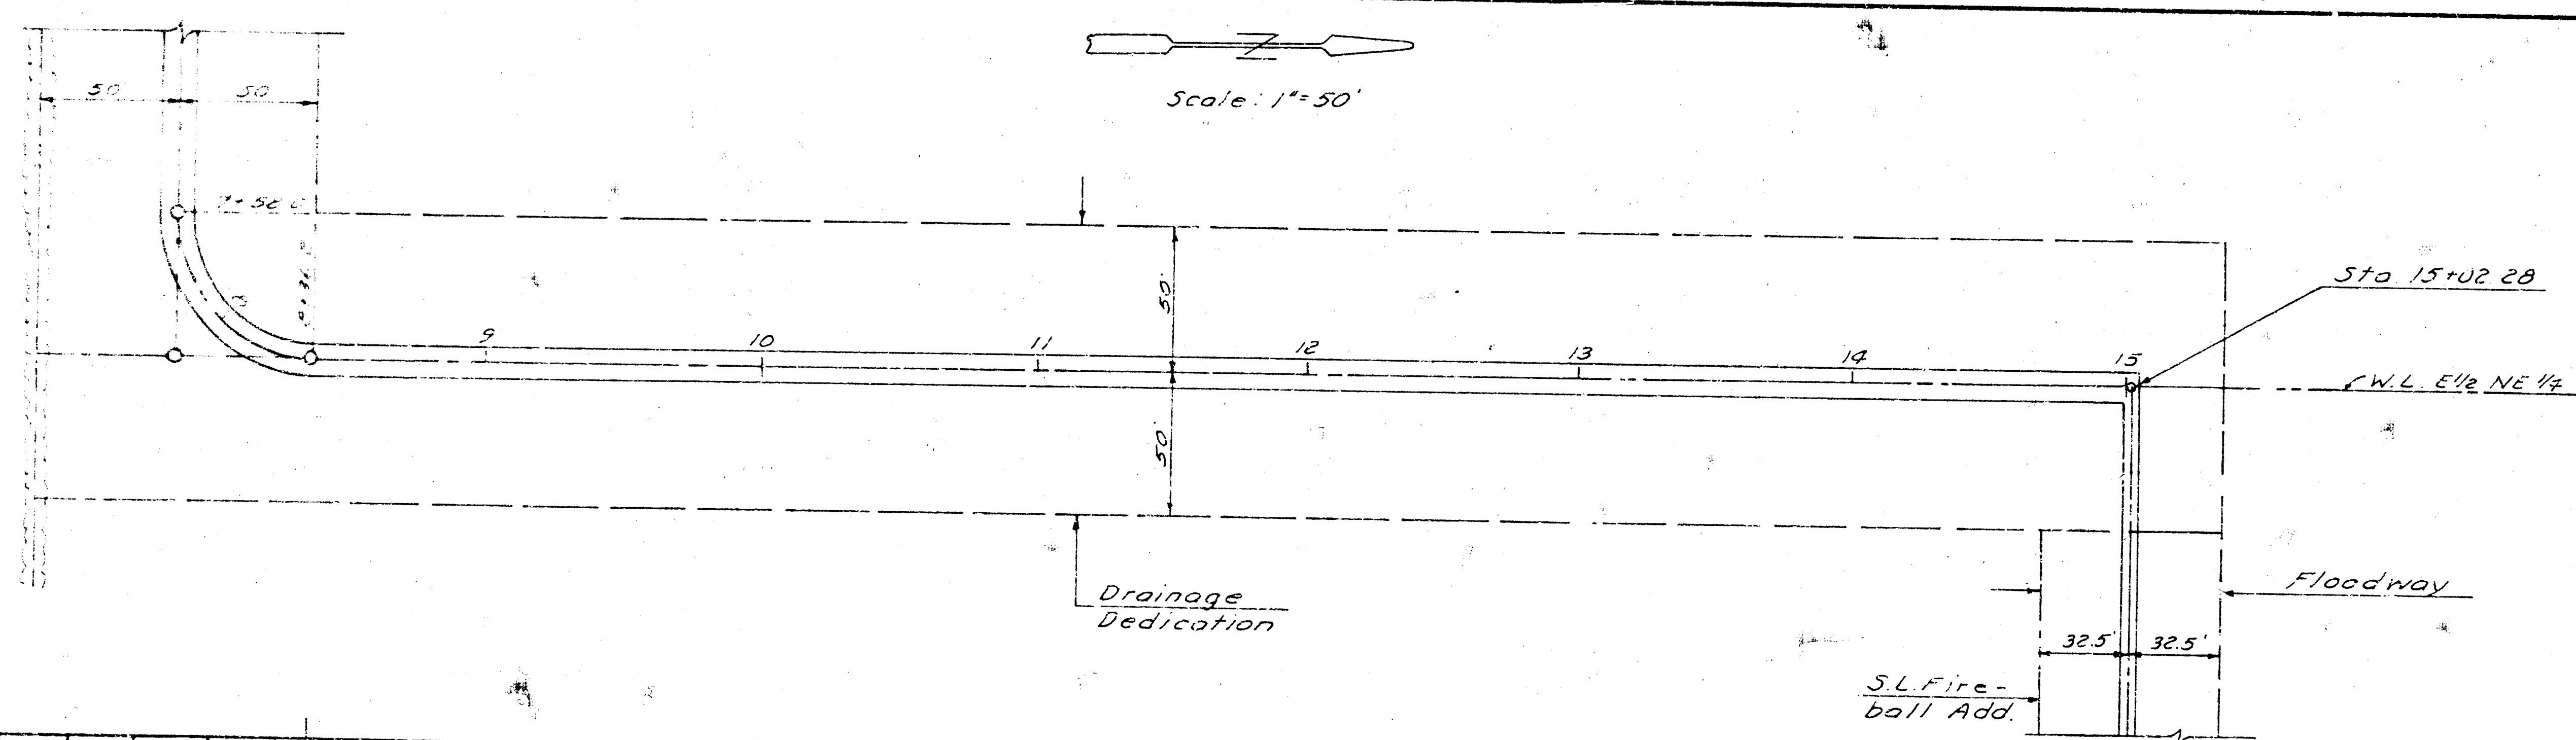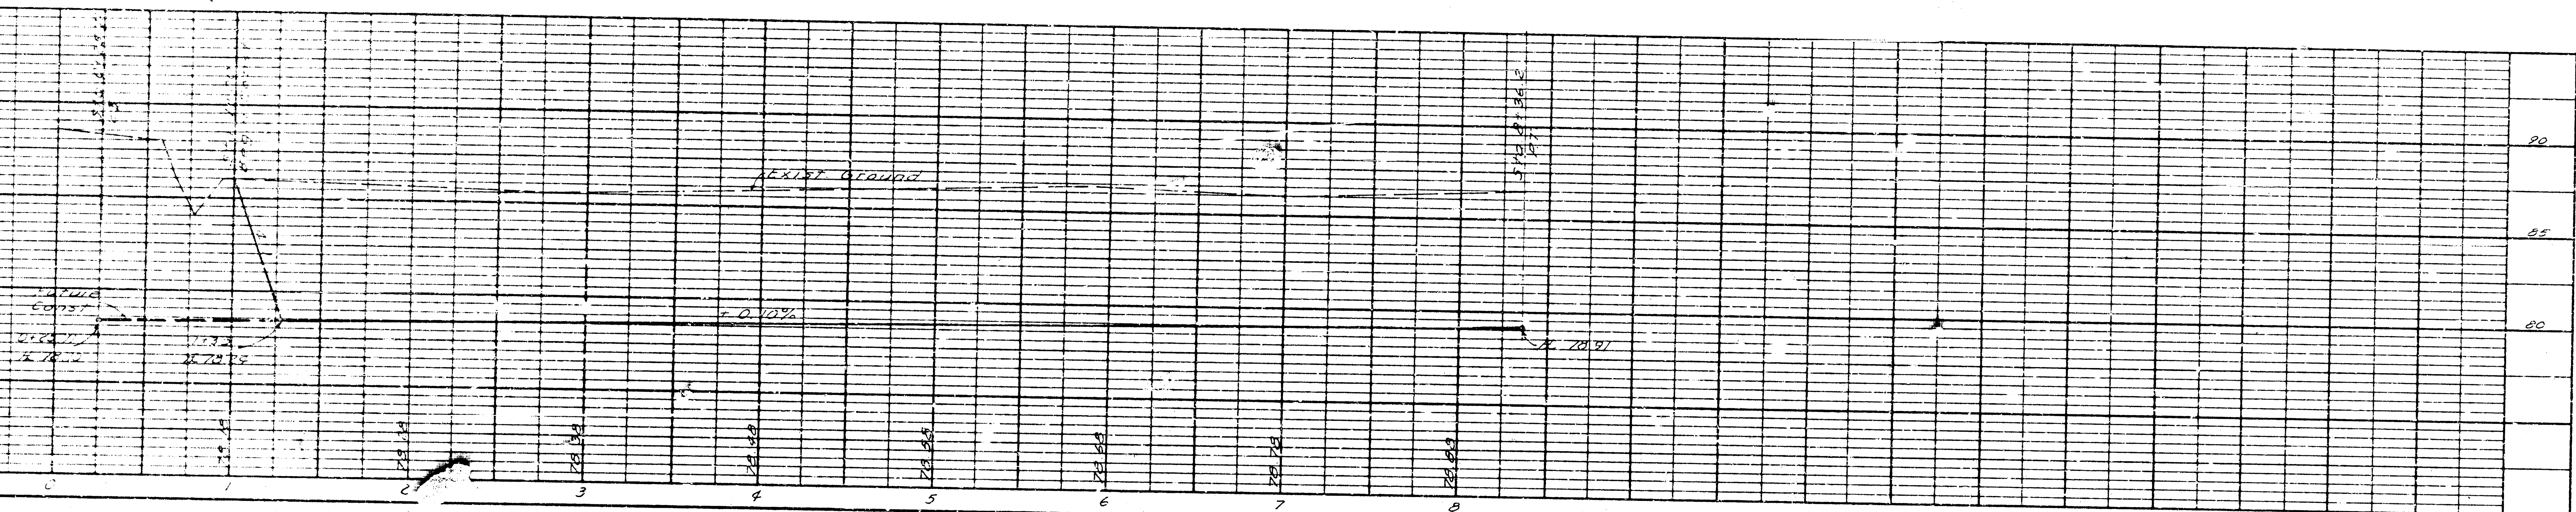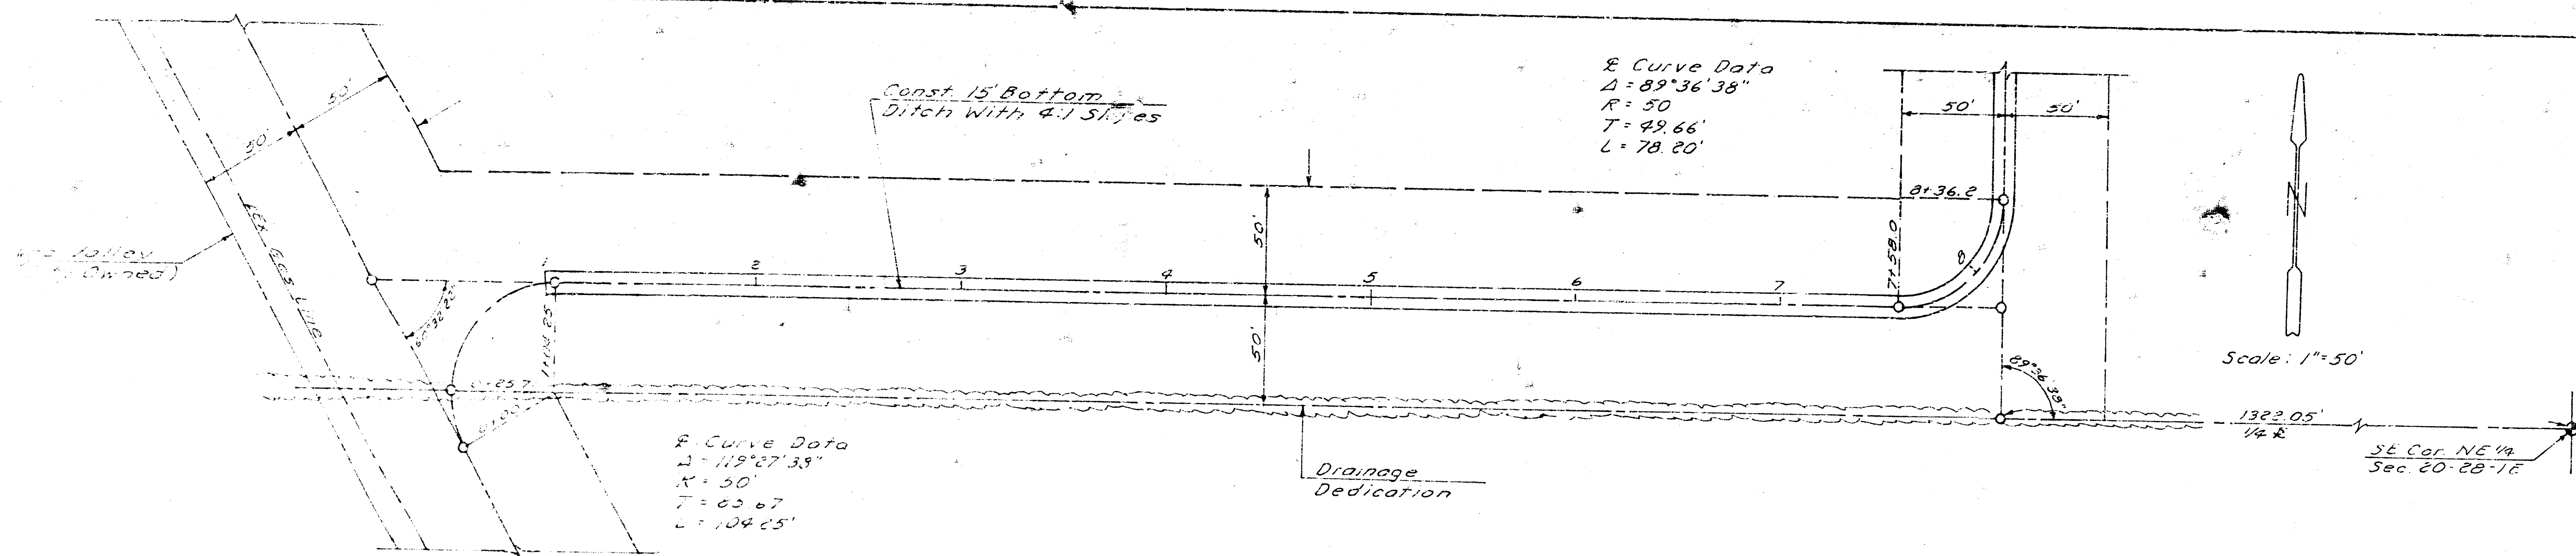

FIREBALL ADDITION
PLAN-PROFILE
DRAINAGE DITCH

FIREBALL GRADING SECTION

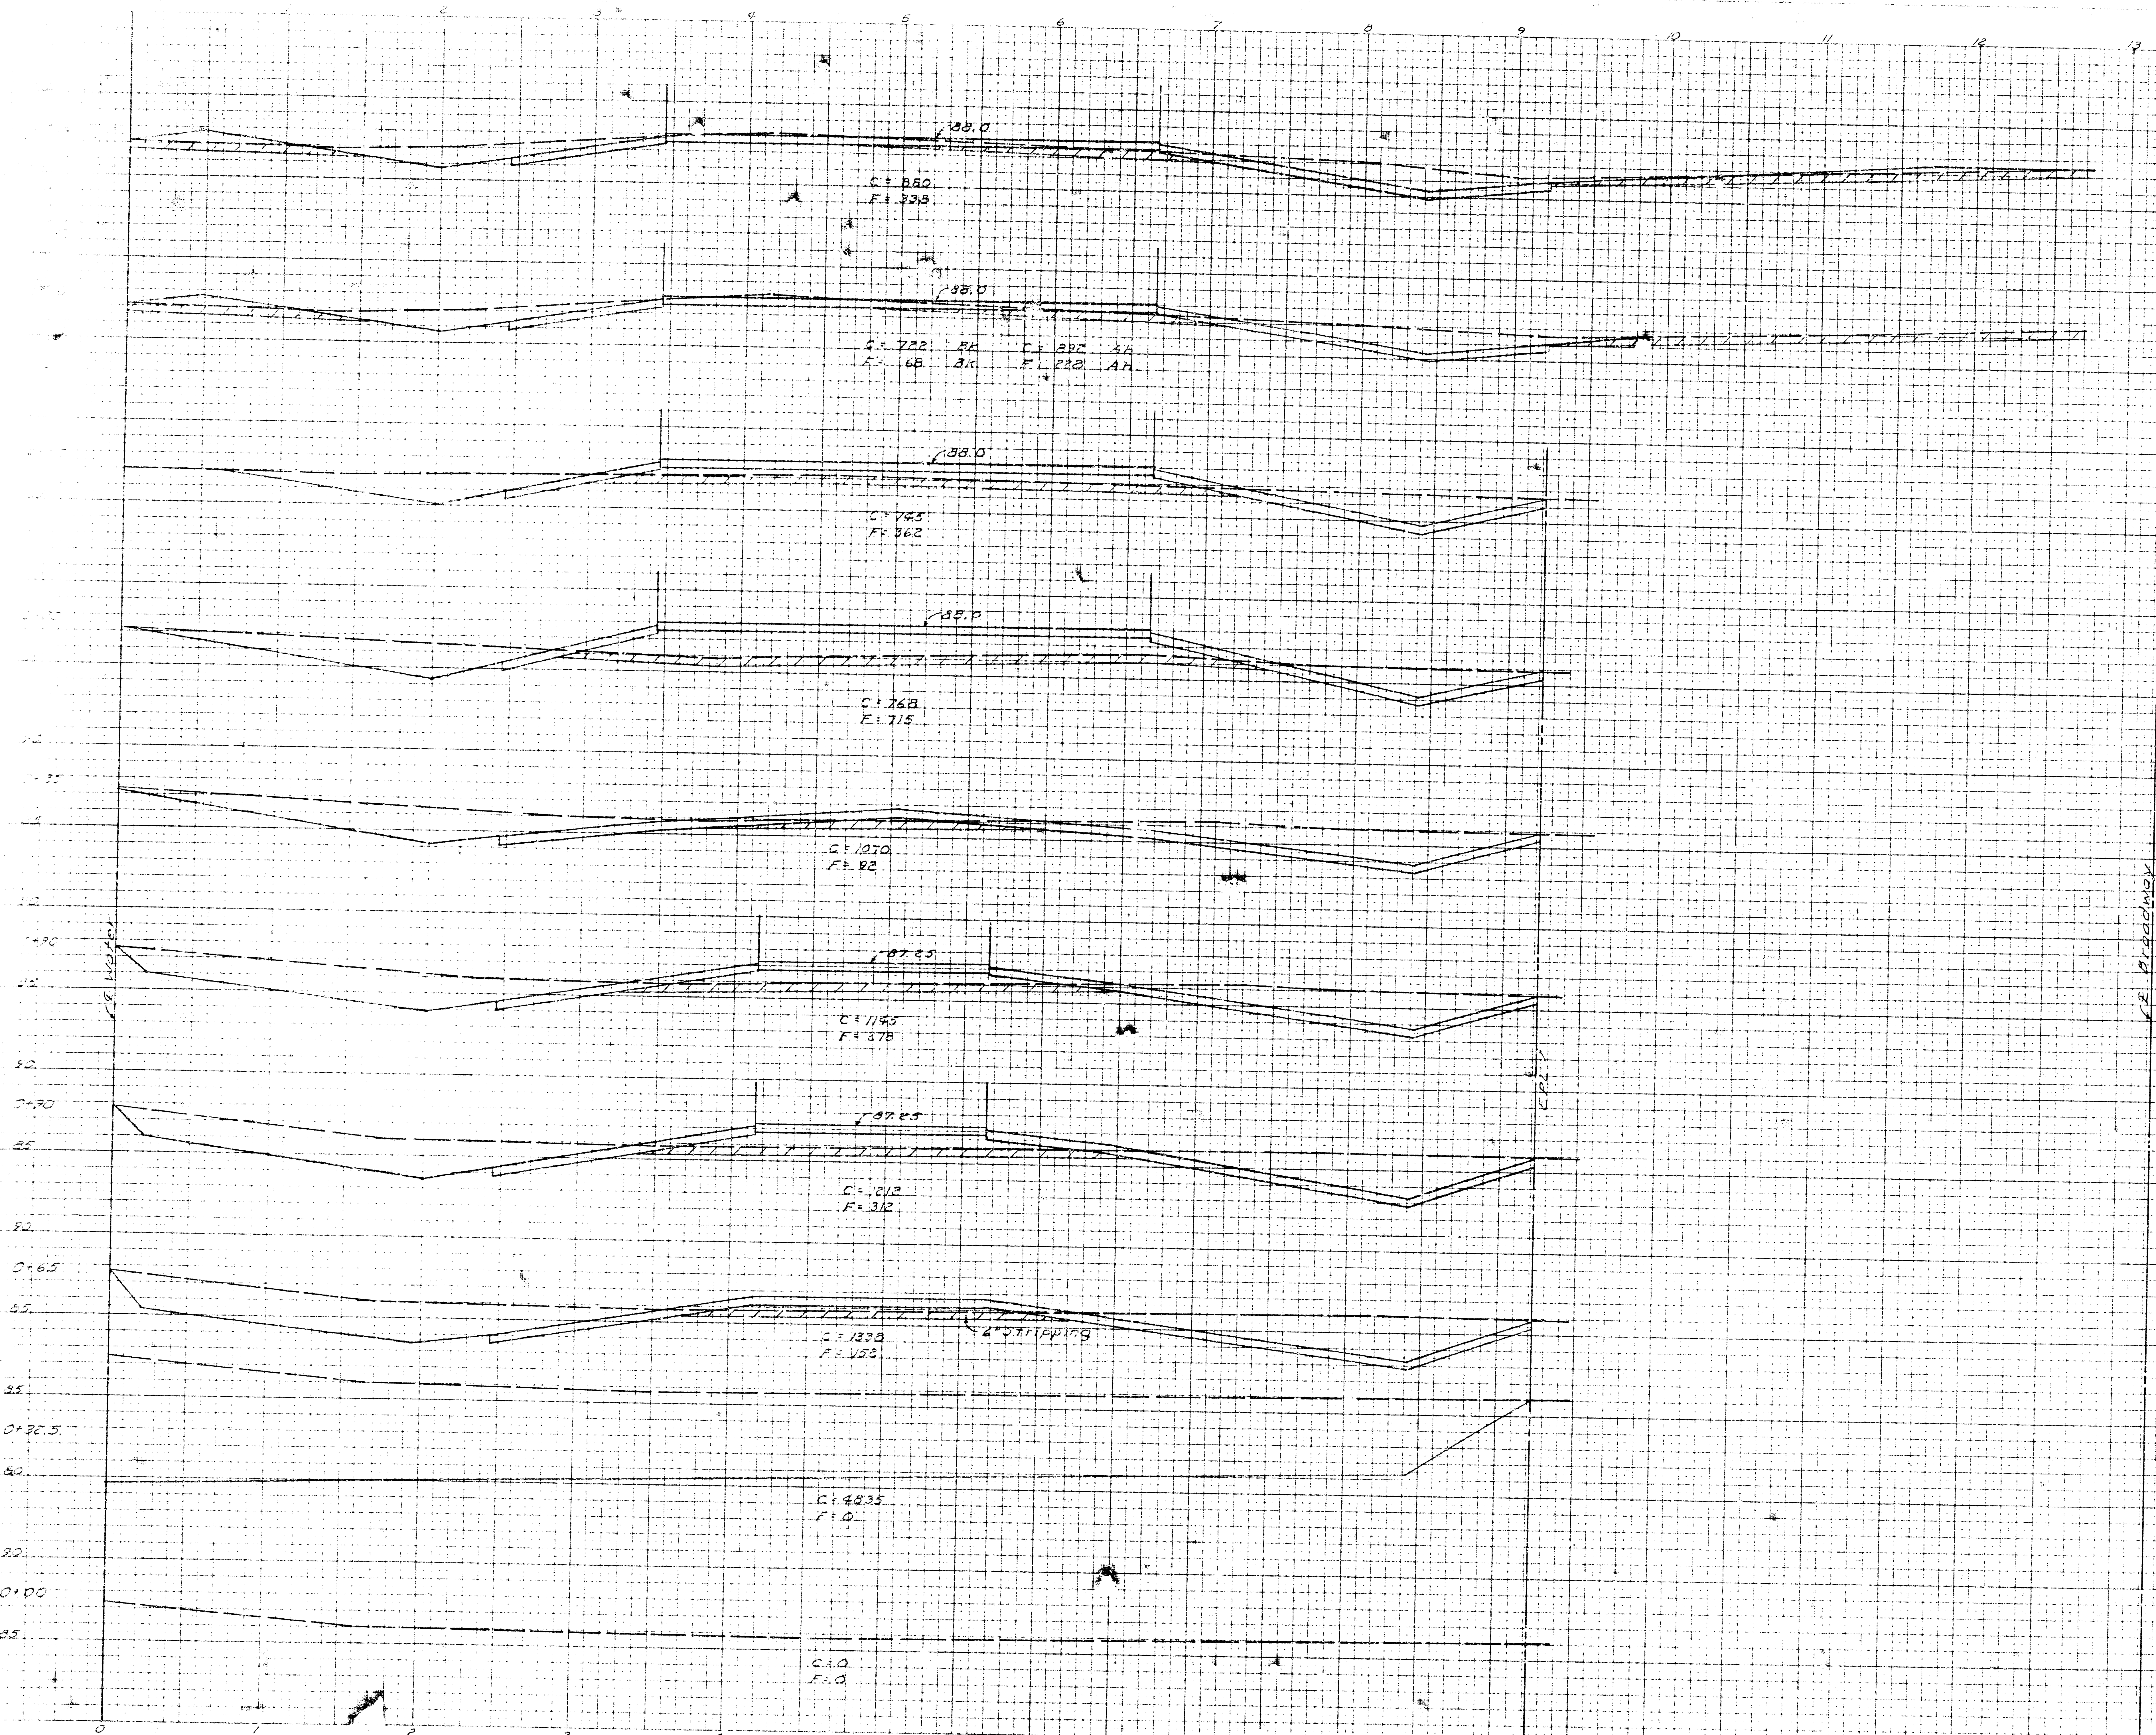

FIREBALL GRADING SECTION

