


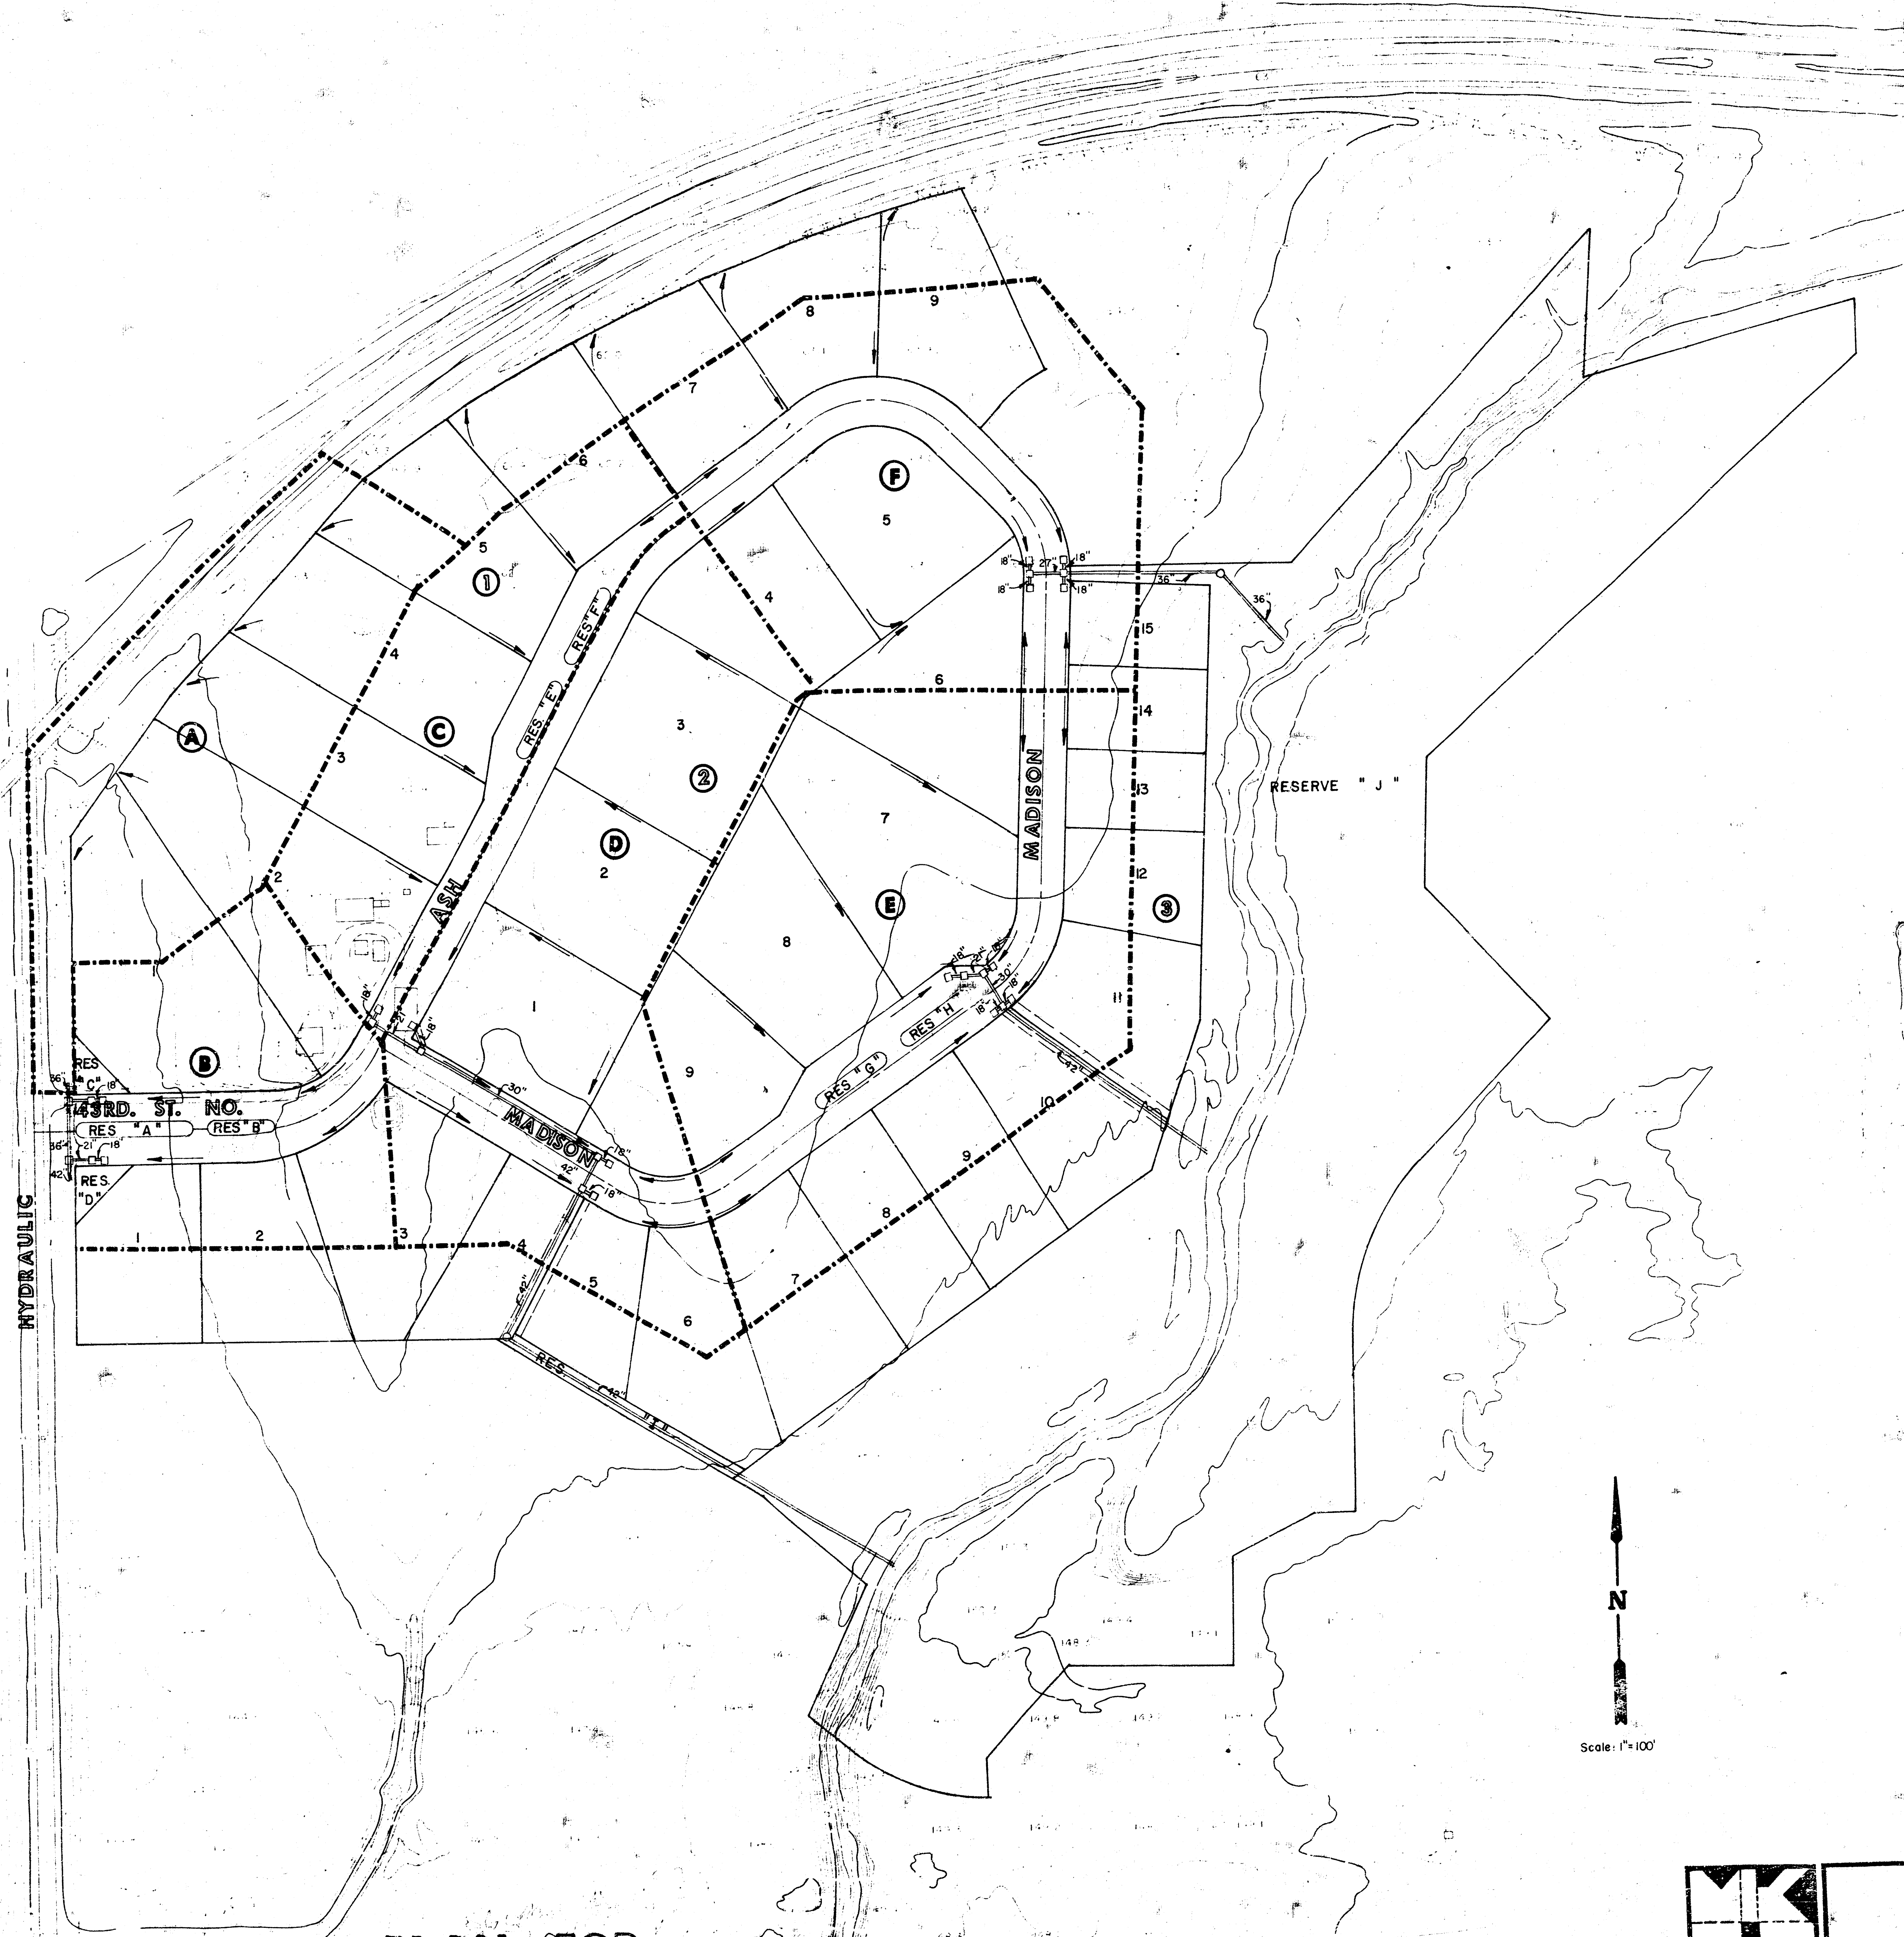


DRAINAGE PLAN FOR CHISHOLM CREEK COMMERCE CENTER

	Drawn by Checked by Date Job No.
	MID-KANSAS ENGINEERING CONSULTANTS PA 240 NORTH ROCK ROAD SUITE 130 WICHITA, KANSAS 67206
	682-6561
	Sheet of

[illegible]


CHISHOLM CREEK COMMERCE CENTER
(DRAINAGE)

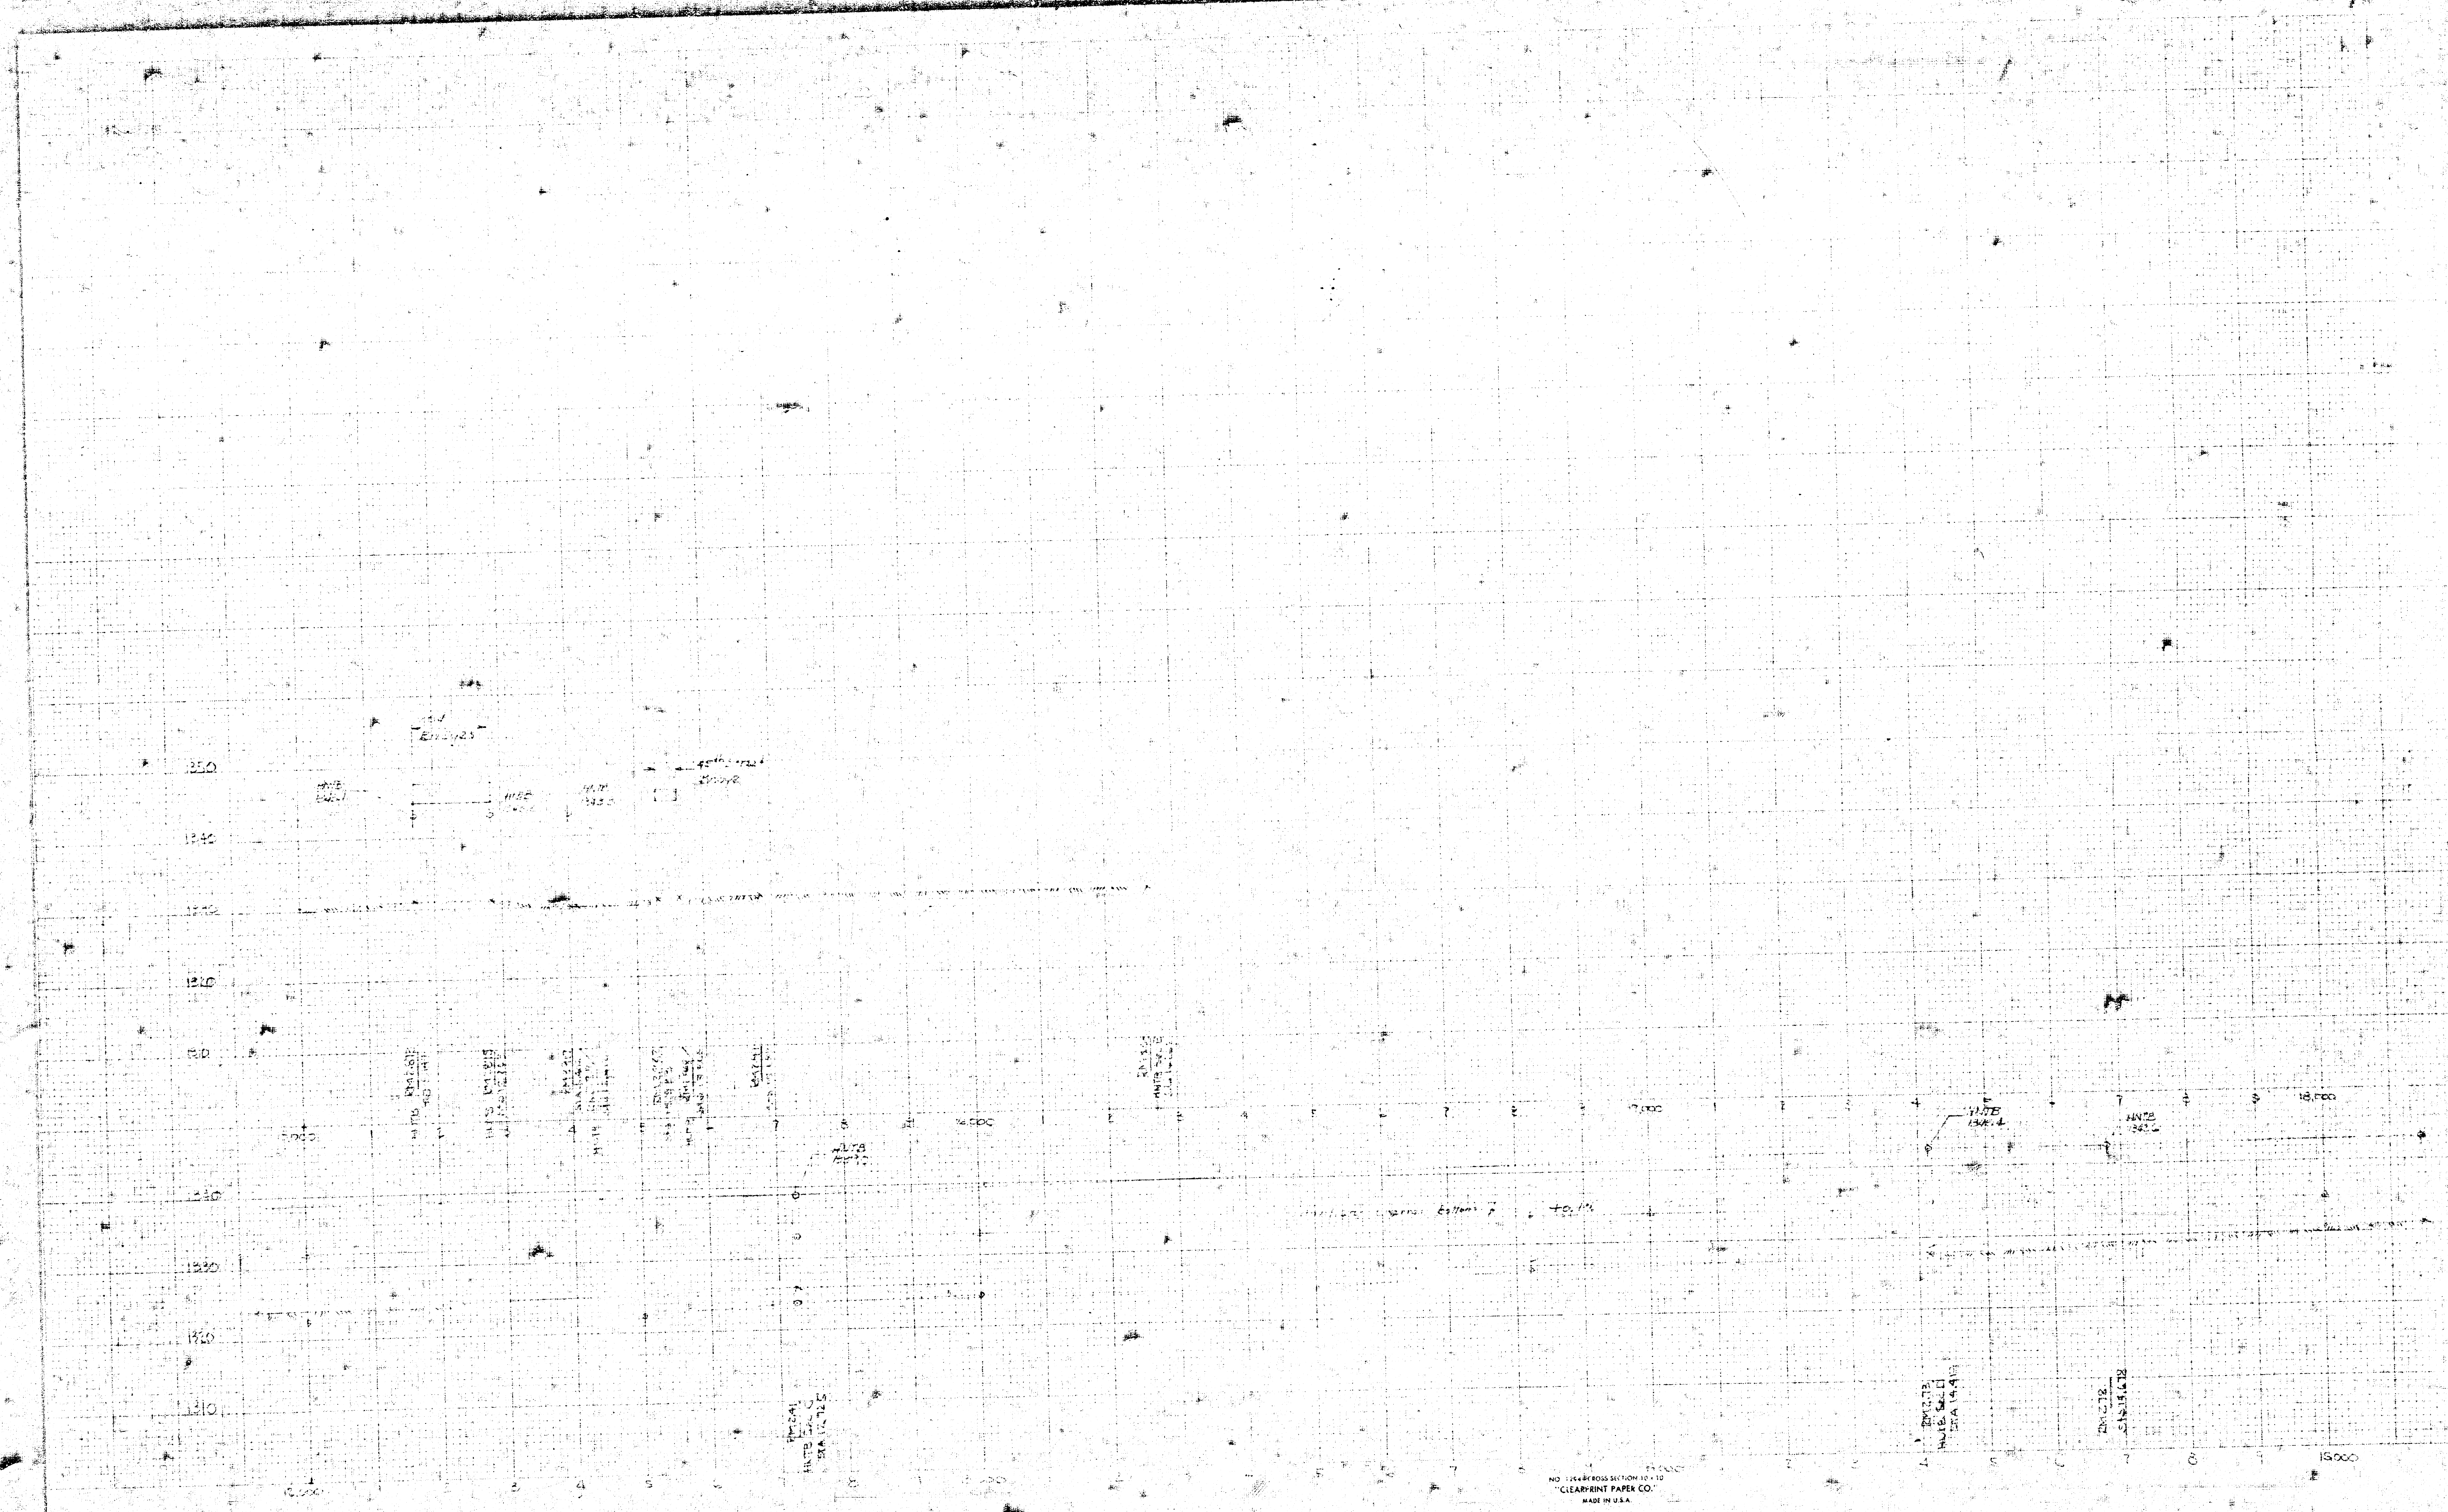

NO. 1264 CROSS SECTION 10 x 10
"CLEARPRINT PAPER CO."
MADE IN U.S.A.


FILMED FROM THE BEST
AVAILABLE COPY

CHISHOLM CREEK COMMERCE CENTER
(DRAINAGE)

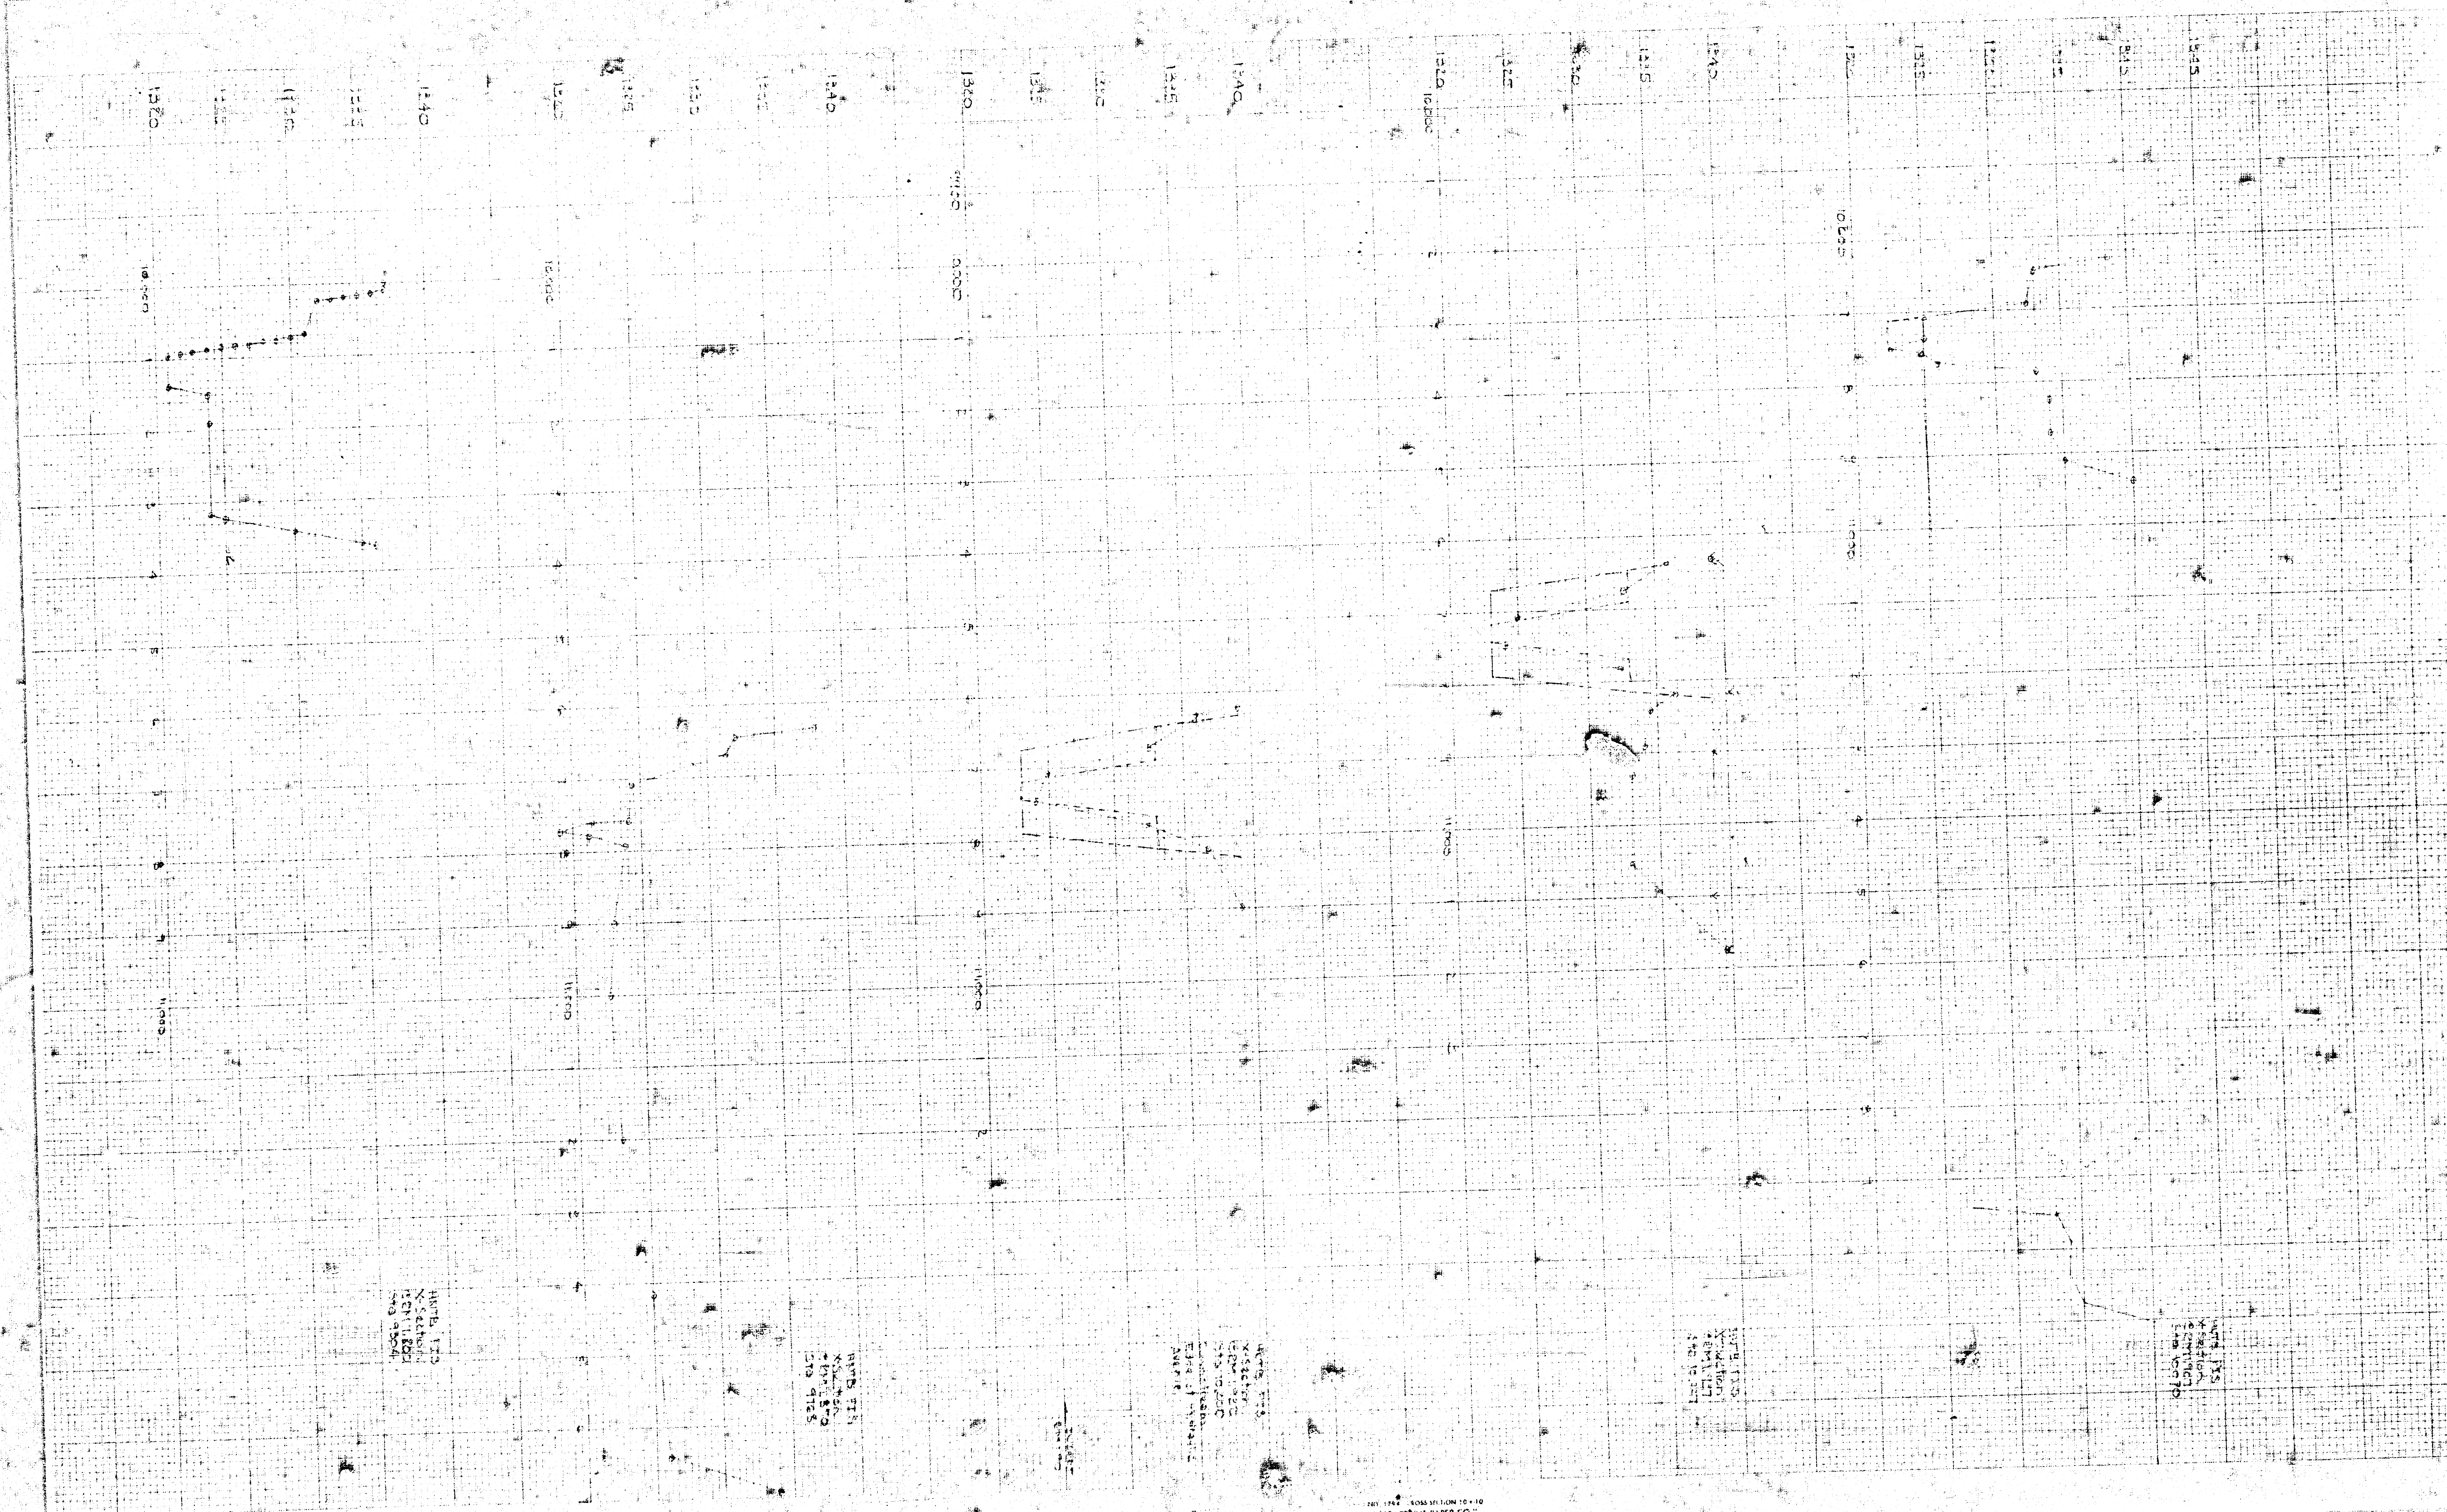


FILMED FROM THE BEST
AVAILABLE COPY.....

7-11-68
7-11-68

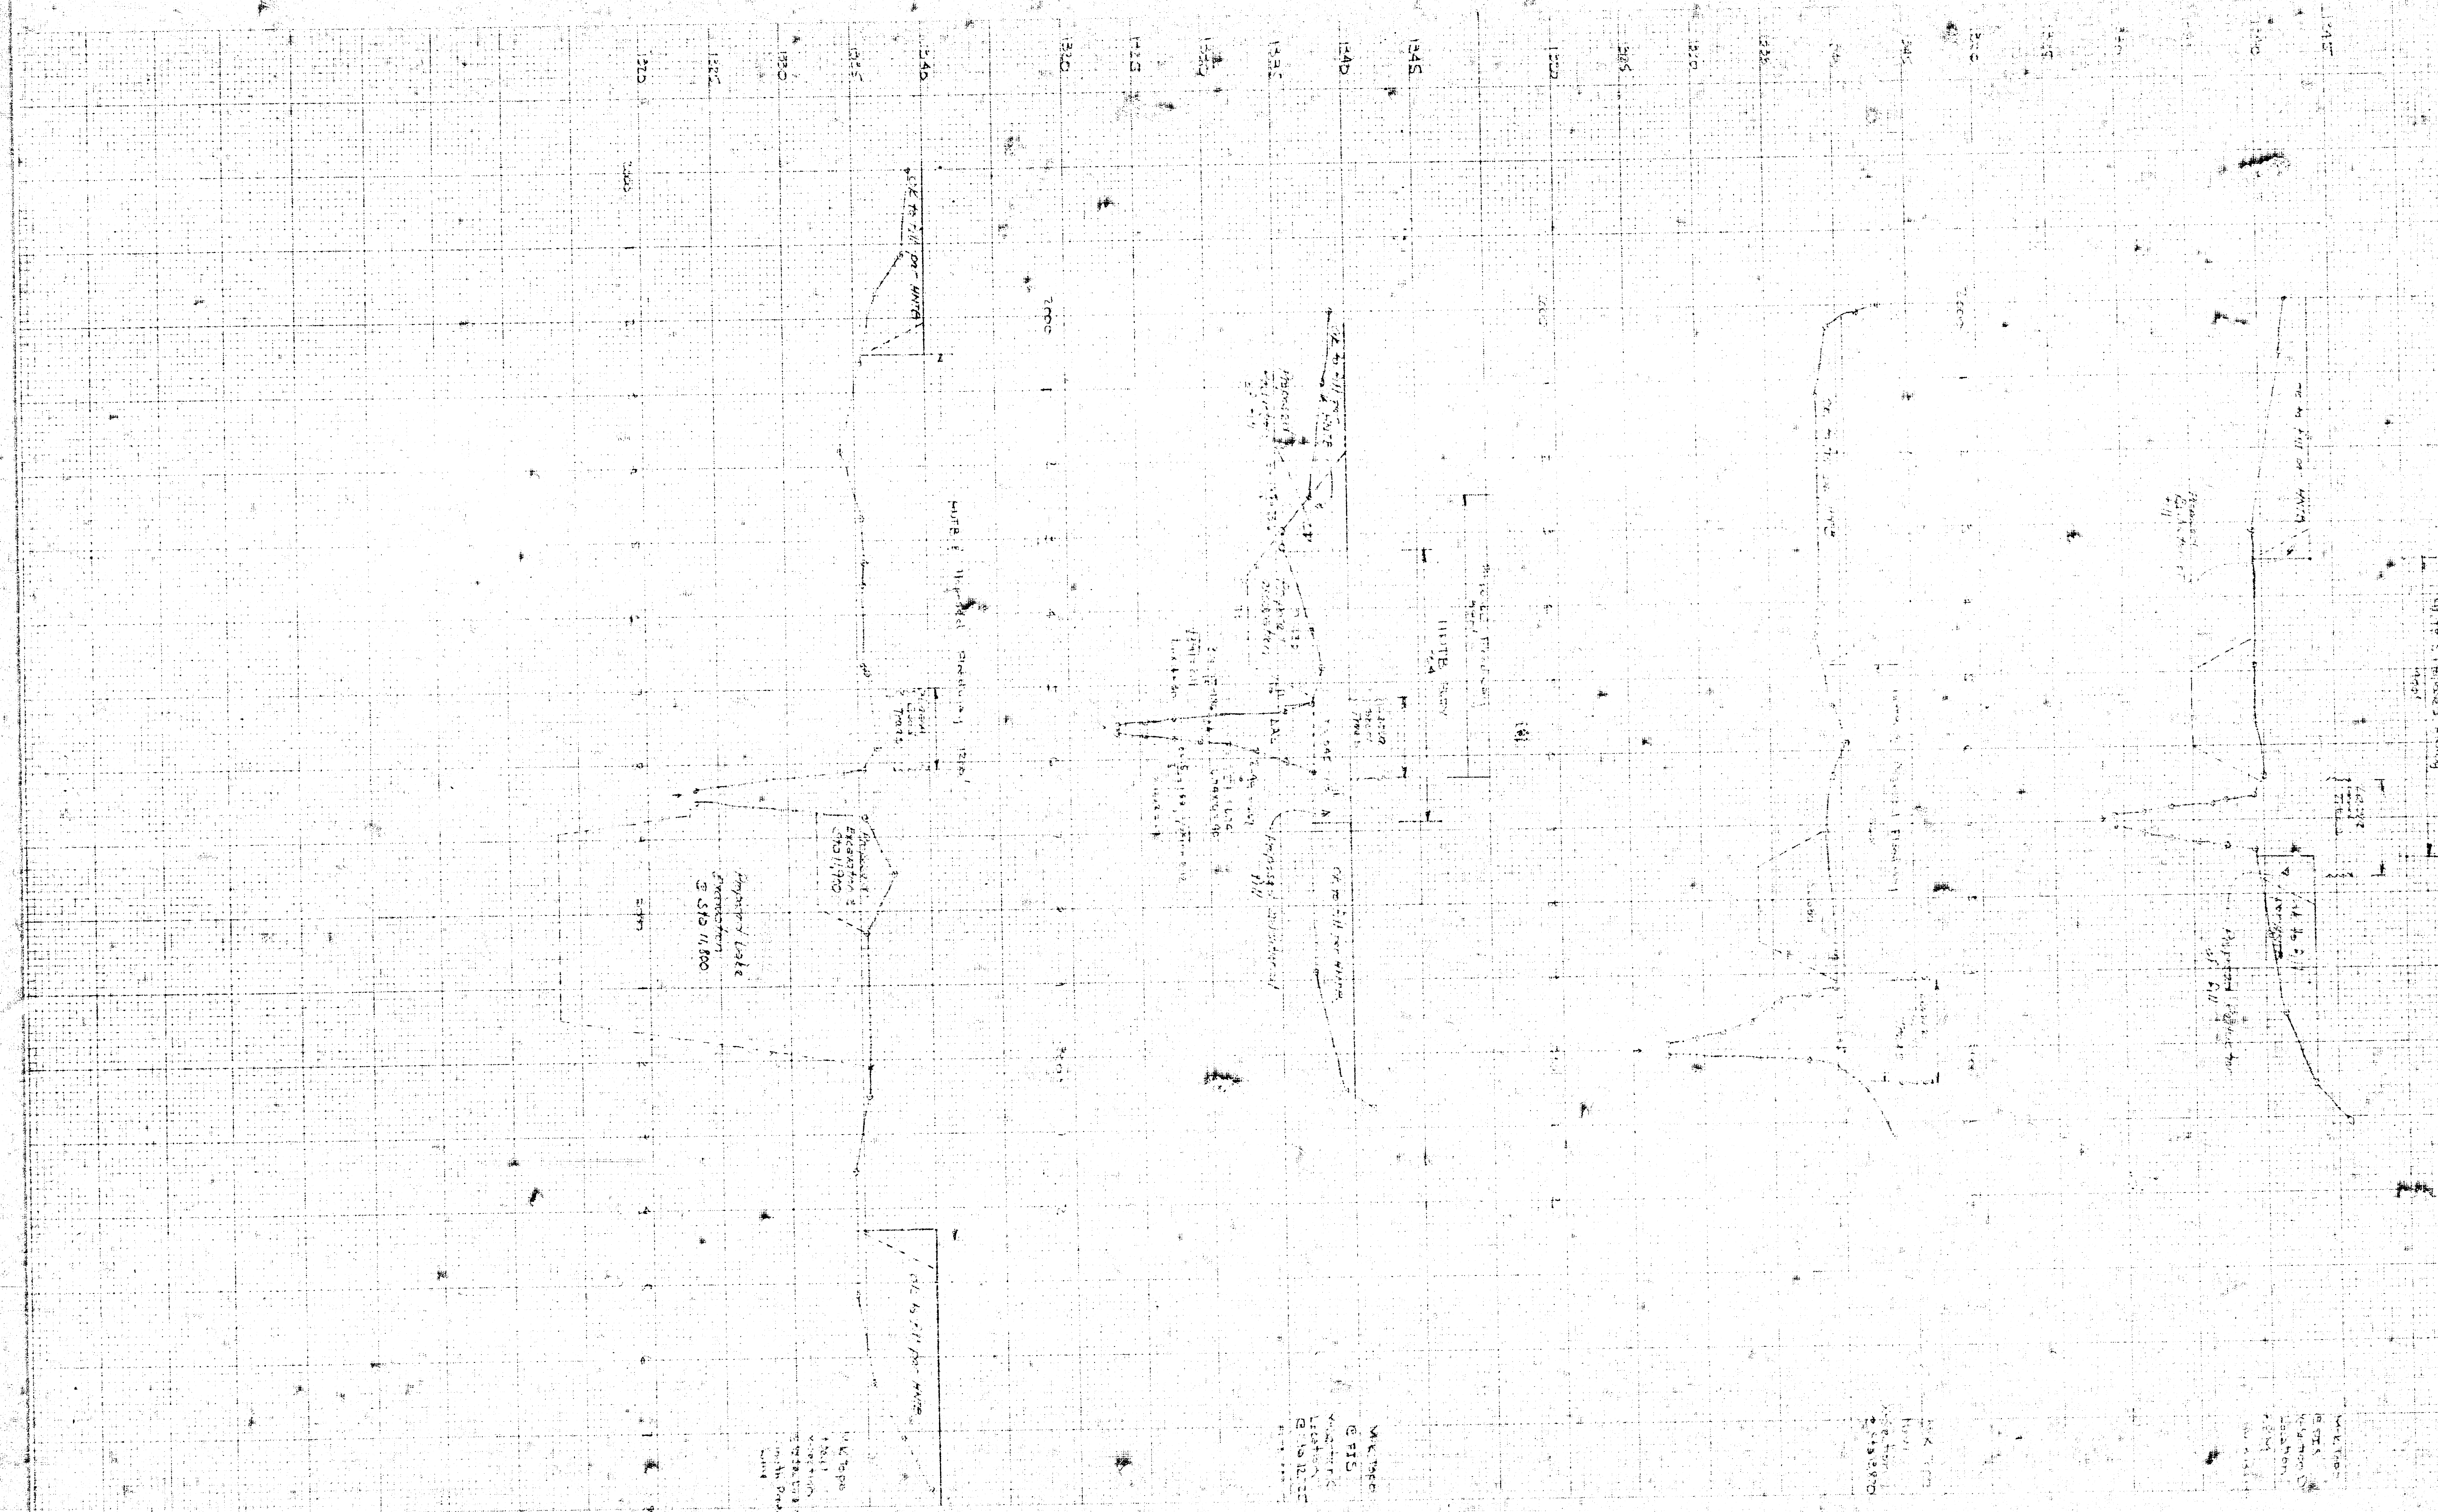

FILMED FROM THE BEST
AVAILABLE COPY

CHISHOLM CREEK CONCRETE CENTER
(DRAINAGE)

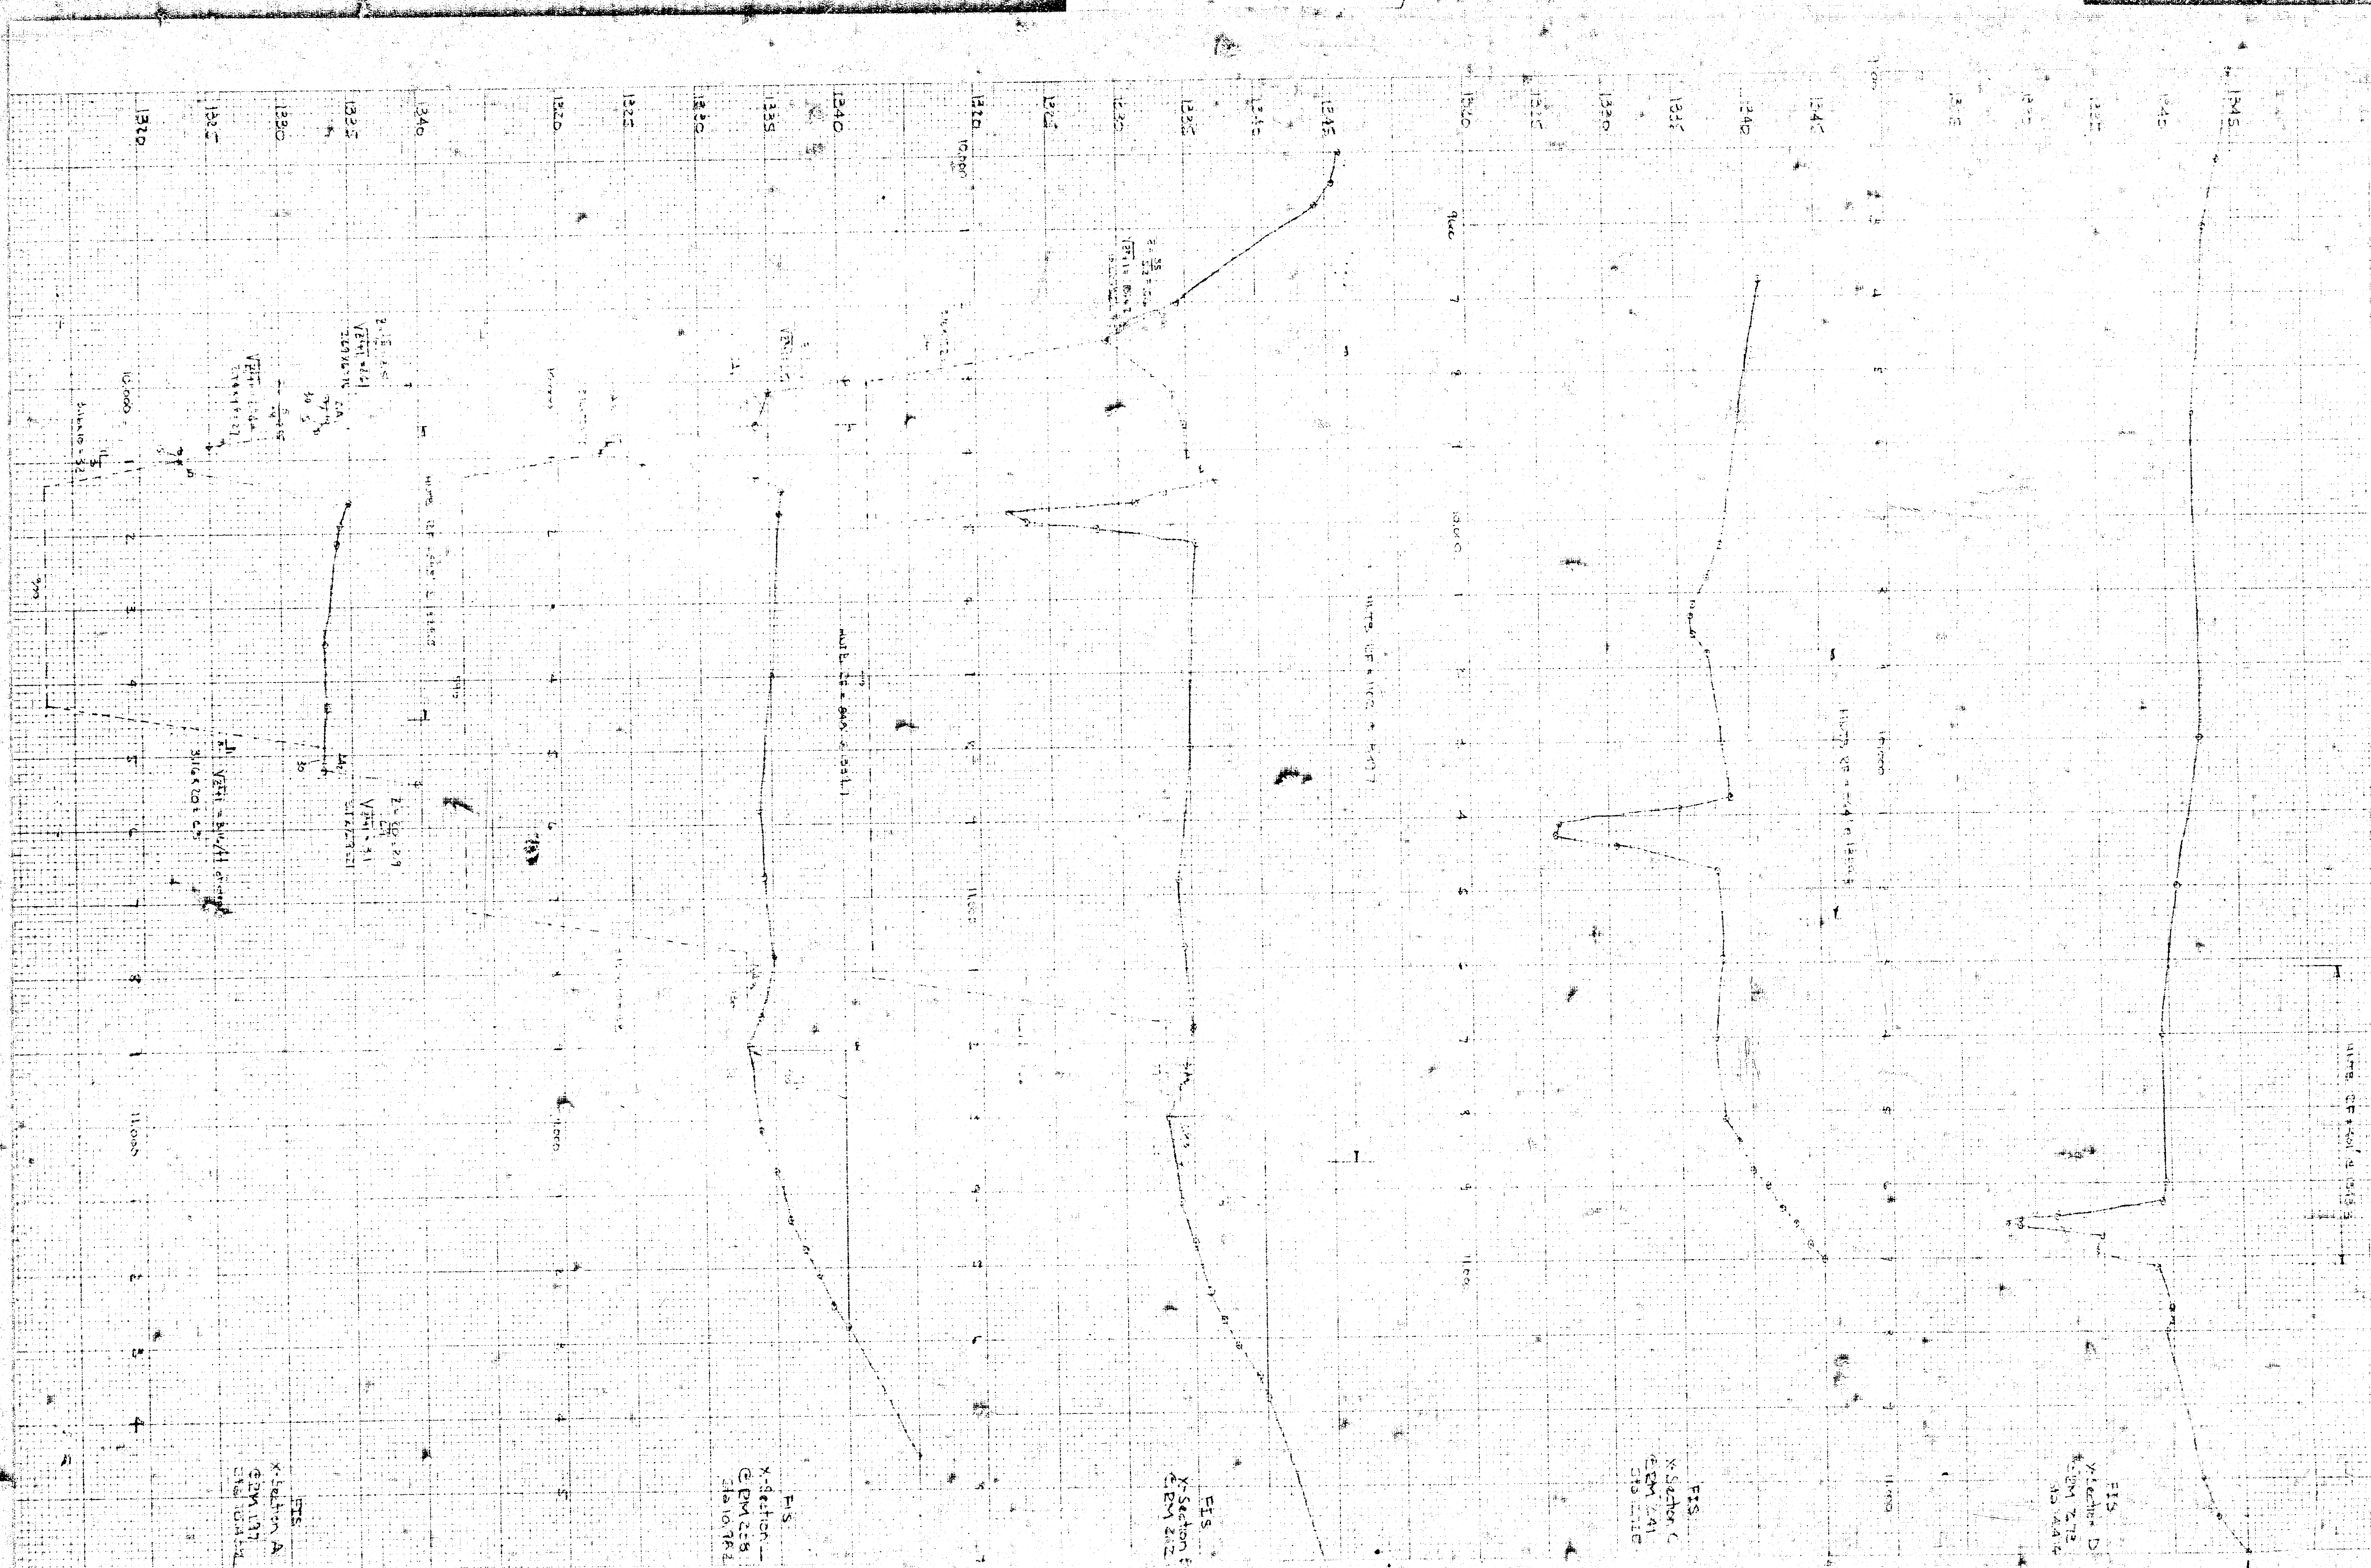

FILMED FROM THE BEST
AVAILABLE COPY