



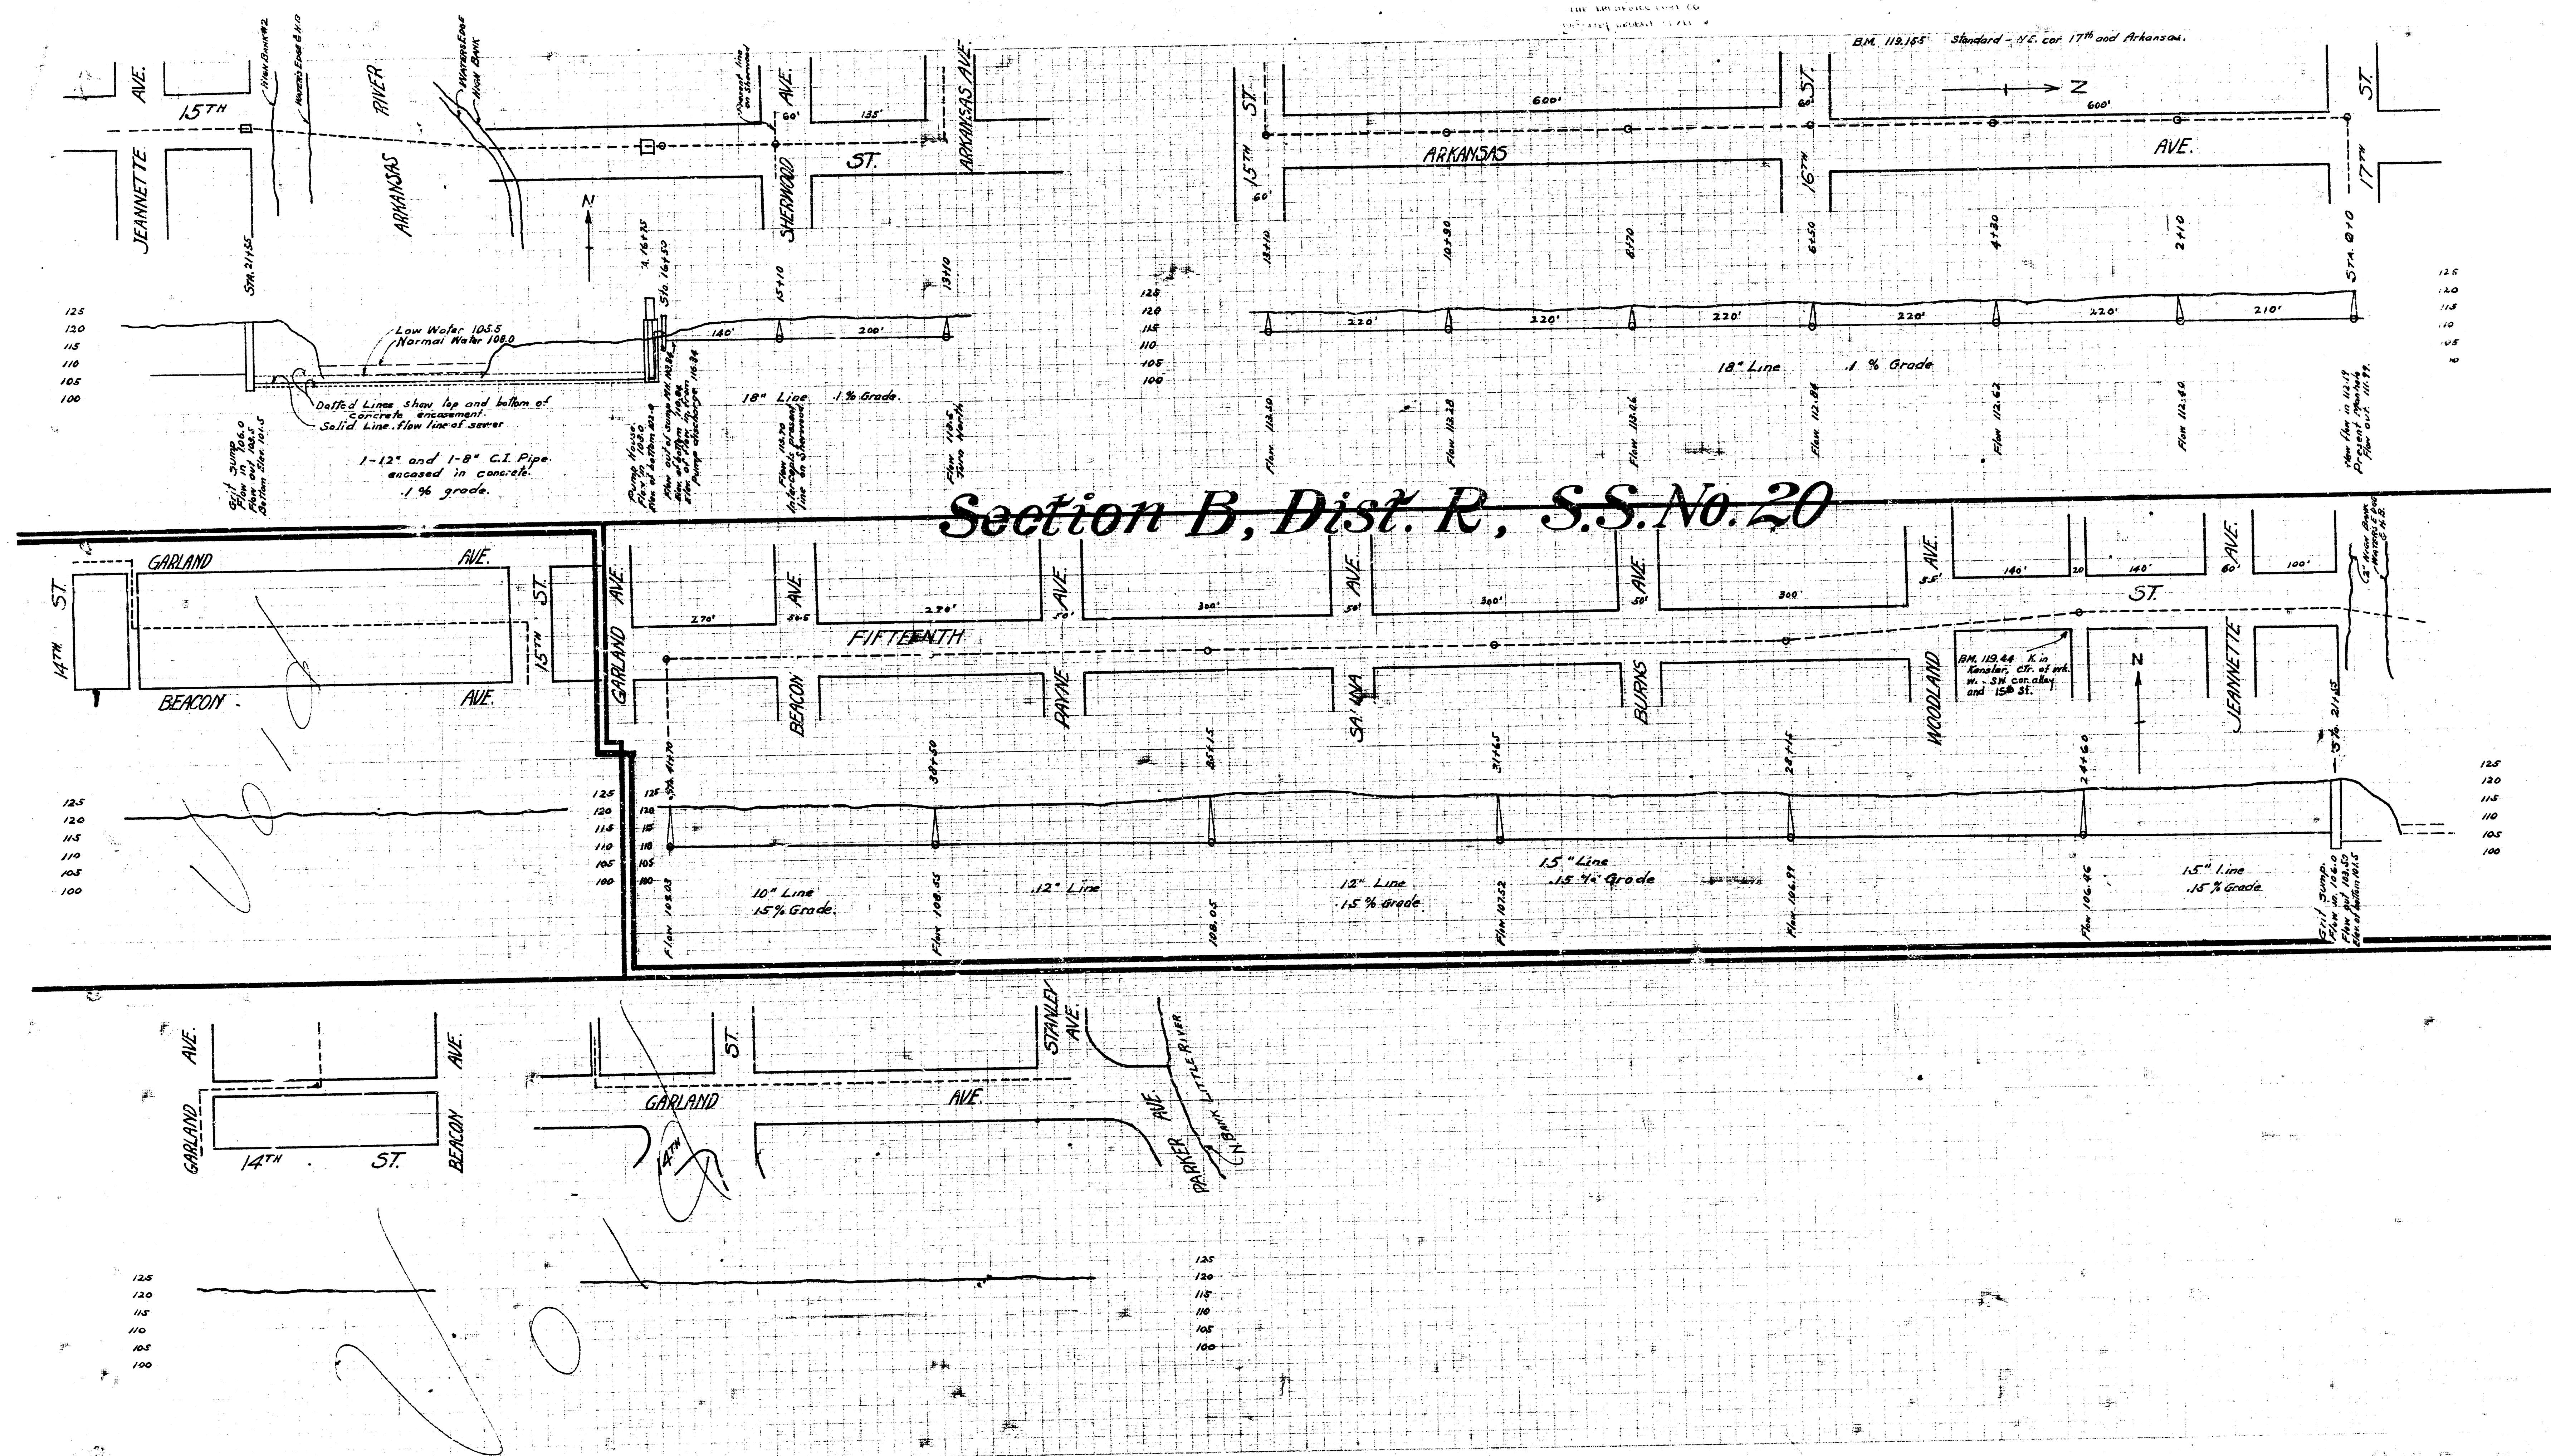


Typical Door Section


Section of Doorway
Scale: 1" = 1'-0"


• POWER LAYOUT
SCALE 1/4" = 1'-0"

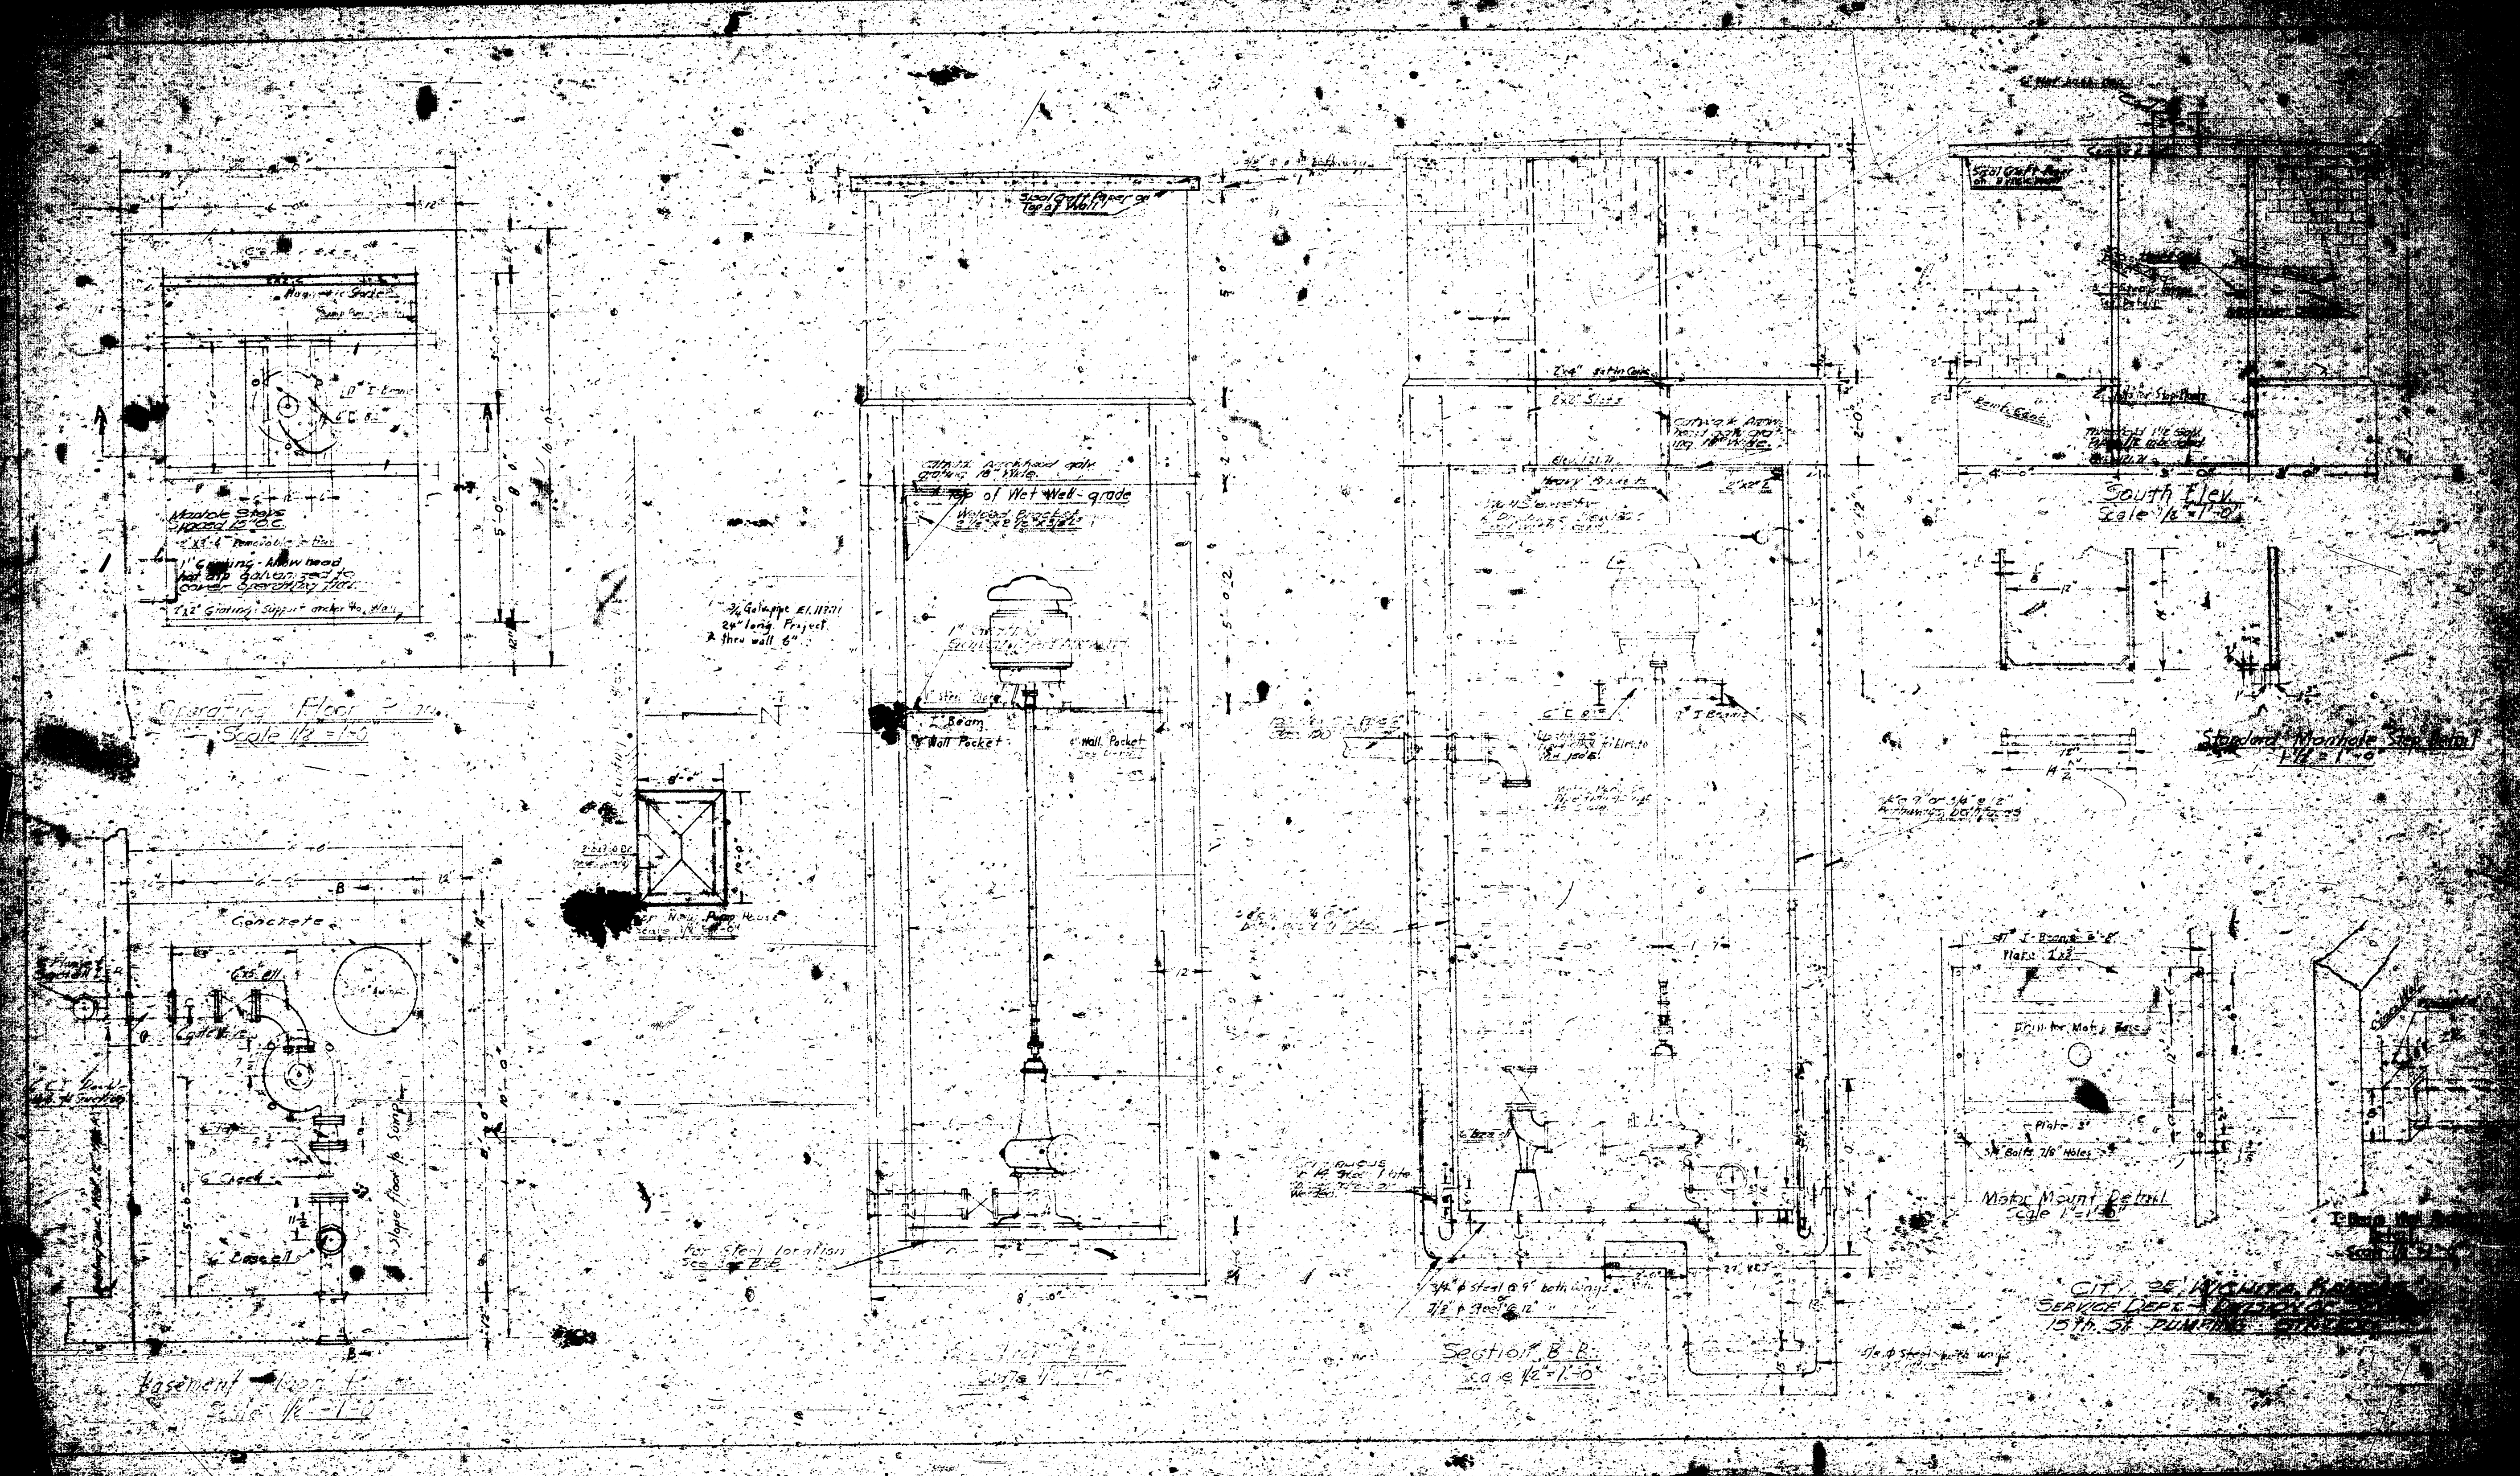

CITY OF WICHITA, KANSAS
SERVICE DEPT. DIVISION OF ENGINEERS
12th ST. PUMPING STATION

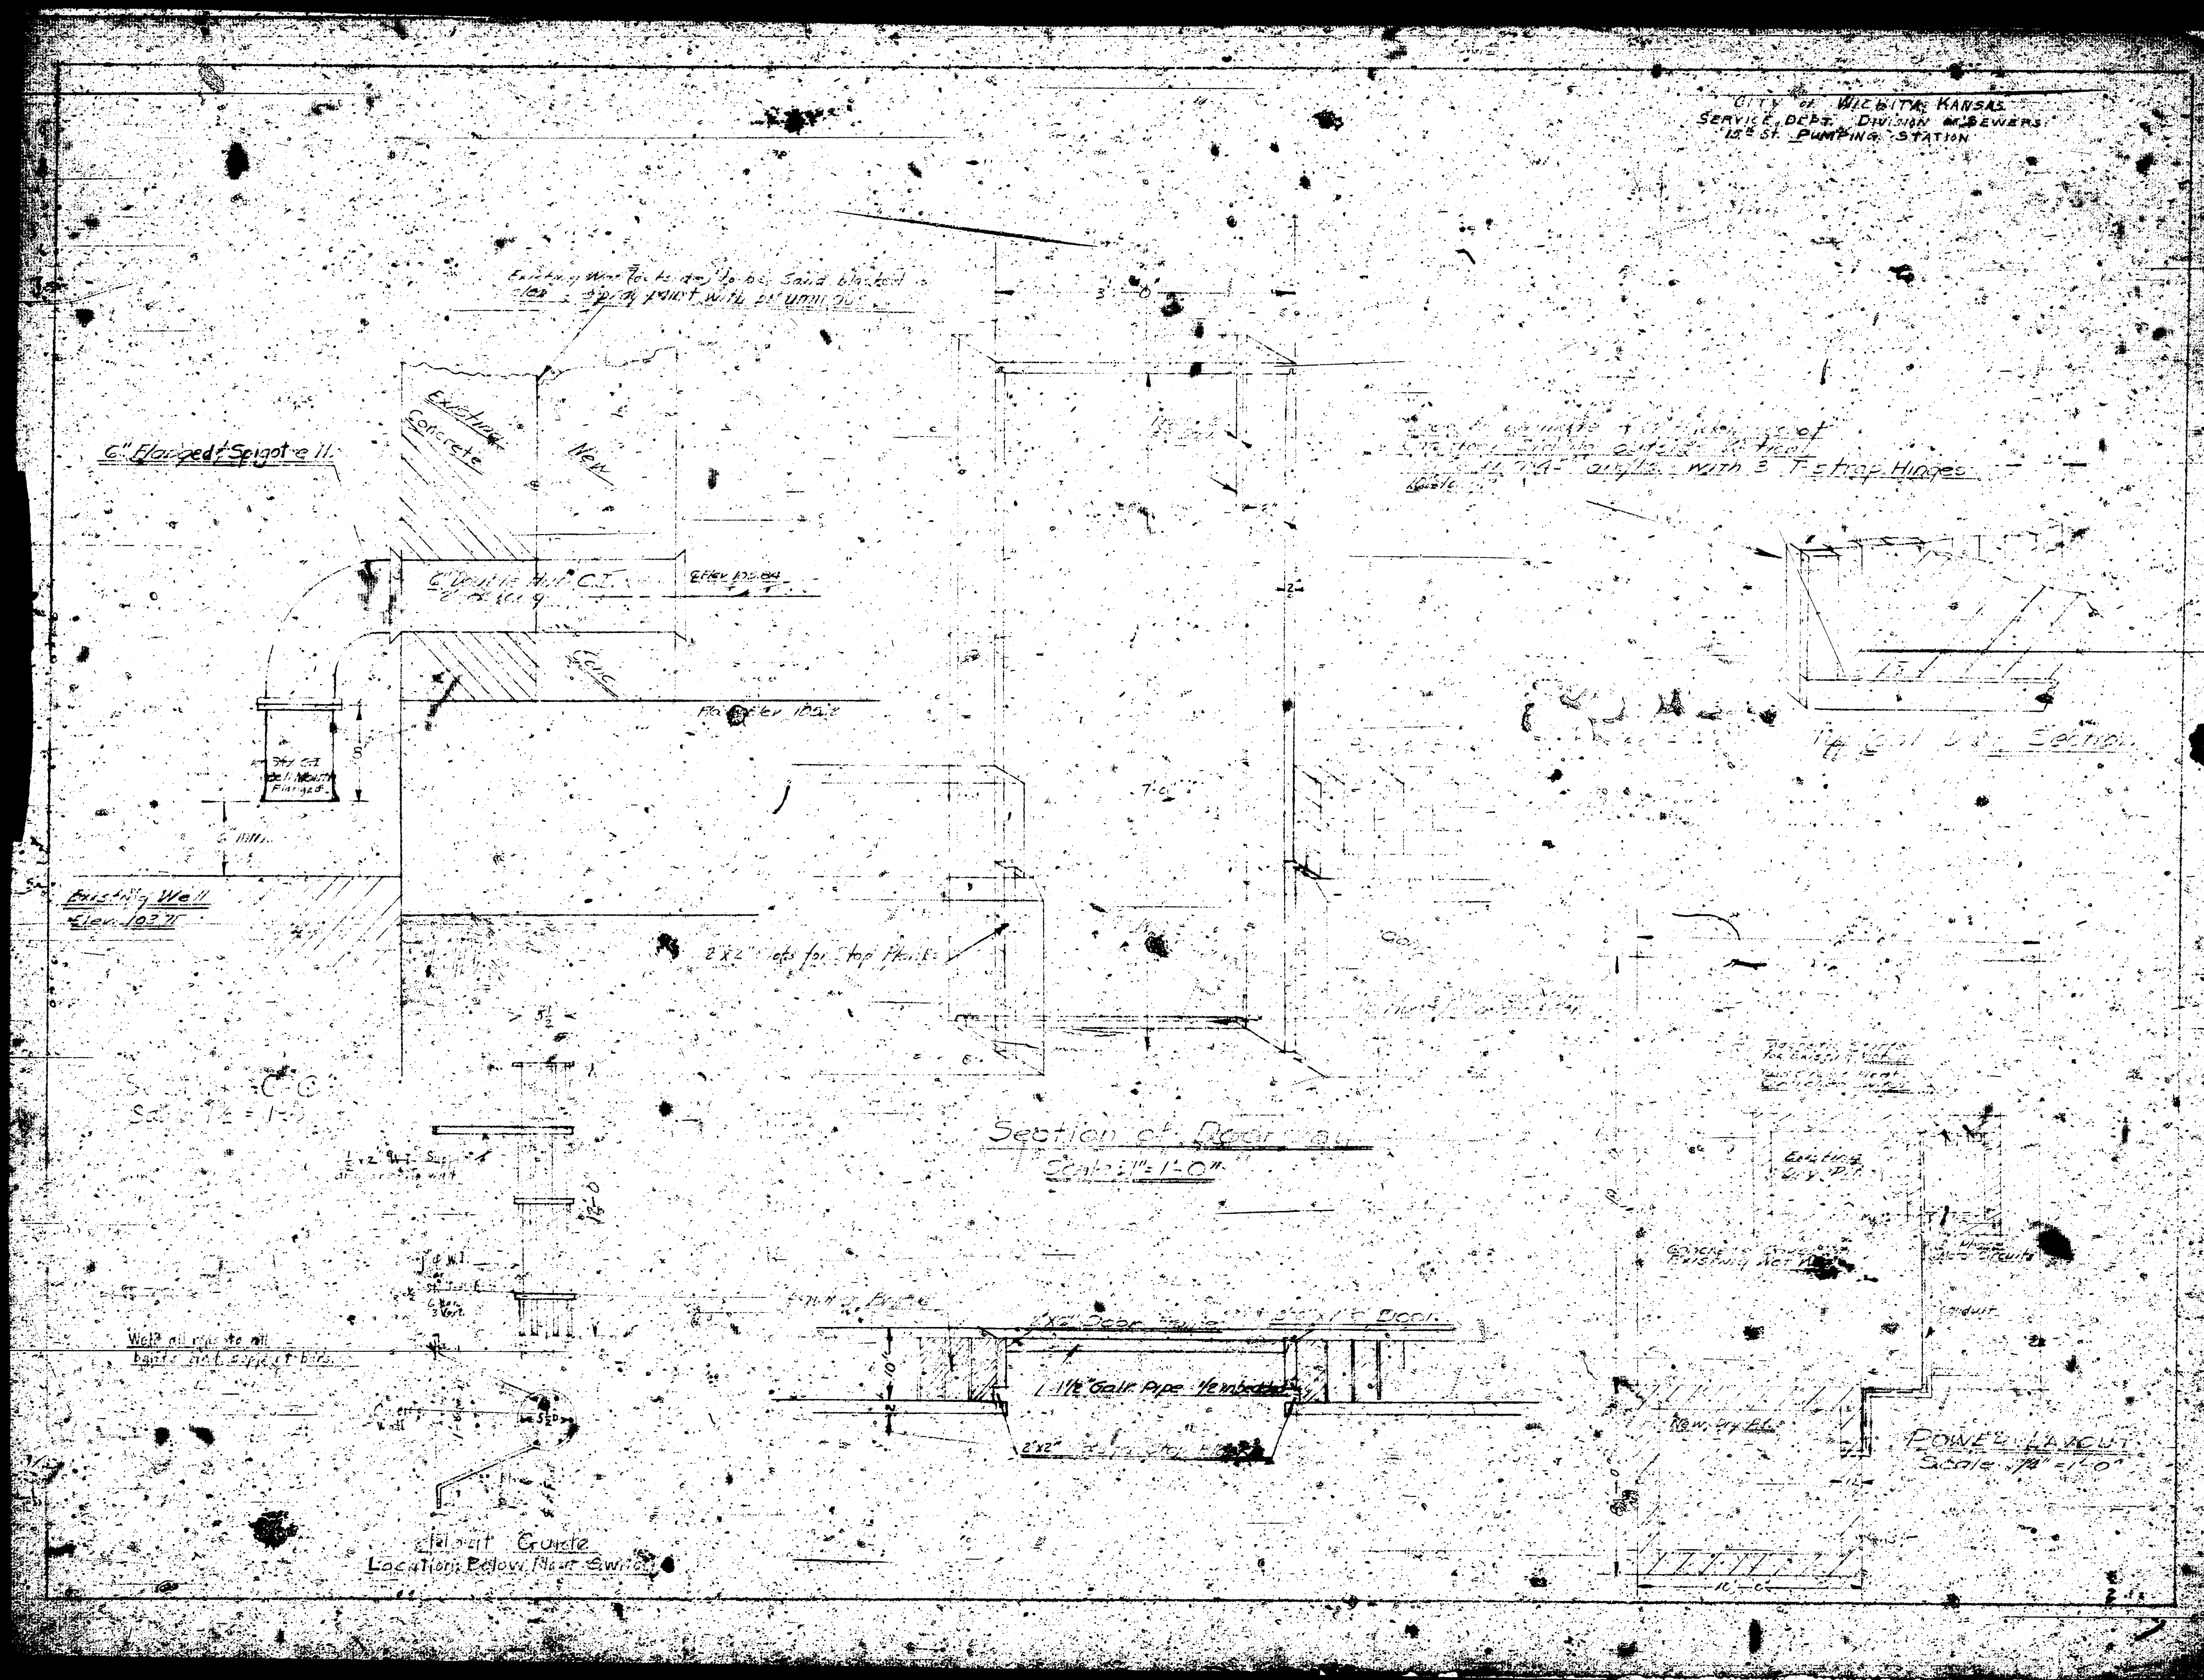

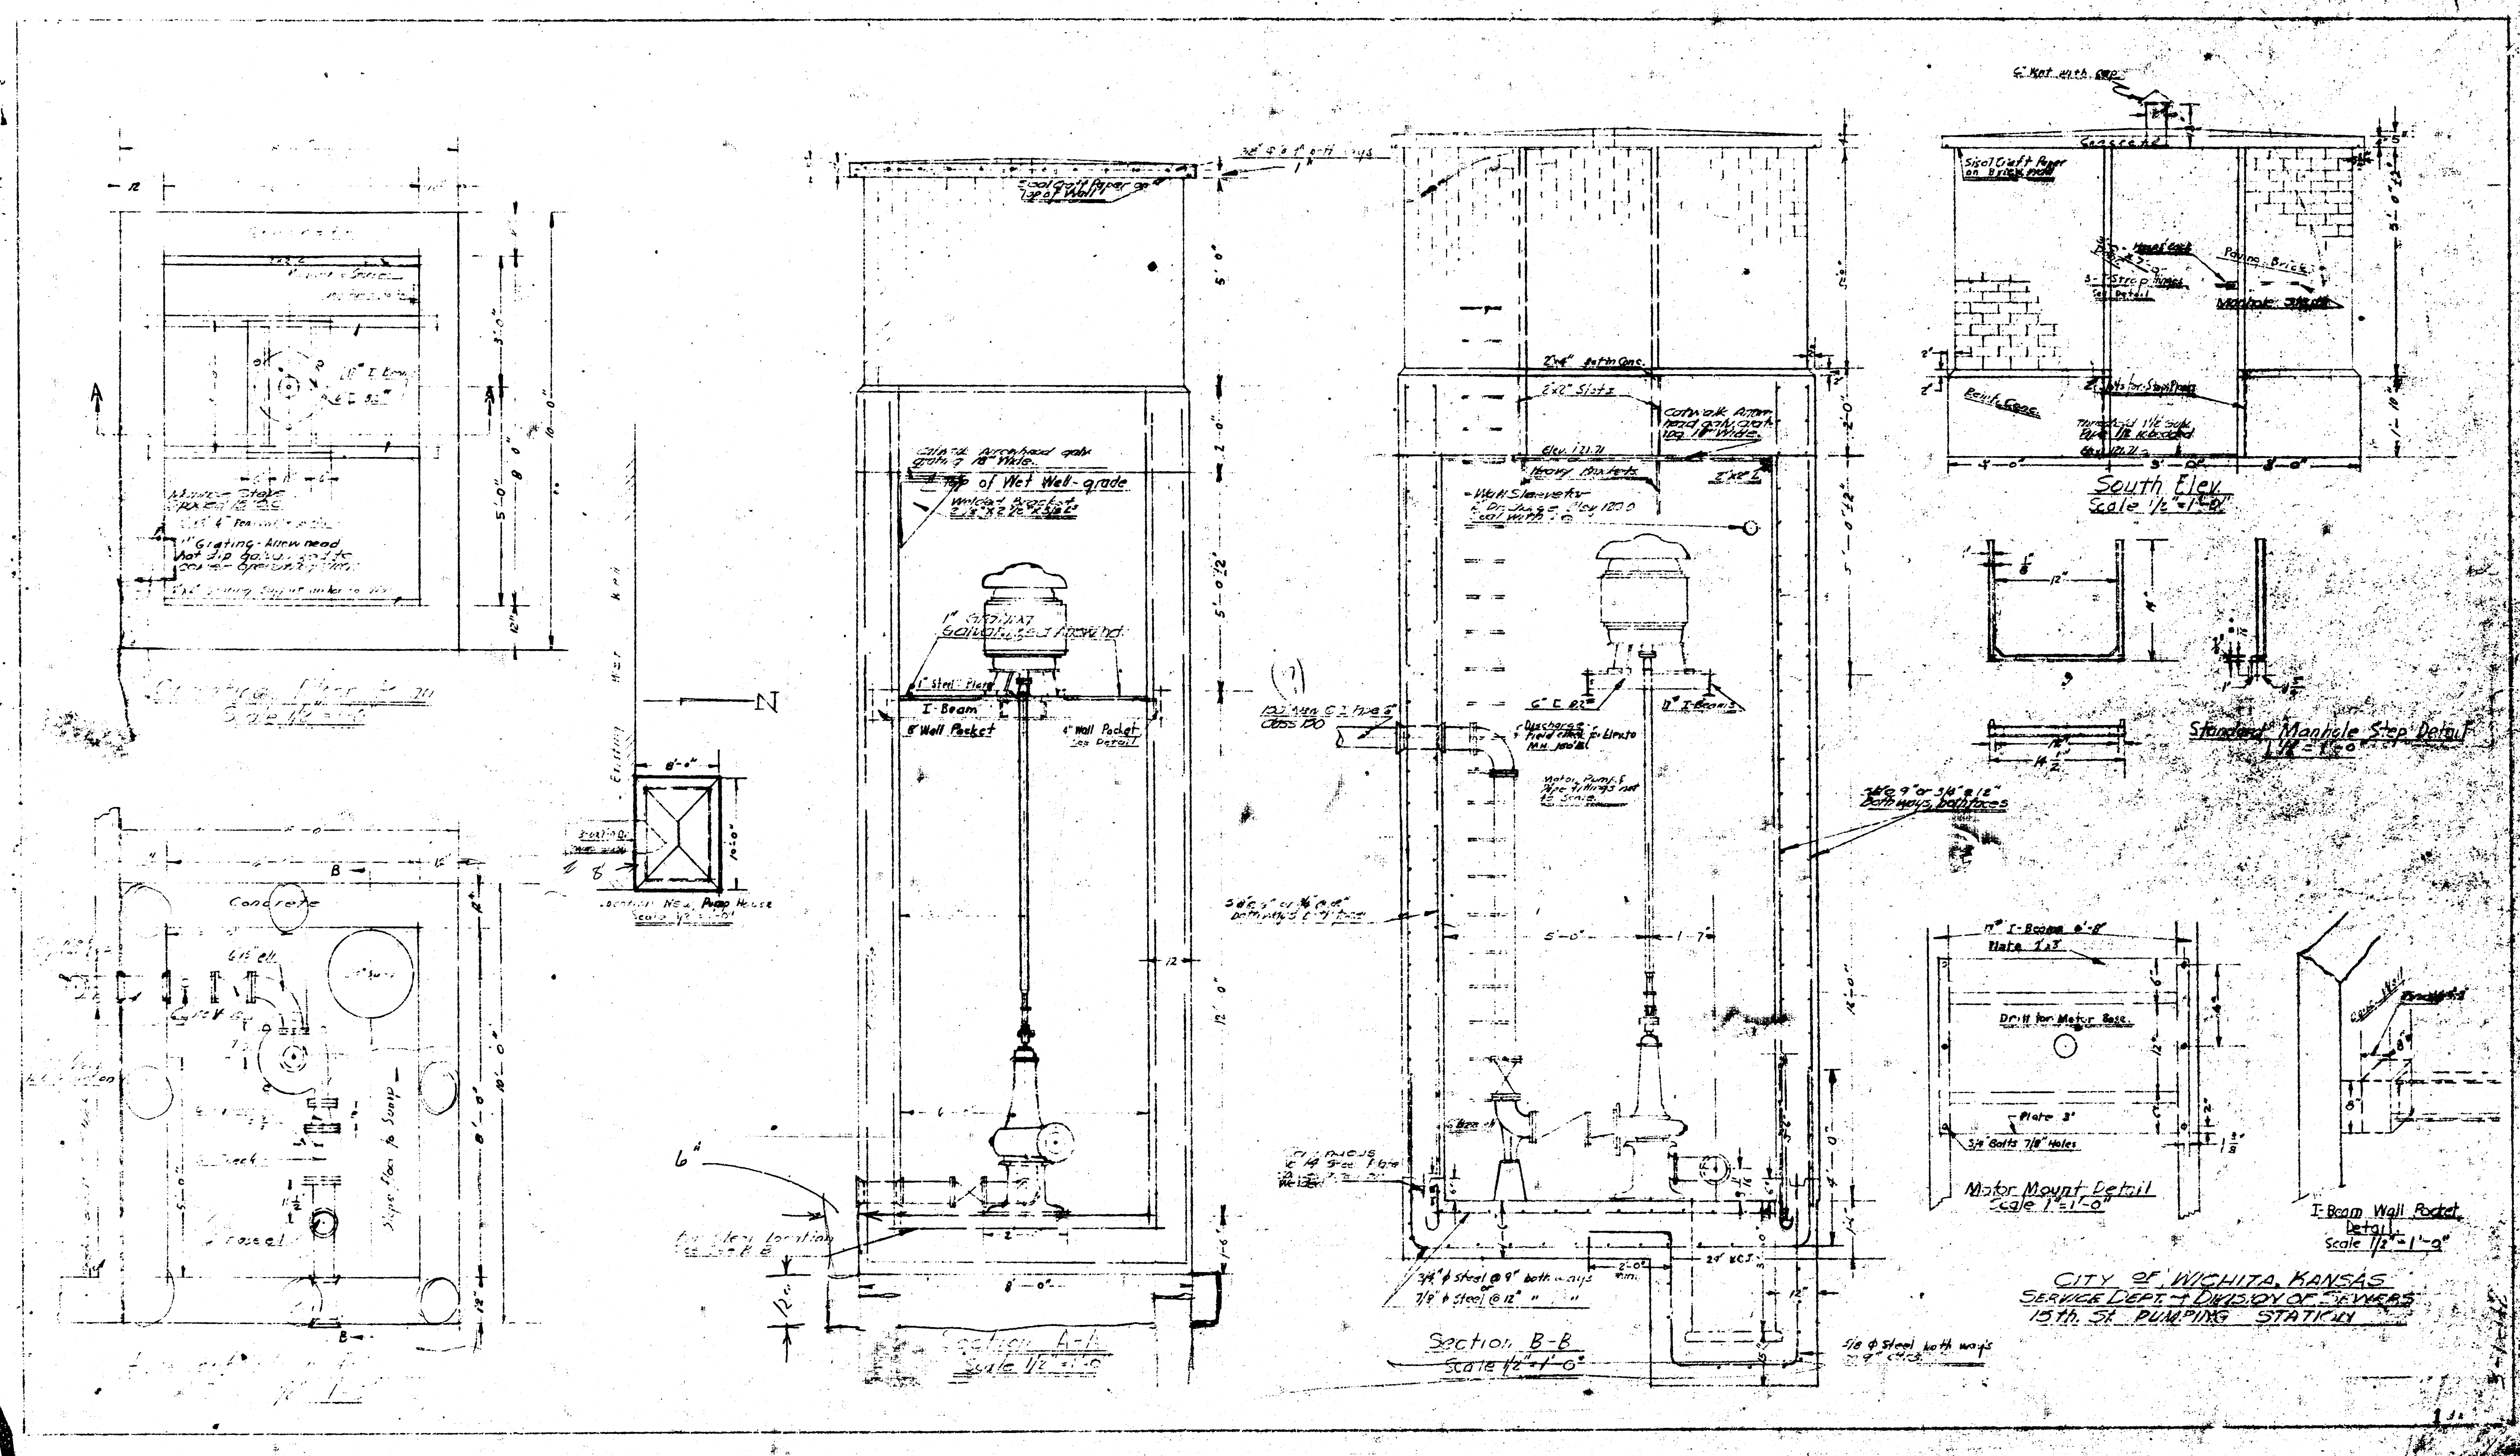

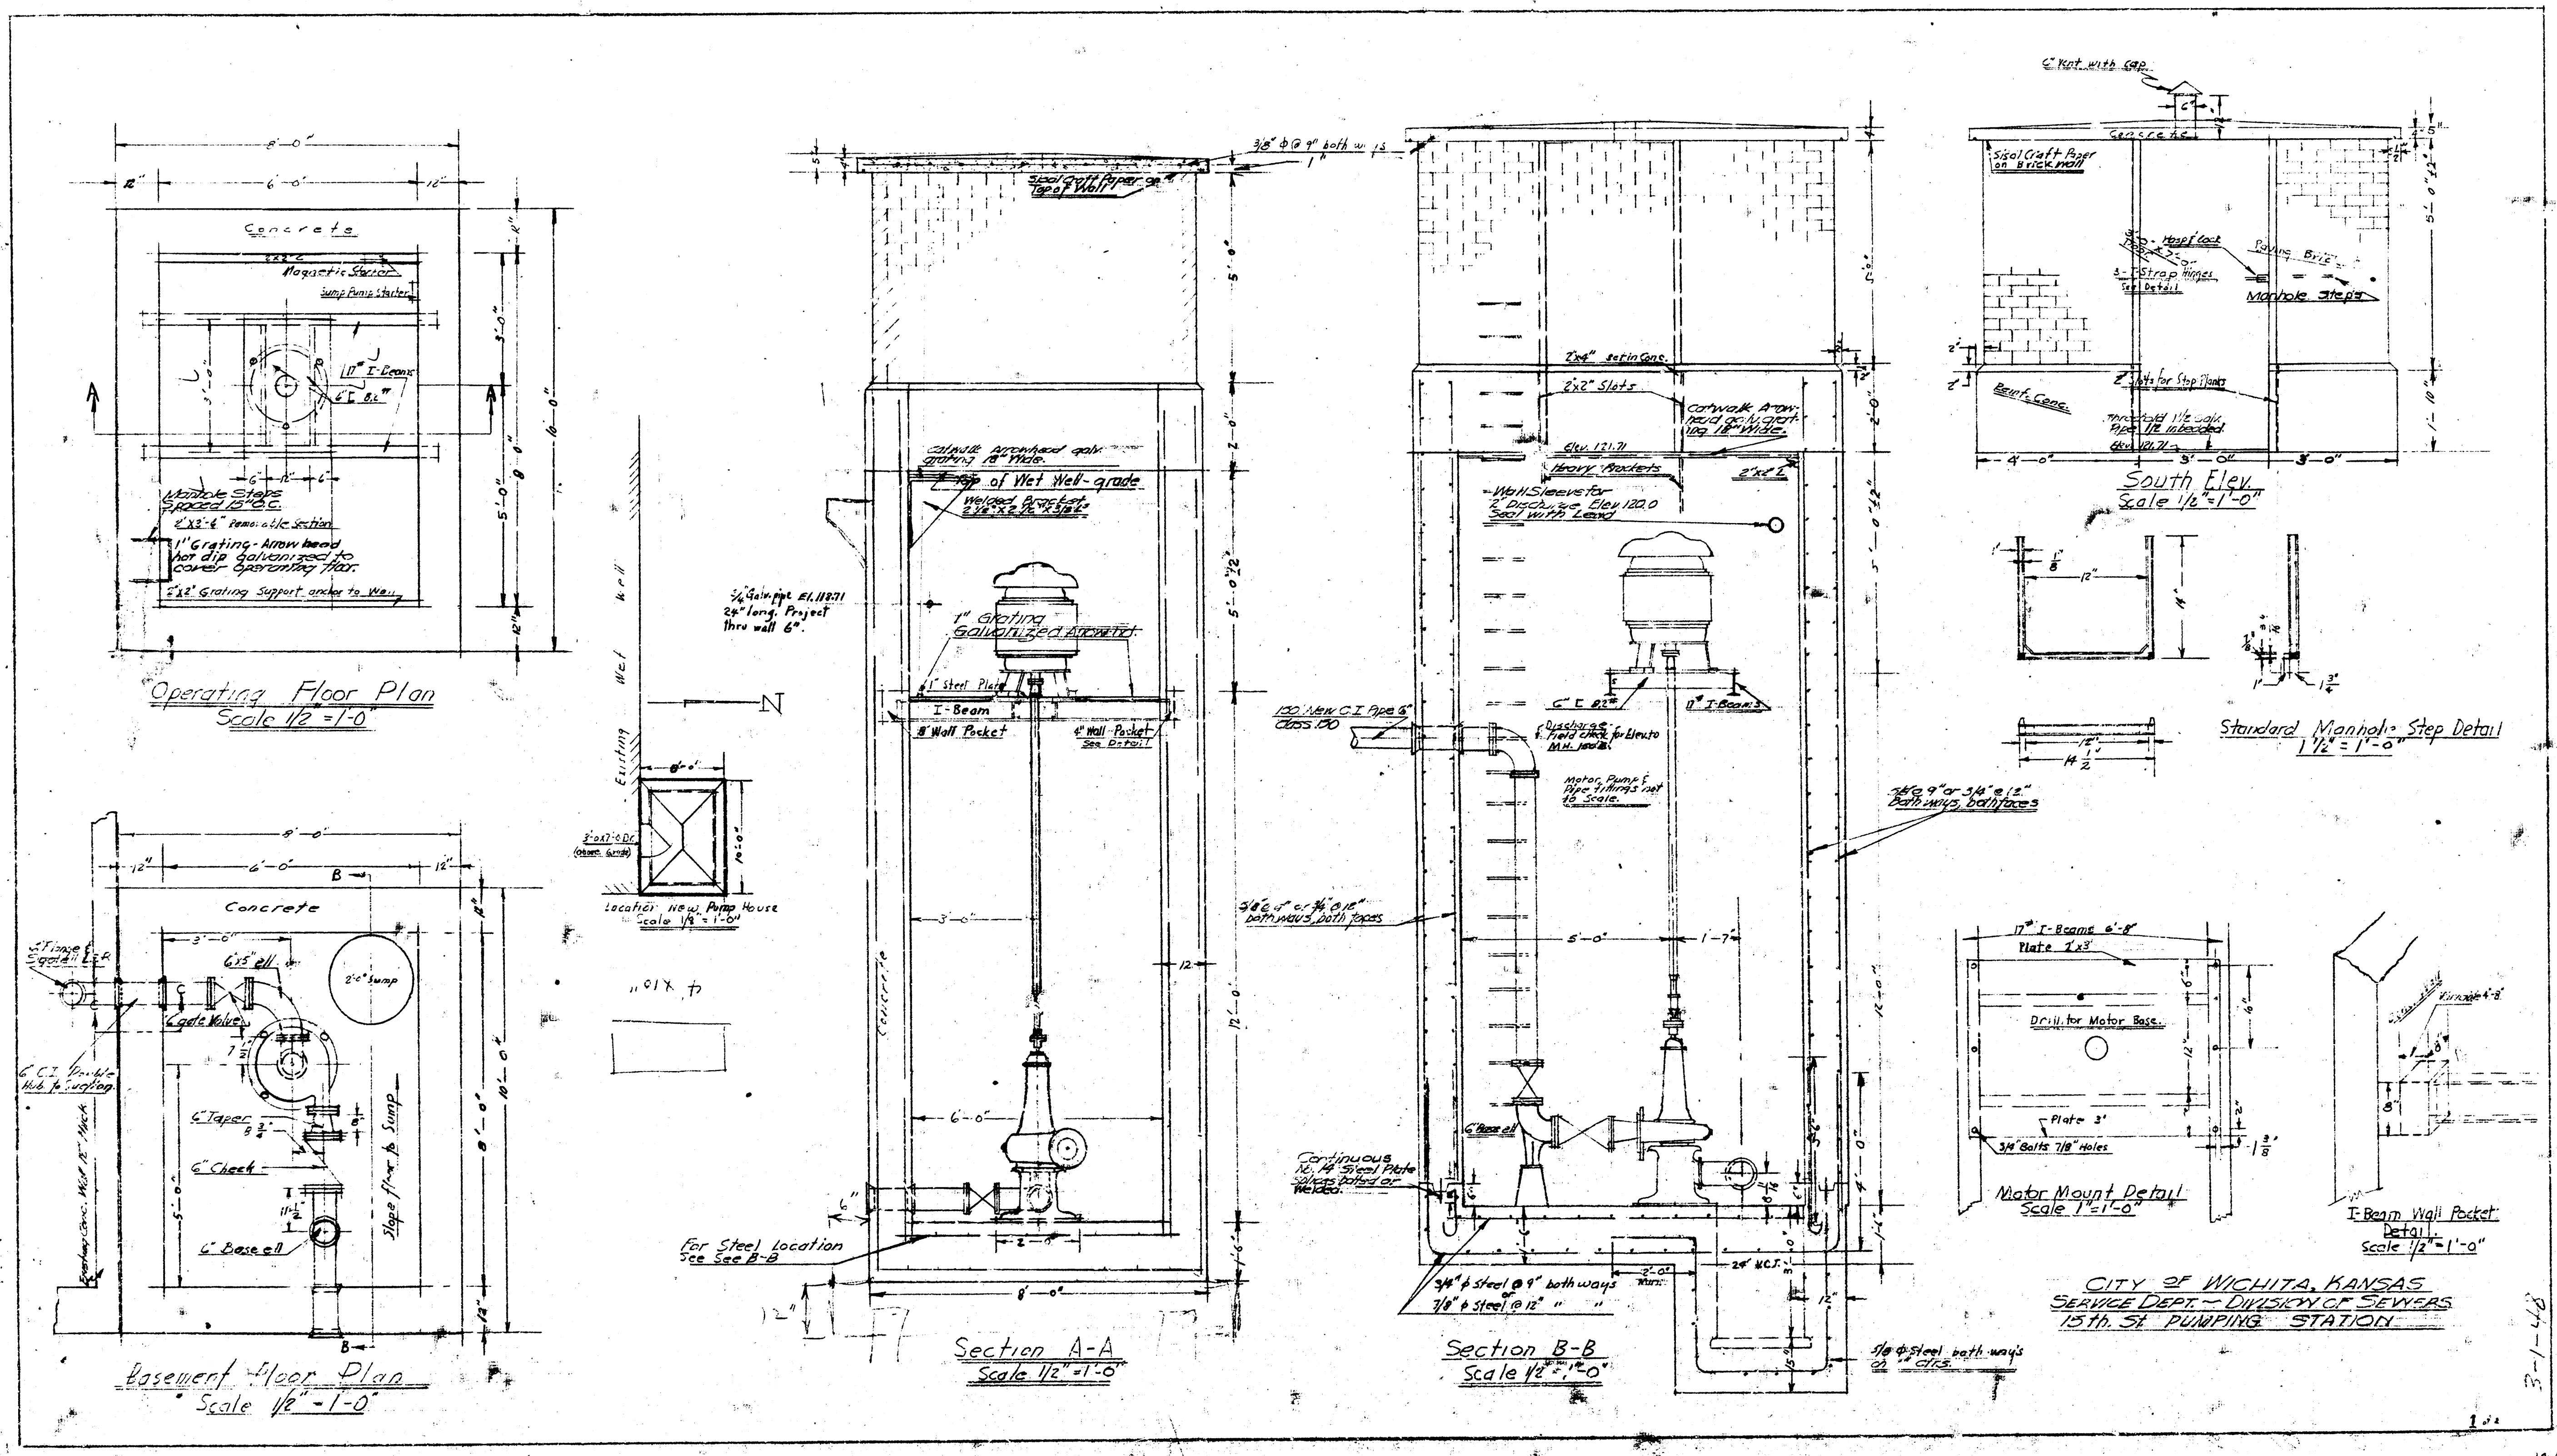

[illegible]

