


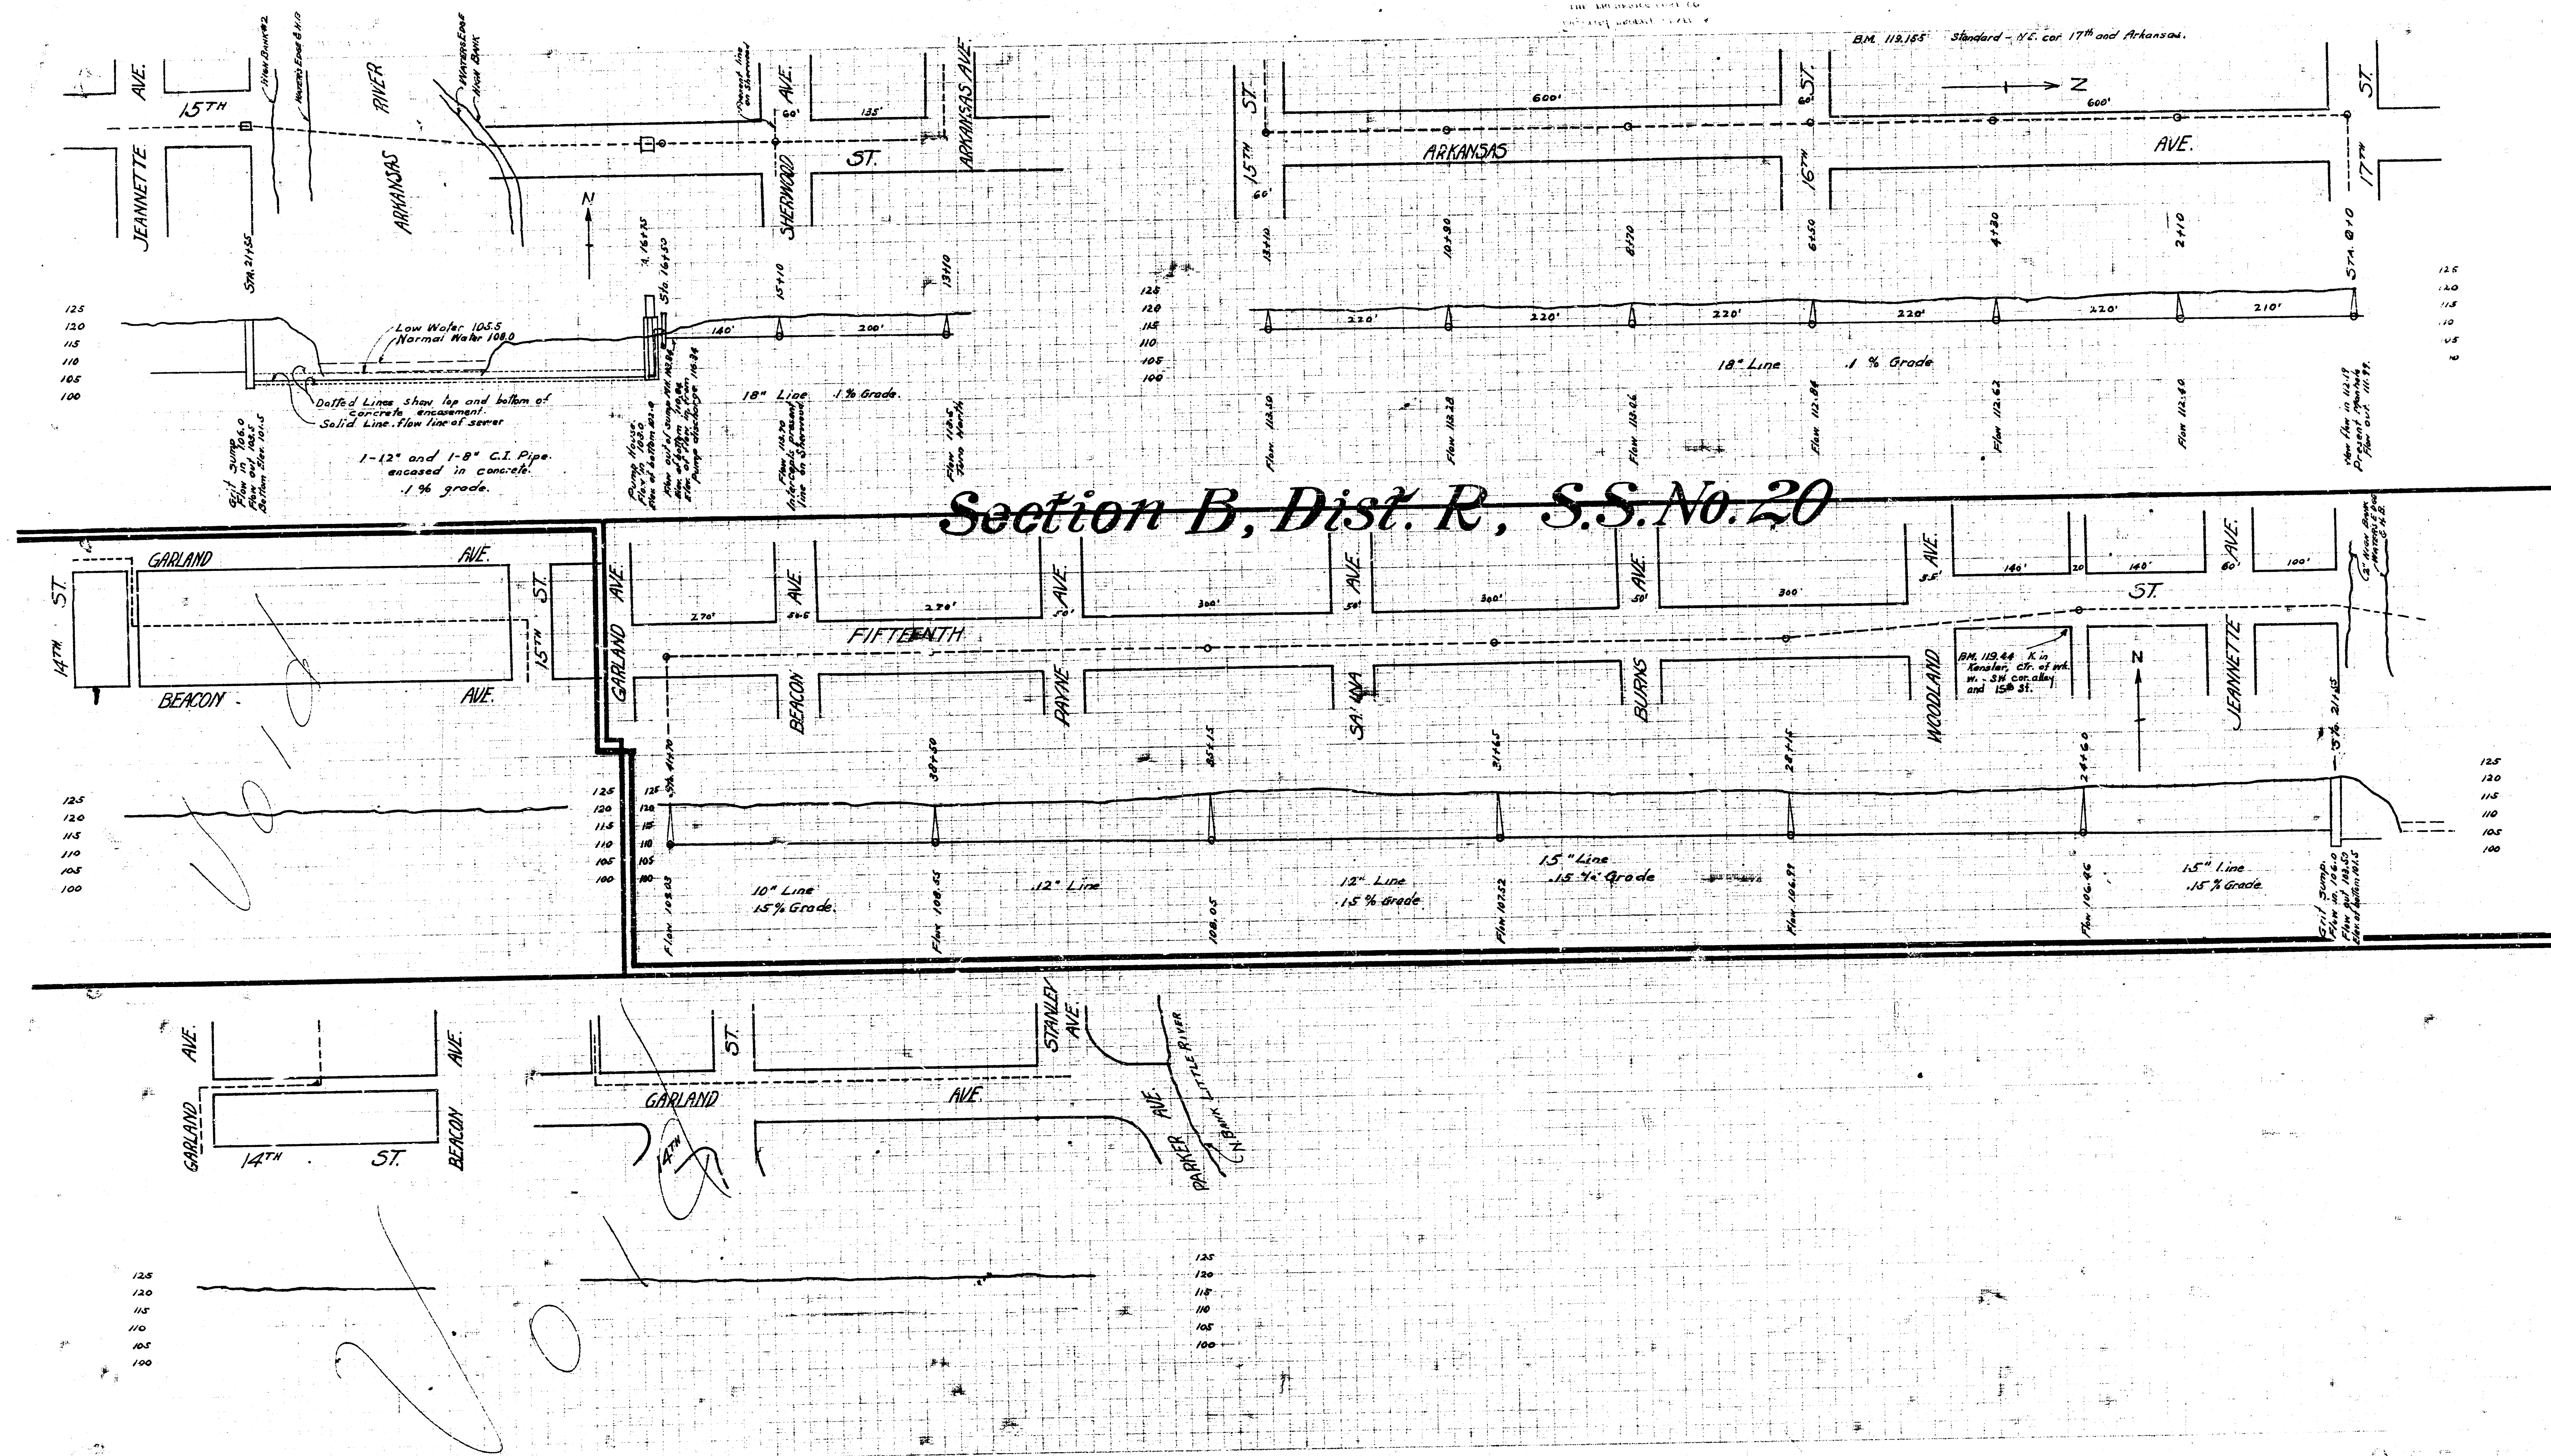


[illegible]


Typical Door Section


Section of Doorway
Scale: 1" = 1'-0"


POWER LAYOUT
SCALE 1/4" = 1'-0"

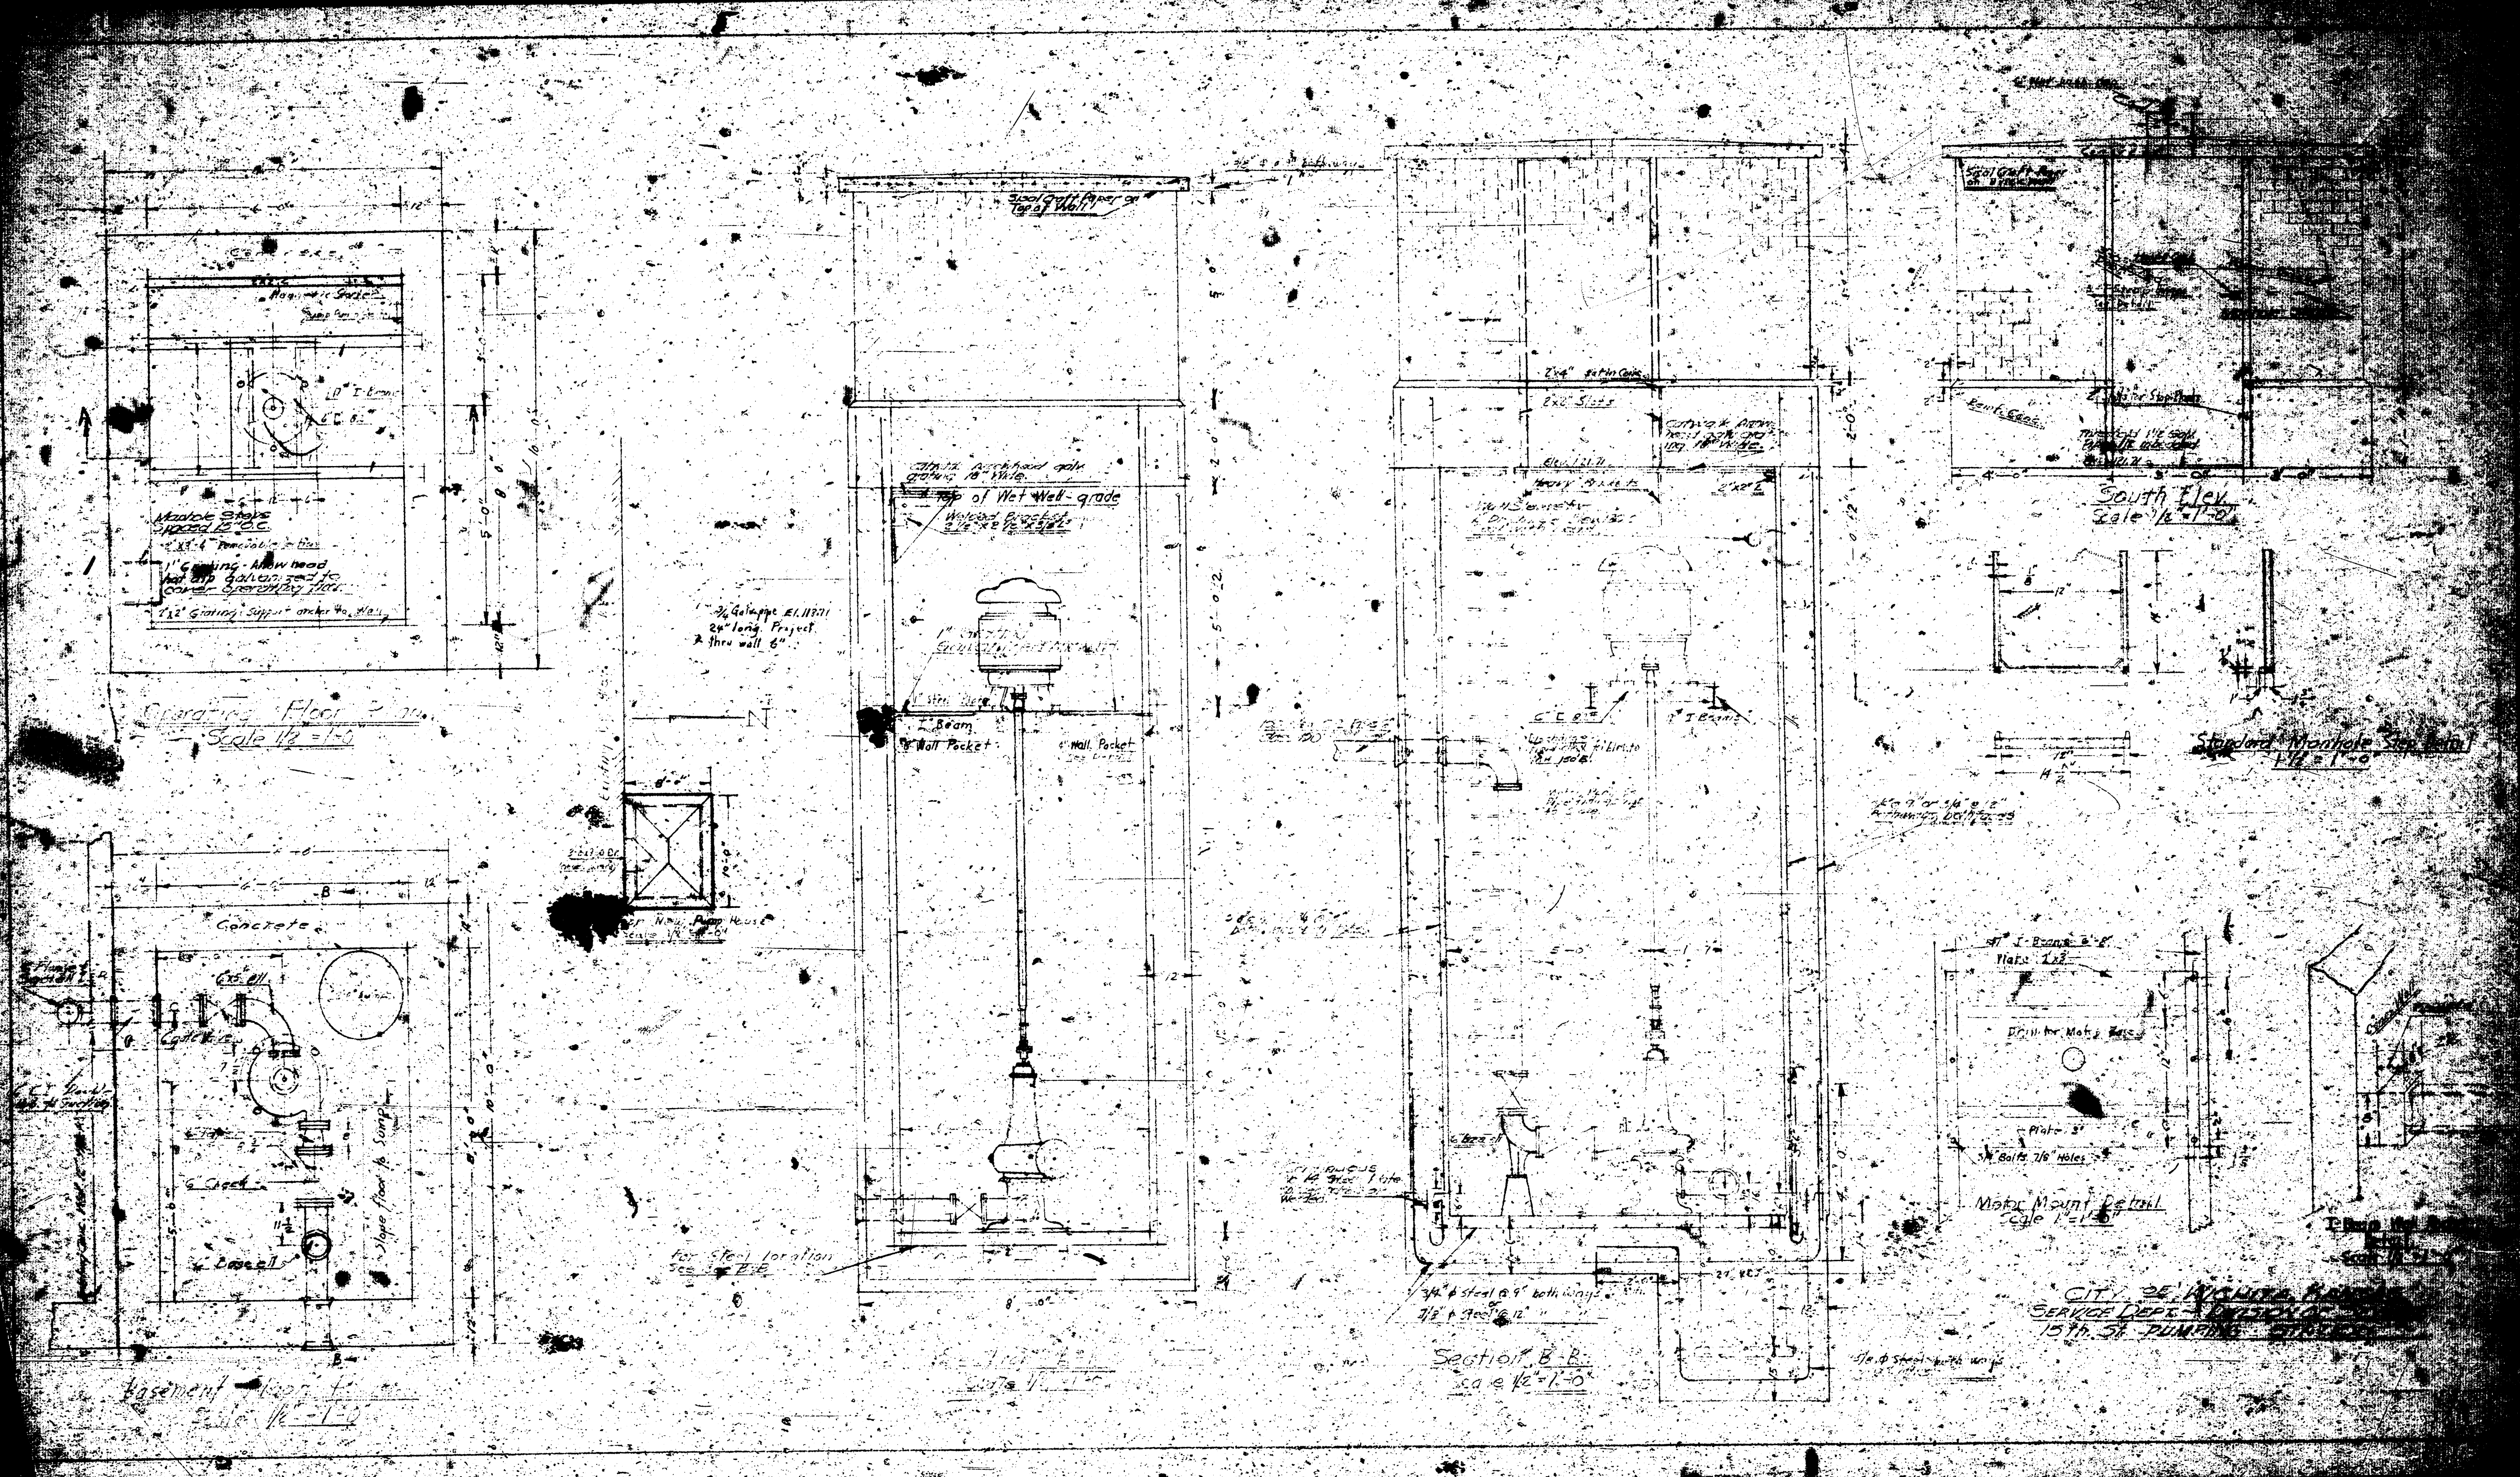

CITY OF WICHITA, KANSAS
SERVICE DEPT. DIVISION OF ENGINEERS
12th ST. PUMPING STATION

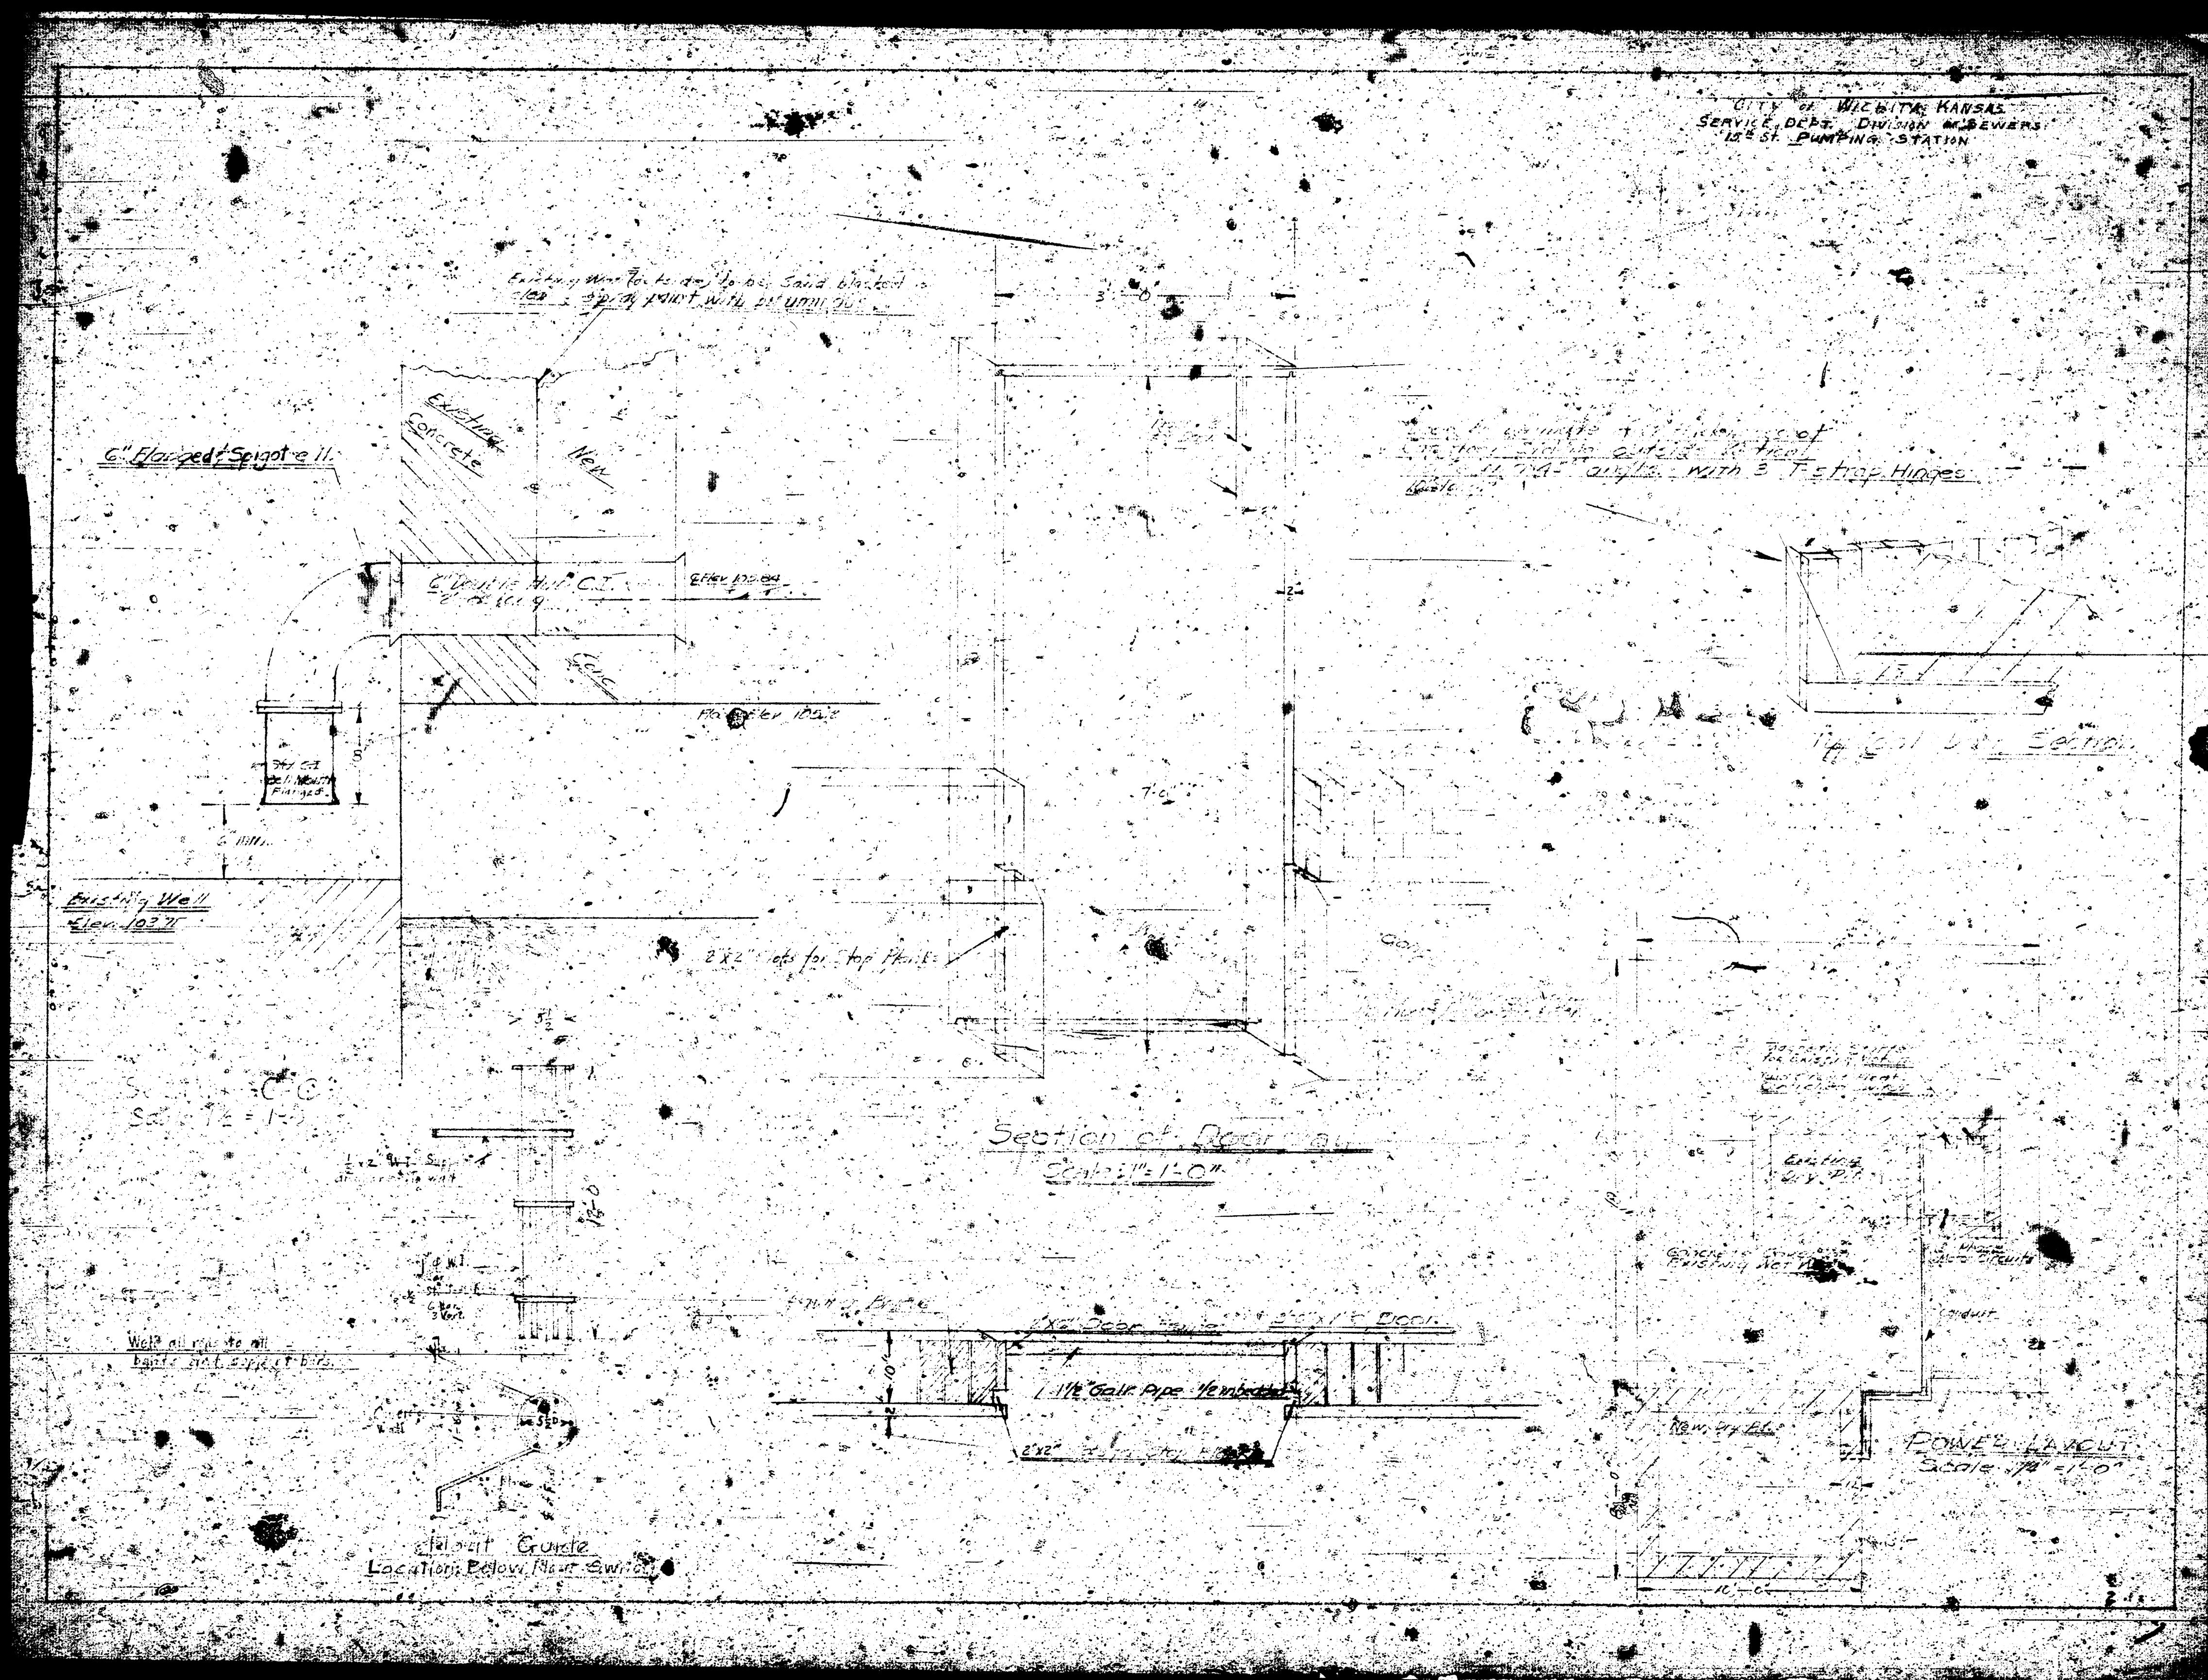

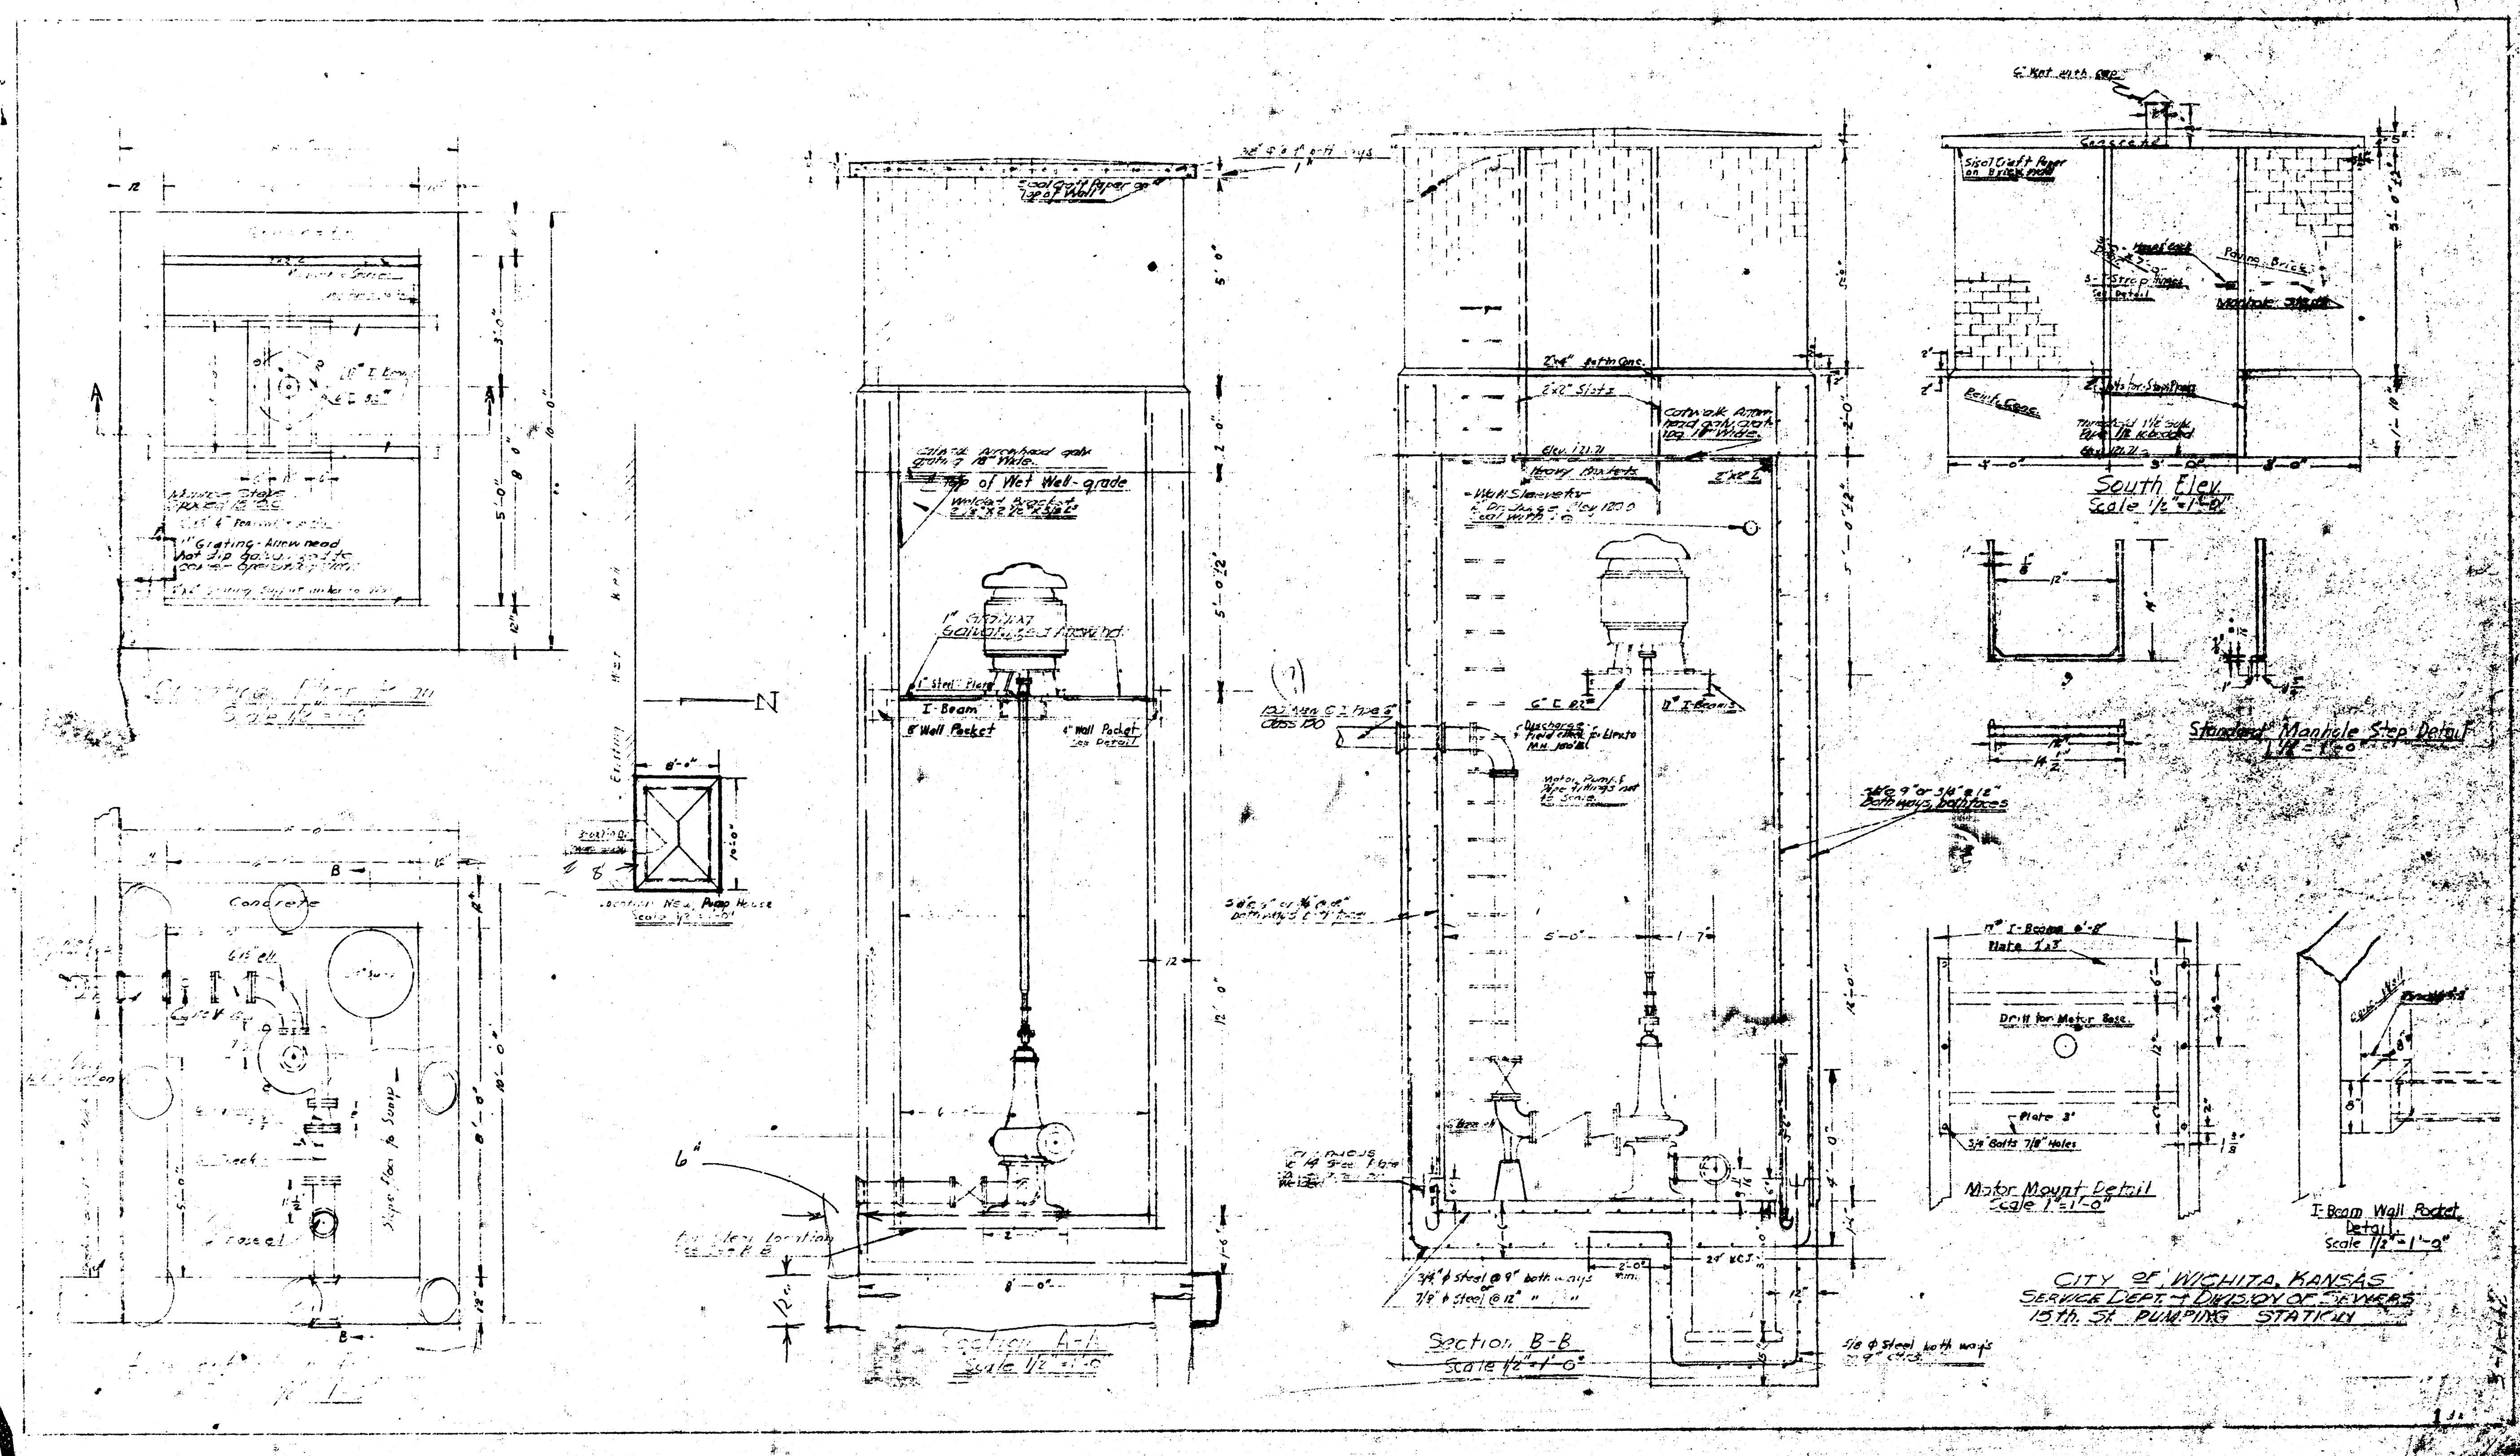

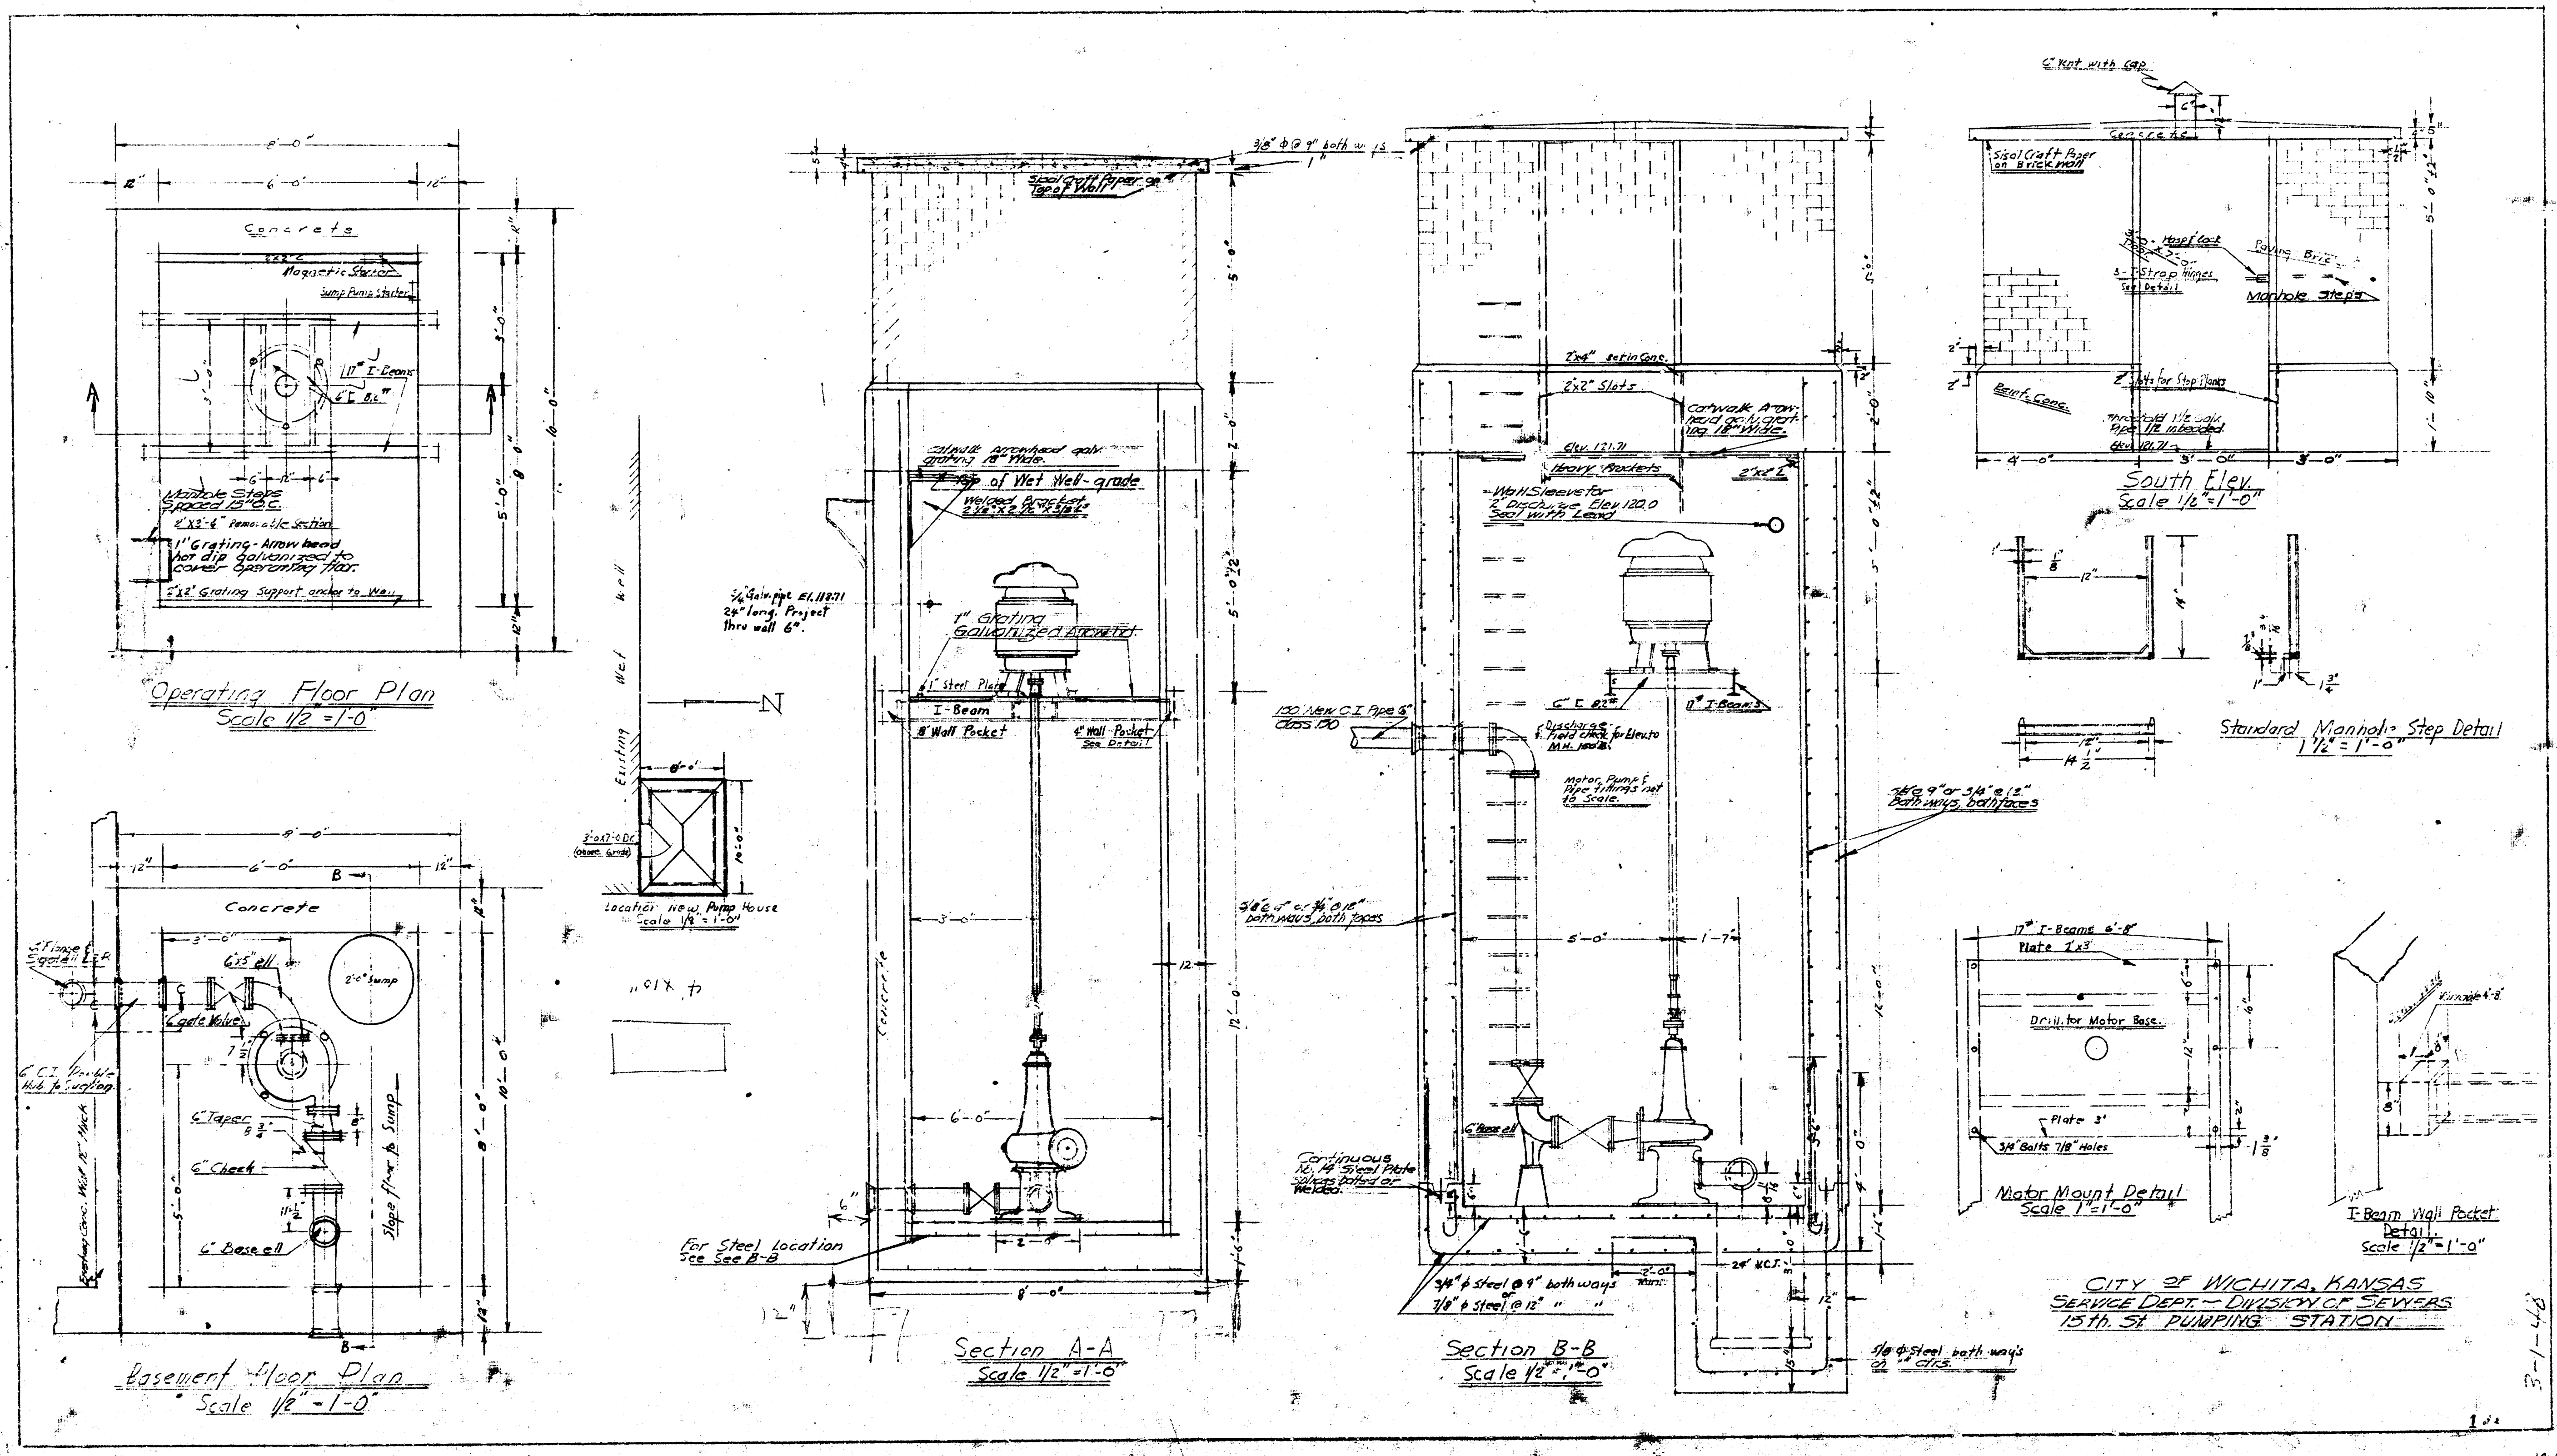

CITY OF WICHITA, KANSAS
SERVICE DEPT. - DIVISION OF SEWERS
15TH ST. PUMPING STATION

3-1-46

CITY OF WICHITA, KANSAS
SERVICE DEPT. DIVISION OF SEWERS
18th ST. PUMPING STATION

