


J.T.A. 10/23/59  
 J.T.A. 10/23/59  
 J.T.A. 10/23/59

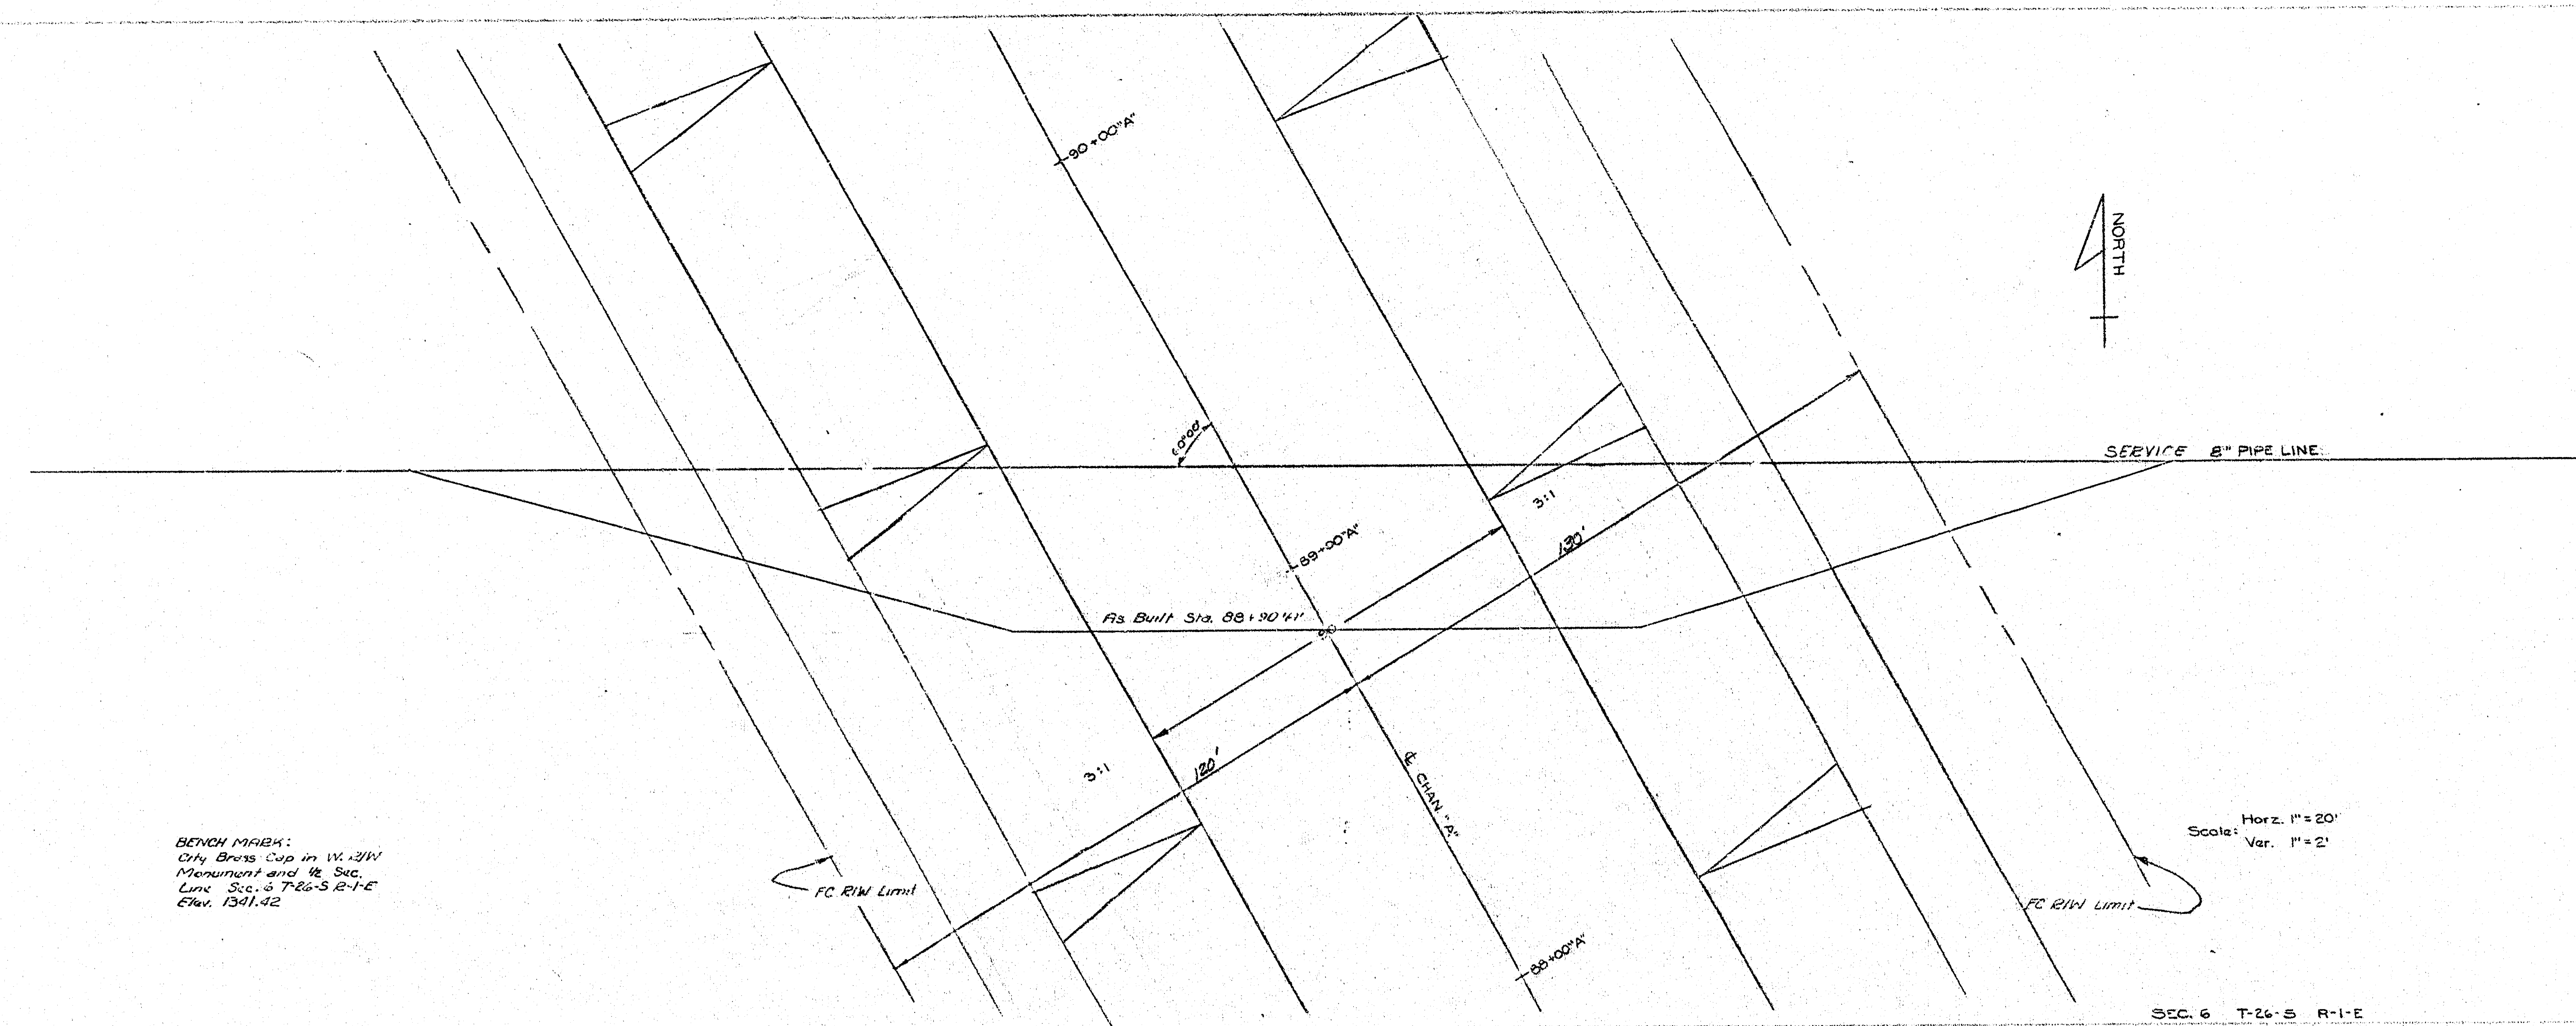


BEYOND MARK:  
 Only Brass Cup in W. 31st  
 Monument and 8. Sec.  
 Line Sec. 5 T26-S 2-1-E  
 Elev. 1341.42

Scale: Horiz. 1"=20'  
 Var. 1"=2'

SEC. 5 T-26-S R-1-E

J.T.A. 10/23/59  
 J.T.A. 10/23/59  
 J.T.A. 10/23/59

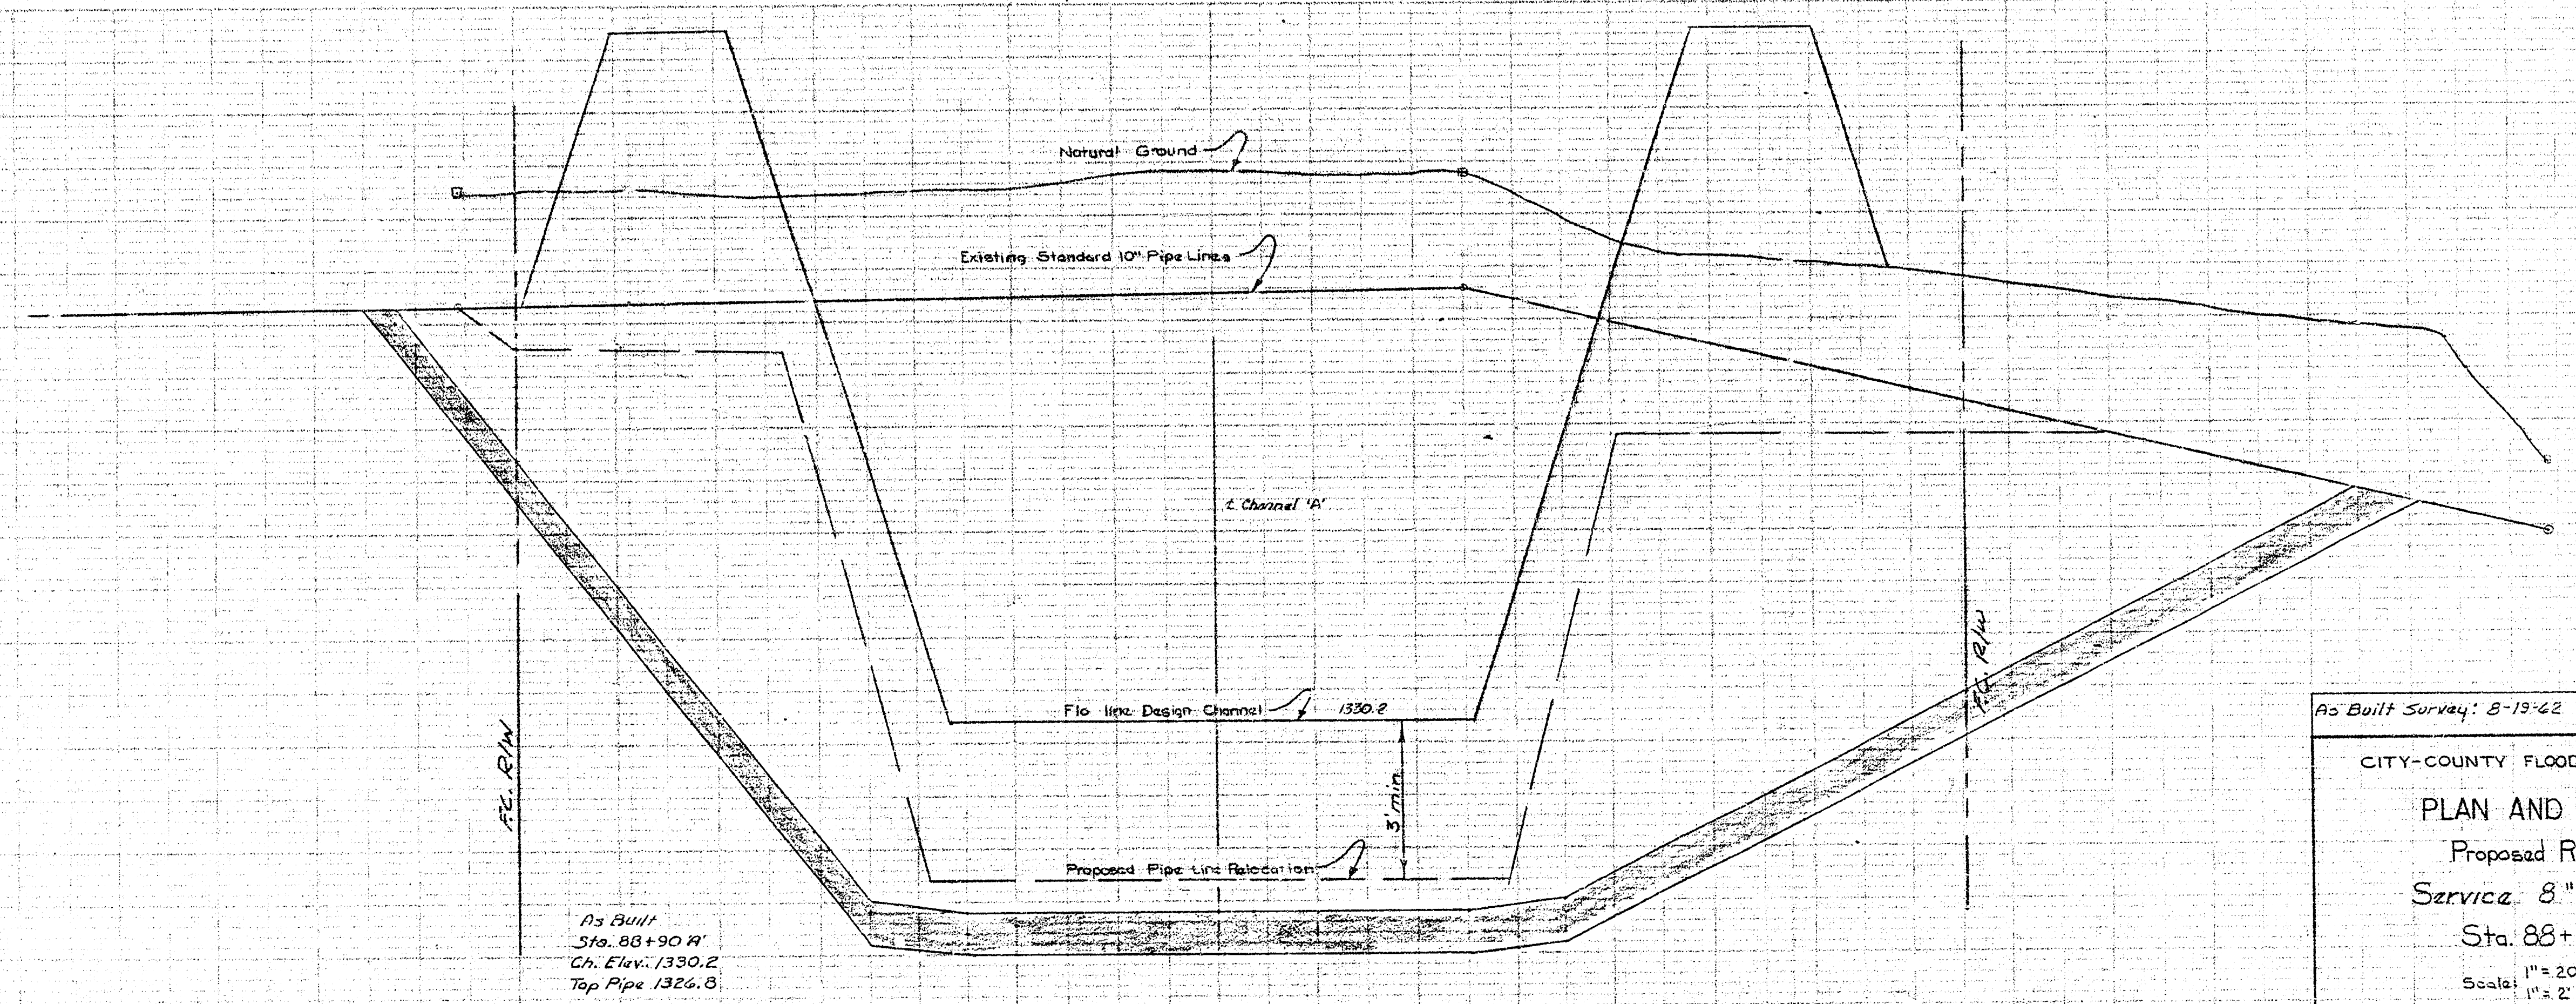

As Built  
 Sta. 88+90.0  
 Ch. Elev. 1330.2  
 Top Pipe 1326.8

As Built Survey: 8-19-62

CITY-COUNTY FLOOD CONTROL OFFICE

PLAN AND PROFILE

Proposed Relocation

Service 8" Pipe Line

Sta. 88+90 "A"

Scale: 1"=20' Horizontal  
1"=2' Vertical

Drawn by: Puente Arce  
Checked by: [Signature]

Date: 10-23-59  
Revised: 9-23-62