





PLAN
 DATE: 8/27/78
 BY: [Signature]
 CHECKED: [Signature]
 NO. OF WAYS CHECKED: 1
 AUGUST 1986

PROFILE
 DATE: 8/27/78
 BY: [Signature]
 CHECKED: [Signature]
 NO. OF WAYS CHECKED: 1
 AUGUST 1986

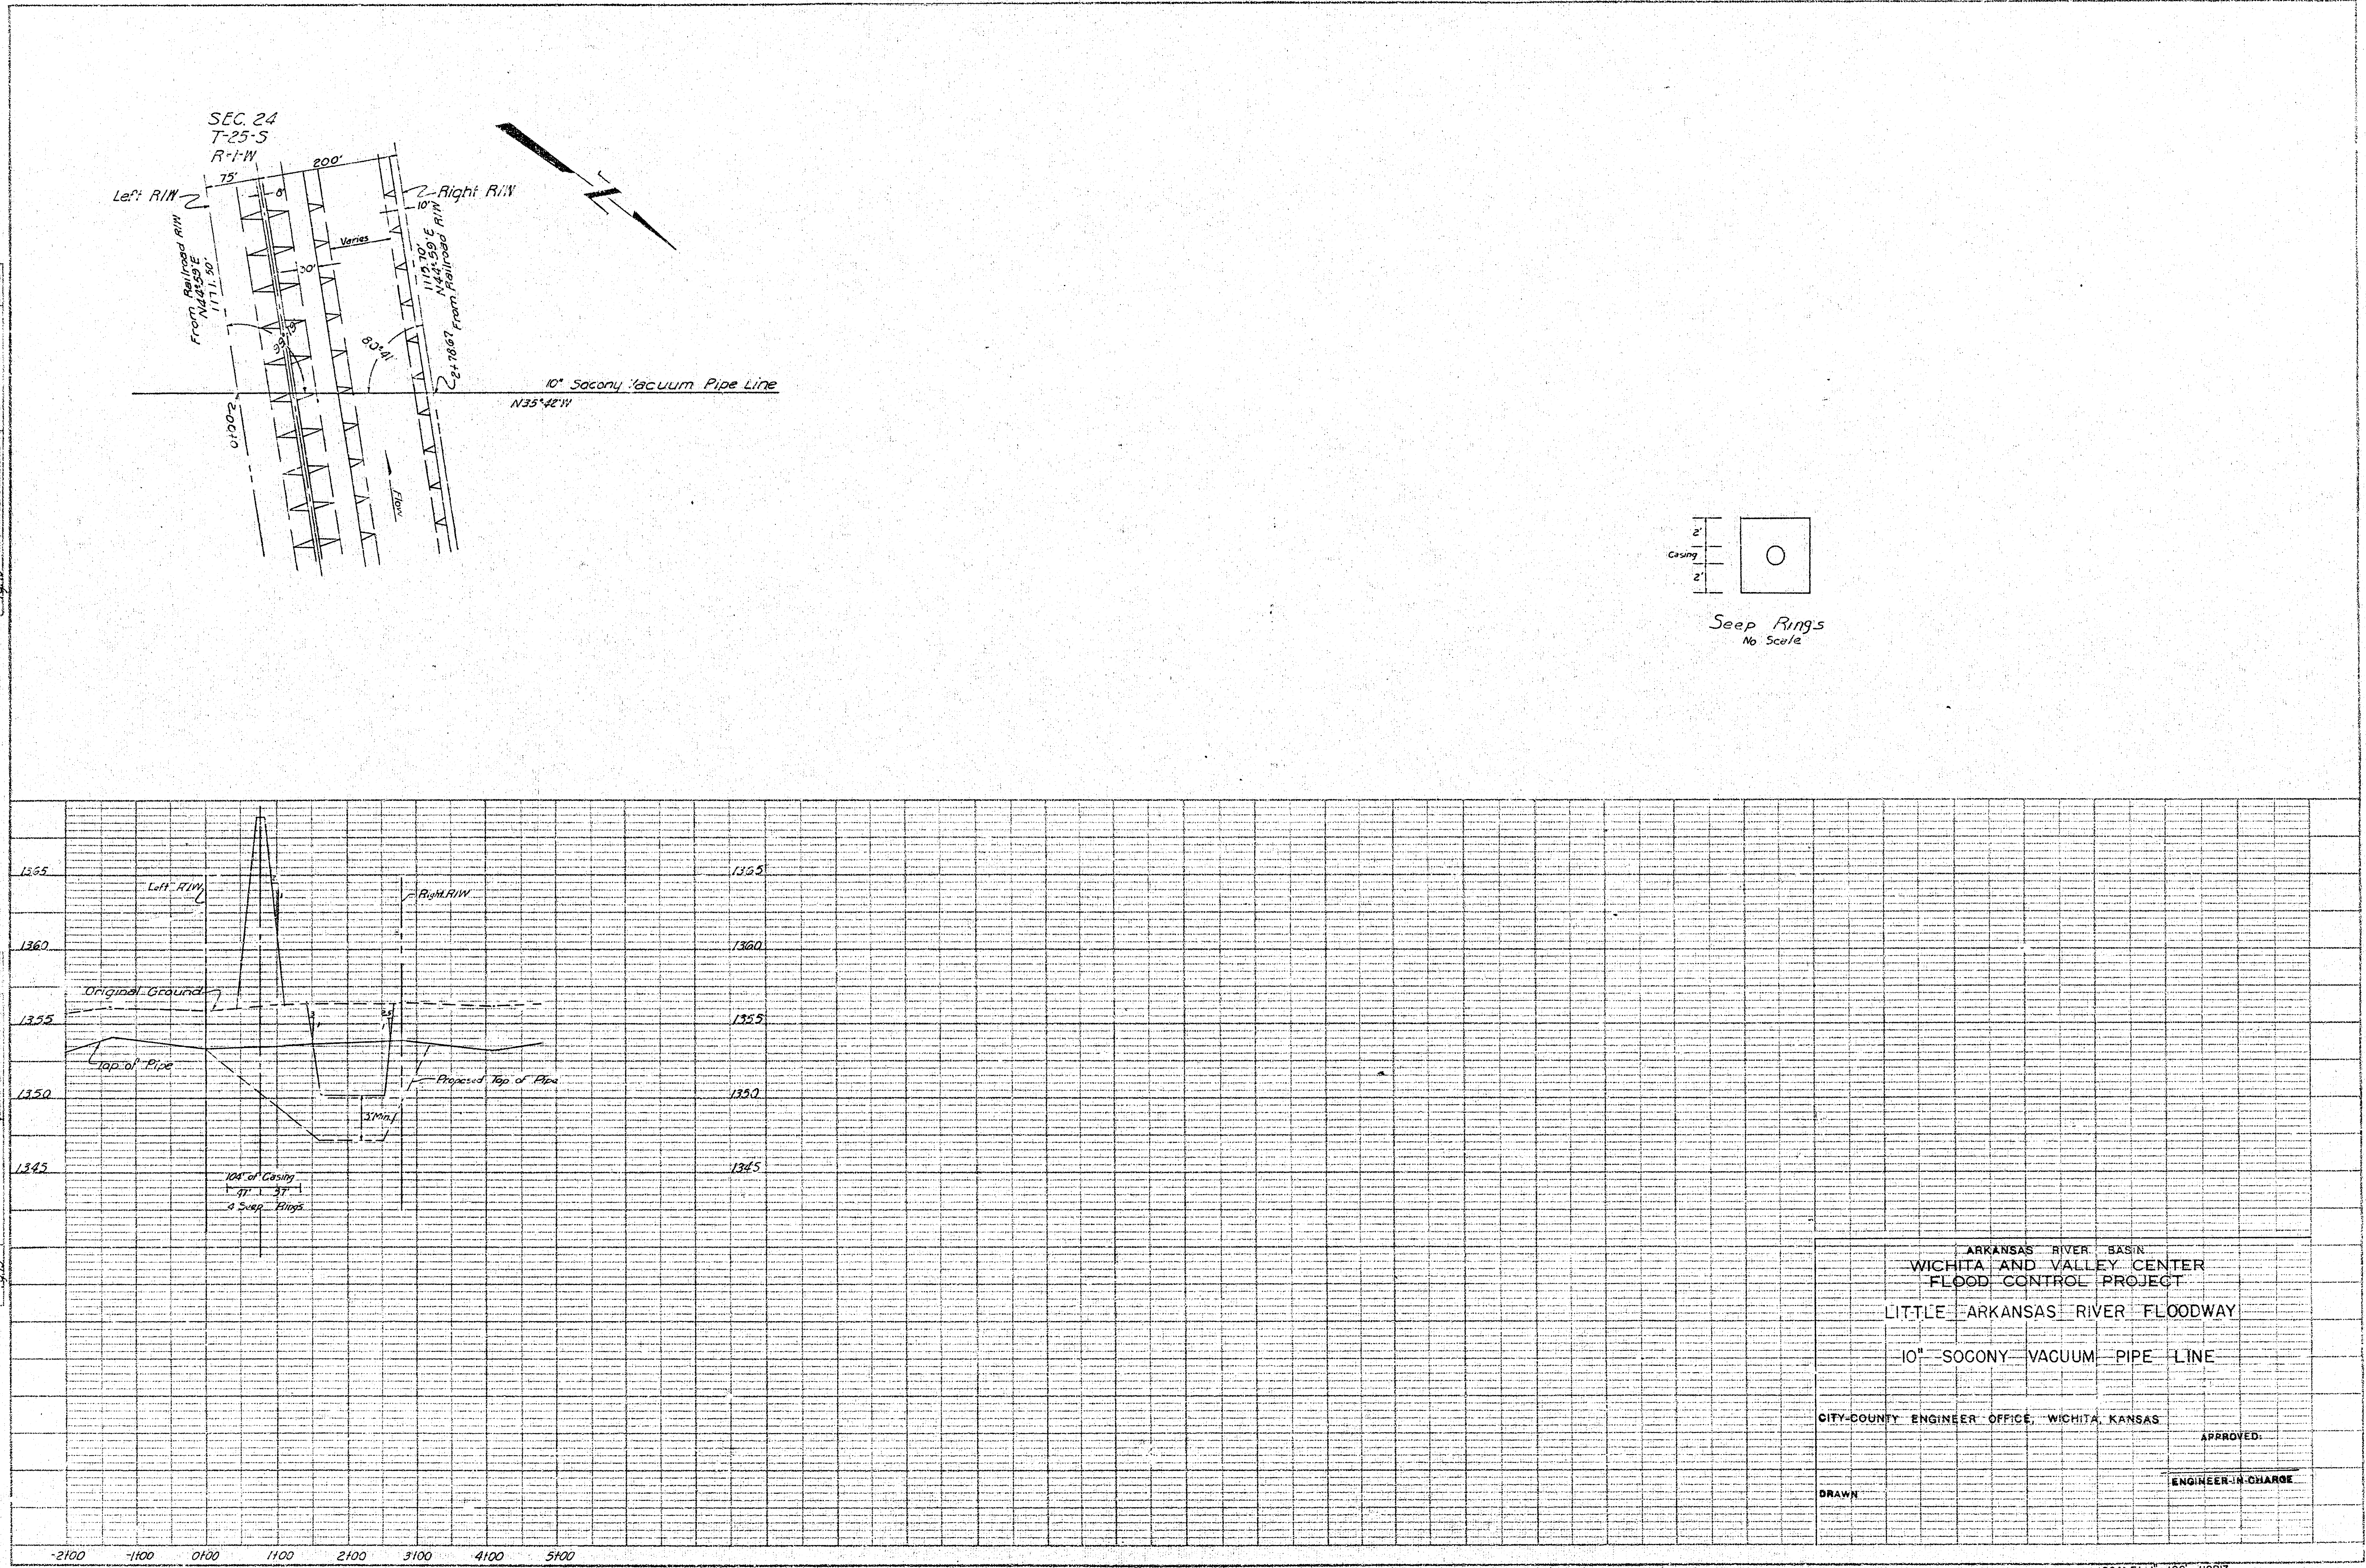

Bench Mark:
City of Wichita Brass Cap
in NE corner of bridge at
lateral A and 93rd street
Elev. 1356.34

NOTE:
Pipe line crosses 93rd street
1573.0 east of Section corner
2+19
25/30 1:25-S R-L-L & R-L-W

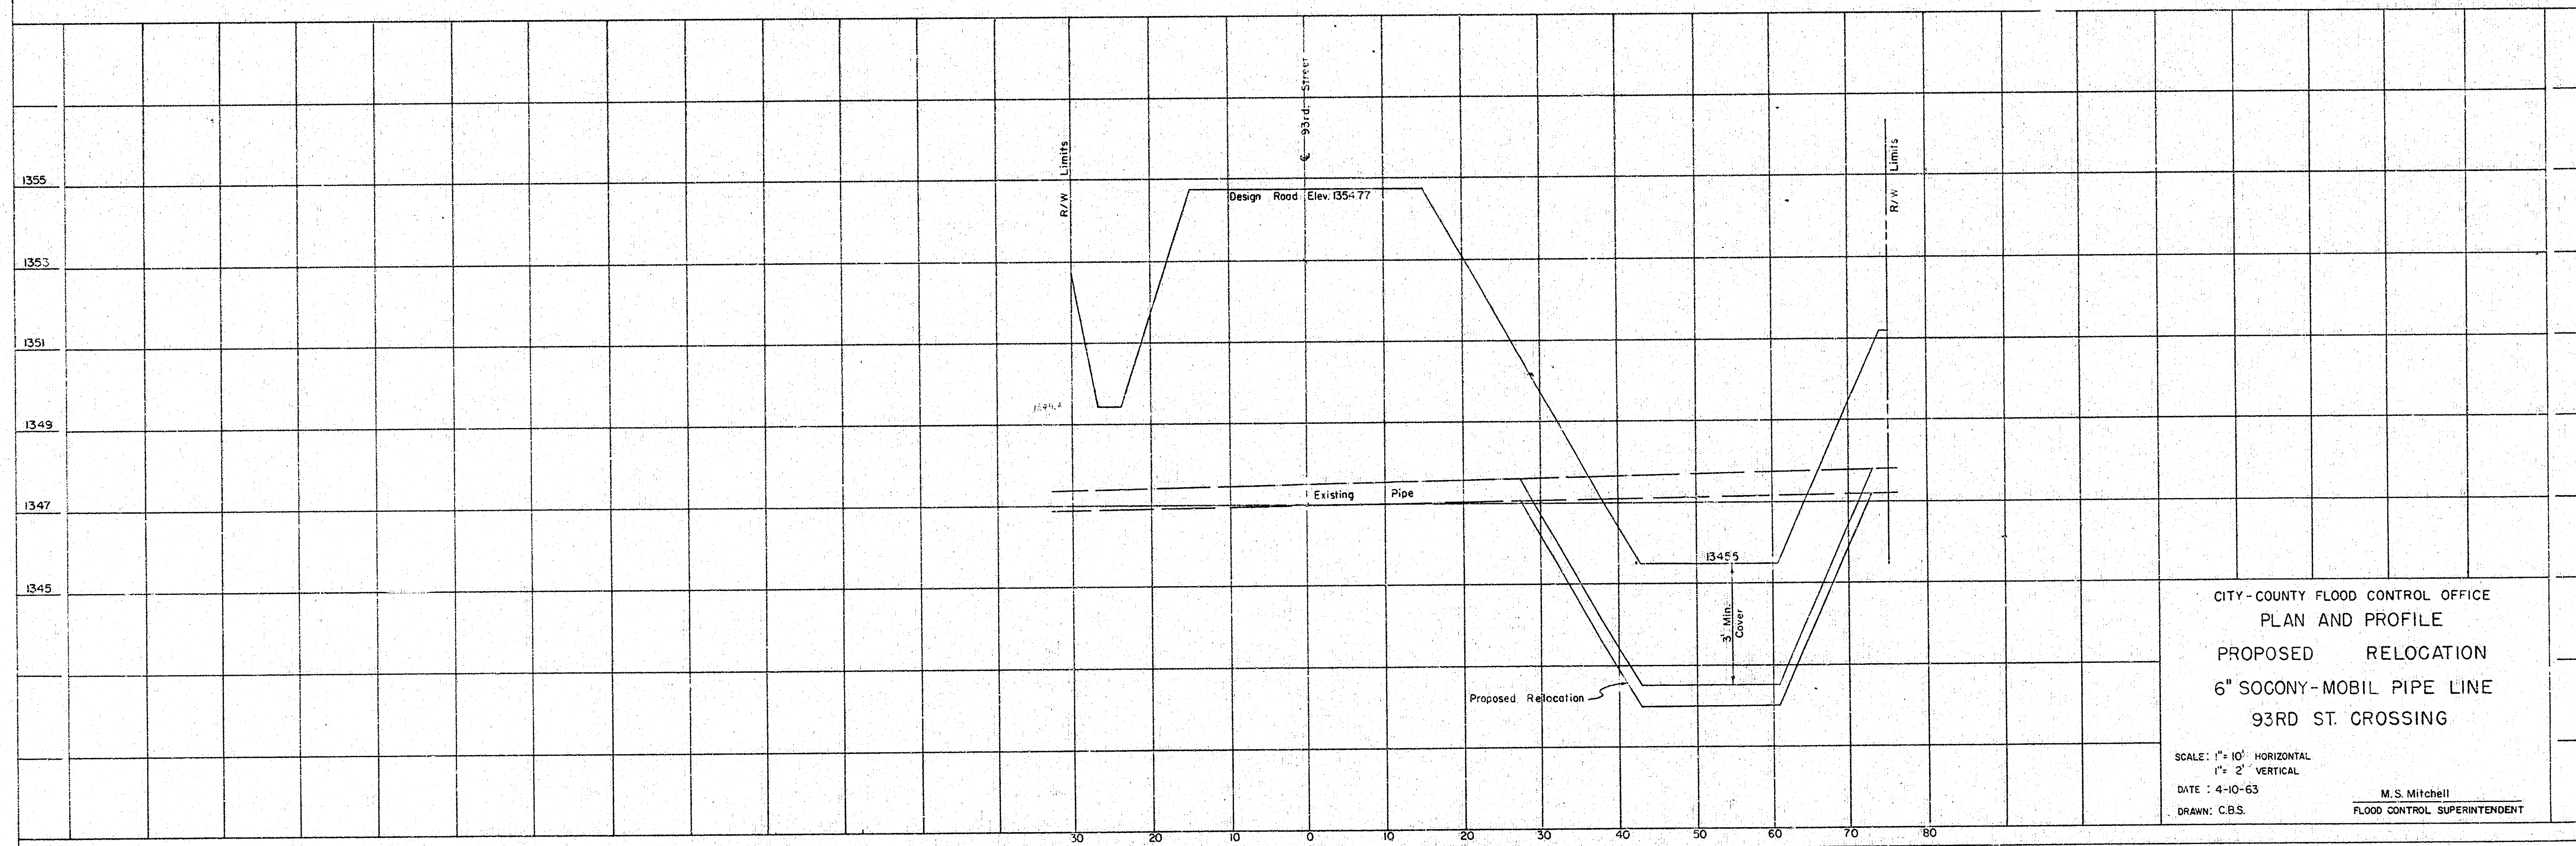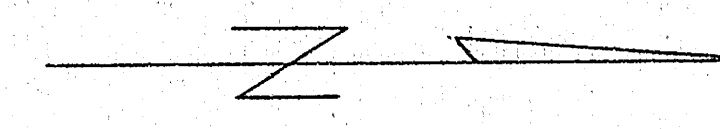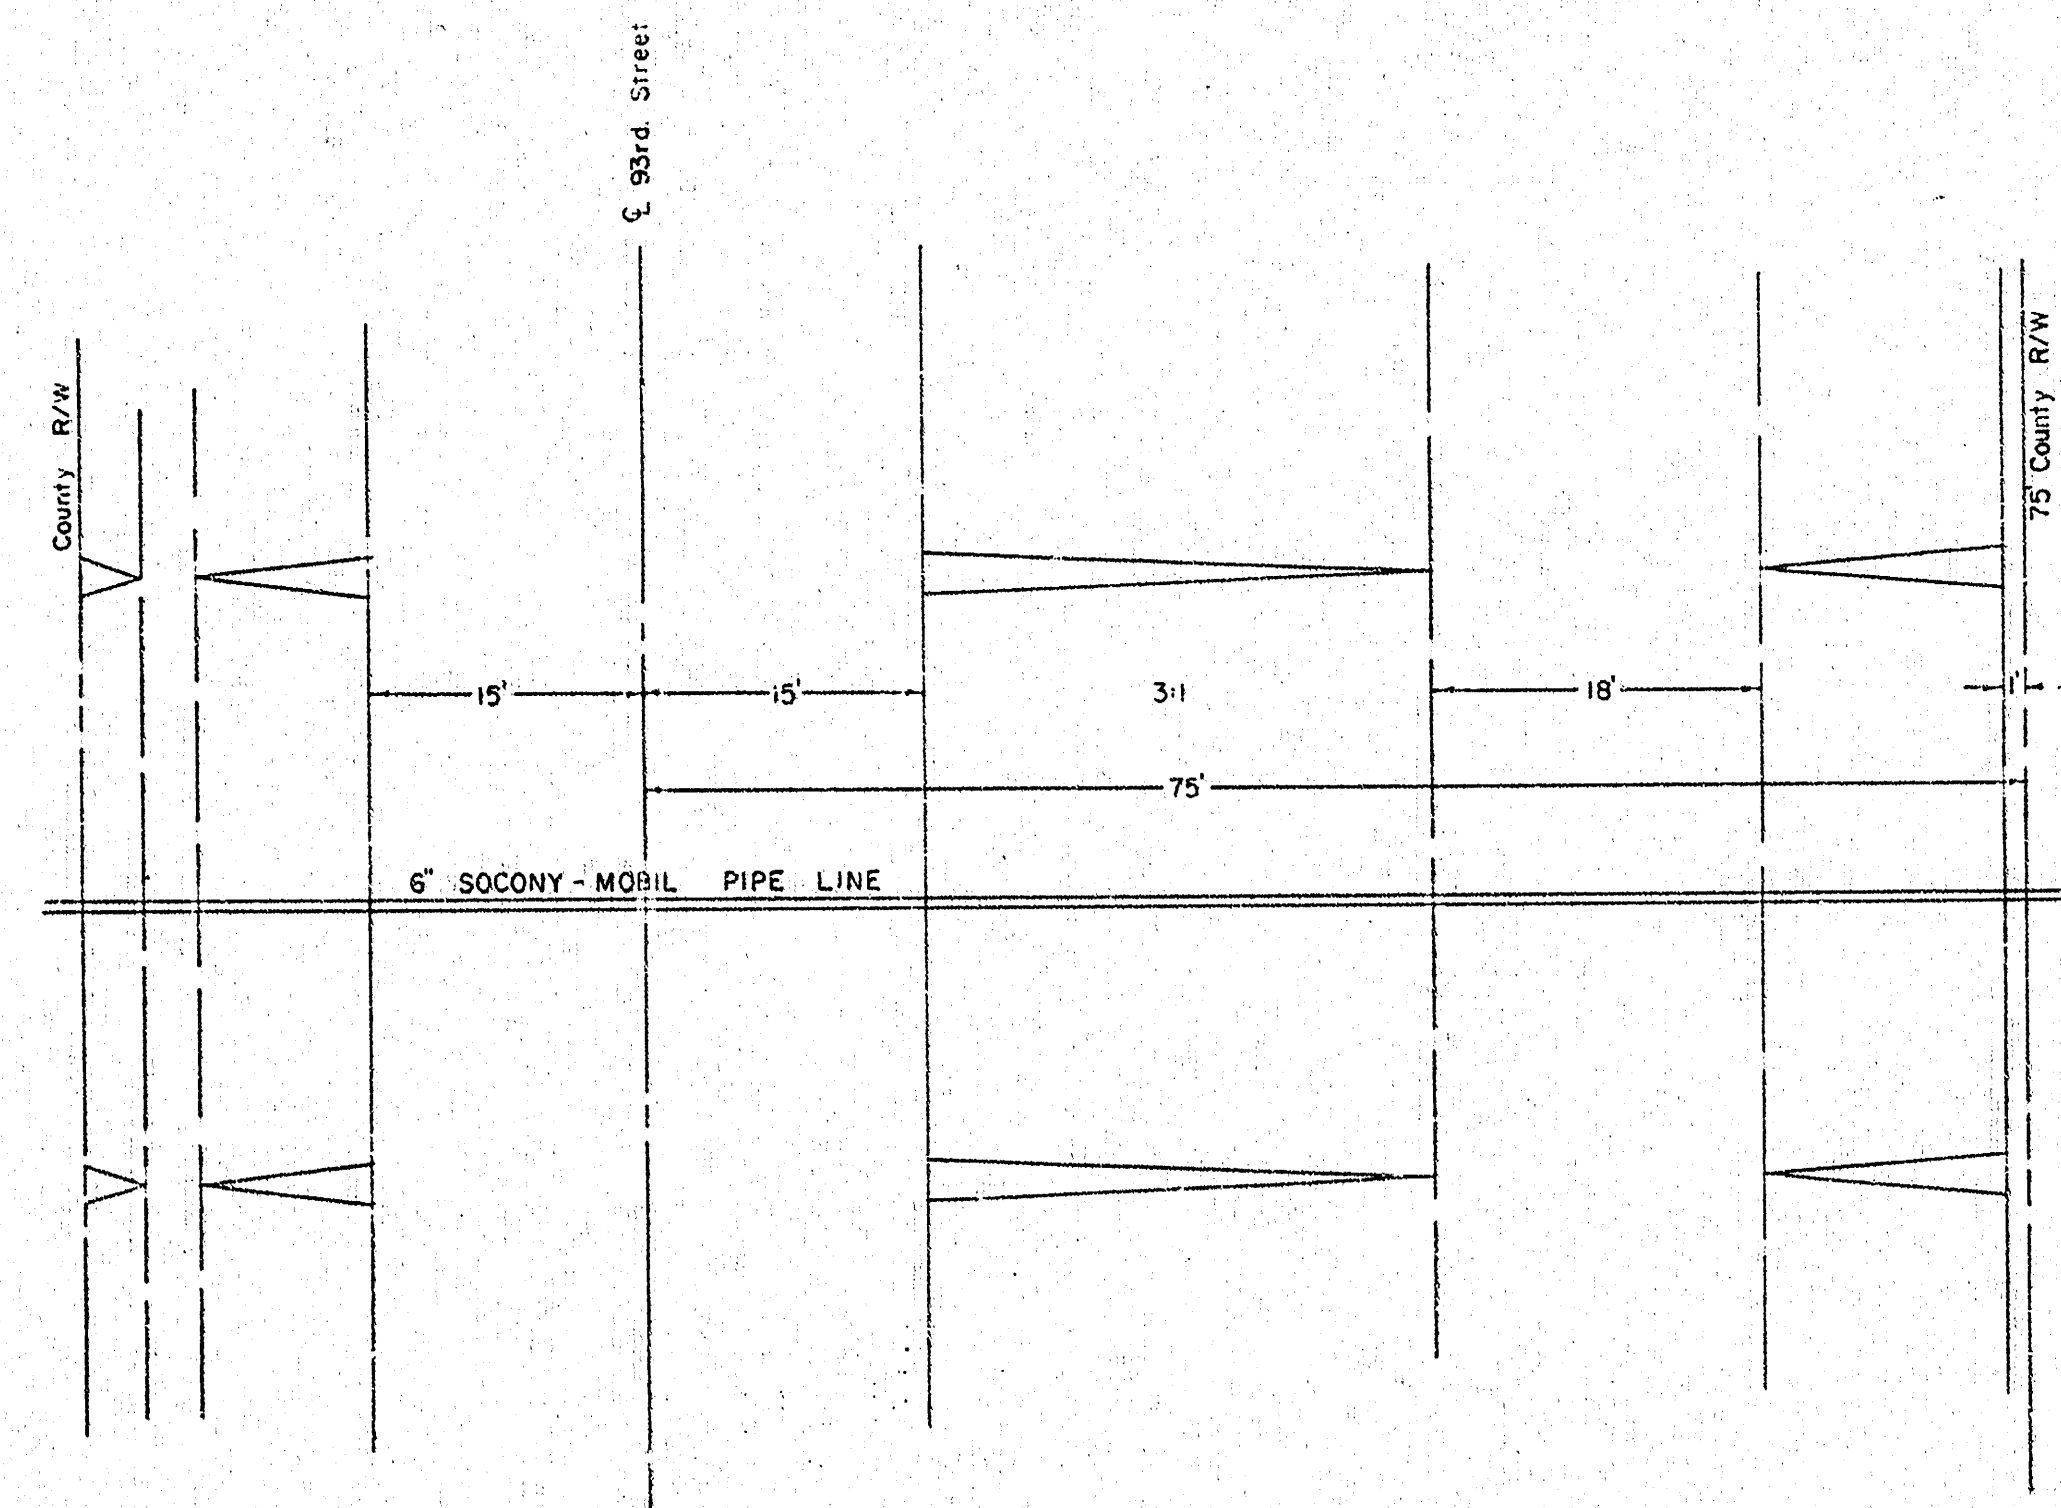




CITY-COUNTY FLOOD CONTROL OFFICE
PLAN AND PROFILE
PROPOSED RELOCATION
6" SOCONY-MOBIL PIPE LINE
93RD ST. CROSSING

SCALE: 1" = 10' HORIZONTAL
1" = 2' VERTICAL
DATE: 4-10-63
DRAWN: C.B.S.

M.S. Mitchell
FLOOD CONTROL SUPERINTENDENT




Bench Mark:
City of Wichita Brass Cap
in NE corner of bridge at
to 93rd St and 93rd Street
Elev. 1356.34

 NOTE:
Pipe line crosses 93rd Street
1580.0' east of Section corner
2419 T-25-S R-1-E & R-1-W
25130

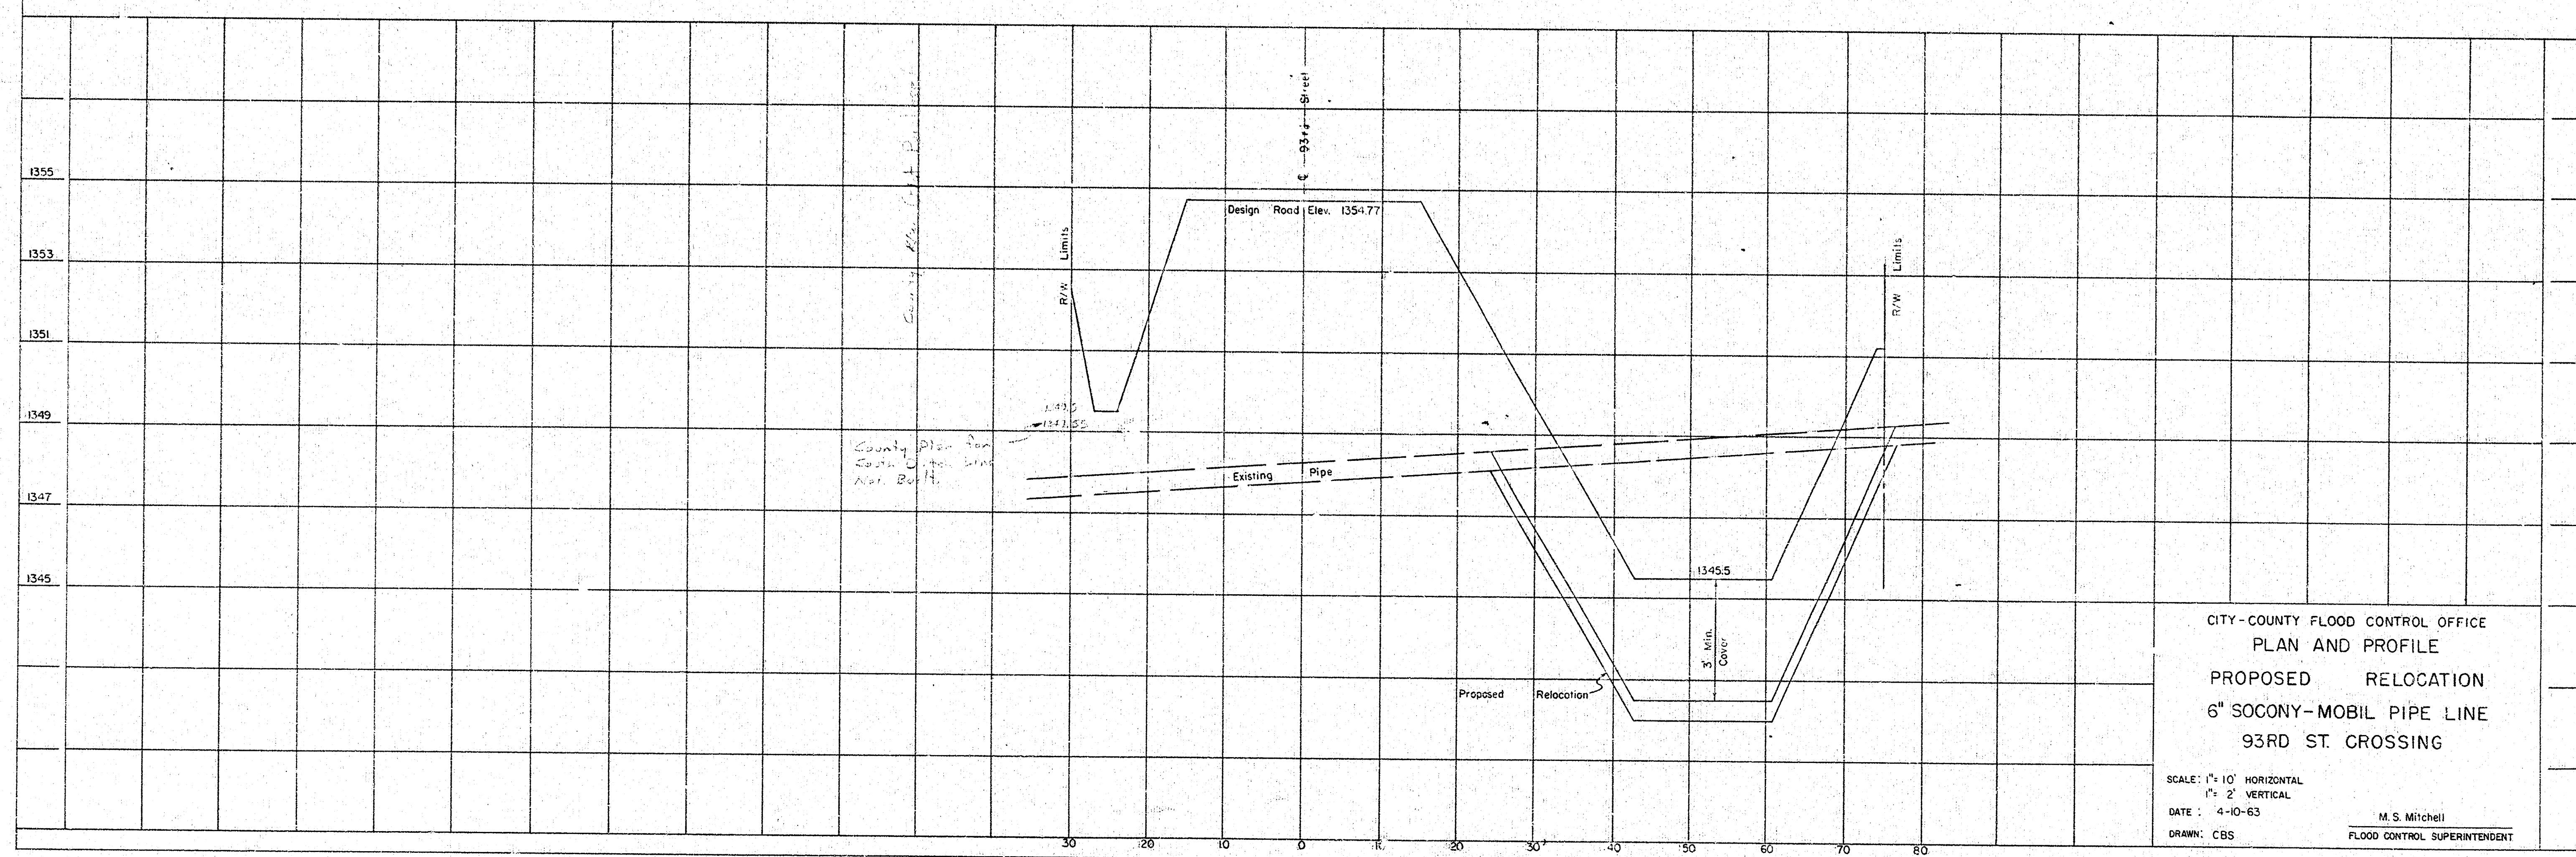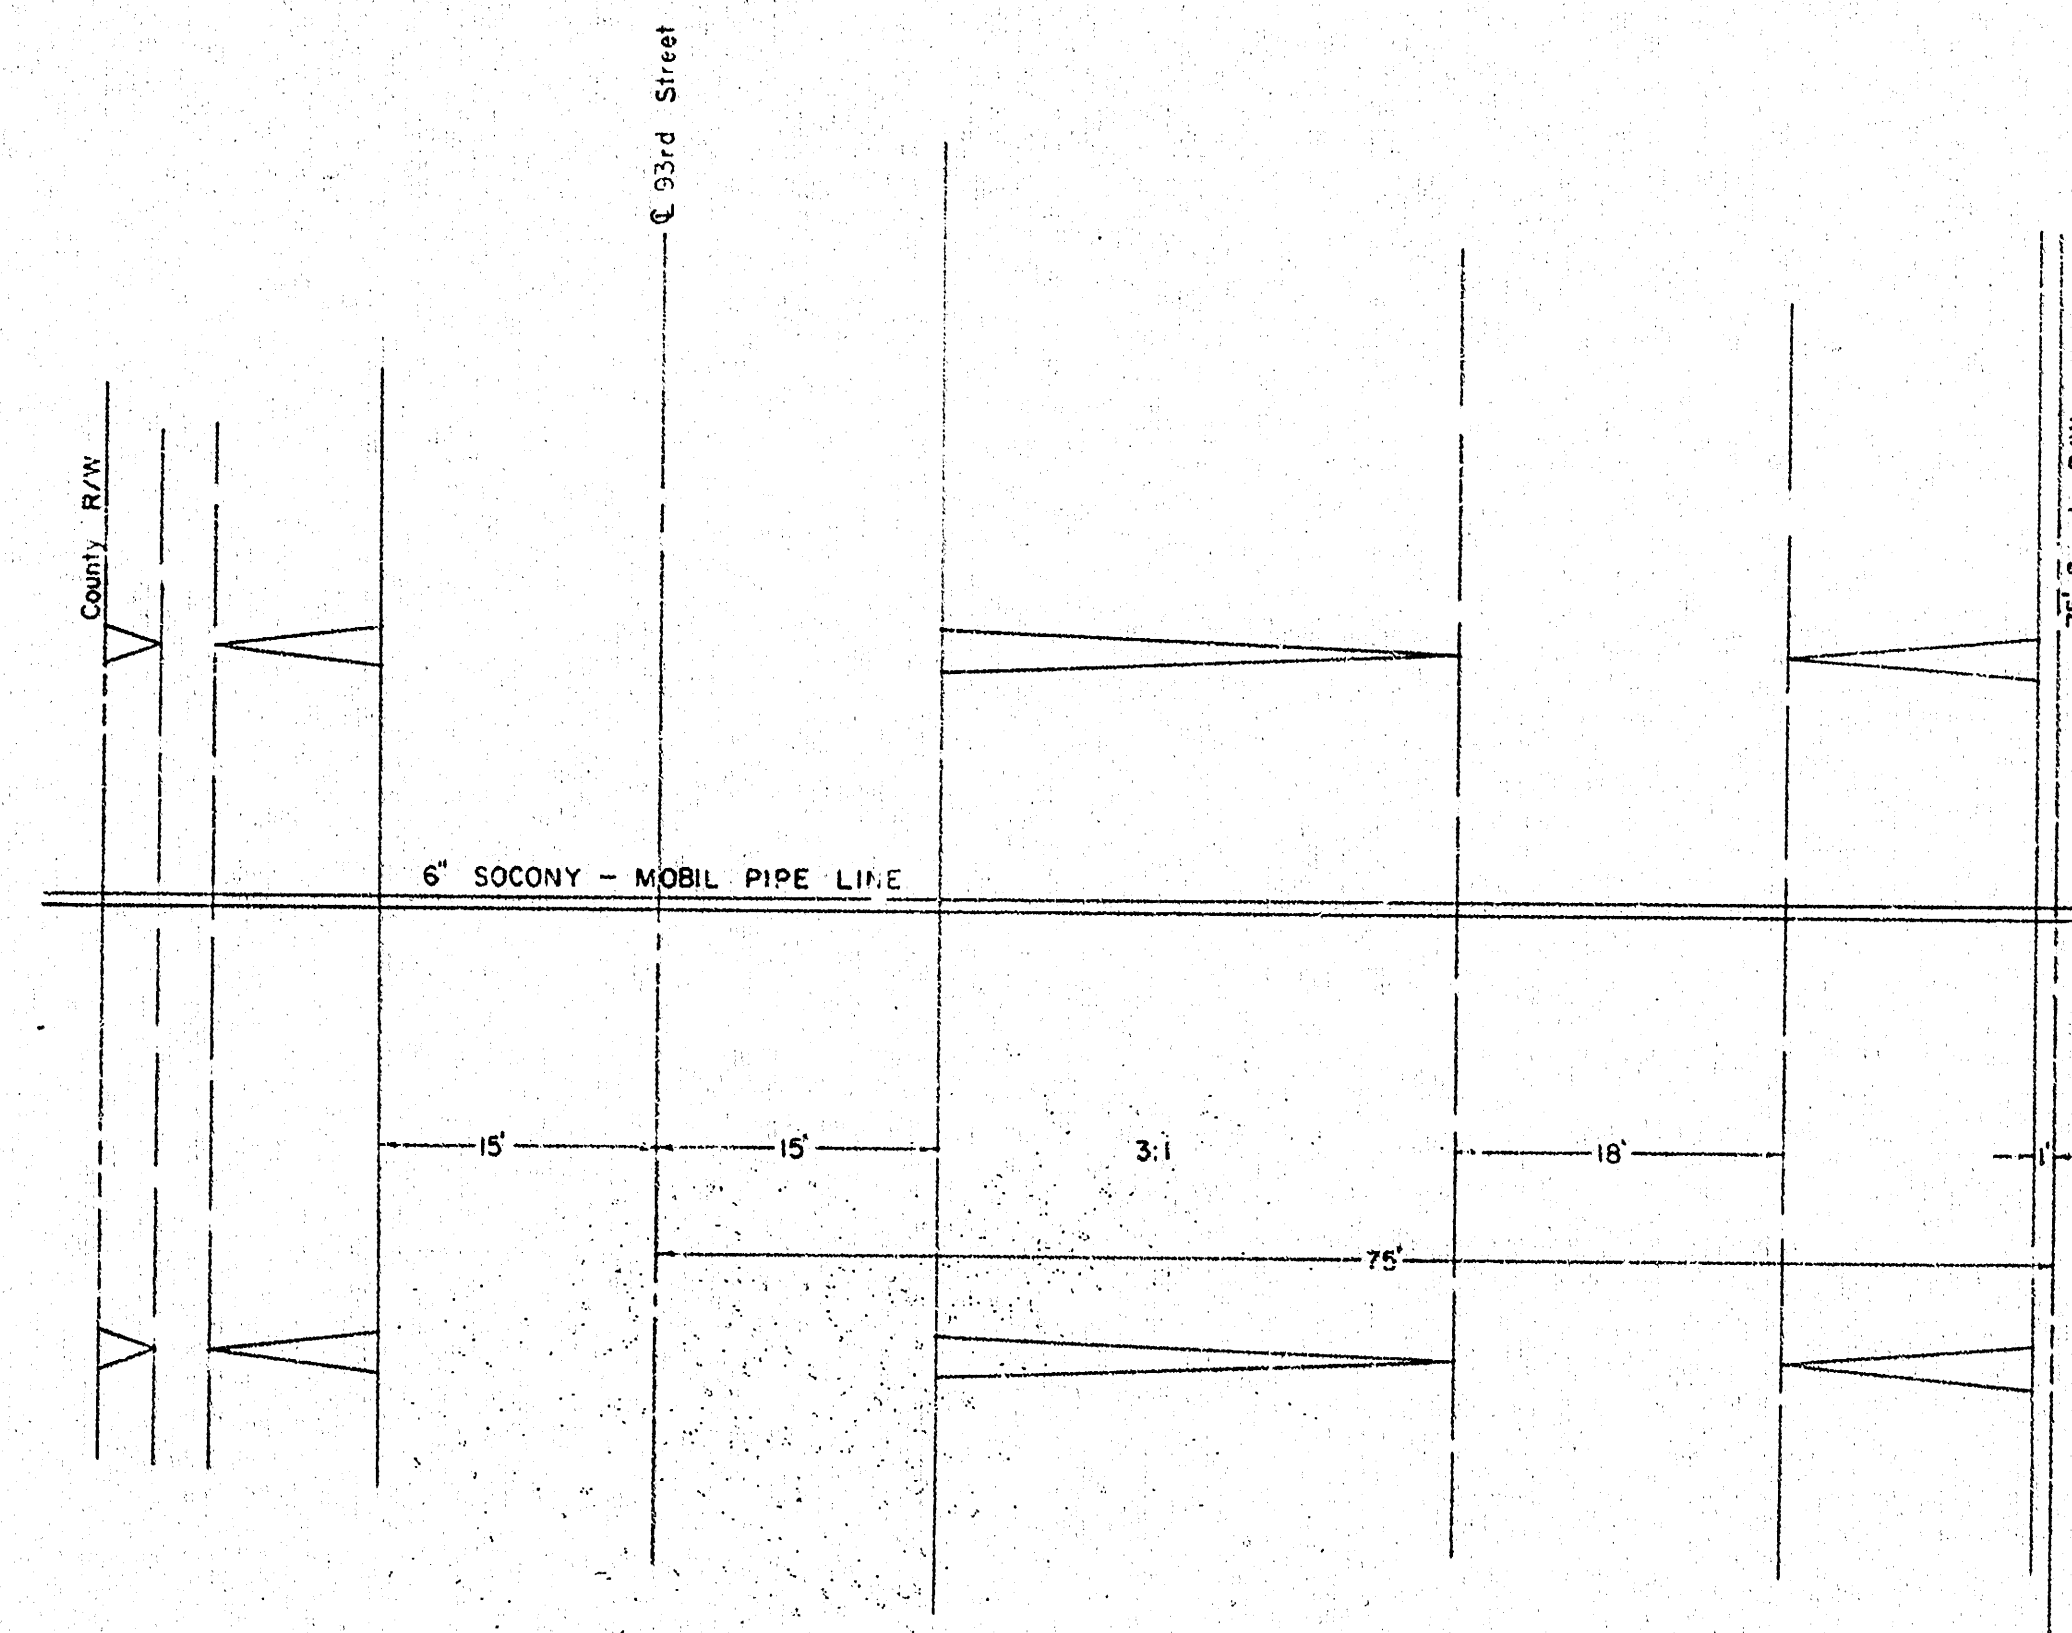

CITY-COUNTY FLOOD CONTROL OFFICE
PLAN AND PROFILE
PROPOSED RELOCATION
6" SOCONY-MOBIL PIPE LINE
93RD ST. CROSSING


 

SCALE: 1" = 10' HORIZONTAL
1" = 2' VERTICAL
DATE: 4-10-63
DRAWN: CBS
M. S. Mitchell
FLOOD CONTROL SUPERINTENDENT

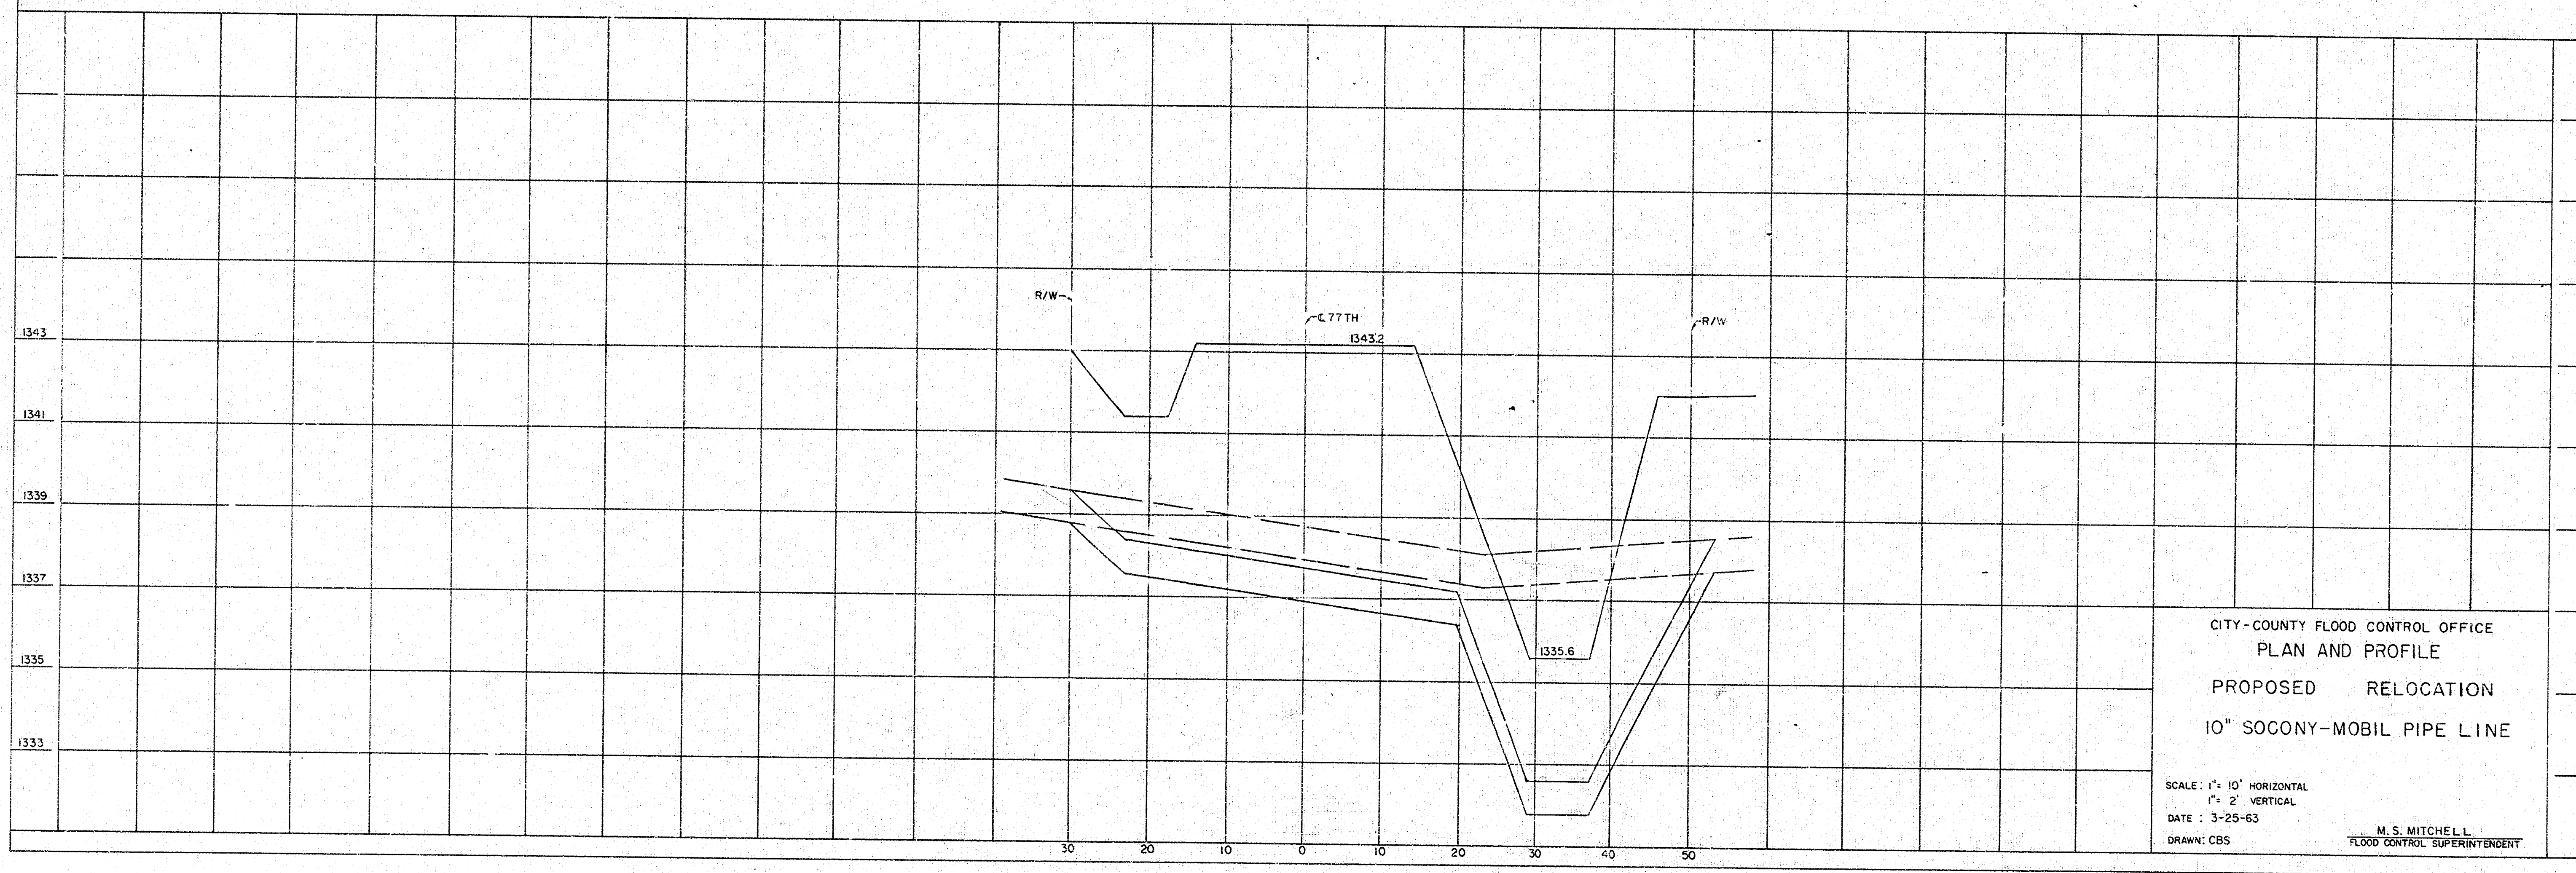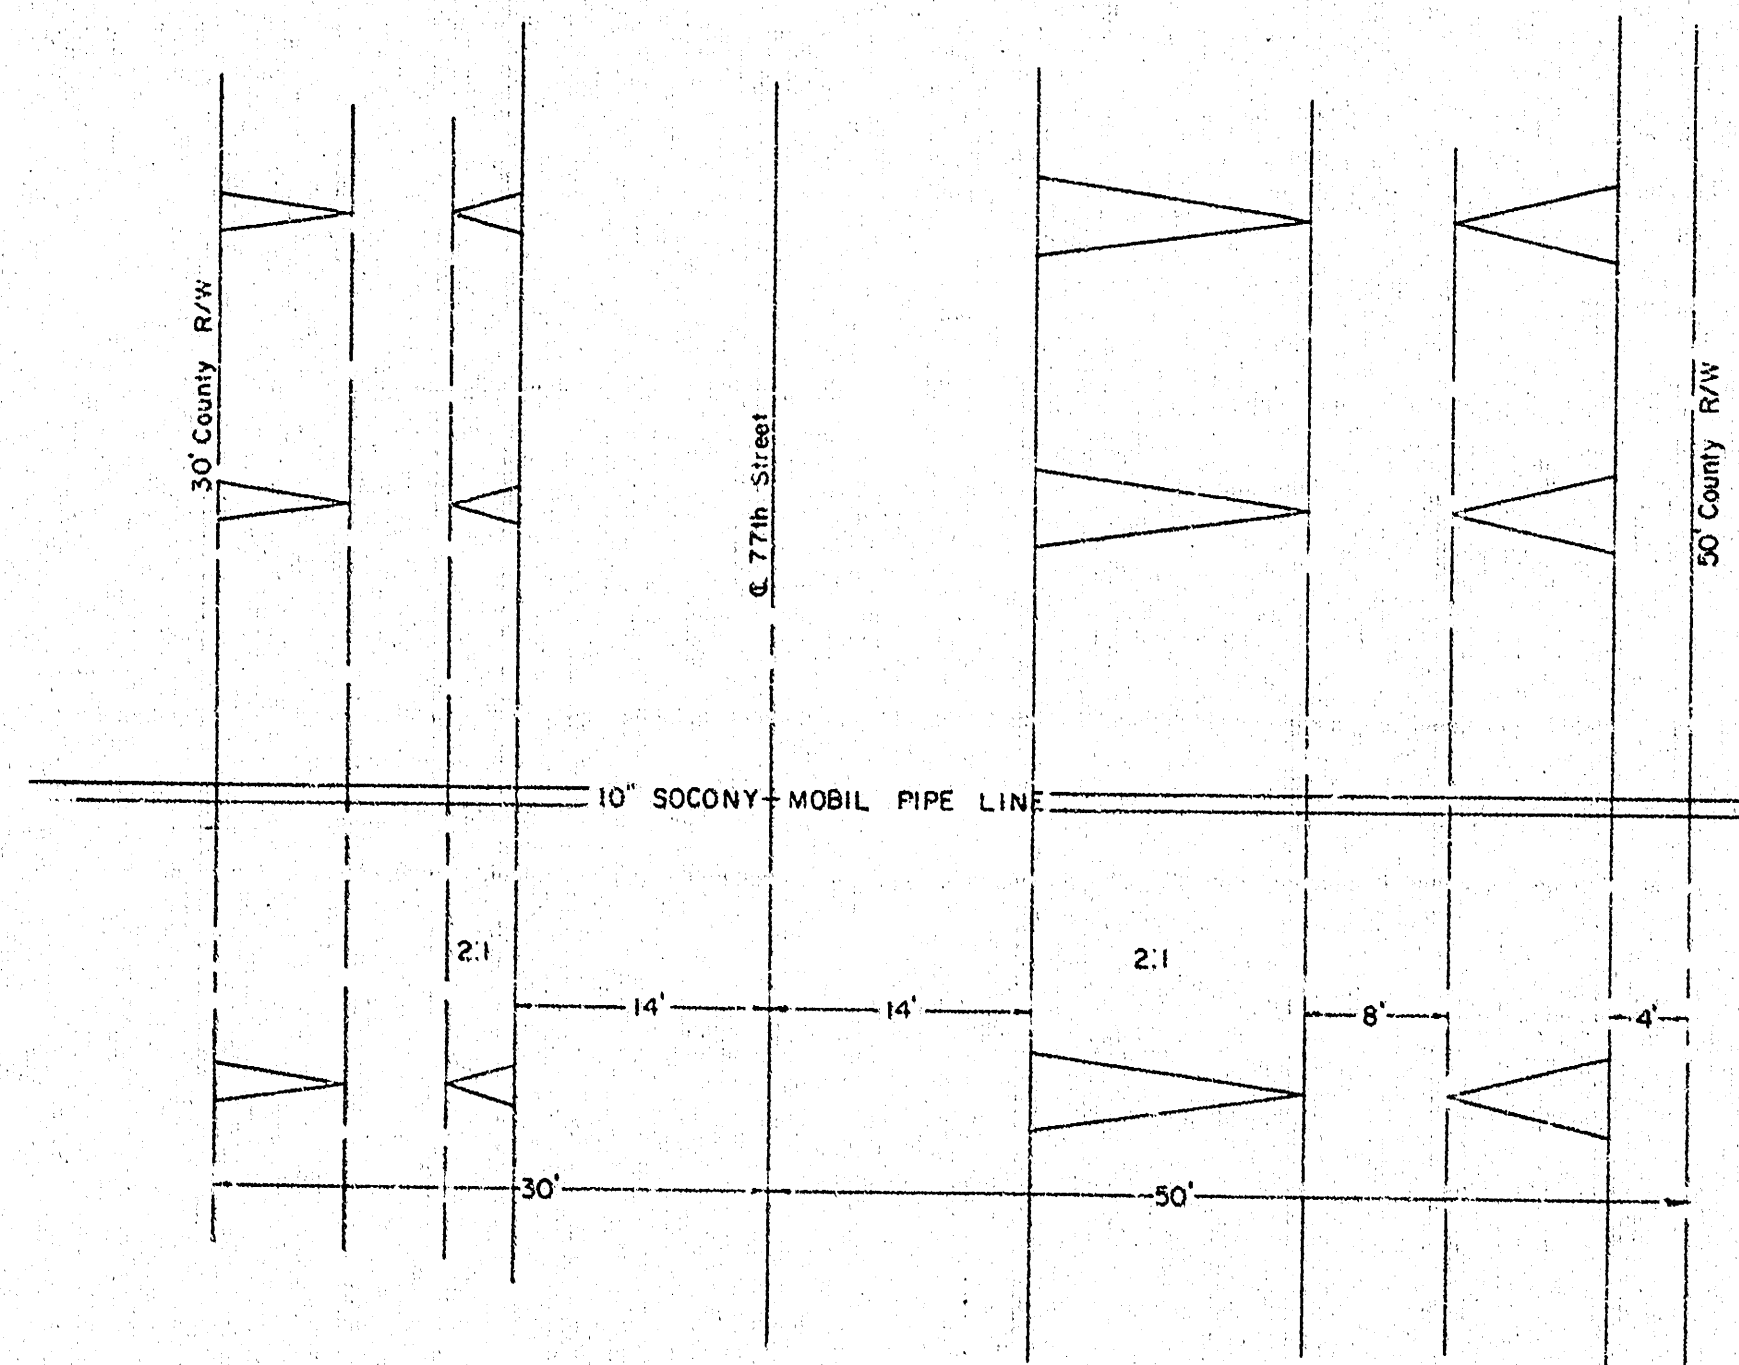

CITY-COUNTY FLOOD CONTROL OFFICE
PLAN AND PROFILE
PROPOSED RELOCATION
10" SOCONY-MOBIL PIPE LINE


SCALE: 1" = 10' HORIZONTAL
1" = 2' VERTICAL
DATE: 3-25-63
DRAWN: CBS

M. S. MITCHELL
FLOOD CONTROL SUPERINTENDENT

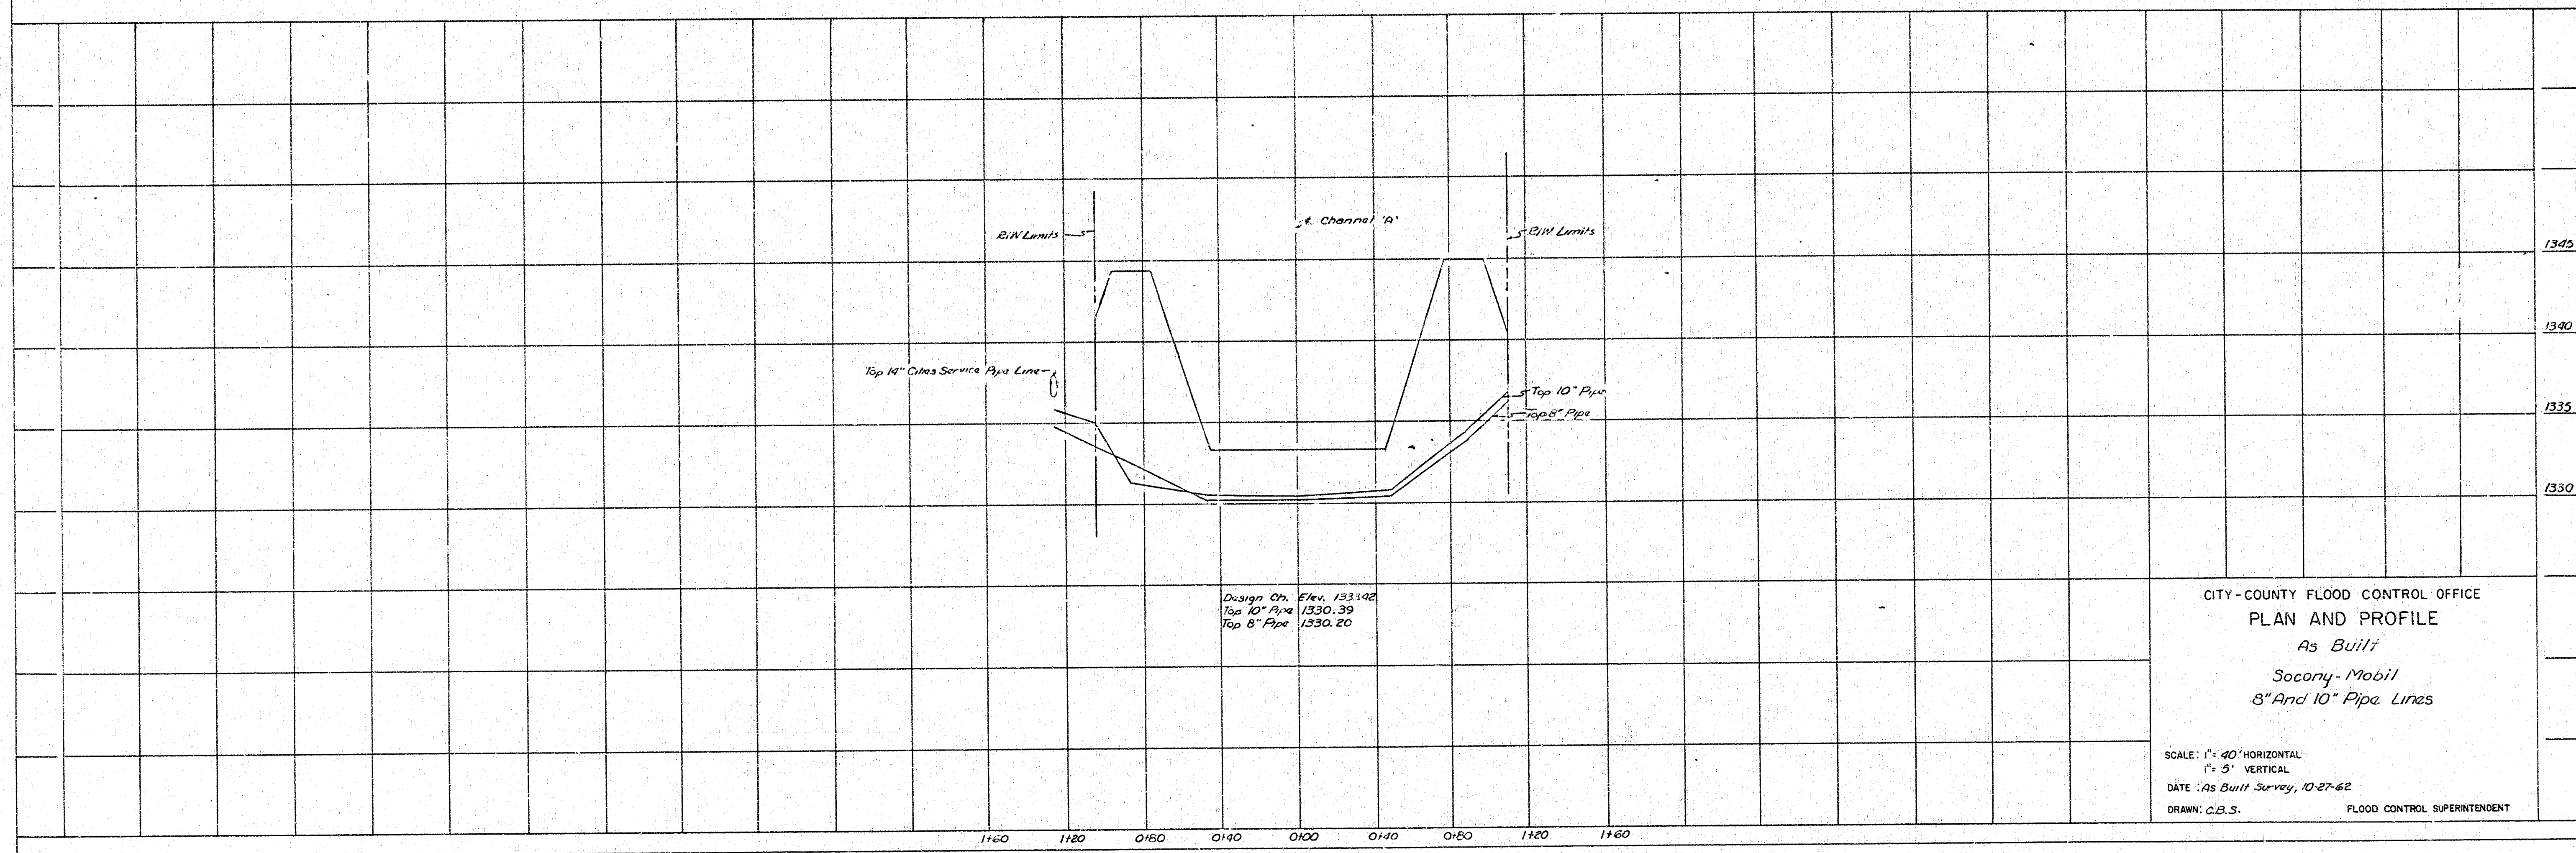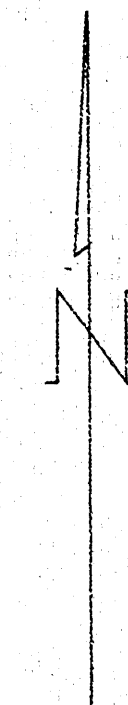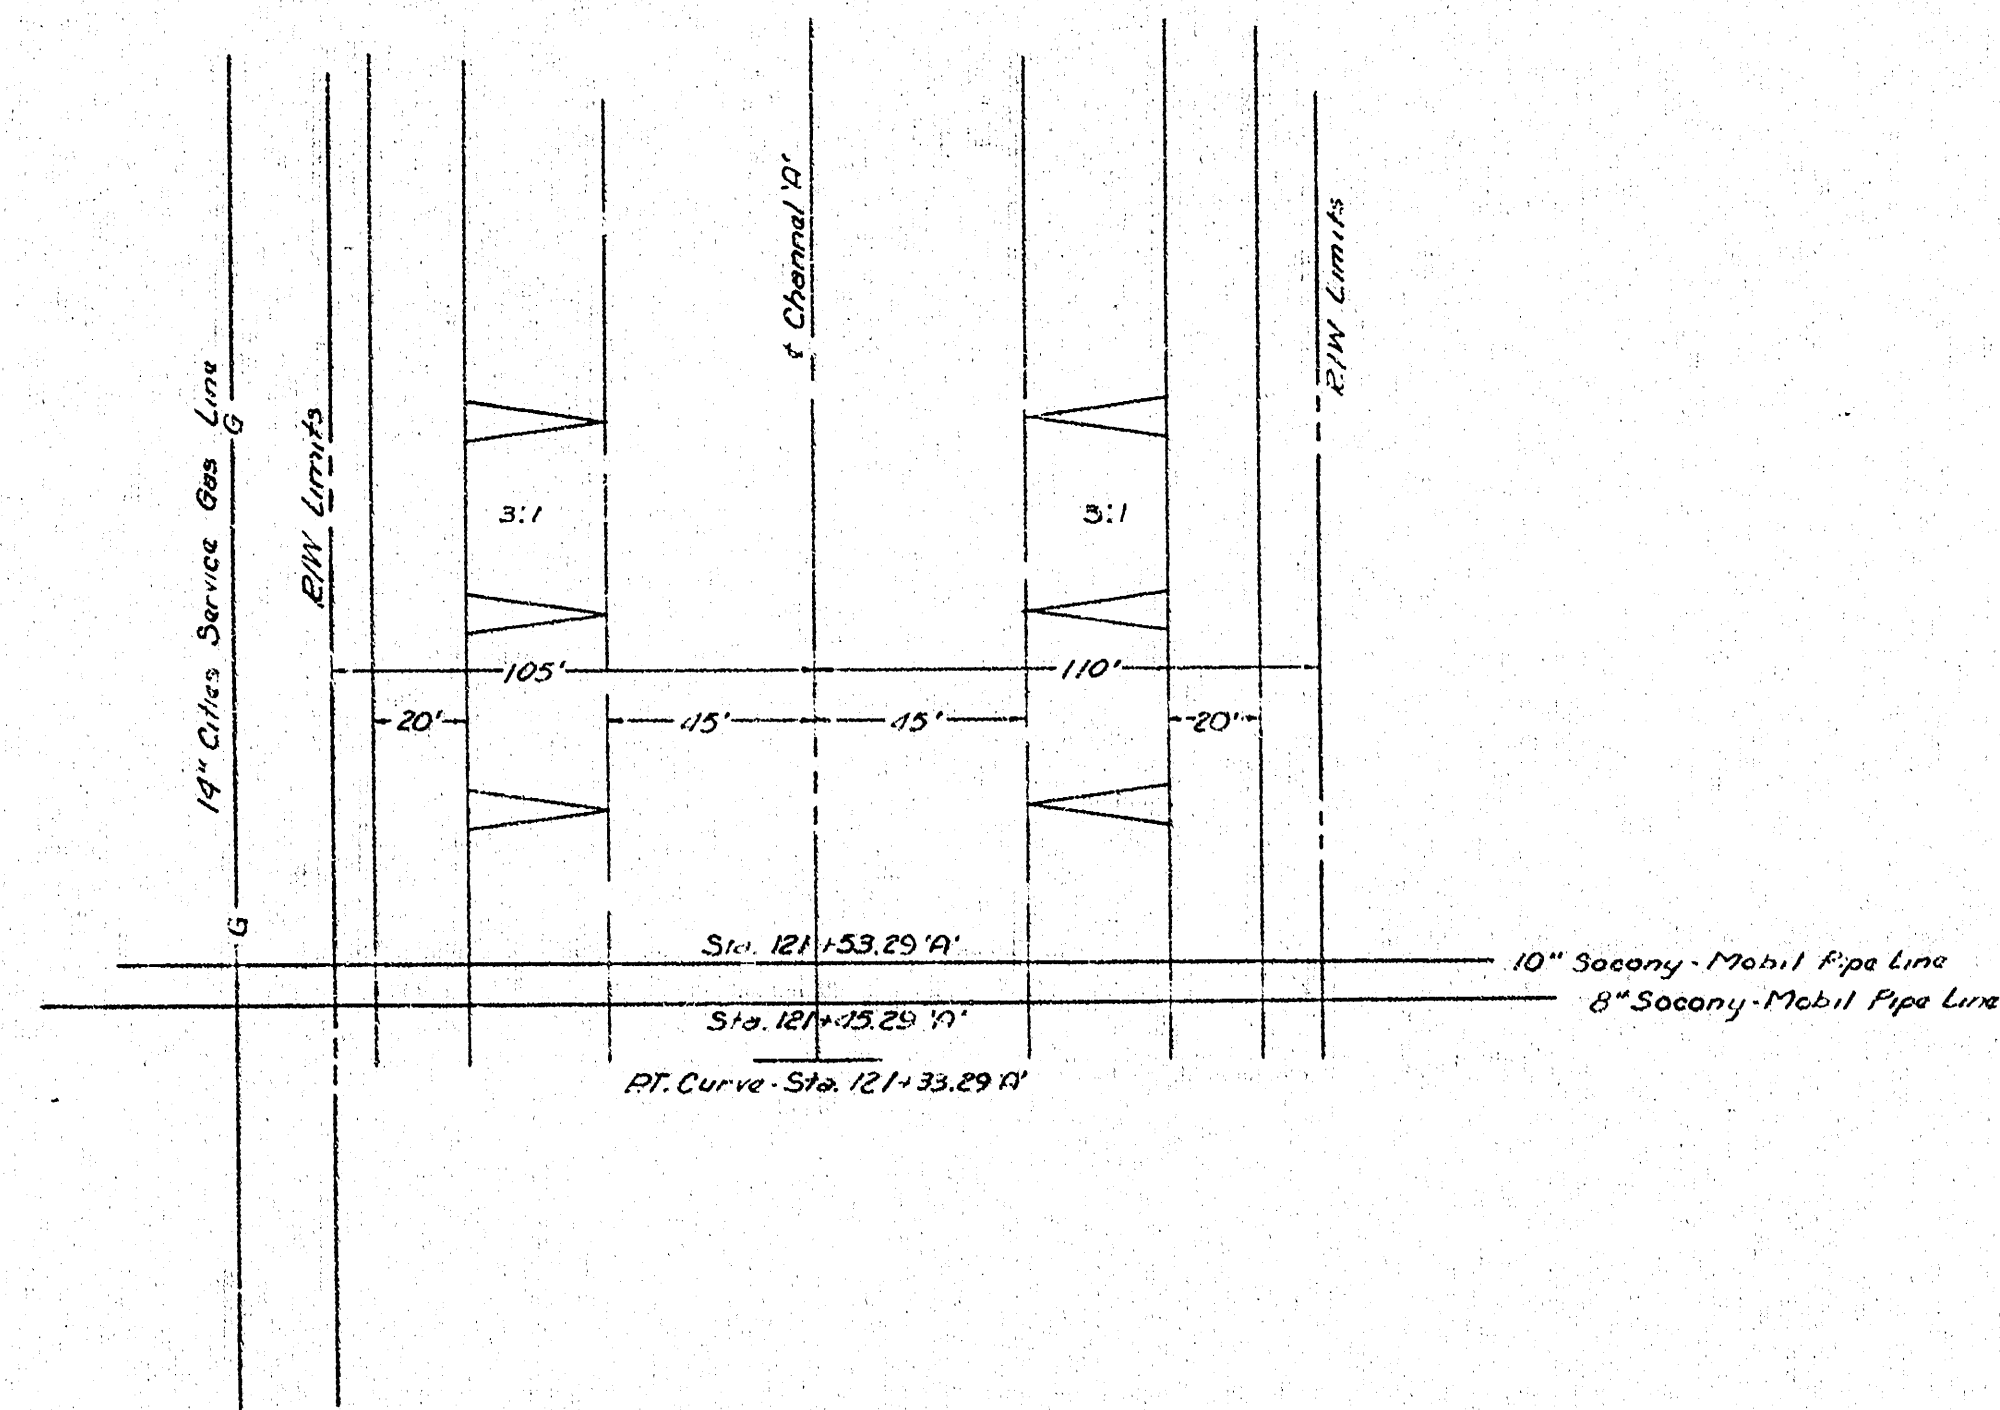


Design On Elev. 1331.42
Top 10" Pipe 1330.39
Top 8" Pipe 1330.20

CITY-COUNTY FLOOD CONTROL OFFICE
PLAN AND PROFILE
As Built
Socony-Mobil
8" And 10" Pipe Lines
SCALE: 1" = 40' HORIZONTAL
1" = 5' VERTICAL
DATE: As Built Survey, 10-27-62
DRAWN: C.B.S. FLOOD CONTROL SUPERINTENDENT

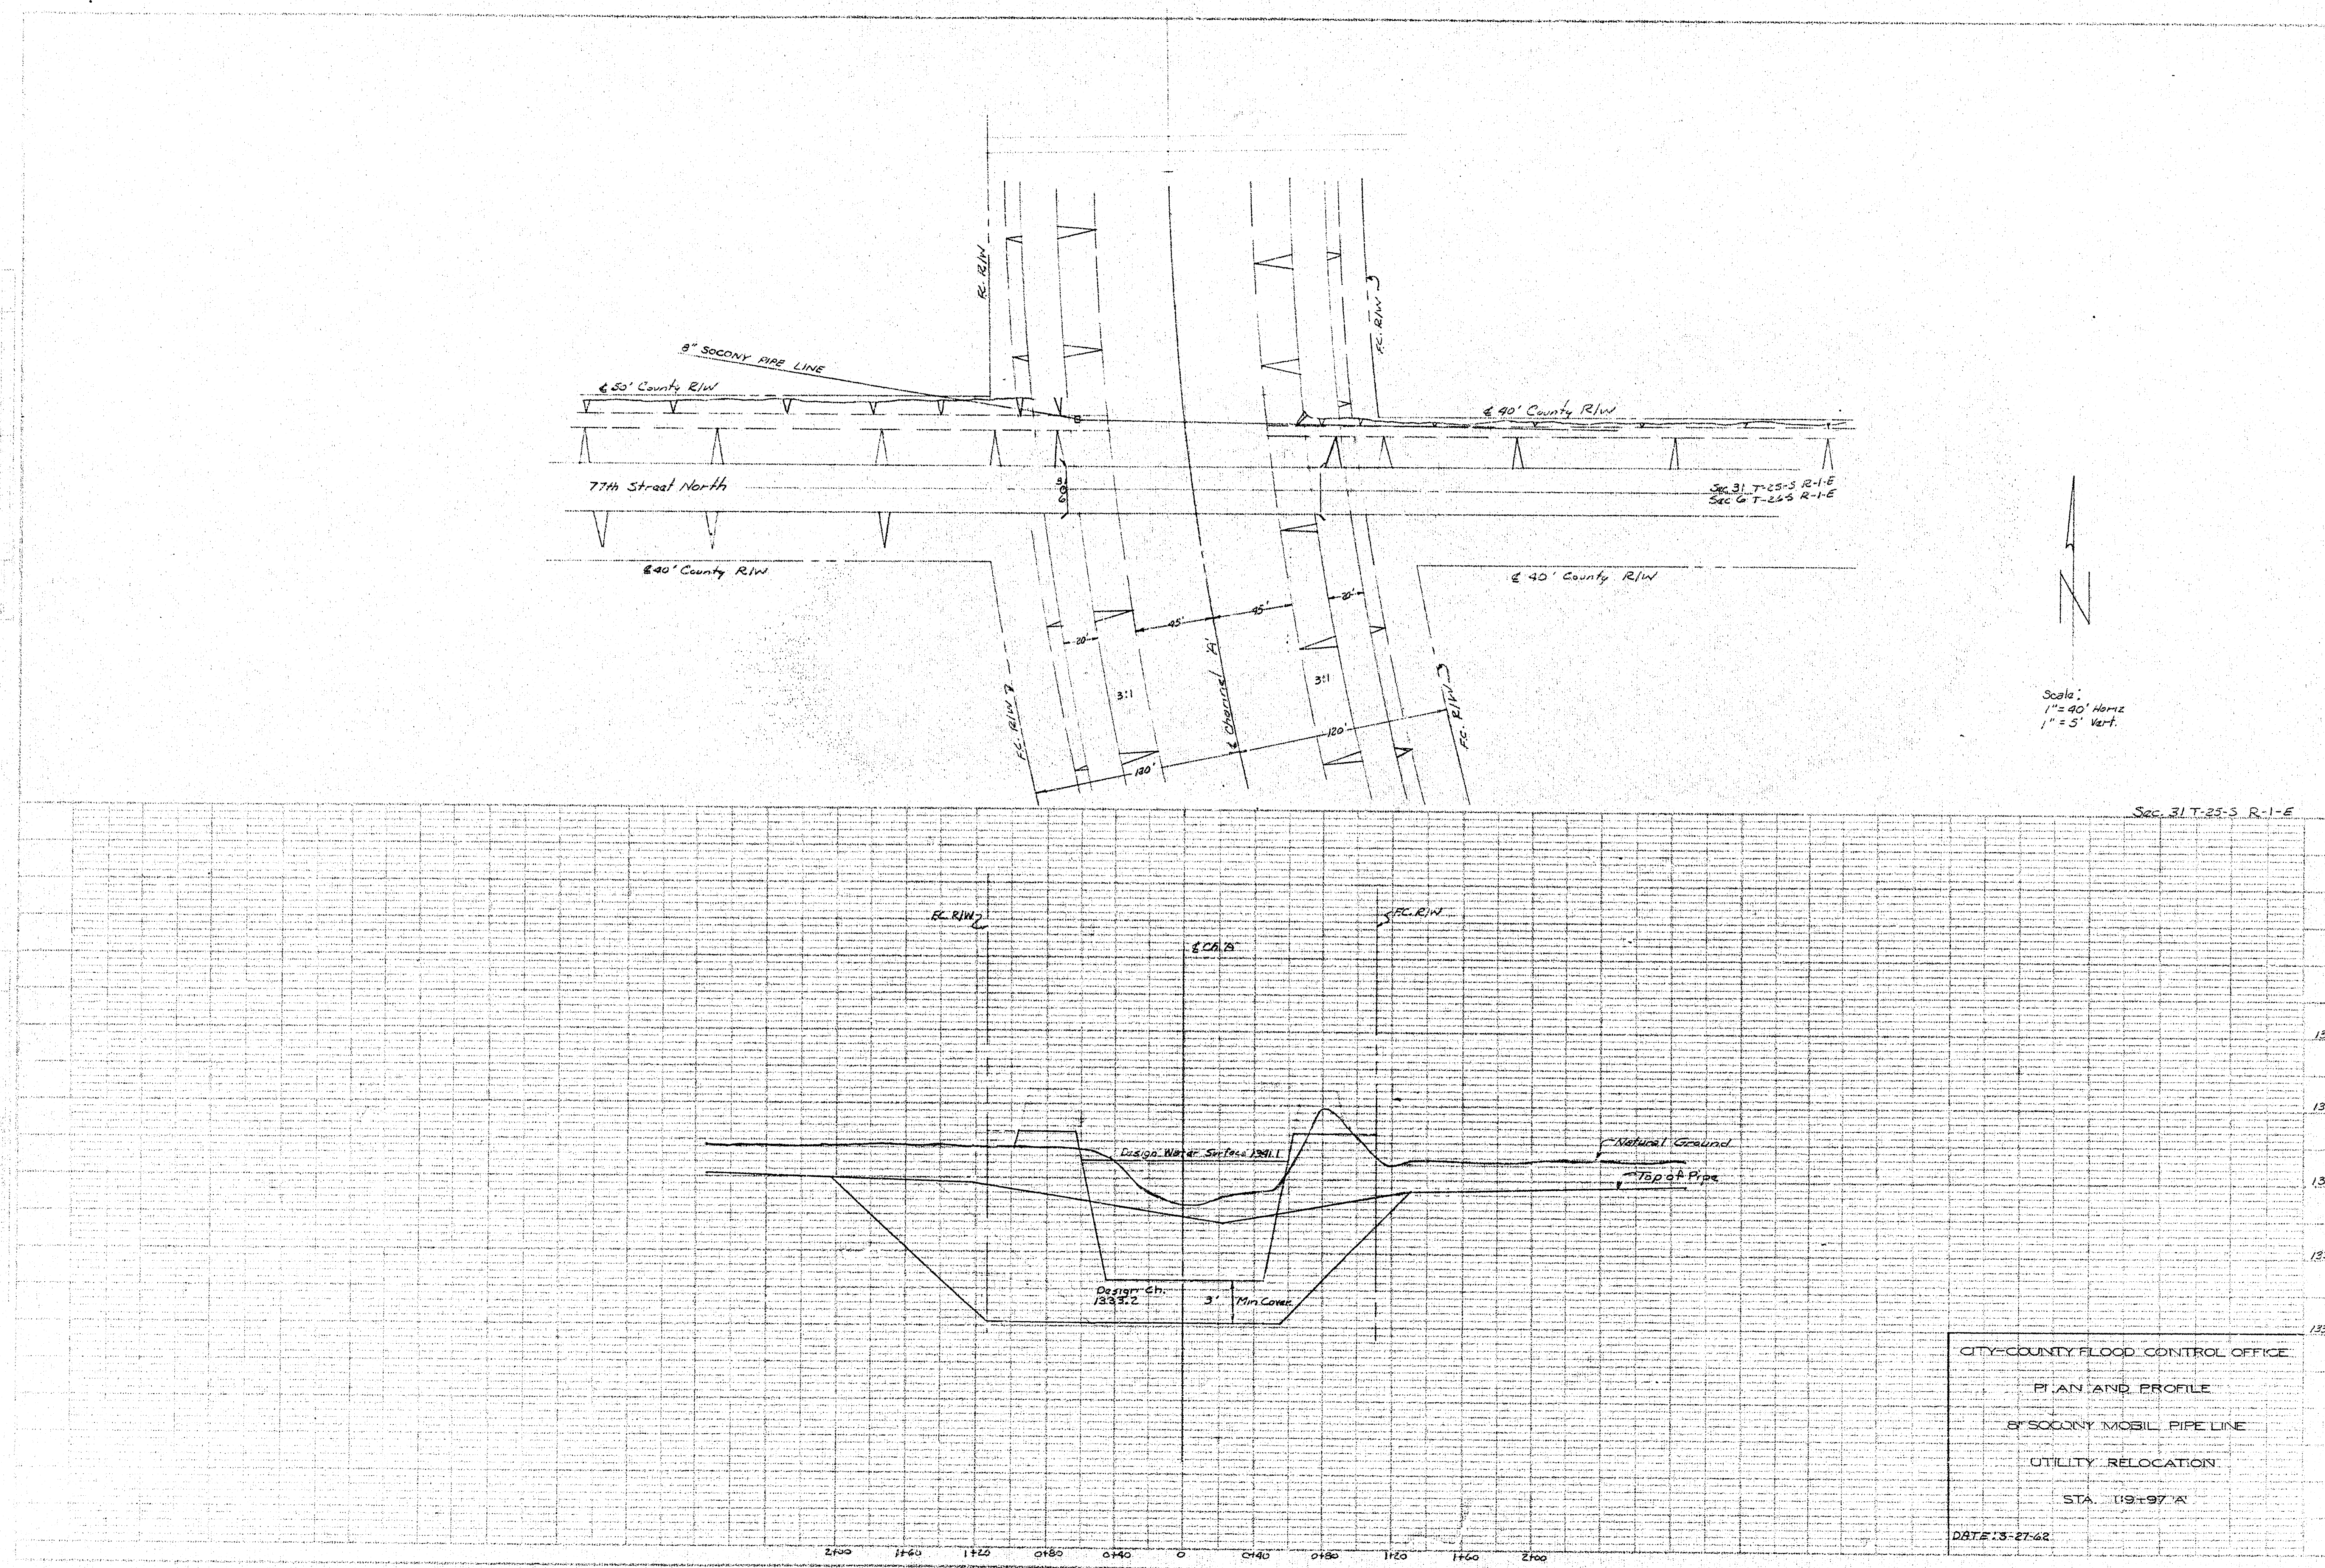

PLAN	REVISION	DATE
1	1	10/1/59
2	2	10/1/59
3	3	10/1/59
4	4	10/1/59
5	5	10/1/59
6	6	10/1/59
7	7	10/1/59
8	8	10/1/59
9	9	10/1/59
10	10	10/1/59

PROFILE	REVISION	DATE
1	1	10/1/59
2	2	10/1/59
3	3	10/1/59
4	4	10/1/59
5	5	10/1/59
6	6	10/1/59
7	7	10/1/59
8	8	10/1/59
9	9	10/1/59
10	10	10/1/59

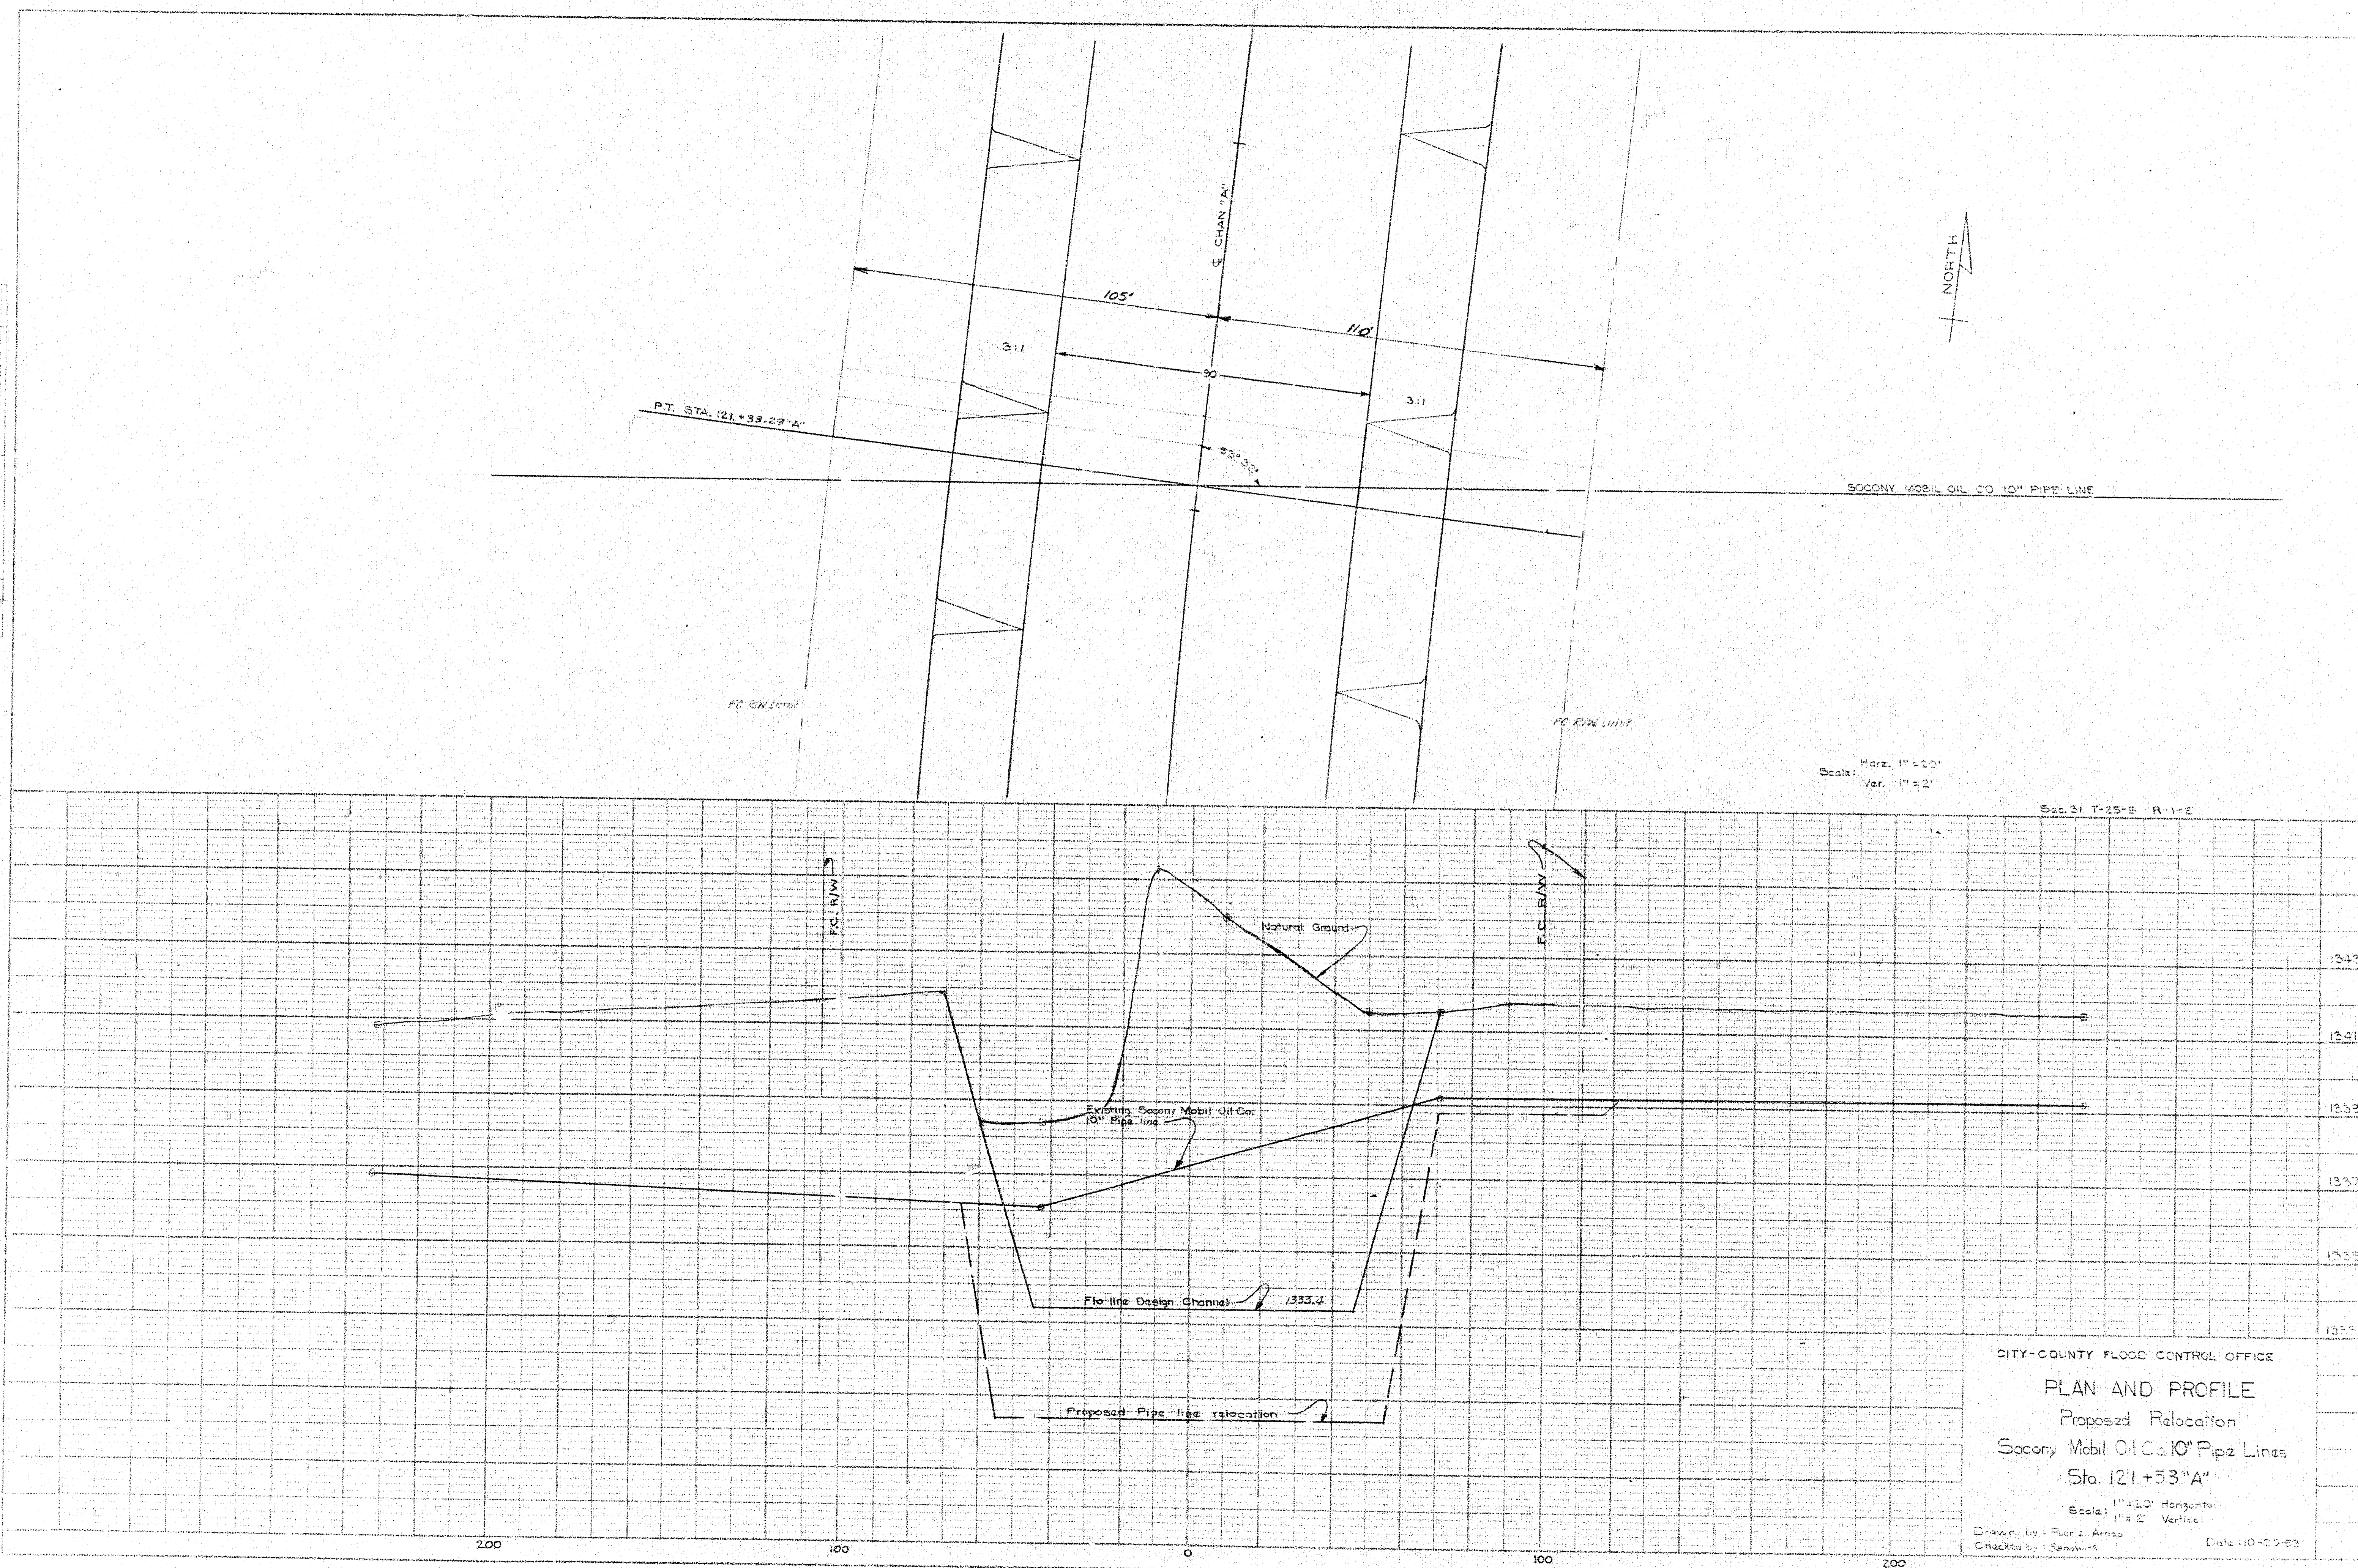

CITY-COUNTY FLOOD CONTROL OFFICE
 PLAN AND PROFILE
 Proposed Relocation
 Socony Mobil Oil Co. 10" Pipe Lines
 Sta. 121+53" A"
 Scale: 1"=10' Horizontal
 1"=2' Vertical
 Drawn by: Bruce Arneson
 Checked by: [Signature]
 Date: 10-1-59