



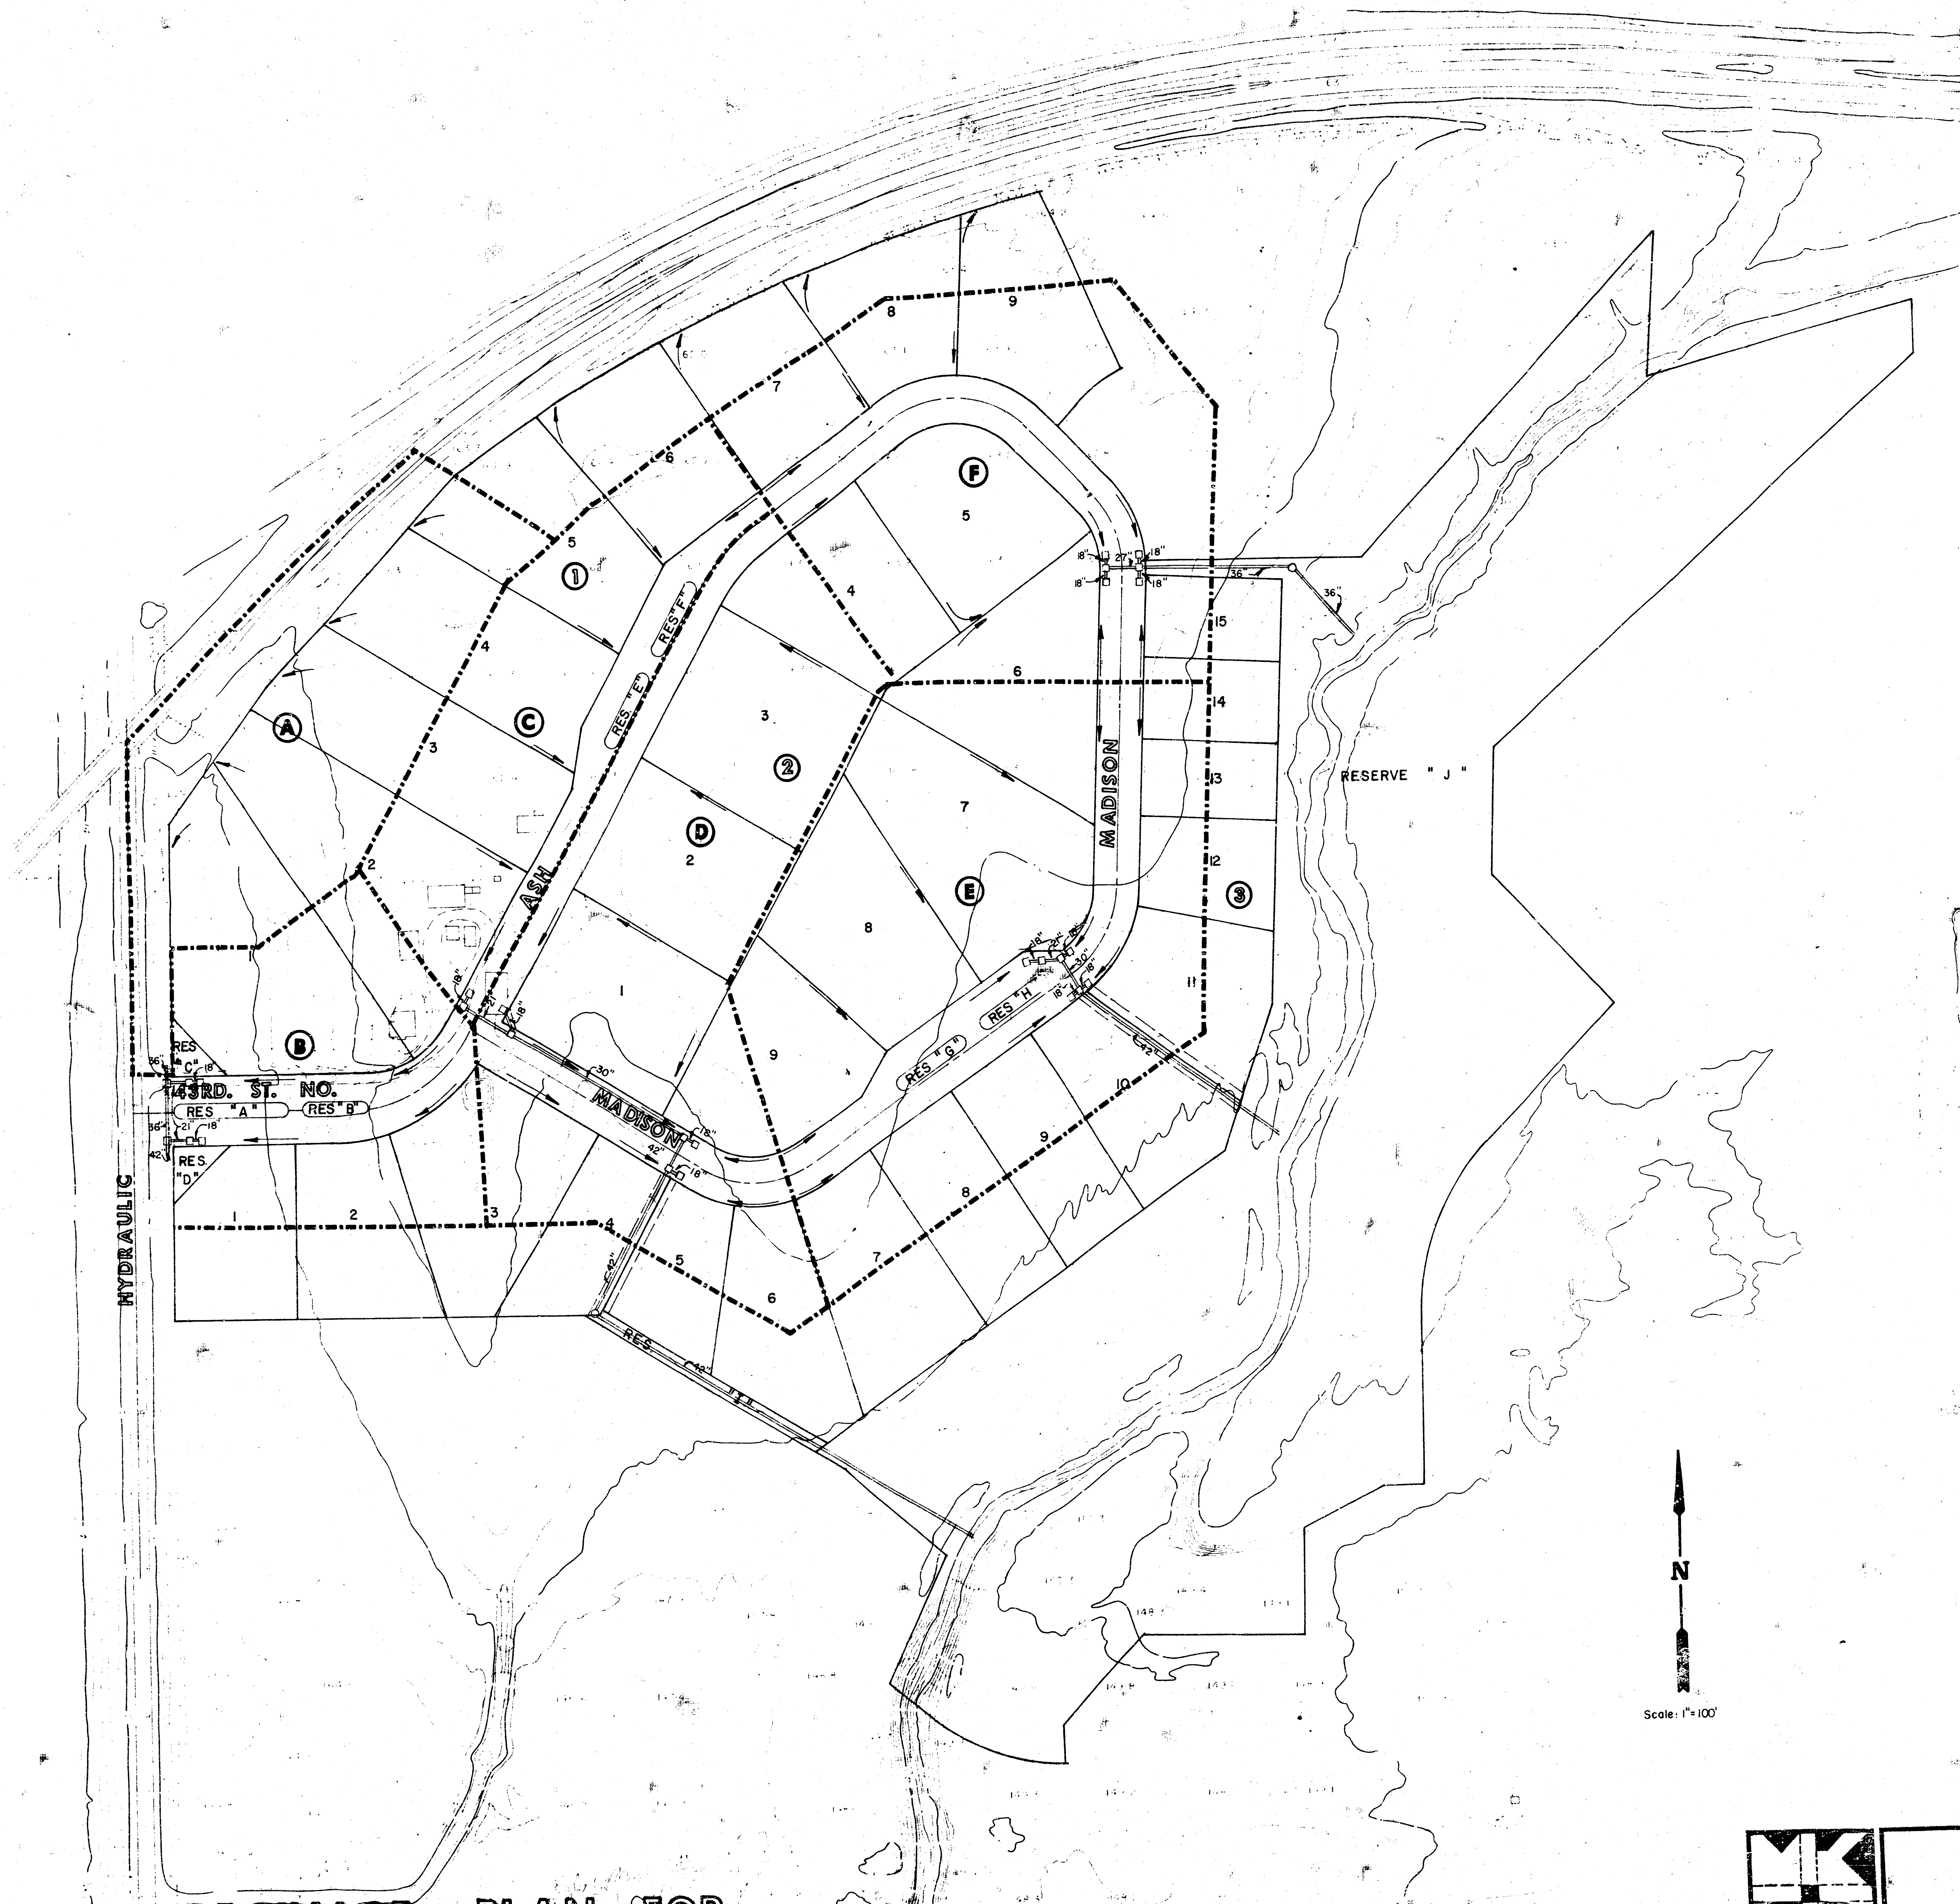

DRAINAGE PLAN FOR CHISHOLM CREEK COMMERCE CENTER

	Drawn by Checked by Date Job No.
	MID-KANSAS ENGINEERING CONSULTANTS PA 240 NORTH ROCK ROAD SUITE 130 WICHITA, KANSAS 67206
	682-6561
	Sheet of

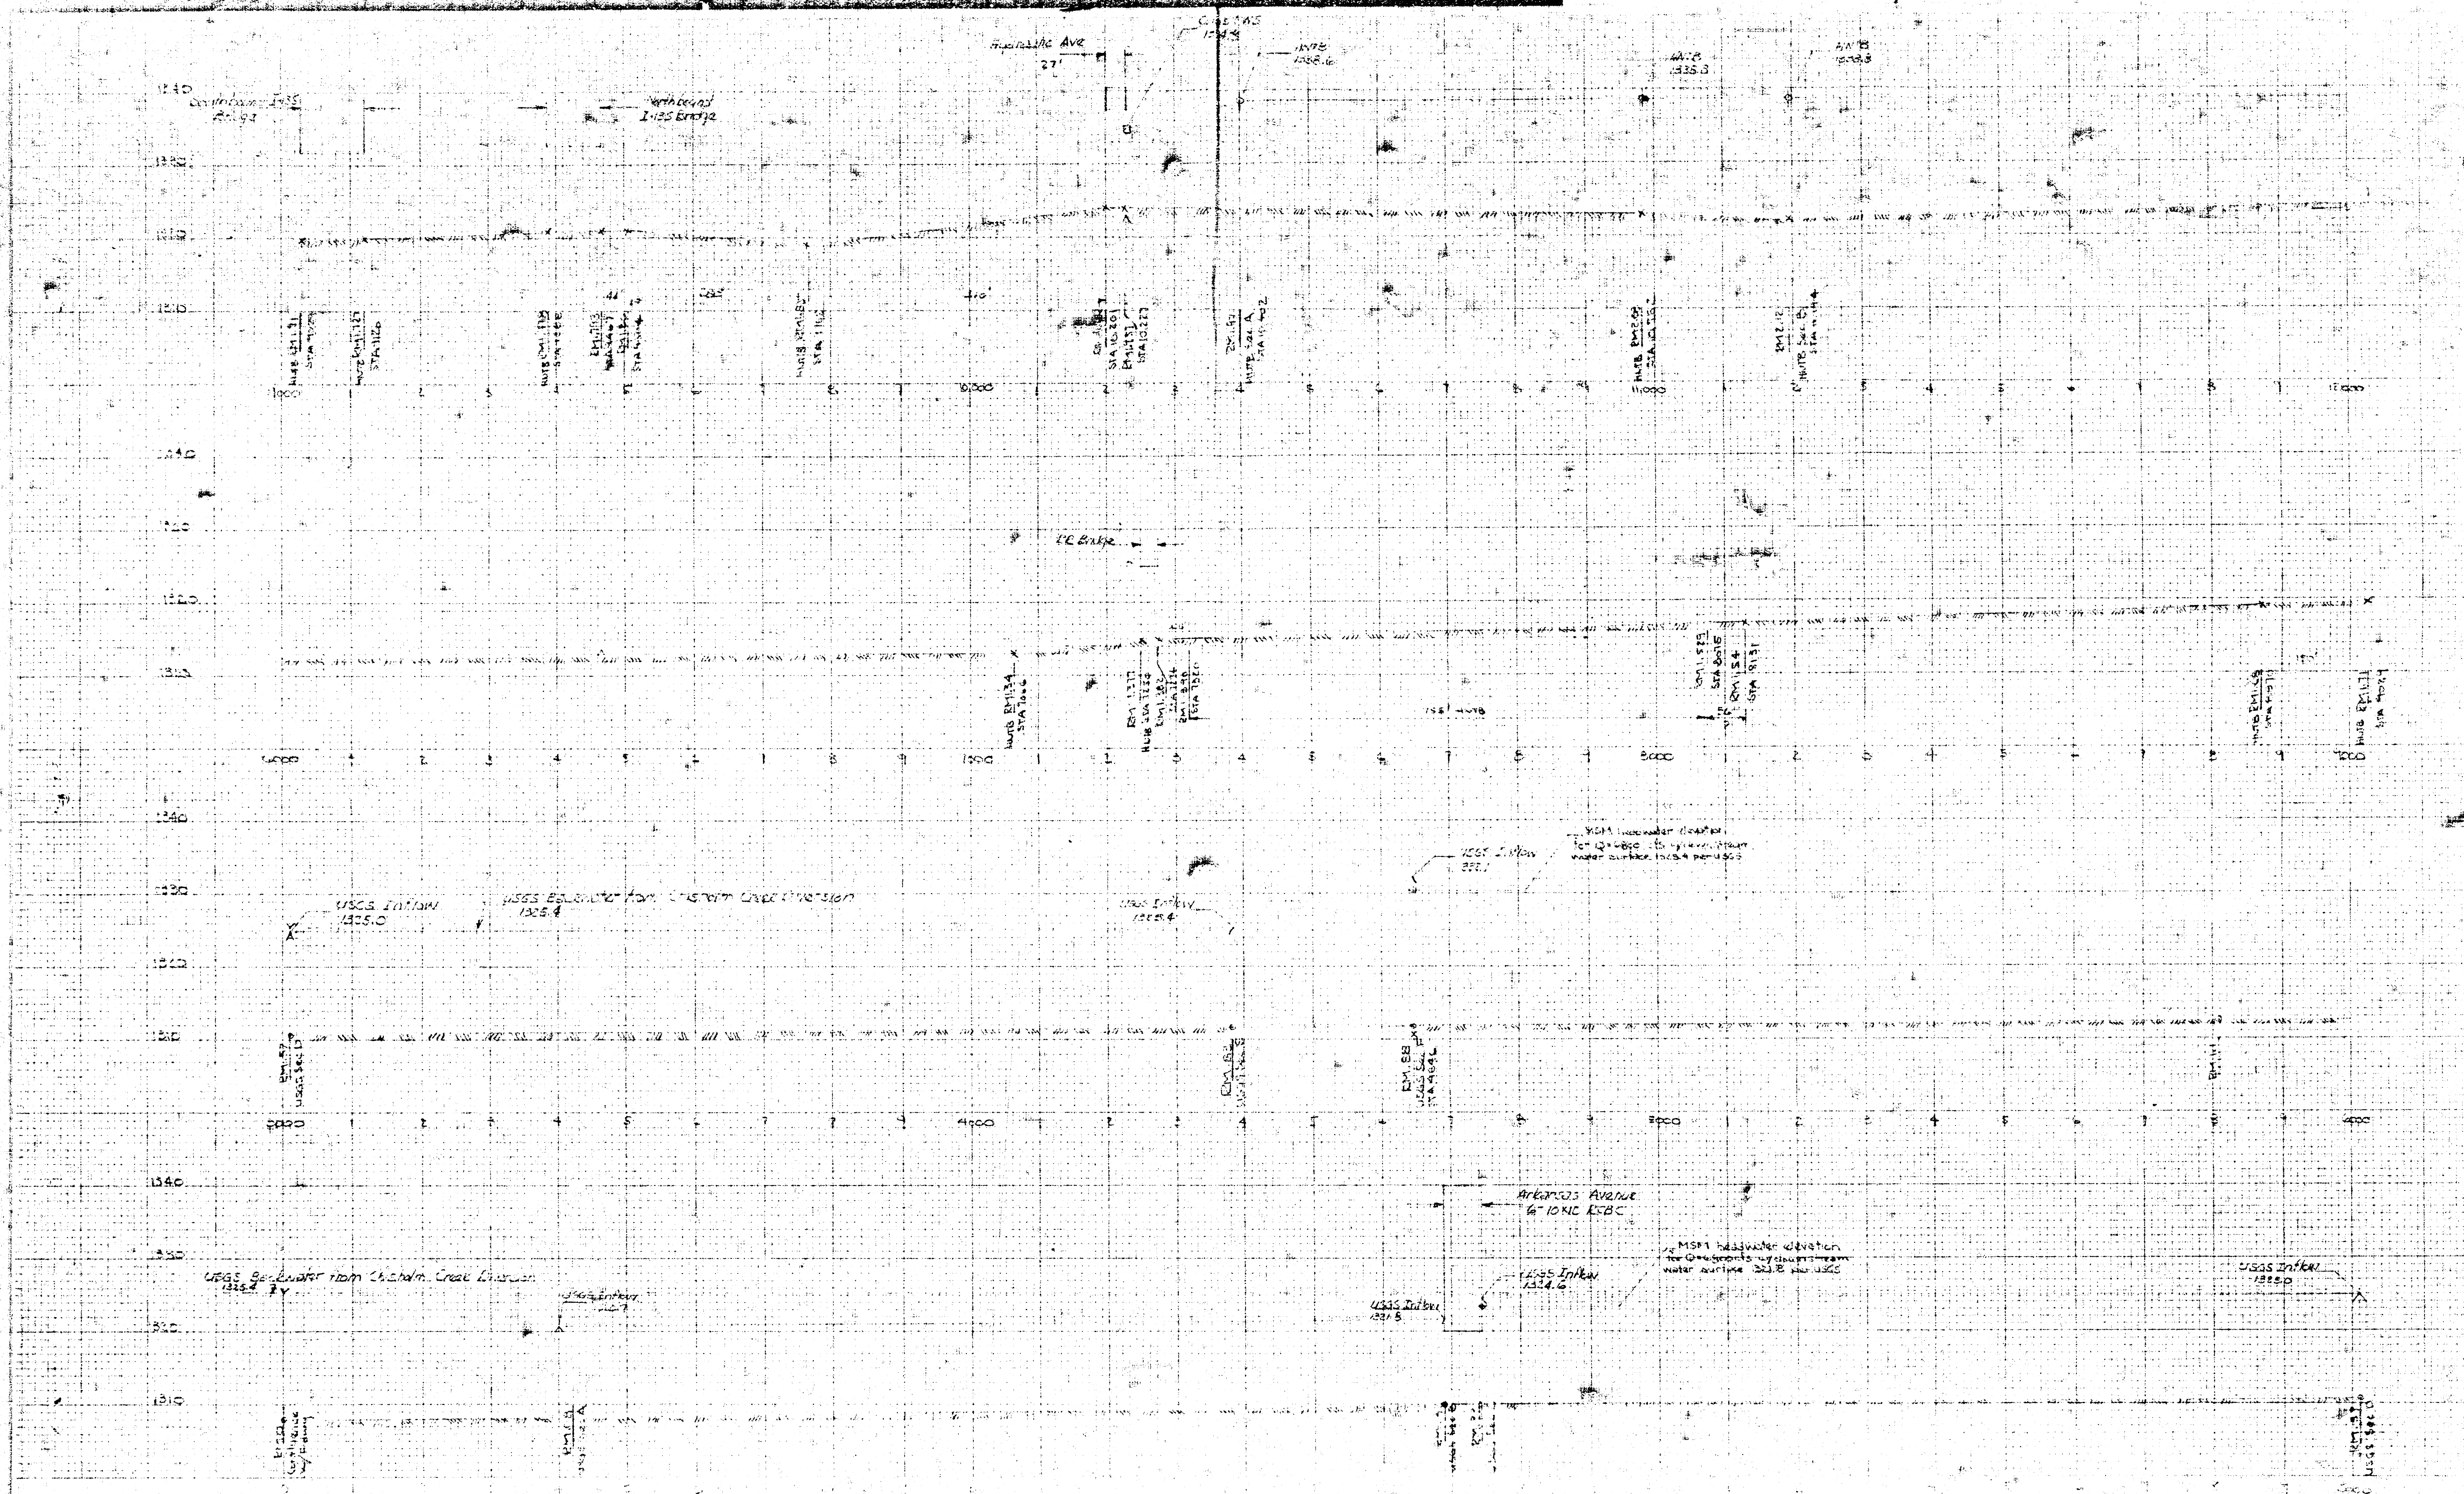

													Proposed Sew. Slope	Pipe Size & Slope	Notes in Sump
STATION	AREA	AREA	T _c	C	L _c	L ₁₀₀	Q _c	Q ₁₀₀	Q ₂	Q ₁₀	Q ₅	Q ₂			
1	1.84 (1.0) TP														
2															
3															
4															
100															


Design should be based on 5 yr storm for commercial district with 100% pipe capacity & length & headloss.

Proposed pipe should be installed at this rate.

Proposed pipe should be installed at this rate.


Proposed pipe should be installed at this rate.

CHISHOLM CREEK COMMERCE CENTER
(DRAINAGE)

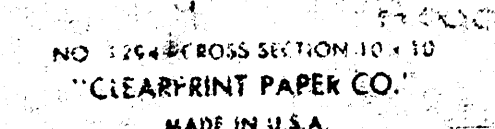


FILMED FROM THE BEST
AVAILABLE COPY

CHISHOLM CREEK COMMERCE CENTER
(DRAINAGE)

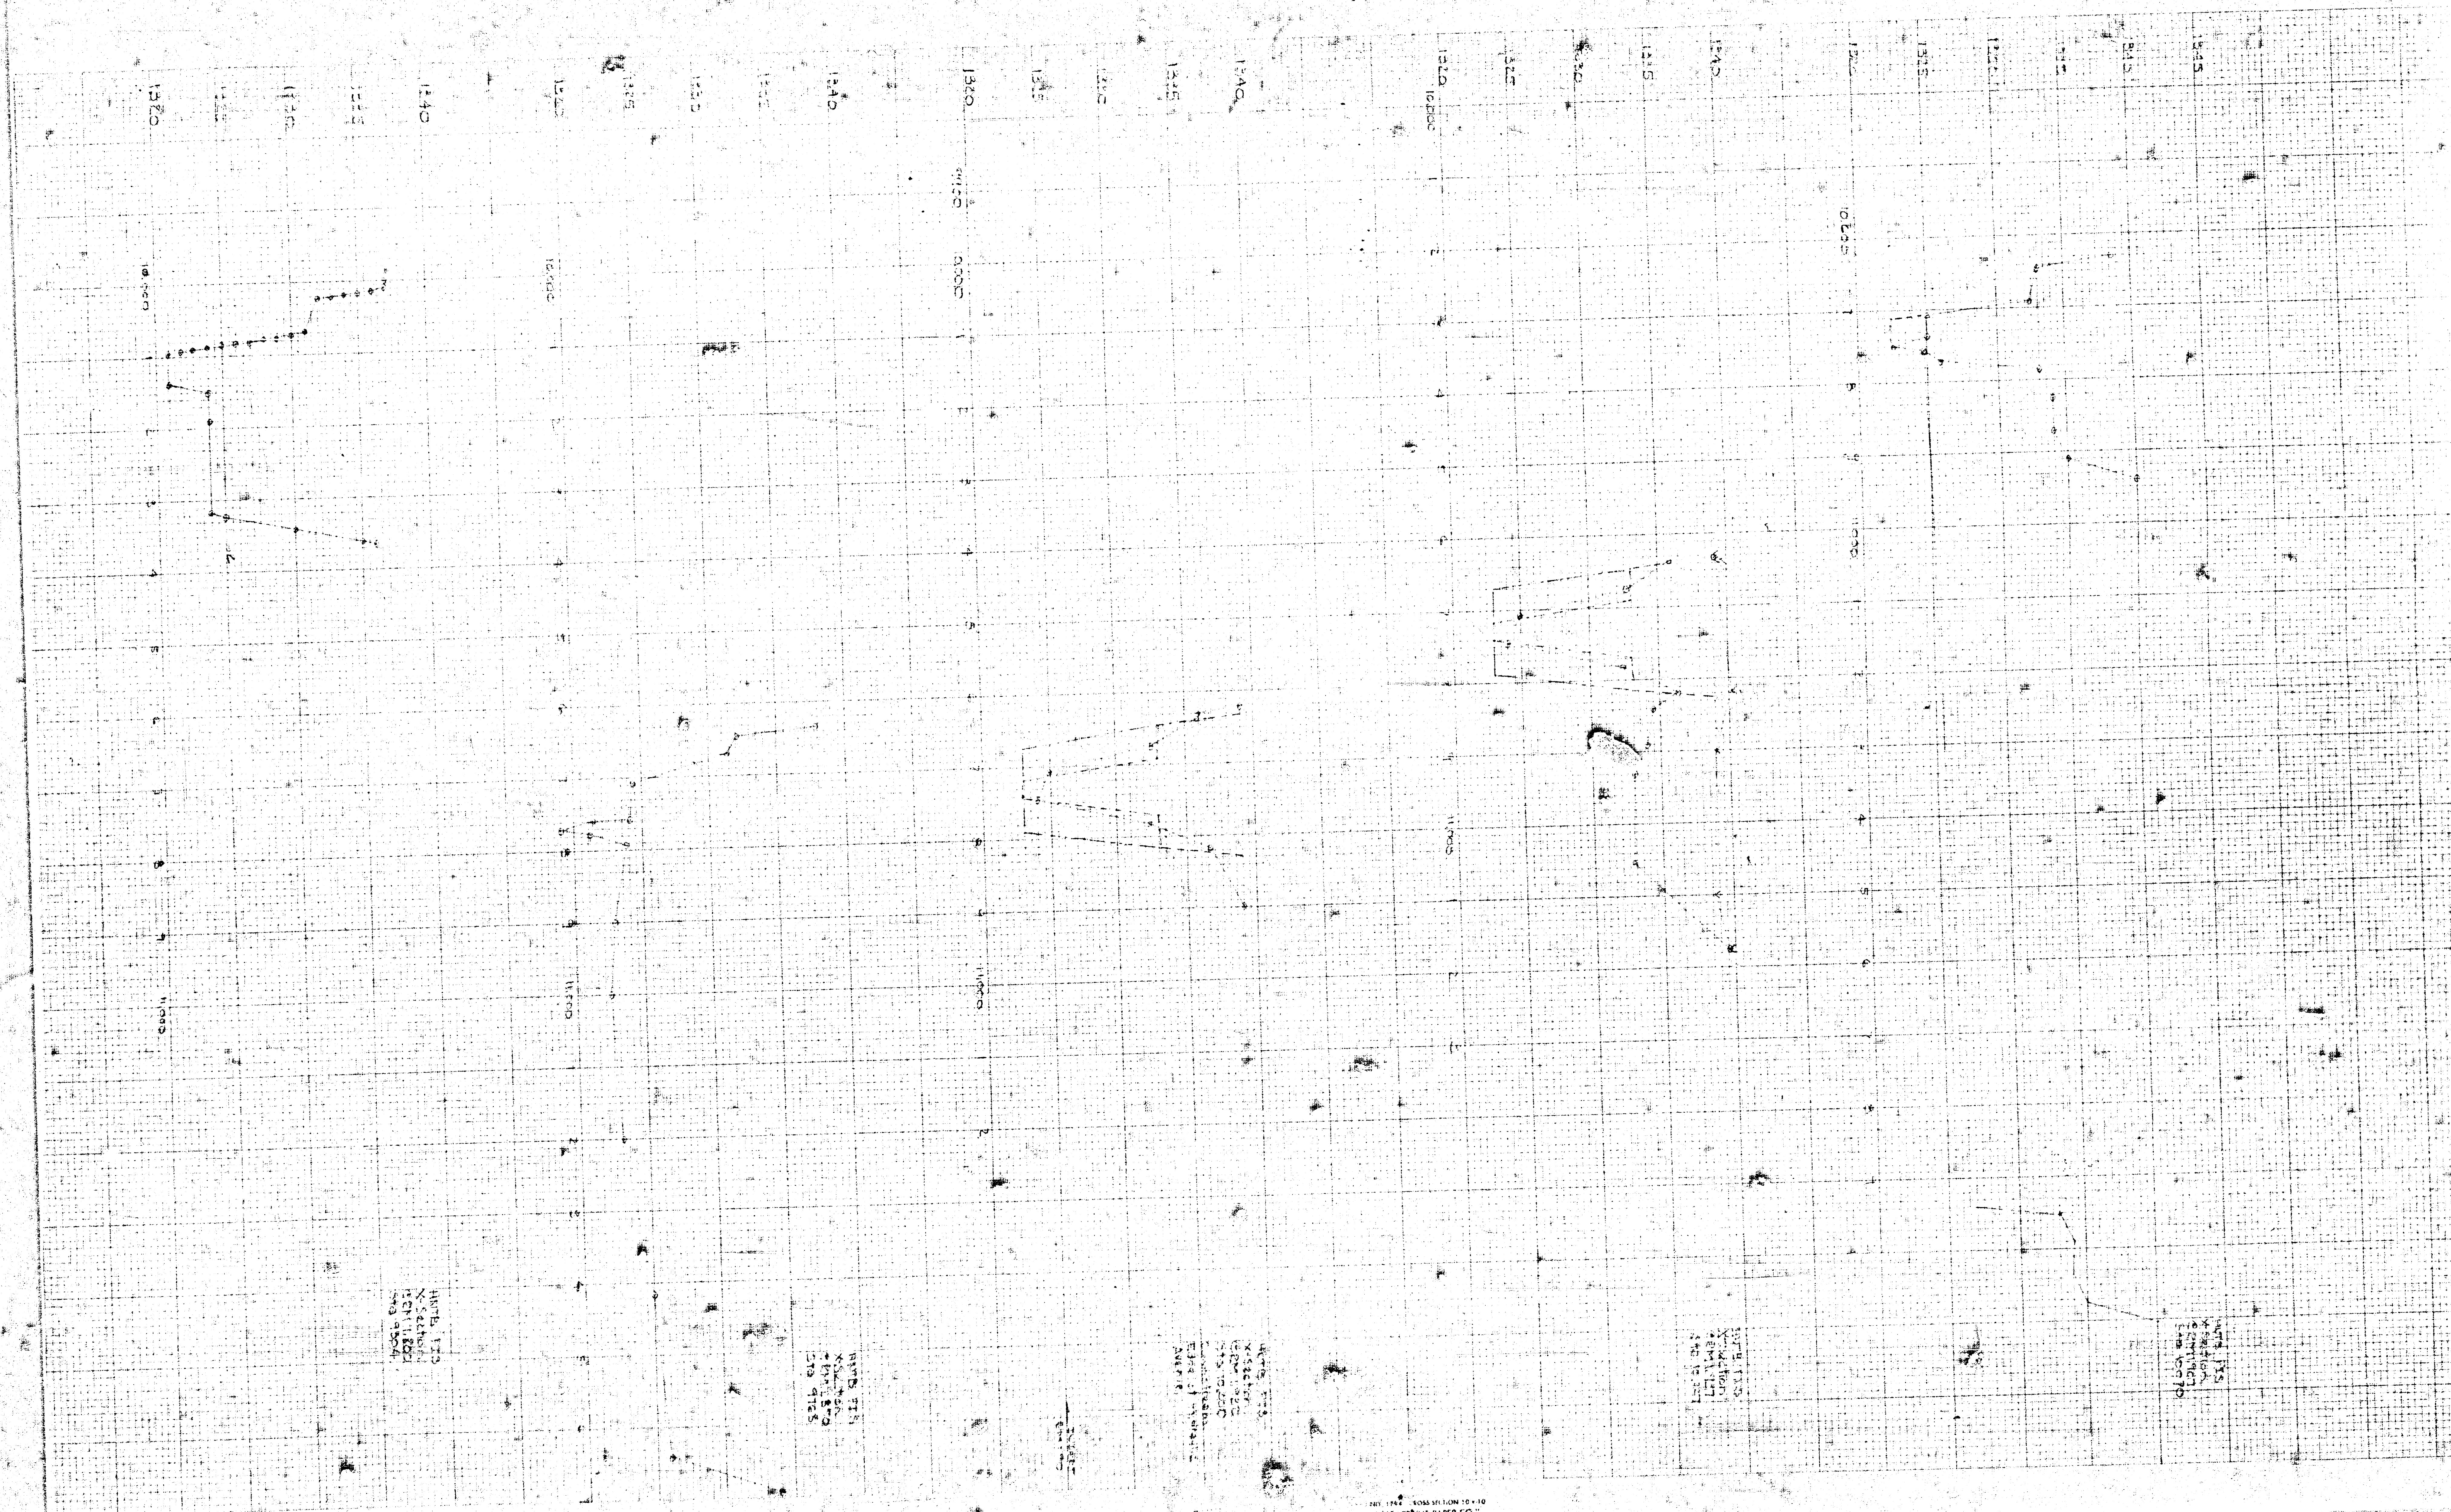


7-11-68
7-11-68

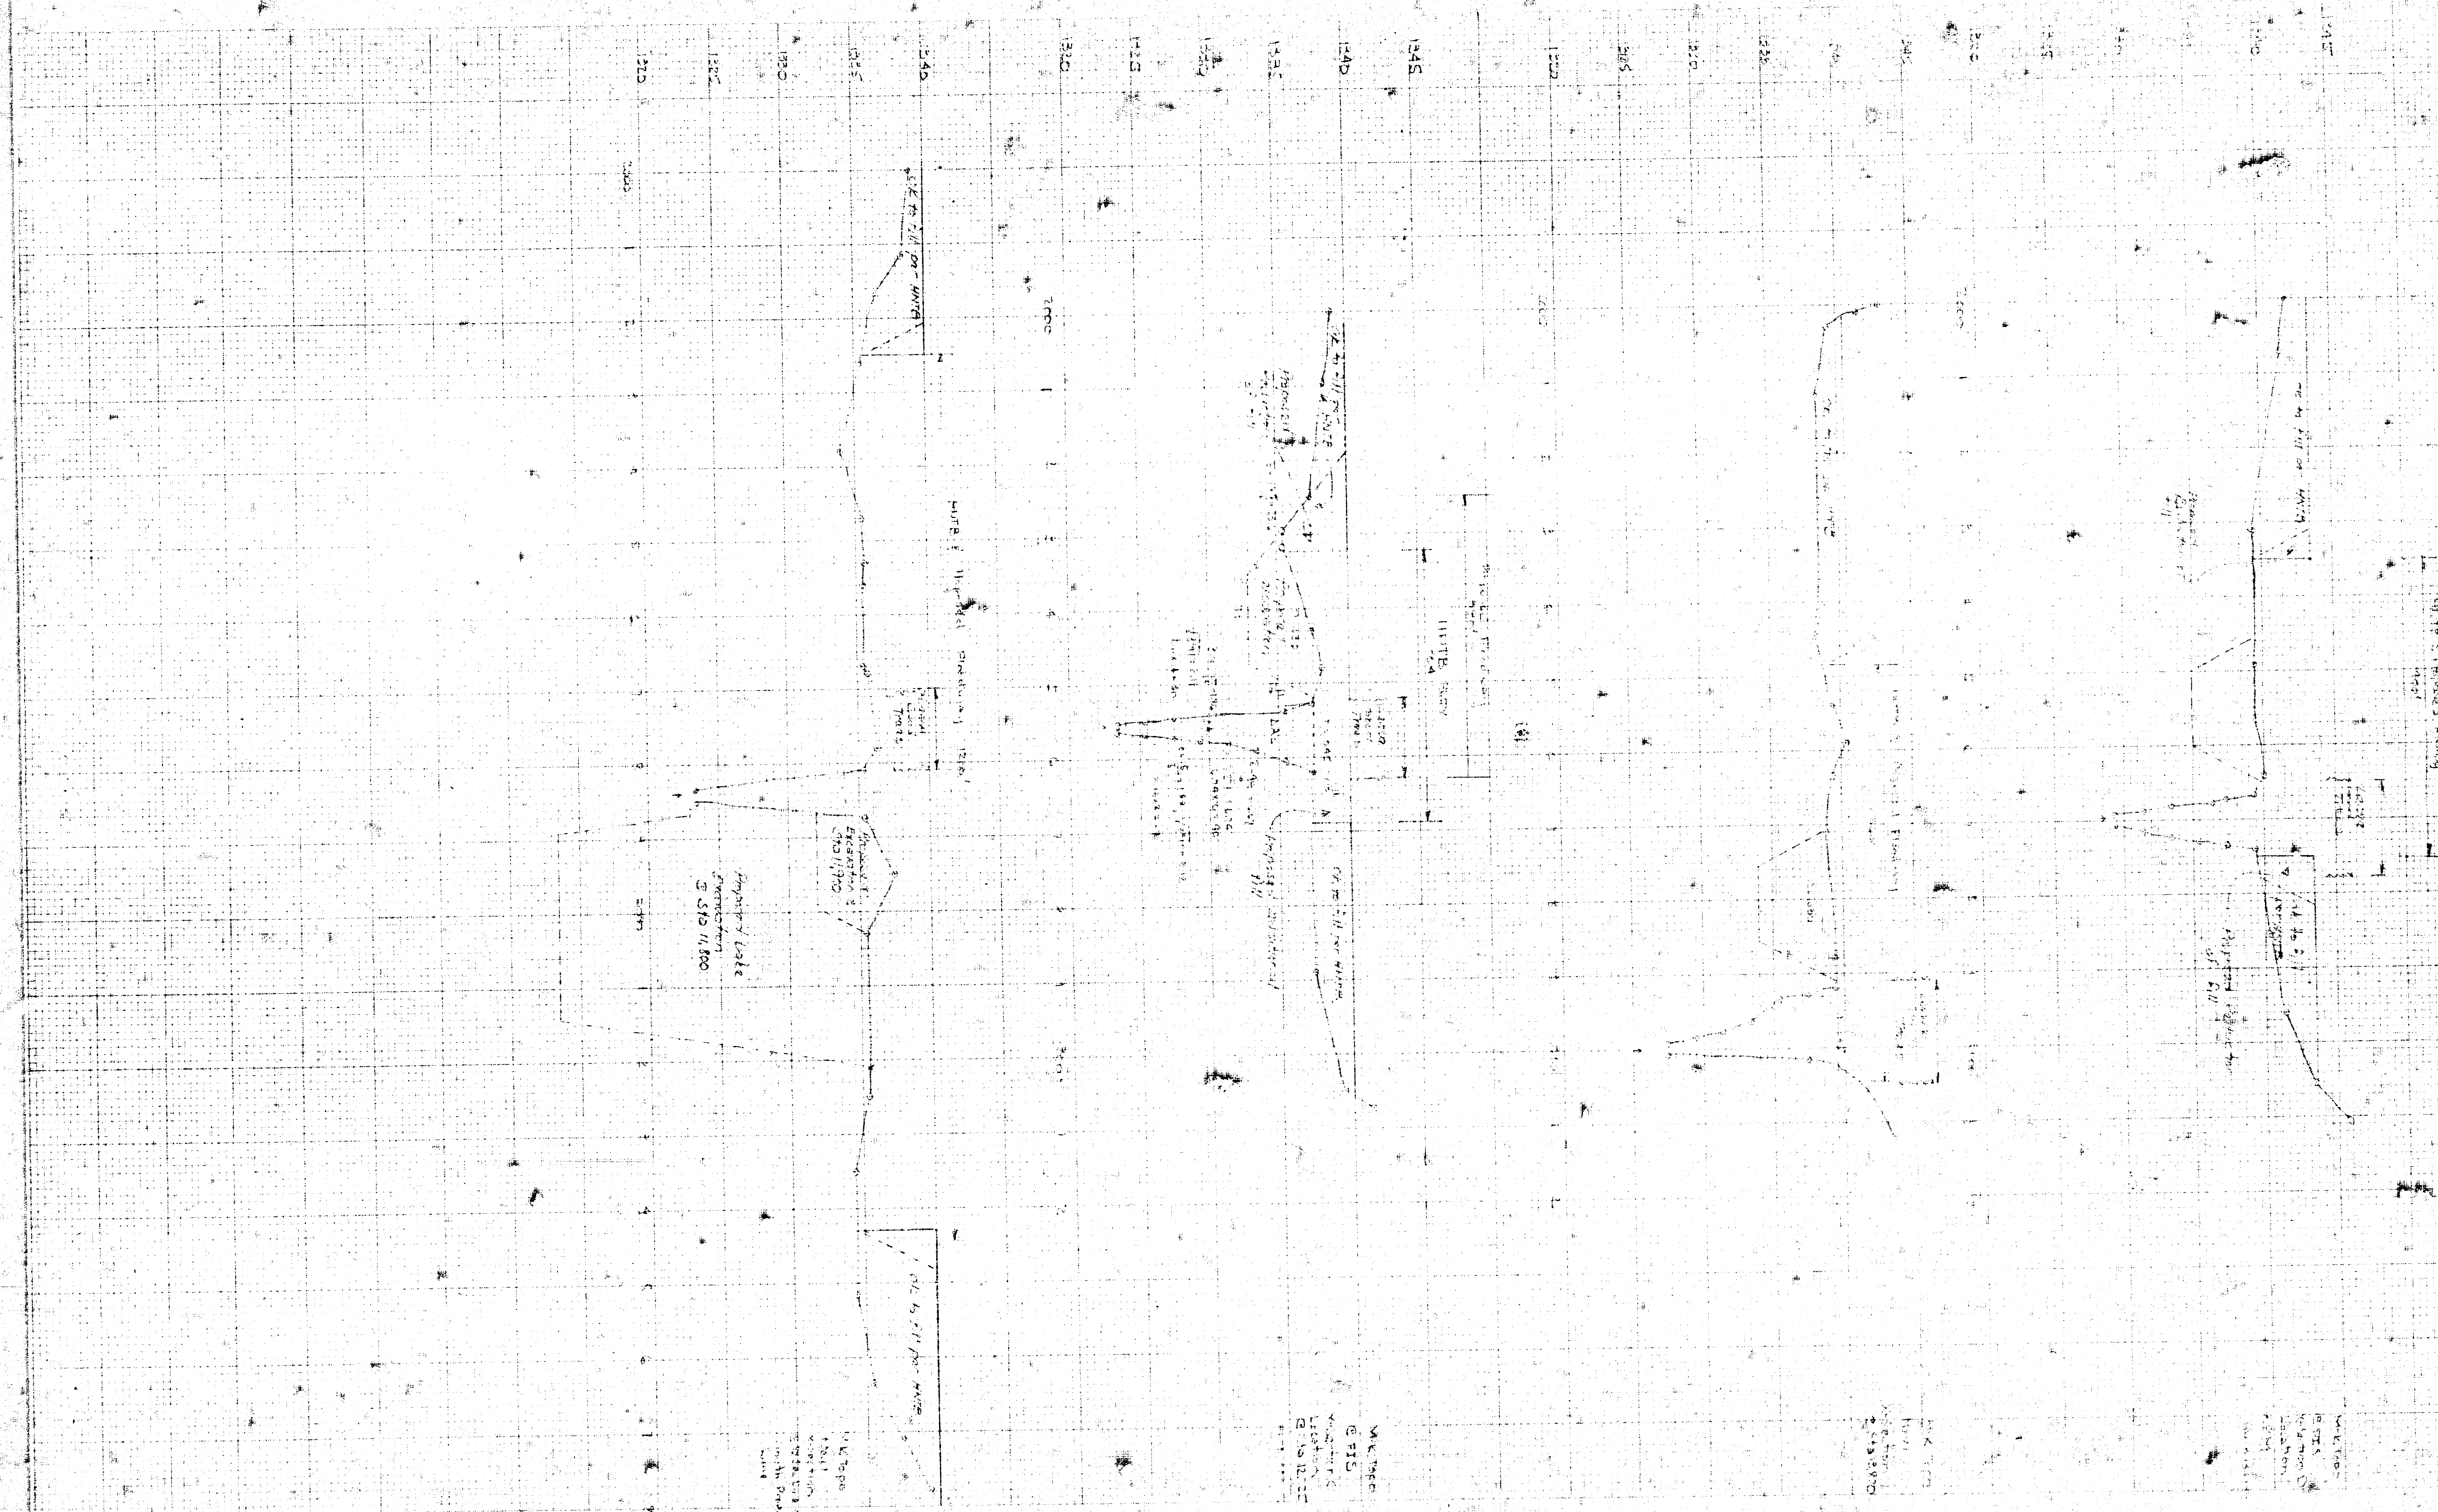

FILMED FROM THE BEST
AVAILABLE COPY

CHISHOLM CREEK COMMERCE CENTER
(DRAINAGE)

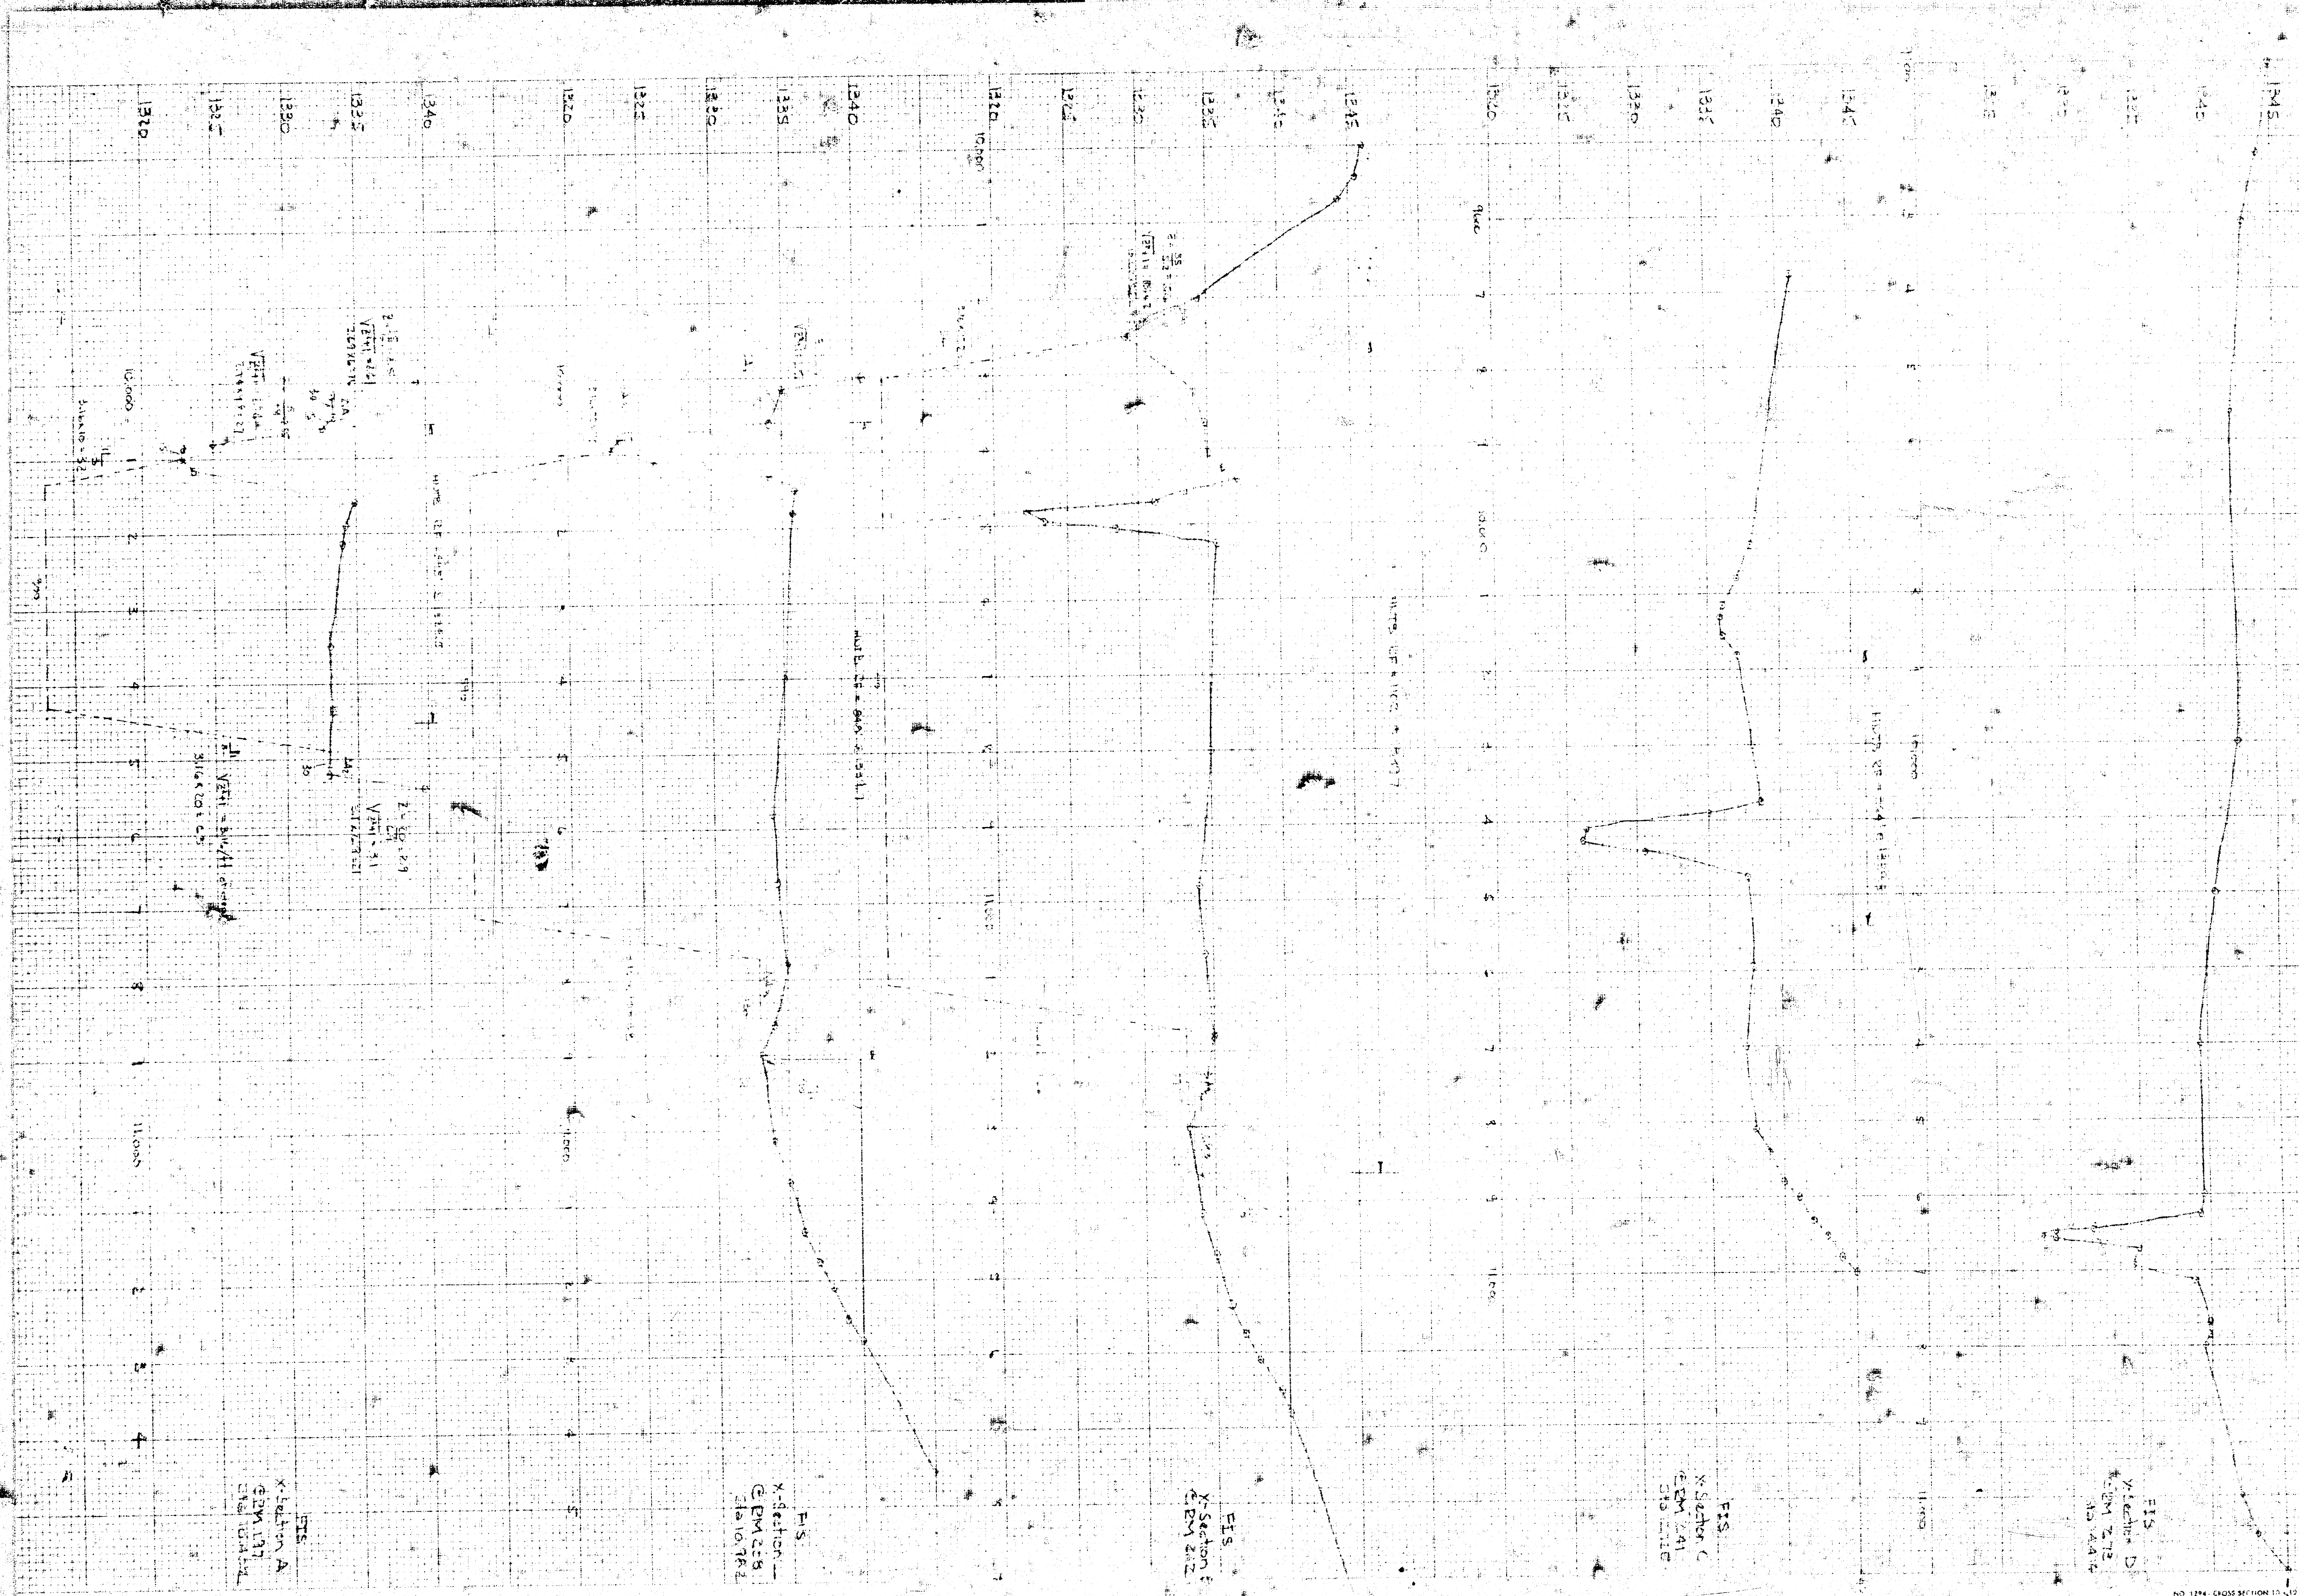

**FILMED FROM THE BEST
AVAILABLE COPY.....**