


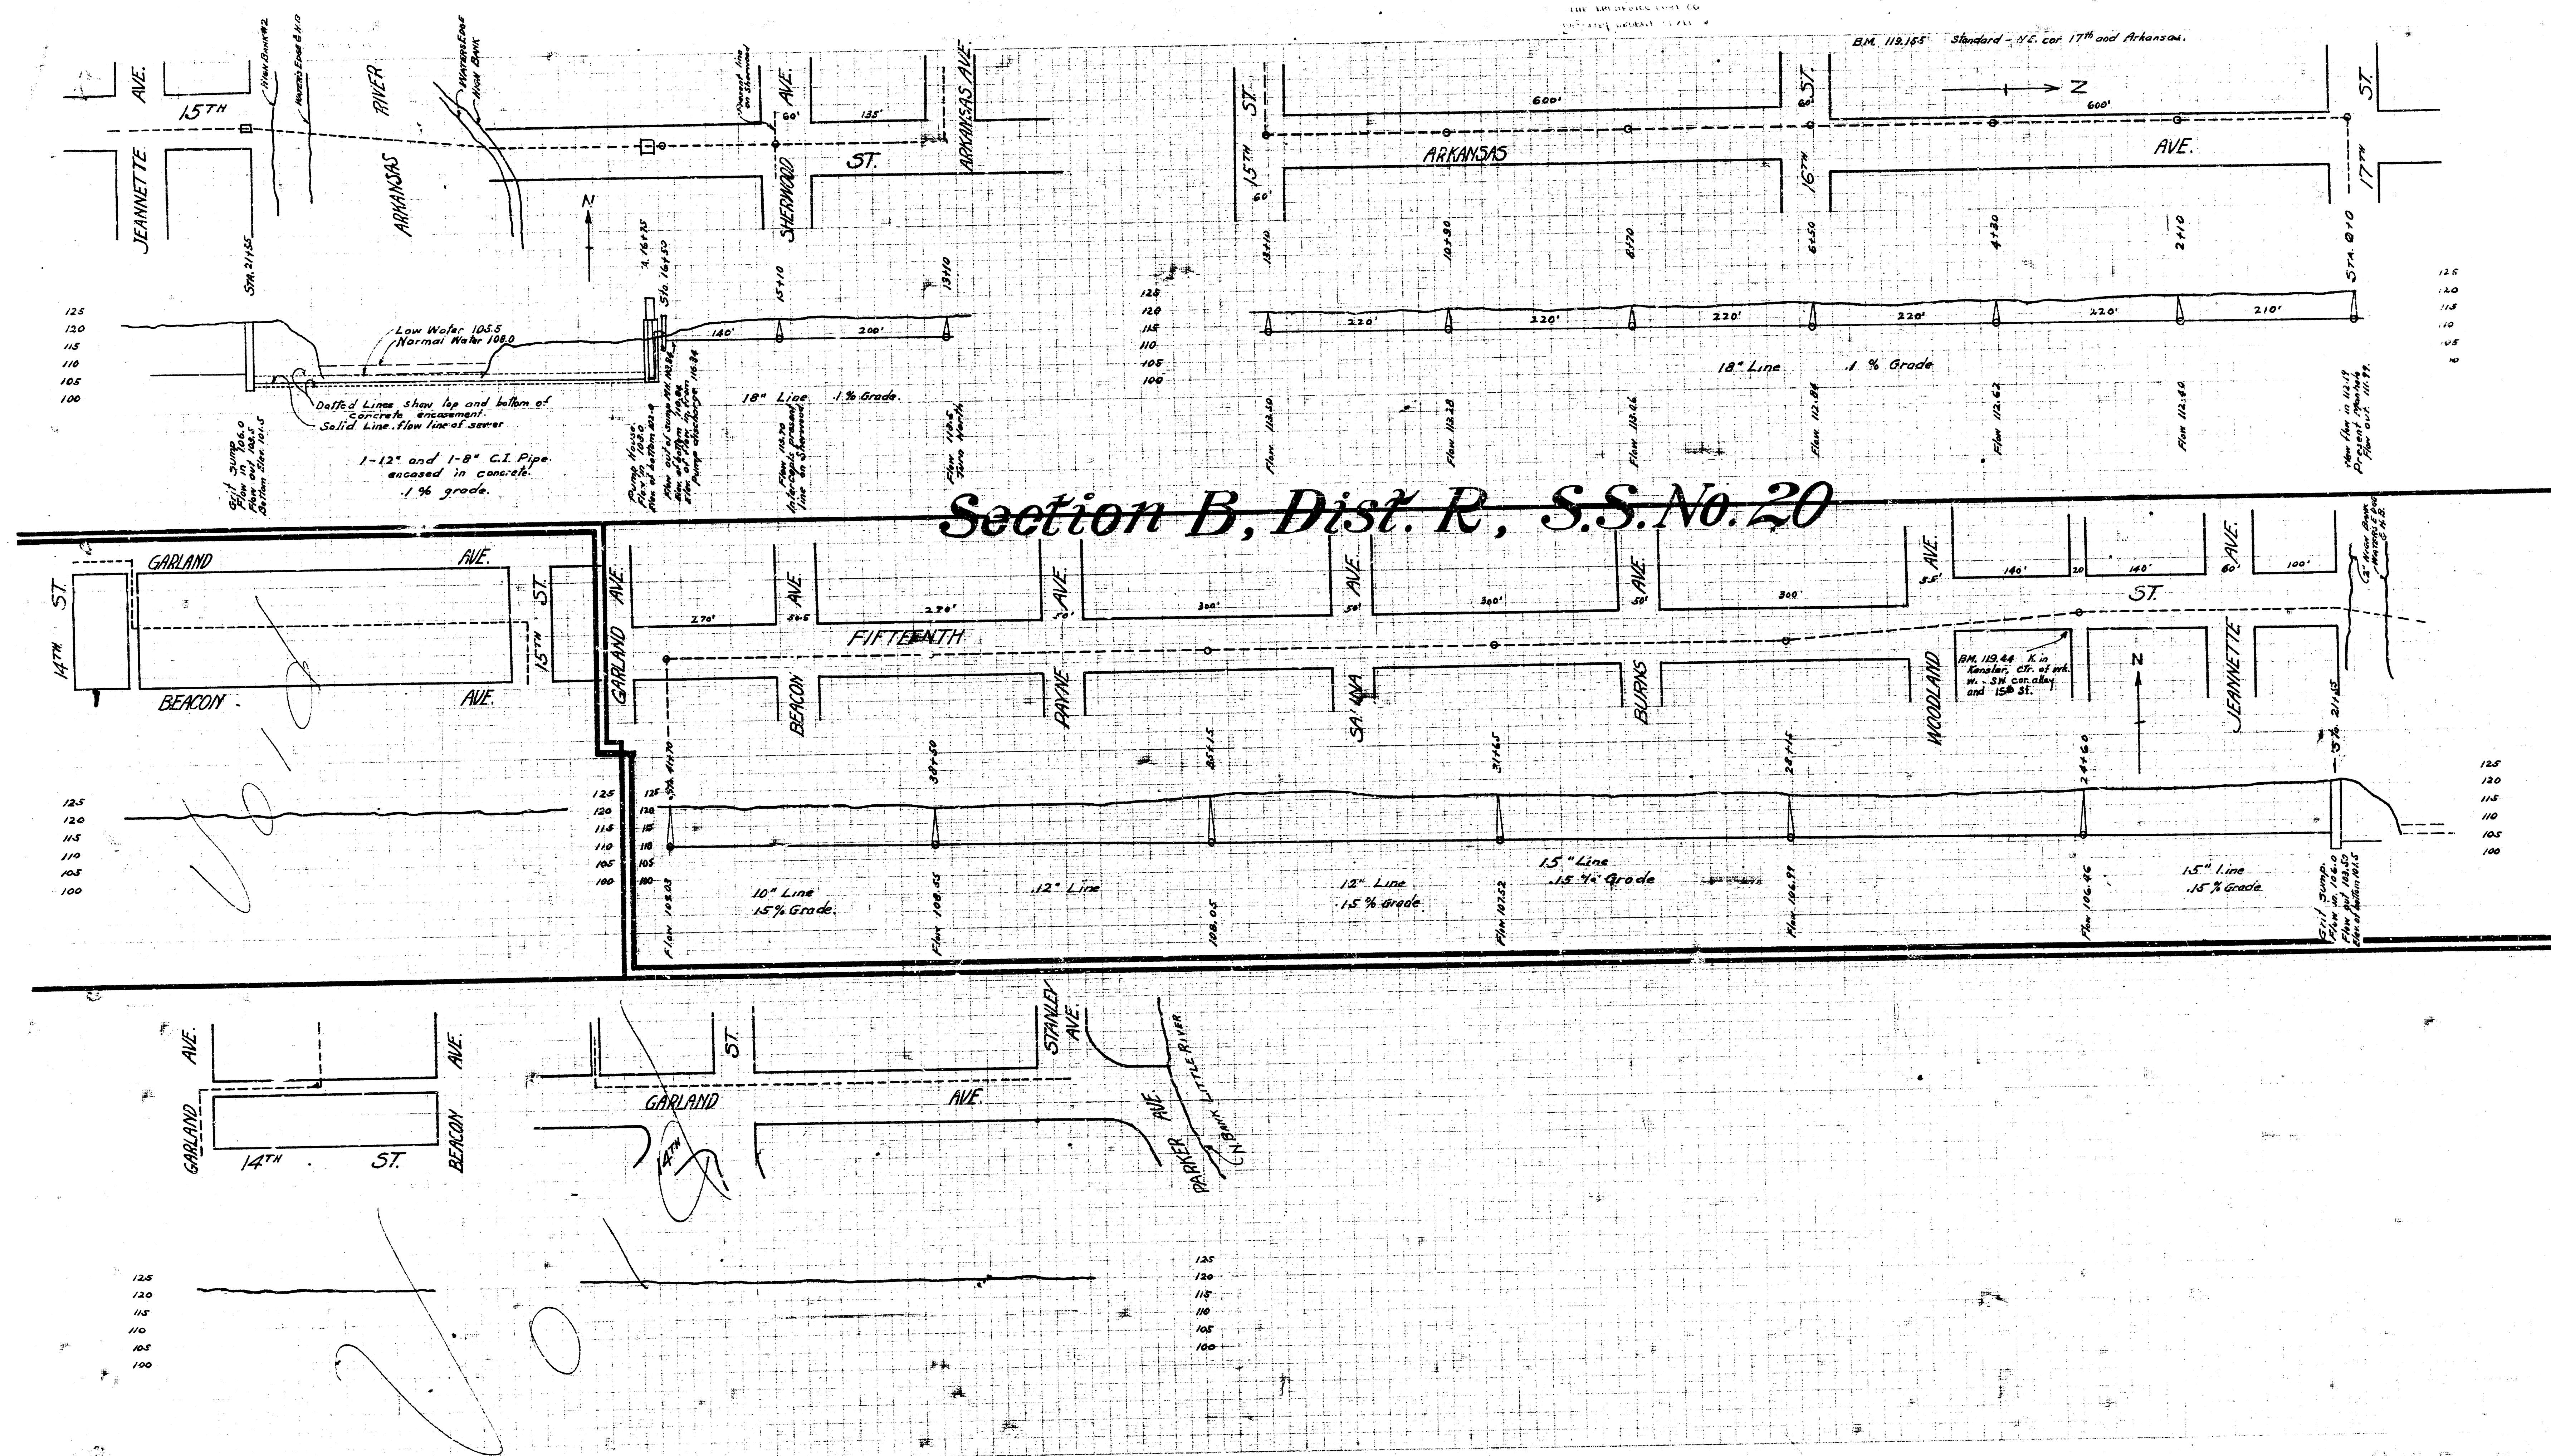


[illegible]


Typical Door Section


Section of Doorway
Scale: 1" = 1'-0"


POWER LAYOUT
SCHEMATIC 11A" x 140"

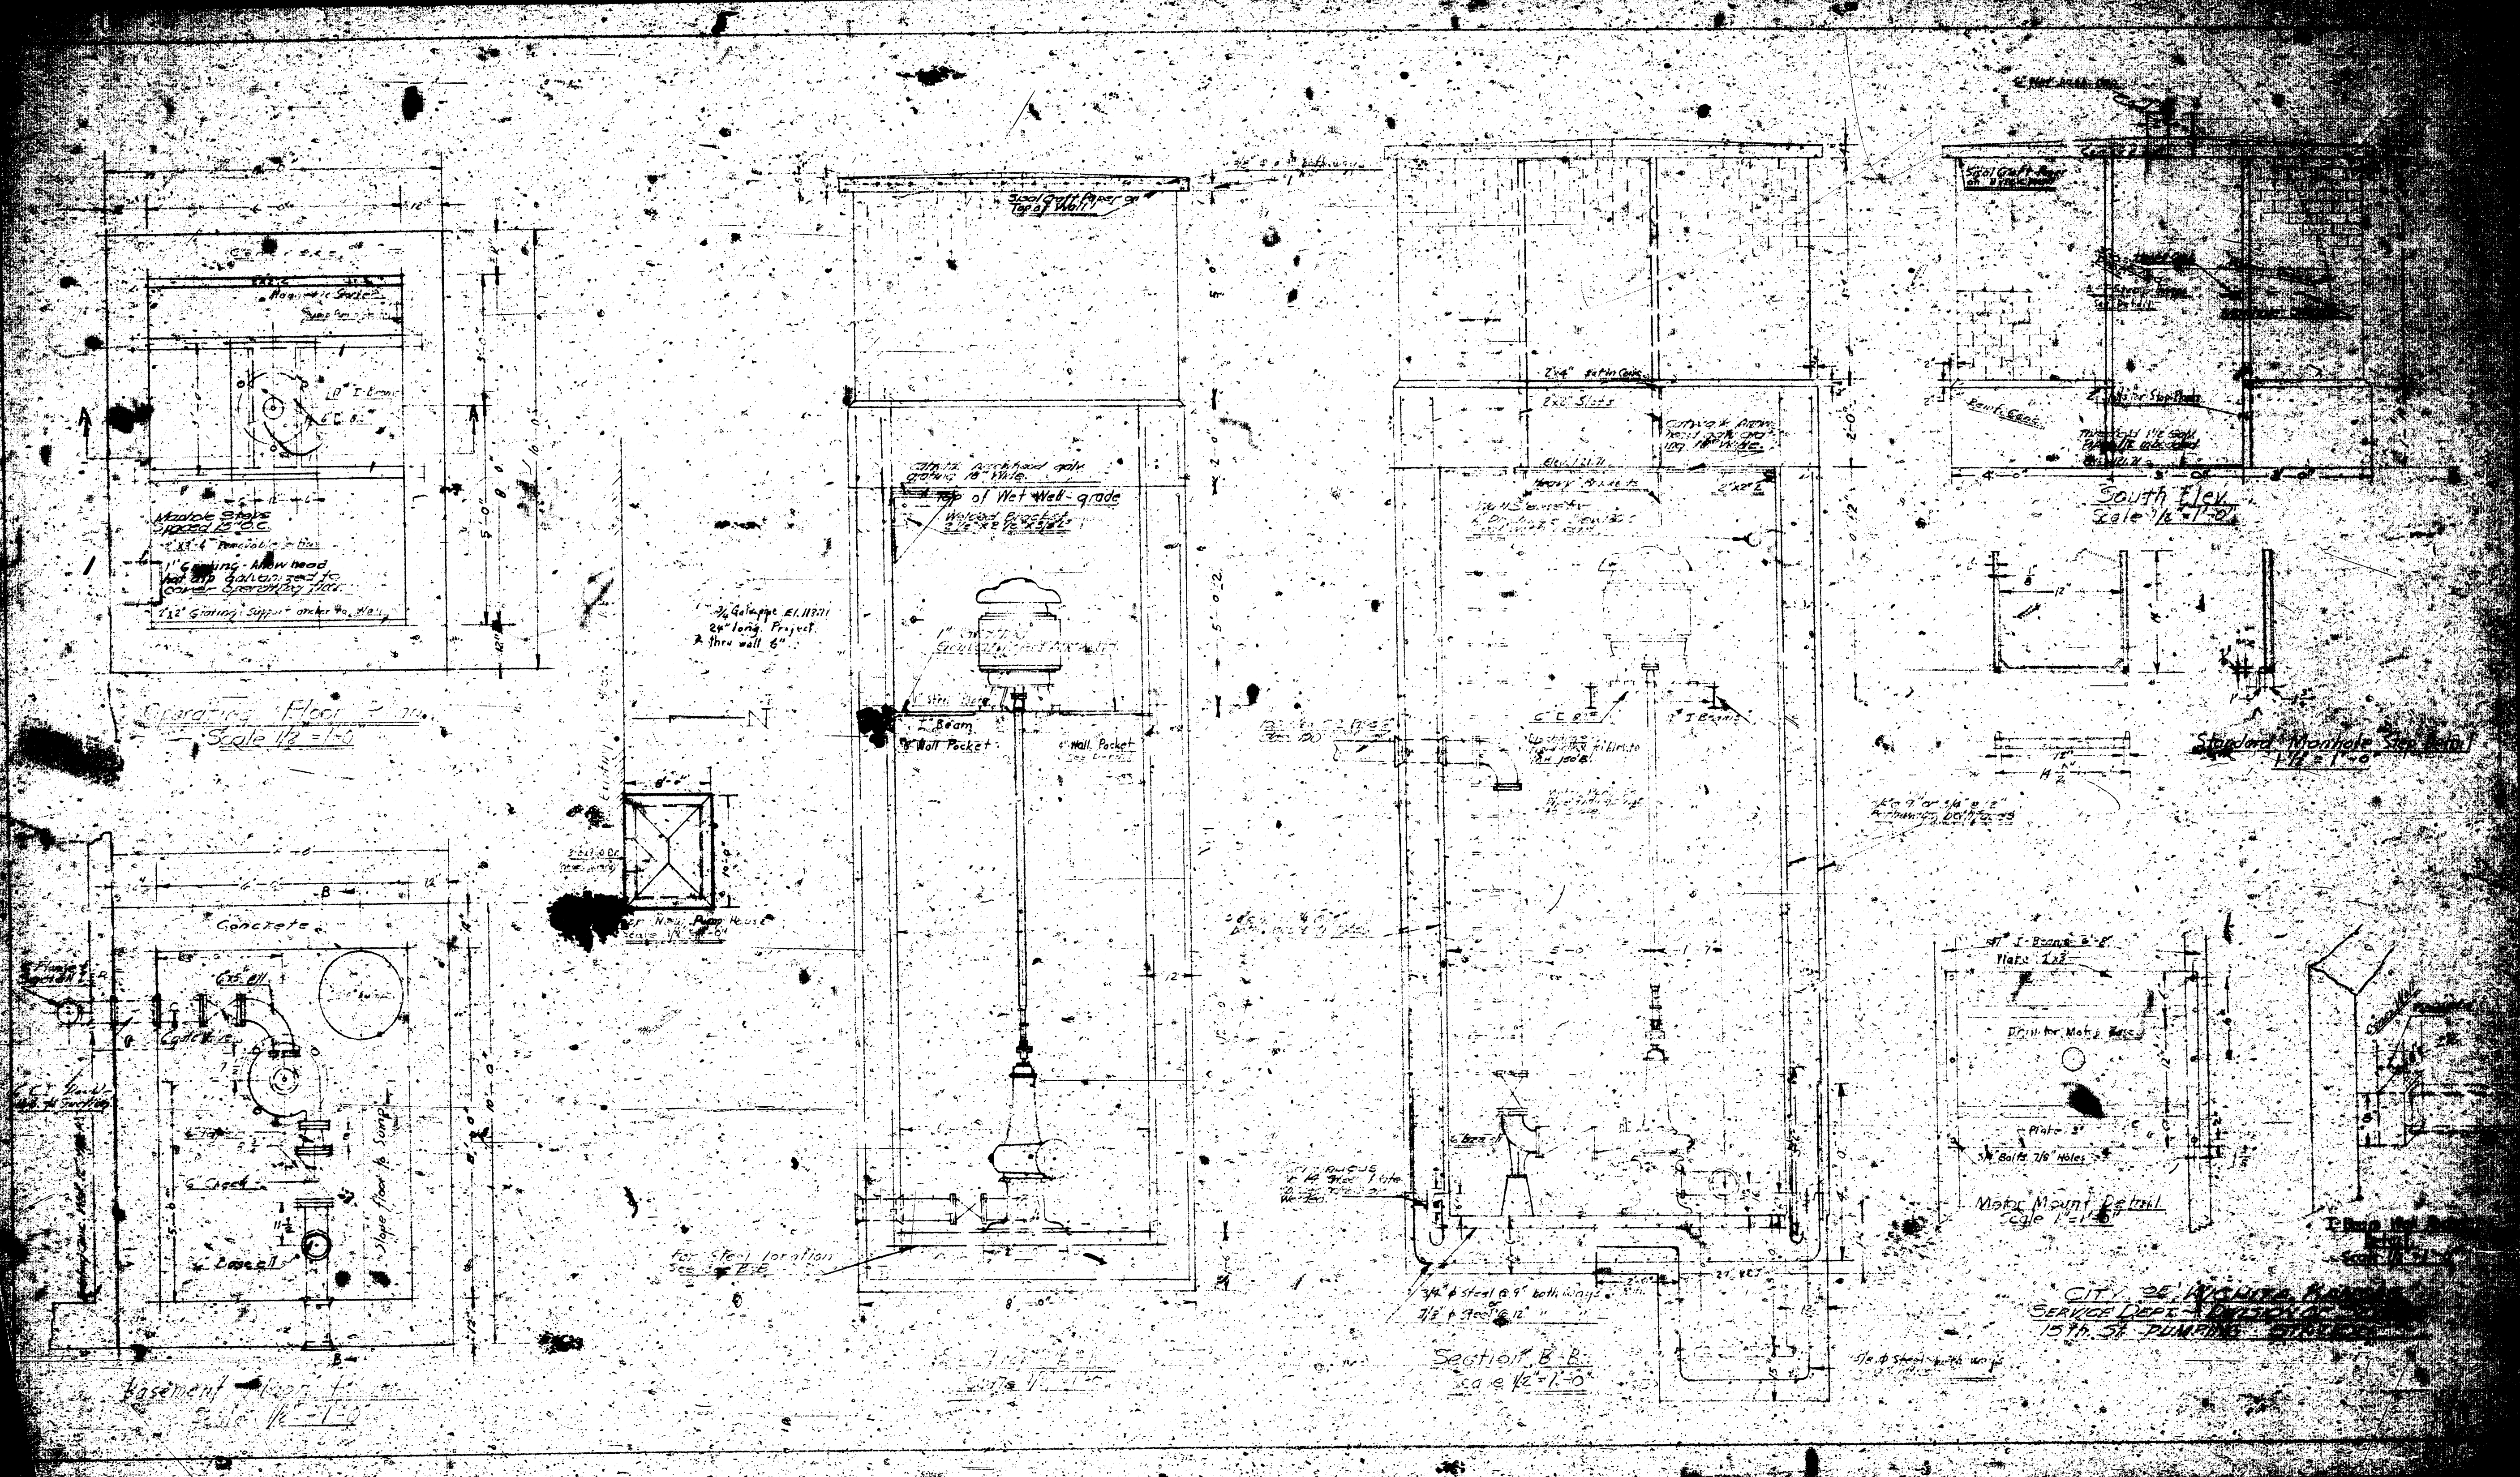


CITY OF WICHITA, KANSAS
SERVICE DEPT. DIVISION OF ENGINEERS
12th ST. PUMPING STATION

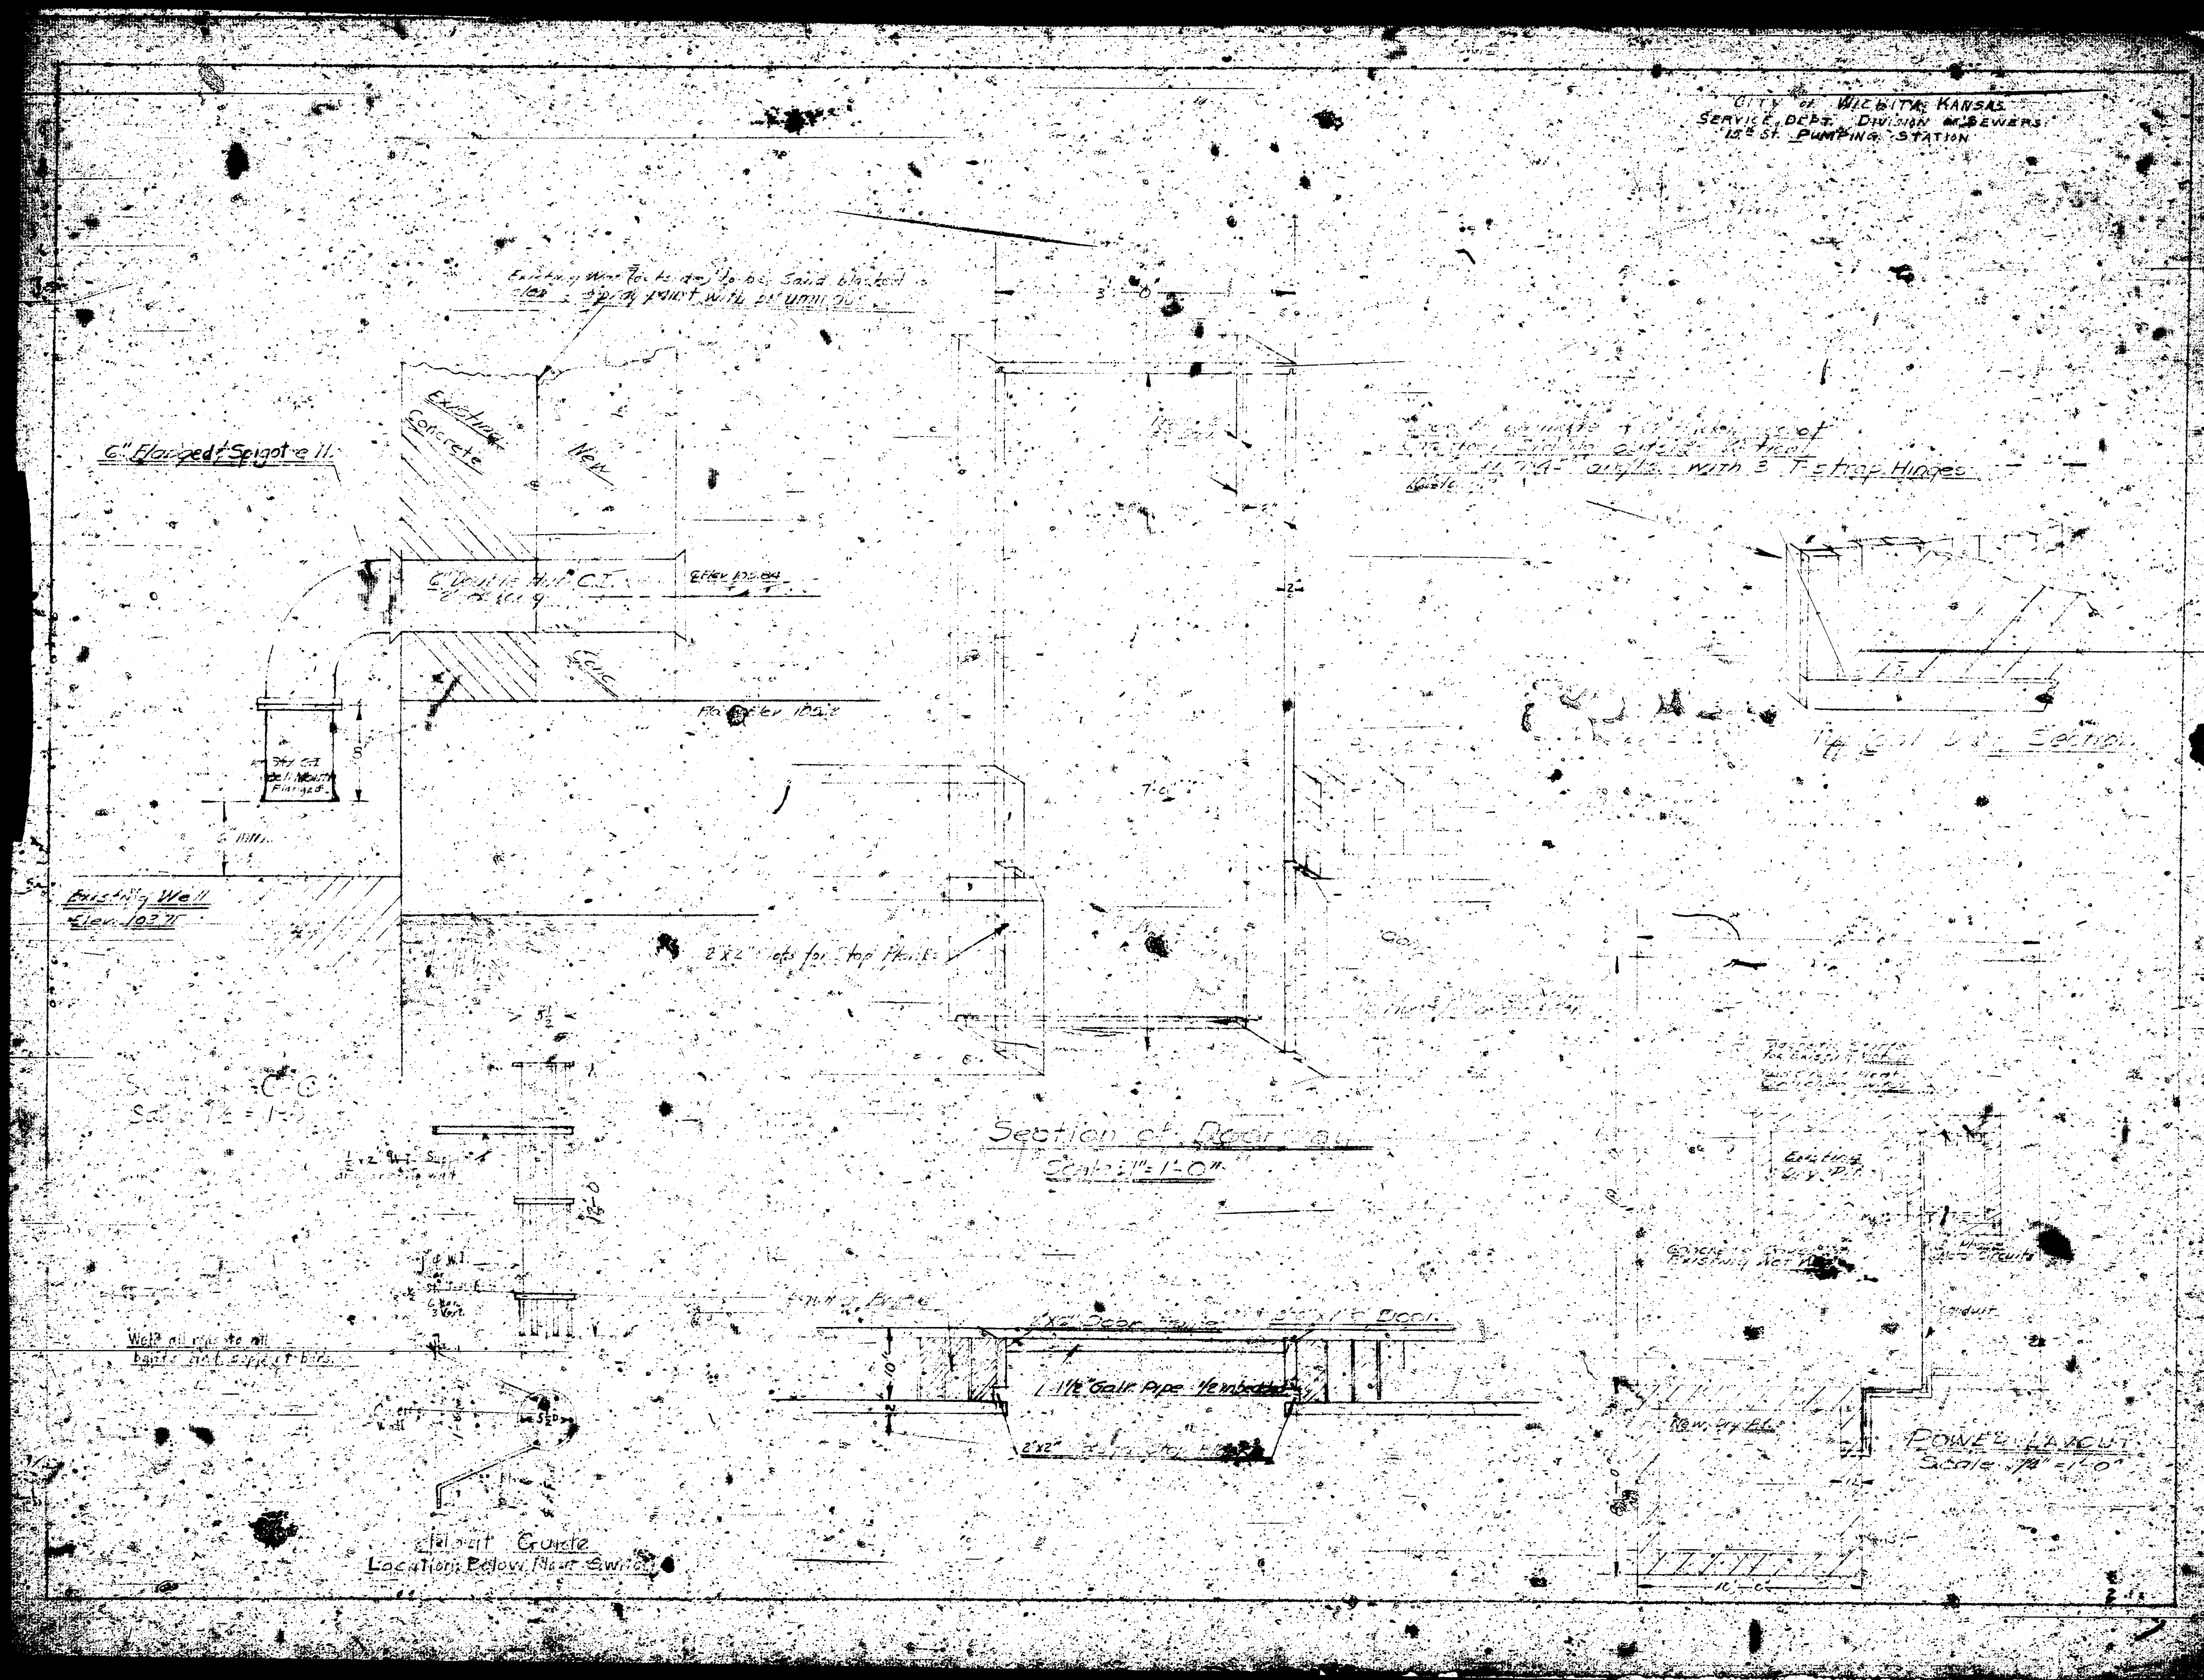

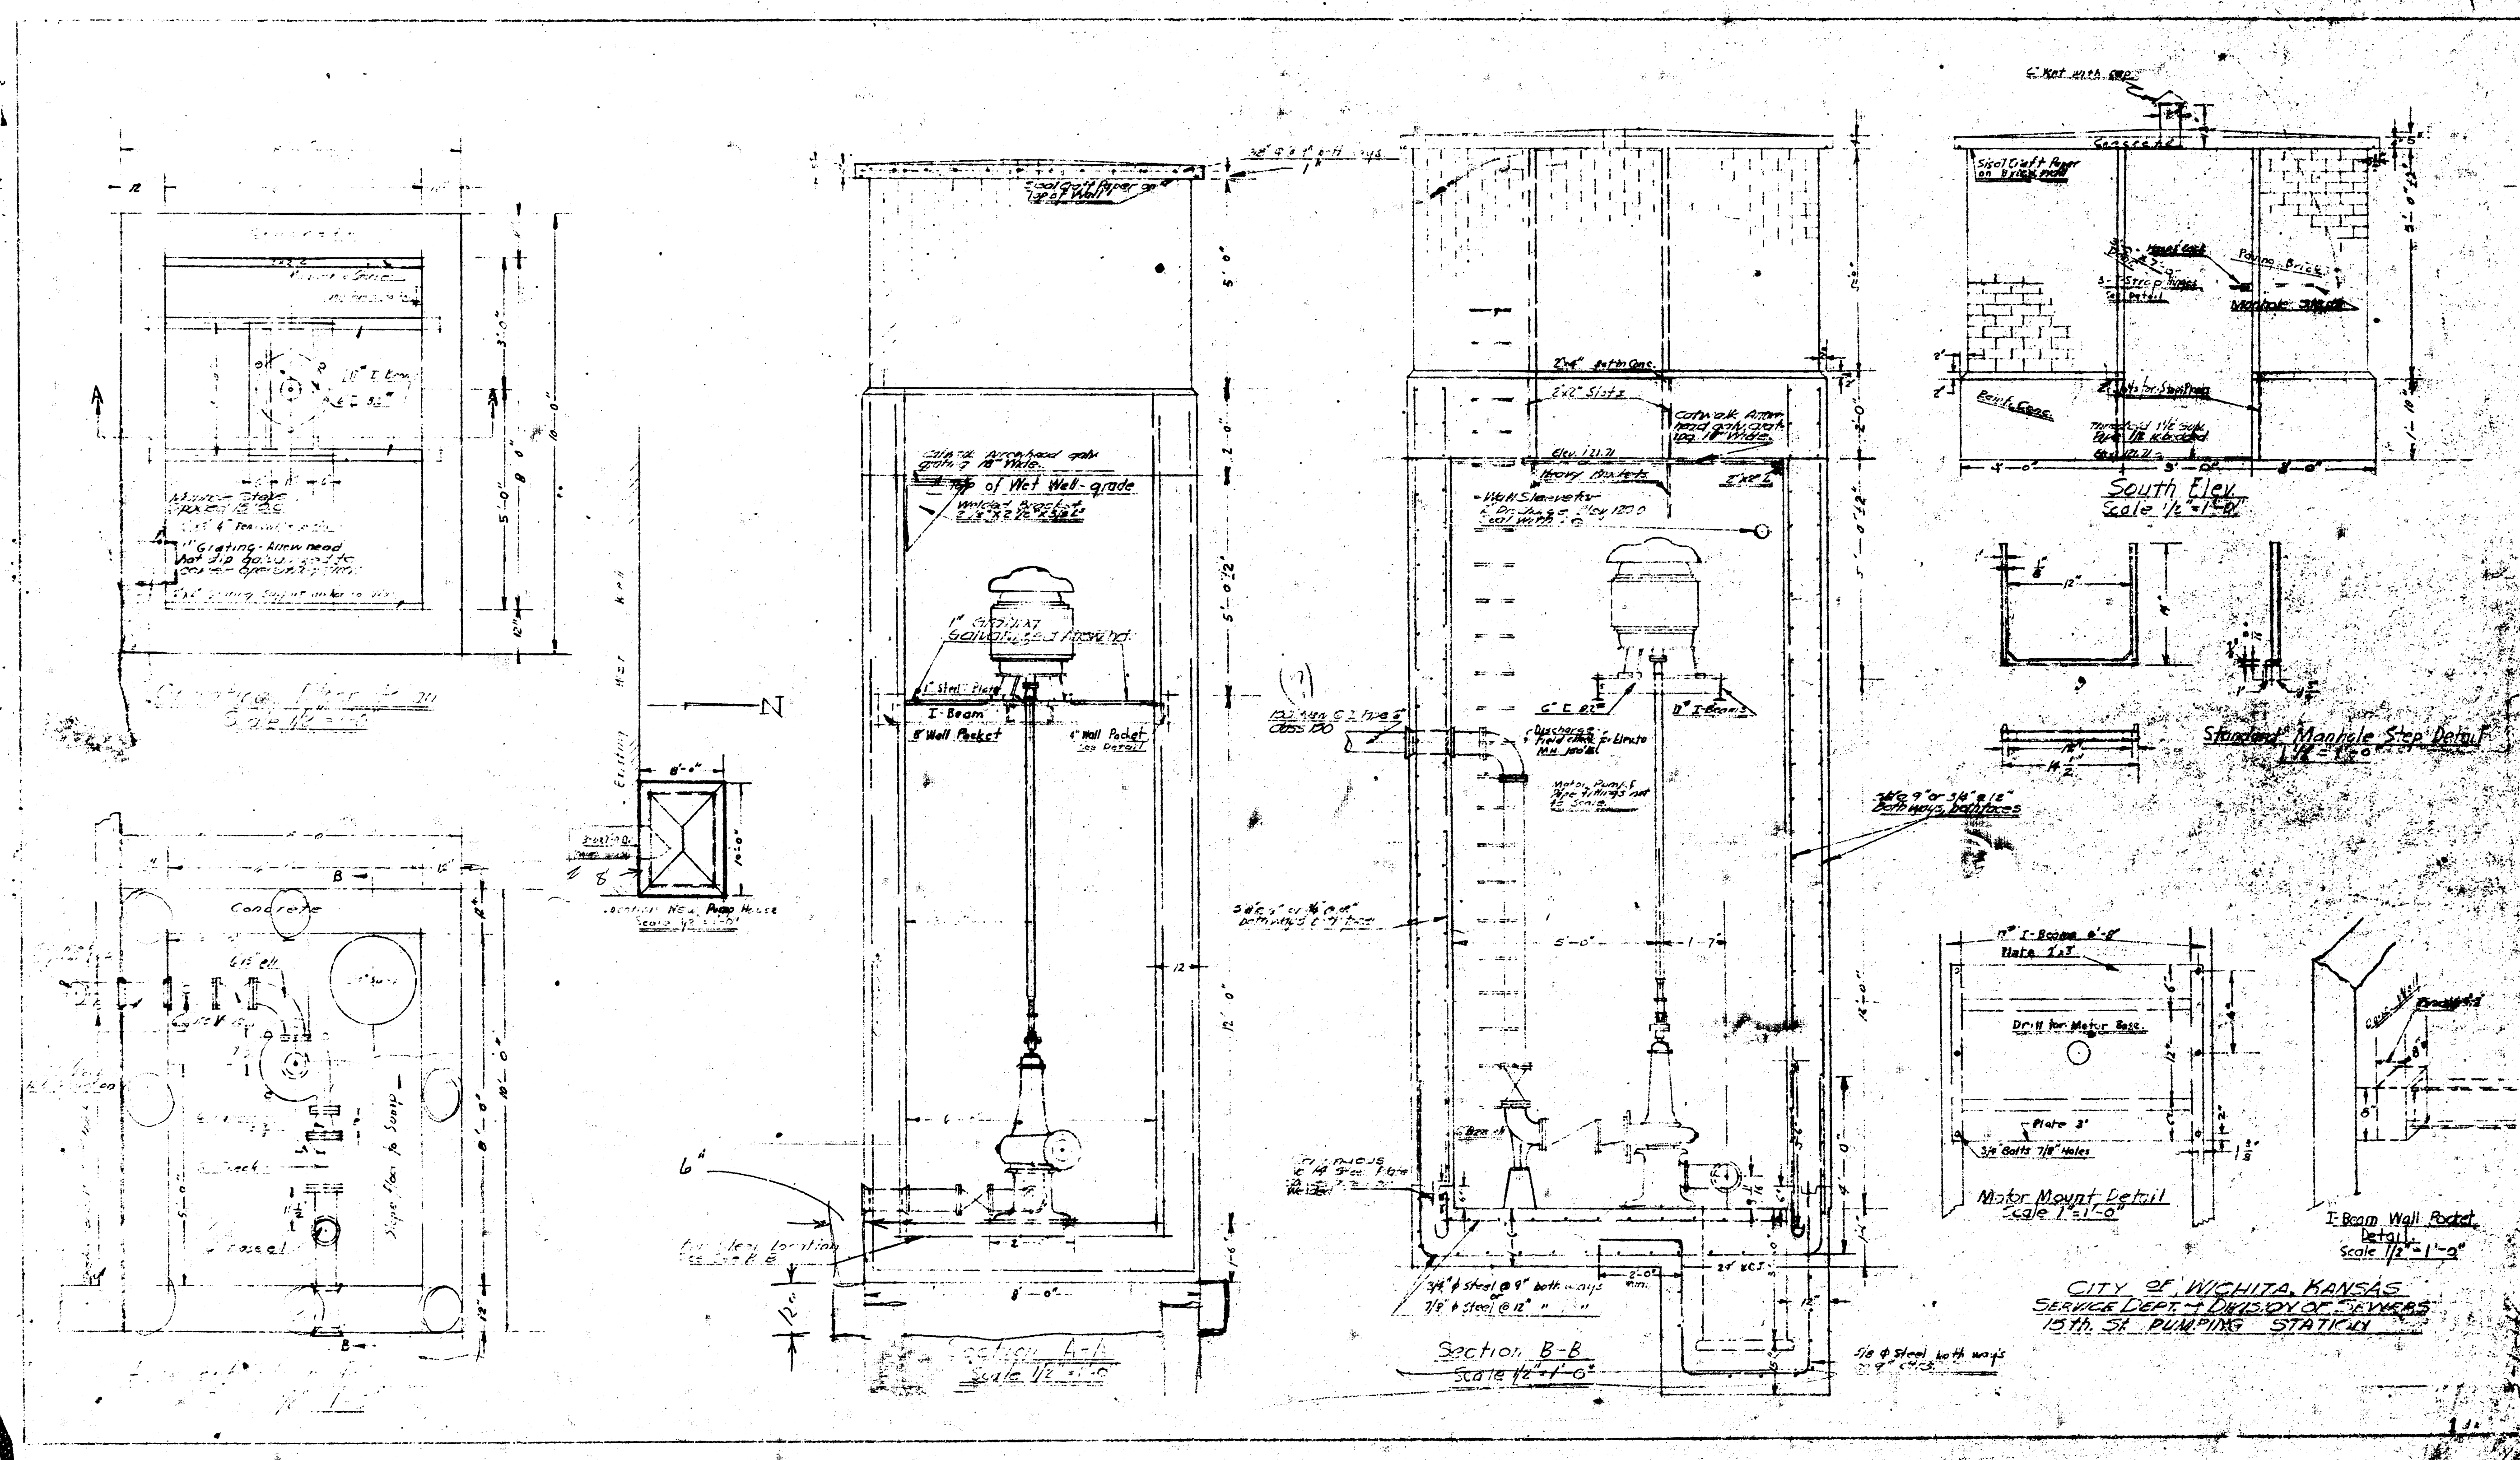


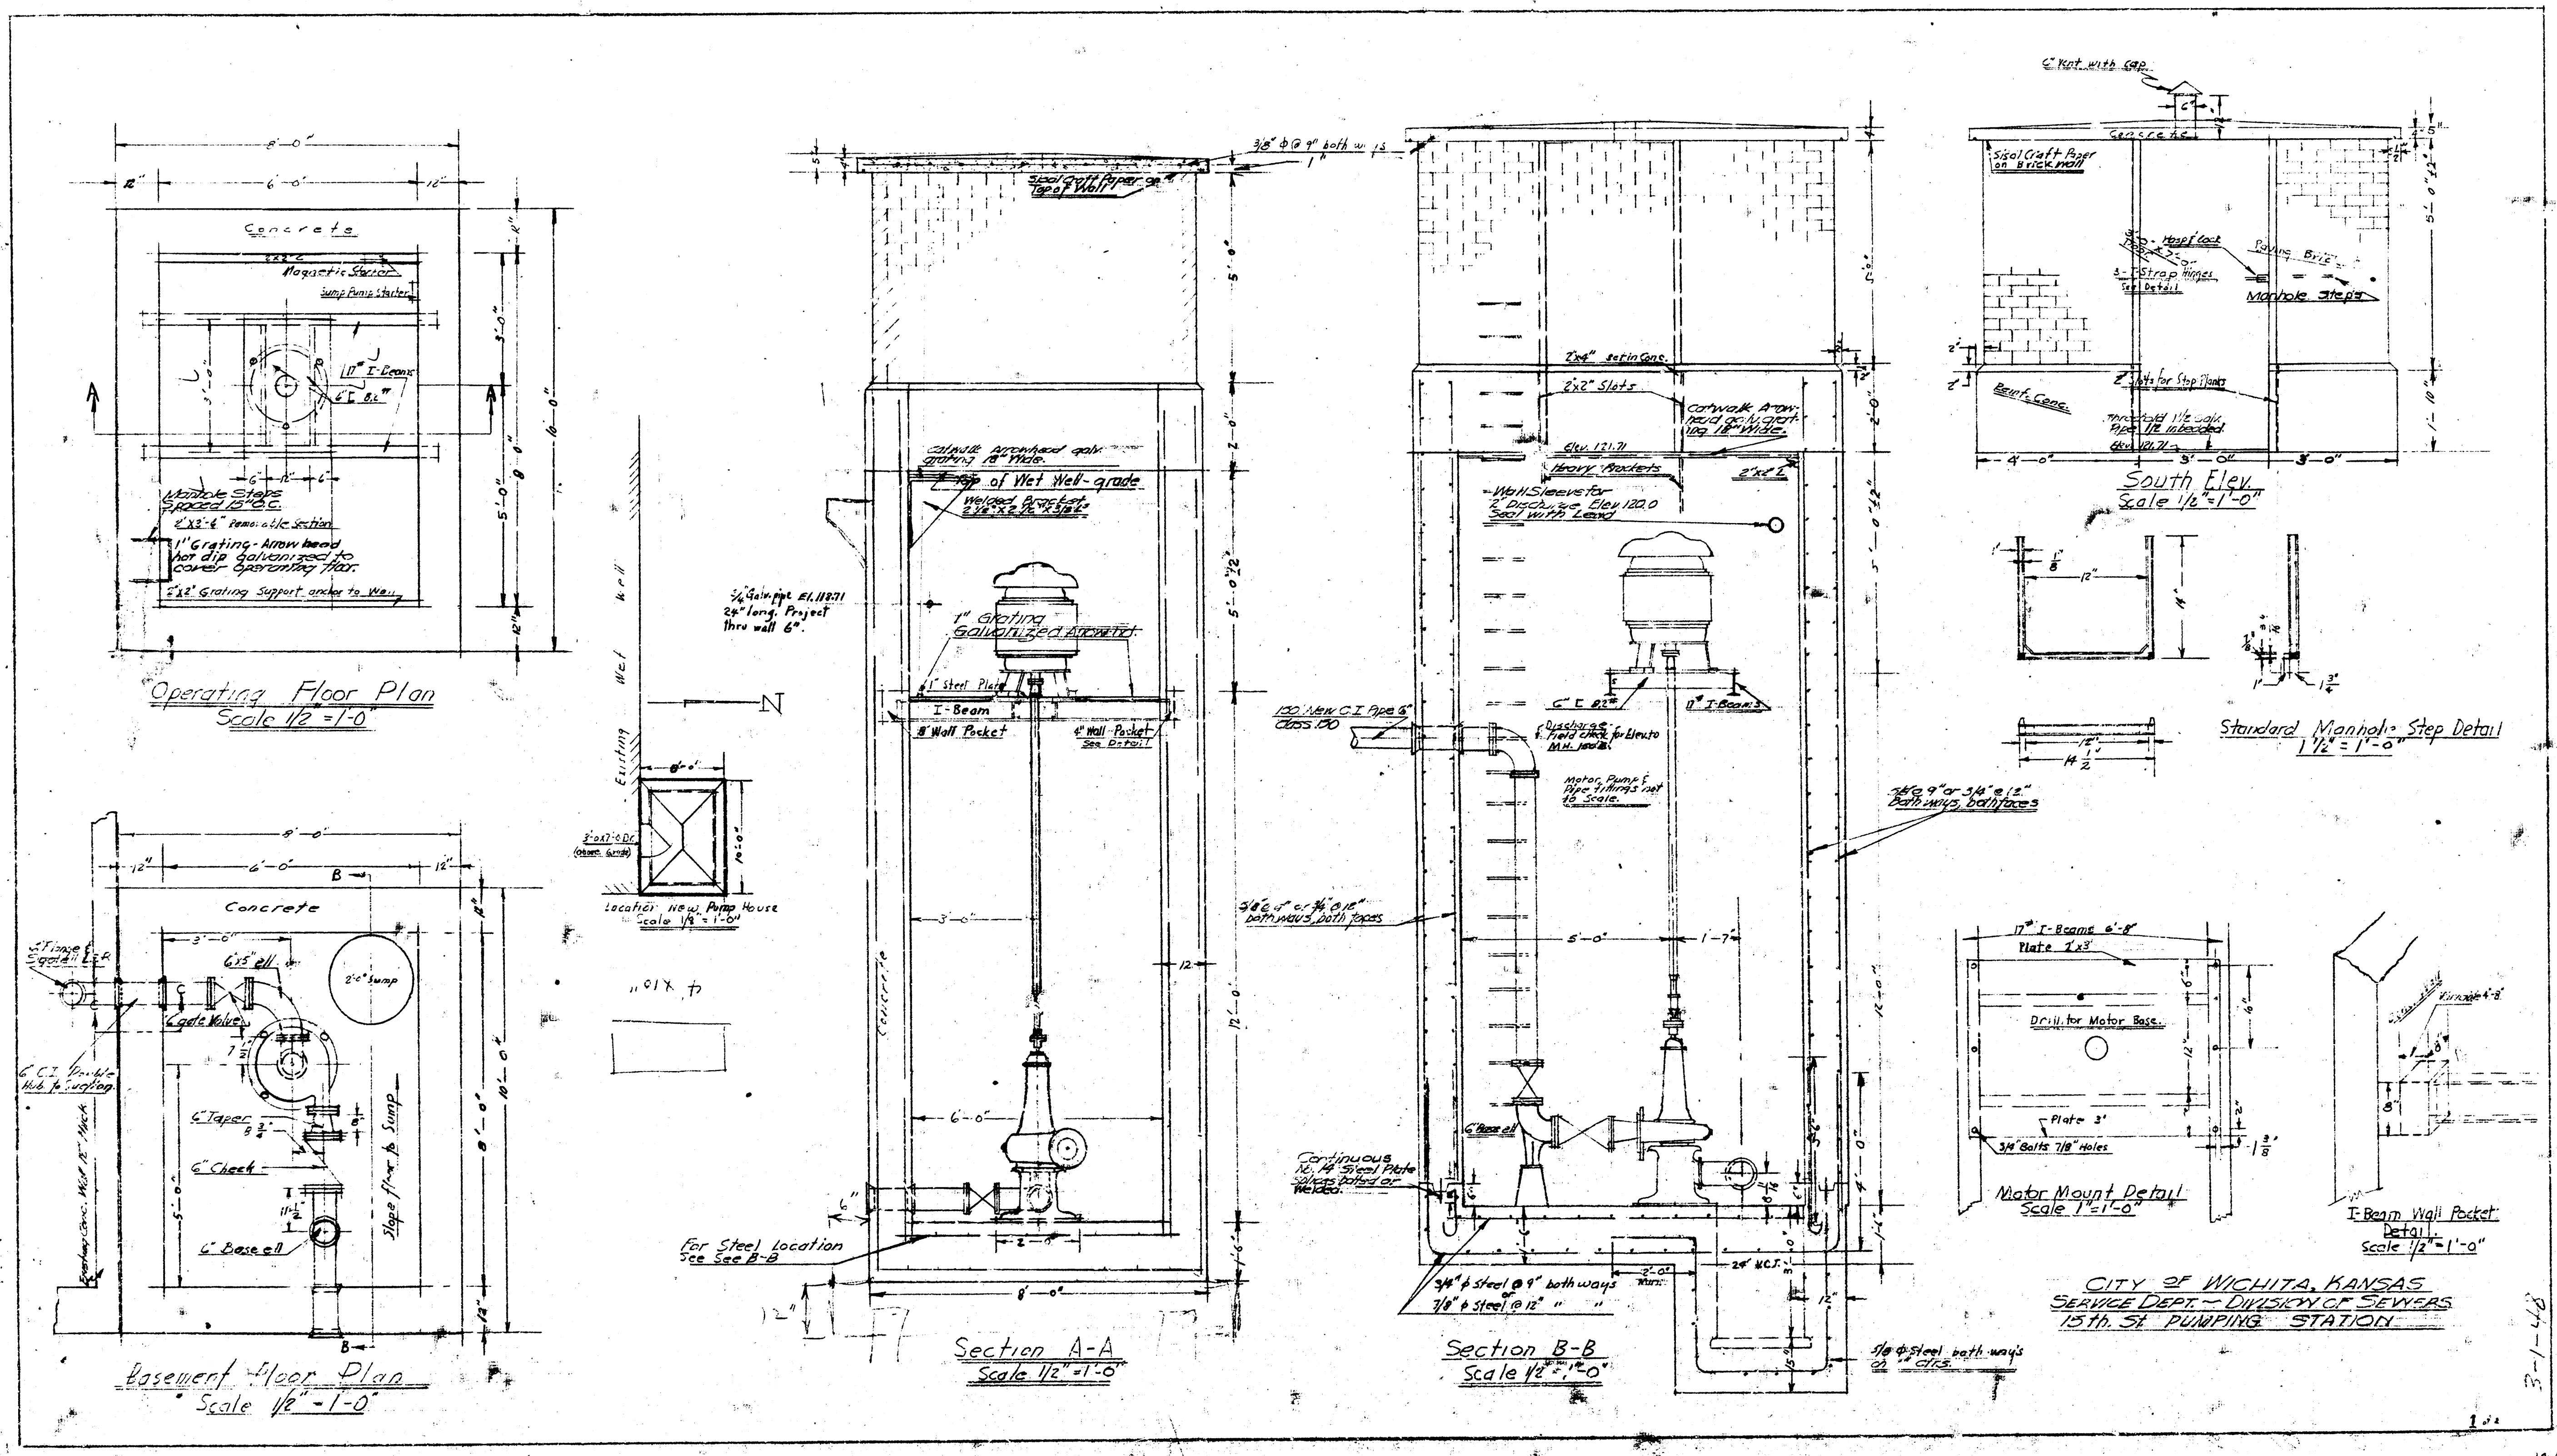

CITY OF WICHITA, KANSAS
SERVICE DEPT. DIVISION OF SEWERS
18th ST. PUMPING STATION

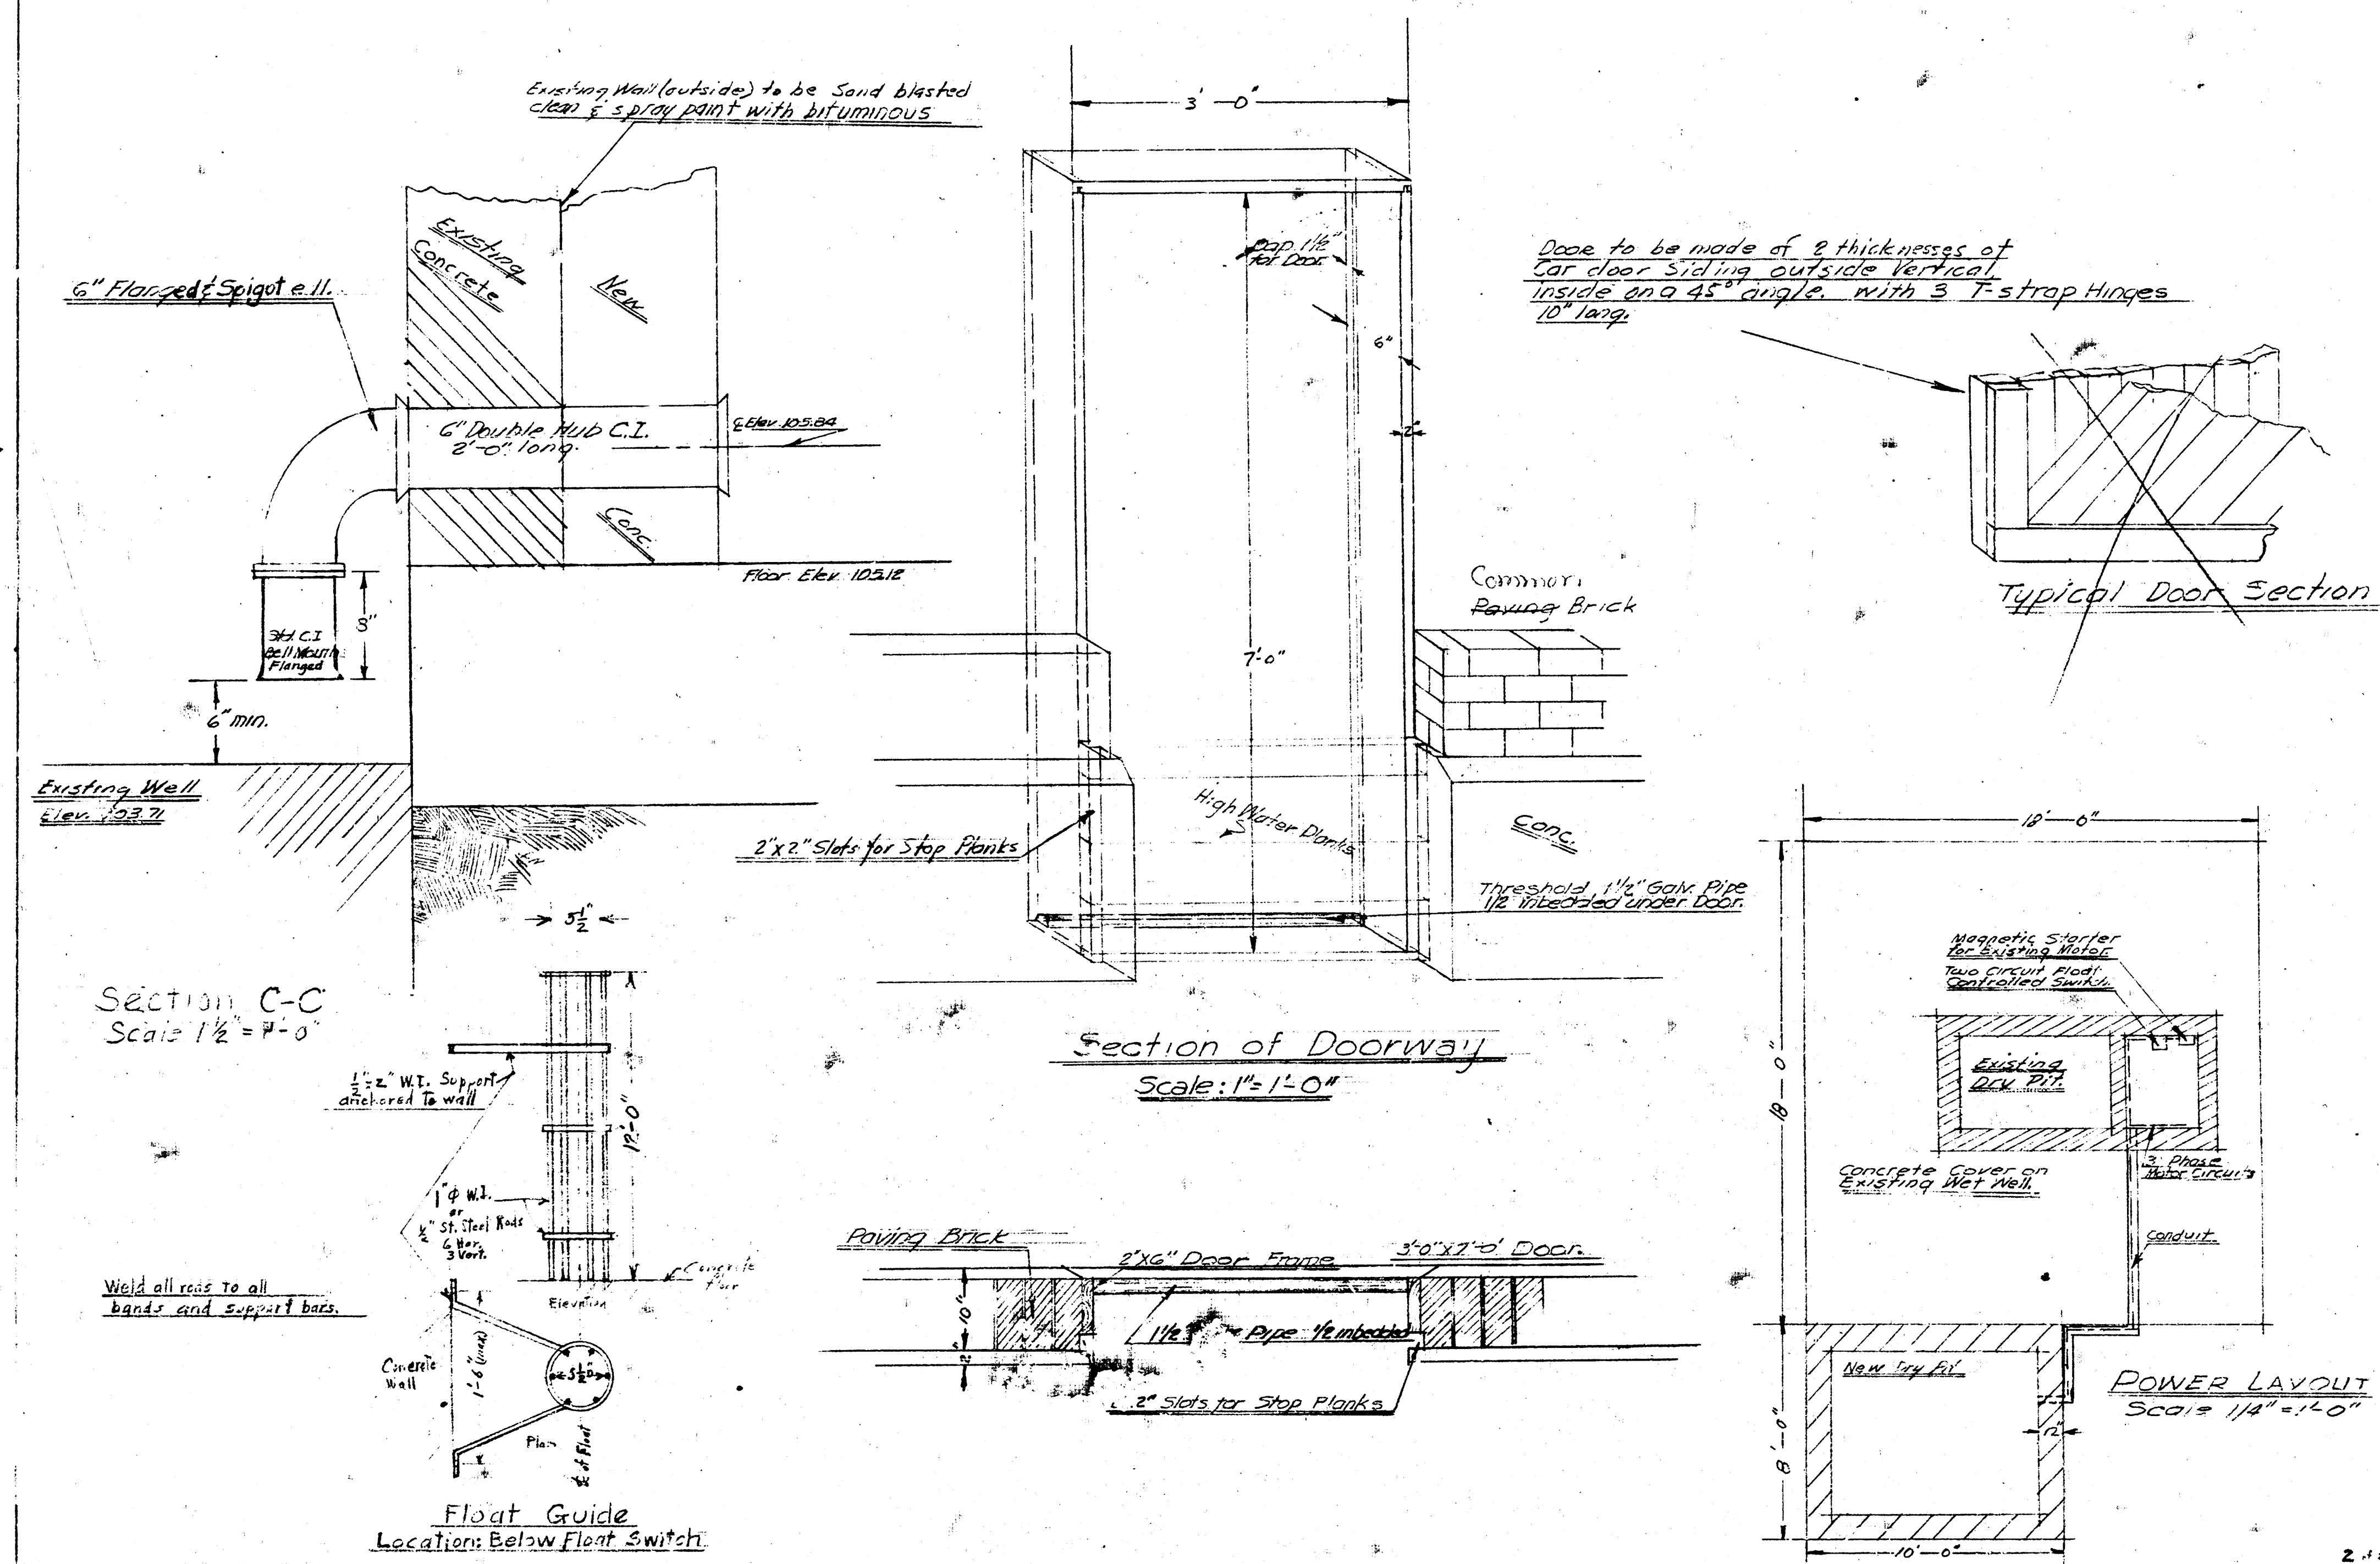

12-20

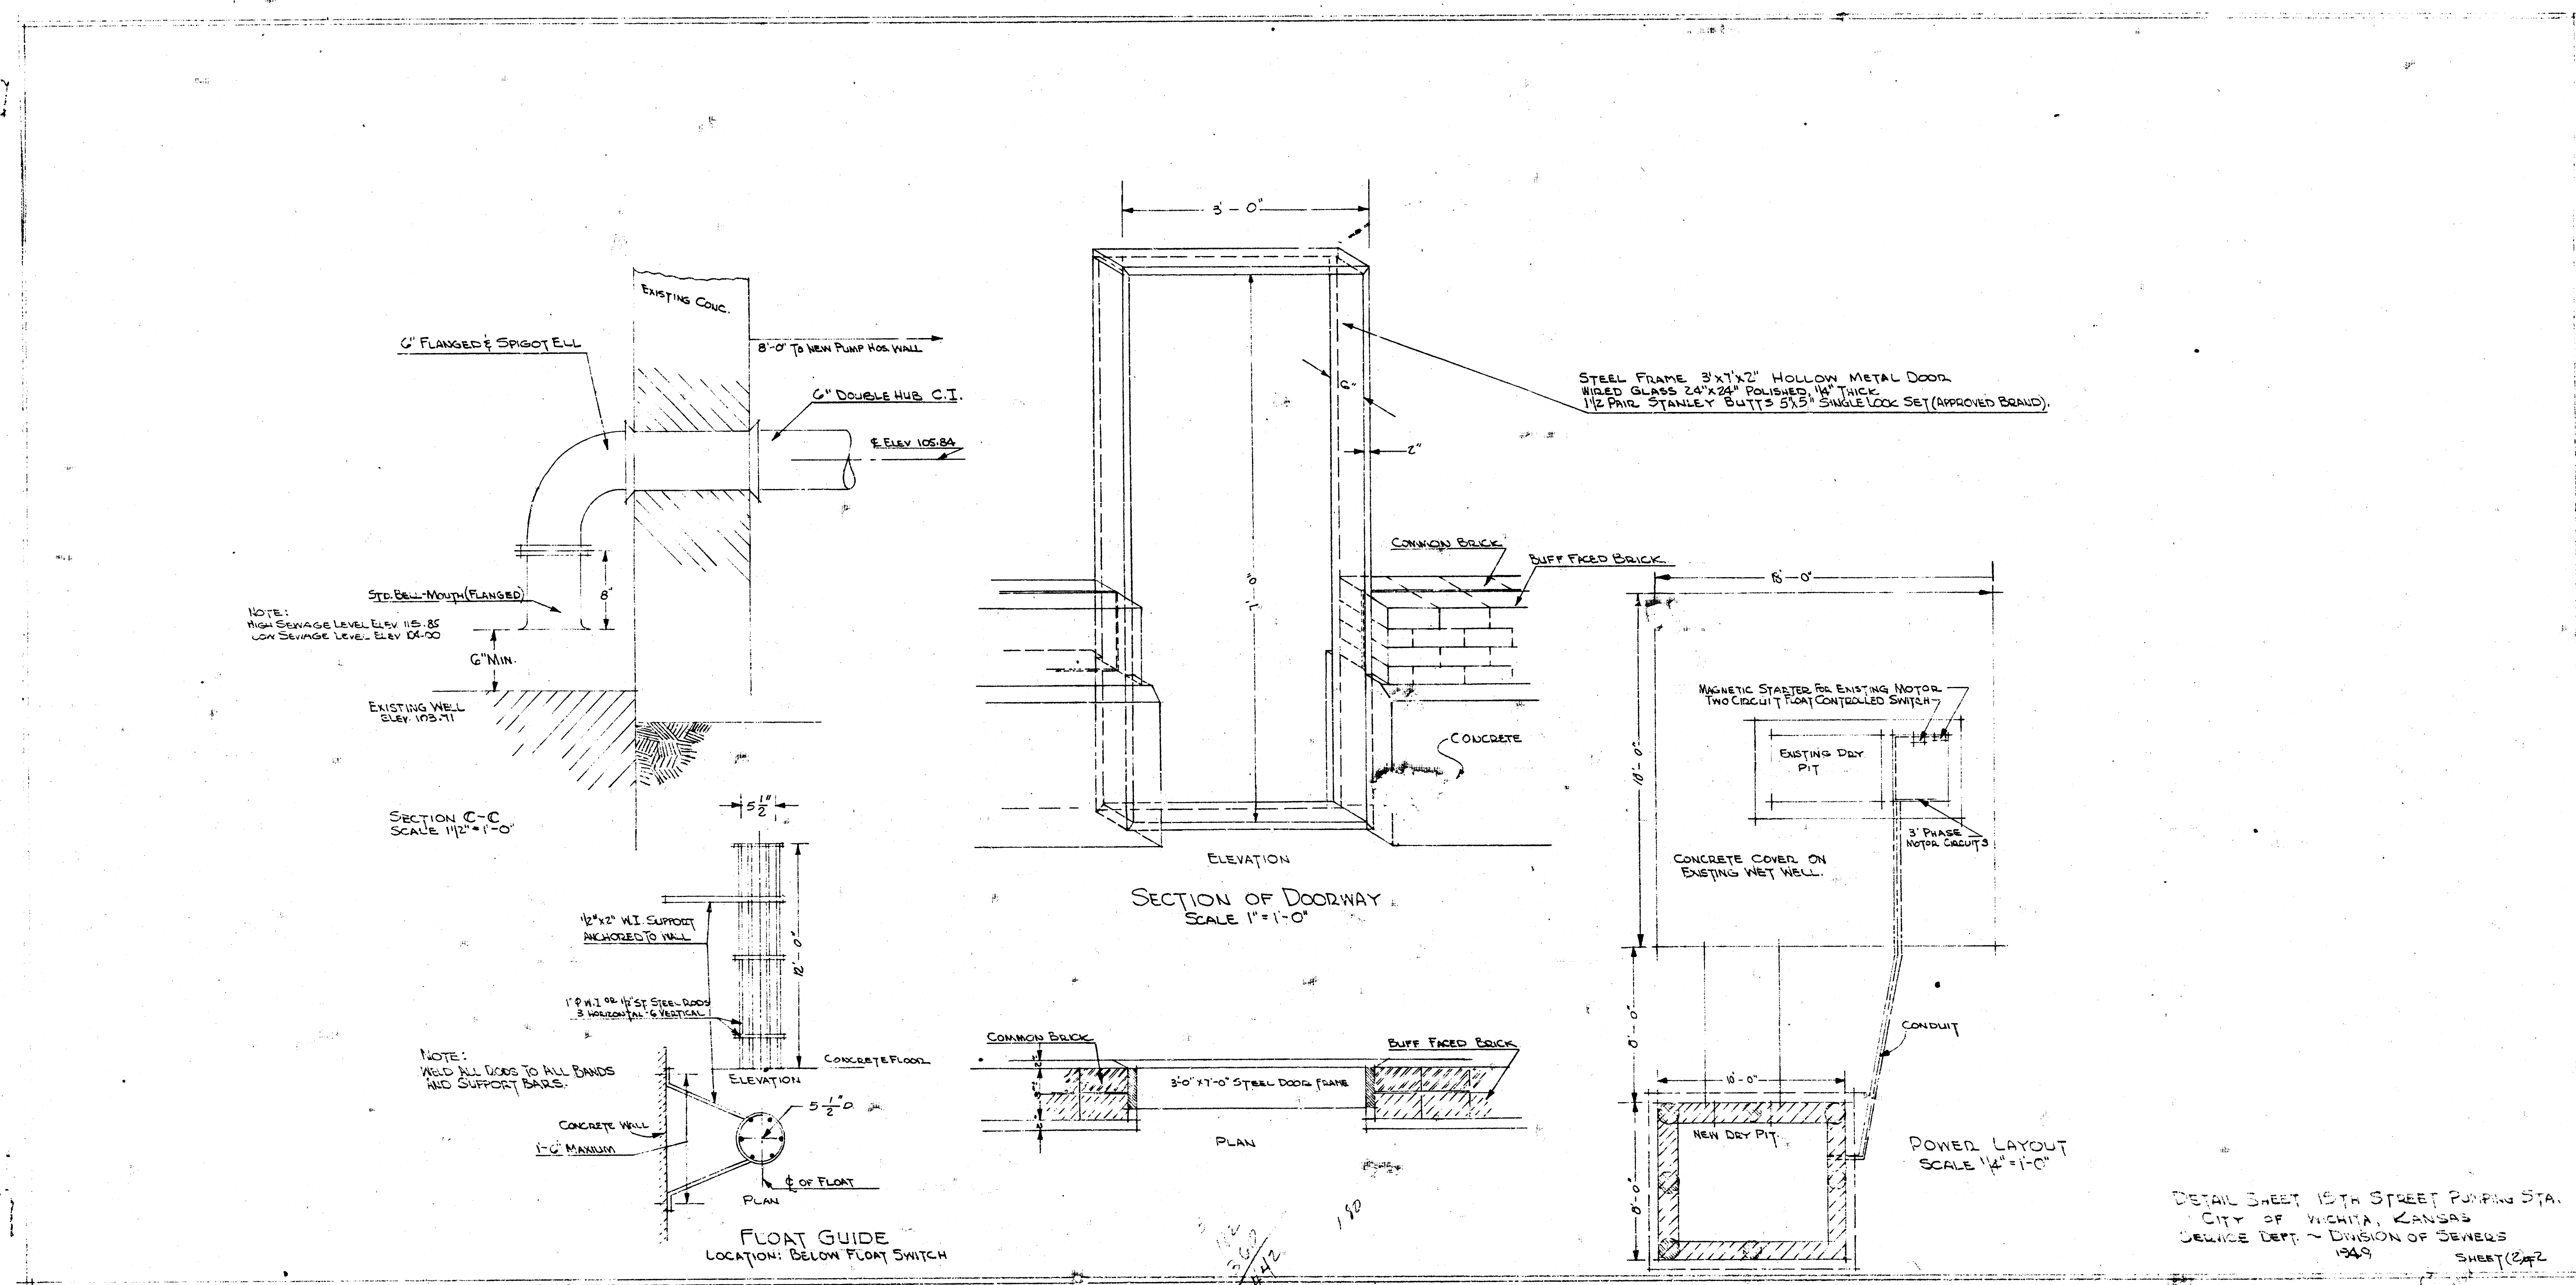

DETAIL SHEET 15TH STREET PUMPING STA.
CITY OF WICHITA, KANSAS
SERVICE DEPT. - DIVISION OF SEWERS
1949
SHEET 2 OF 2

