
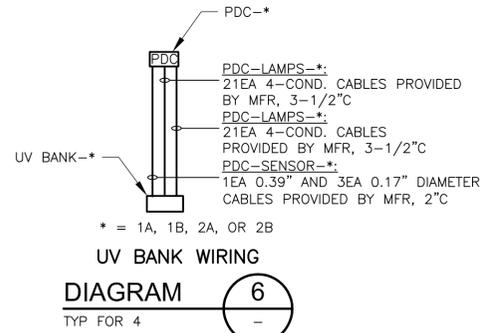


XREF: CDM_S_2234, CSTPL100, EUVDFPL100, DFPL100, DFPL110, DFPL110ELEC Images: []
 Last saved by: HANDLEMNG Time: 4/16/2015 1:22:36 PM
 pw:\dcpwpp\1\FW_XM1\2395\104609\04 Design Services NM_5%09 Electrical\10 CAD\10 E-5.dwg
 ©2015 CDM SMITH ALL RIGHTS RESERVED.
 REUSE OF DOCUMENTS: THESE DOCUMENTS AND DESIGNS PROVIDED BY PROFESSIONAL SERVICE, INCORPORATED HEREIN, ARE THE PROPERTY OF CDM SMITH AND ARE NOT TO BE USED, IN WHOLE OR PART, FOR ANY OTHER PROJECT WITHOUT THE WRITTEN AUTHORIZATION OF CDM SMITH.








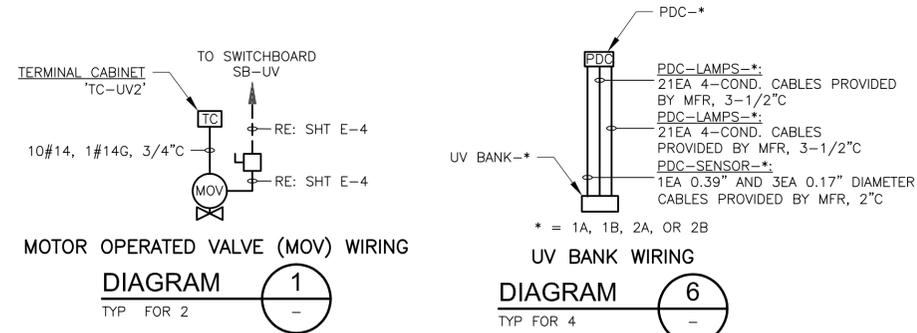


GENERAL NOTES:

- EACH BIDDER OR THEIR AUTHORIZED REPRESENTATIVES SHALL, BEFORE PREPARING THEIR PROPOSAL, VISIT ALL AREAS OF THE EXISTING BUILDINGS AND STRUCTURES IN WHICH WORK UNDER THIS CONTRACT IS TO BE PERFORMED AND INSPECT CAREFULLY THE PRESENT INSTALLATION.
- THIS DRAWING REPRESENTS THE LATEST DOCUMENTED INFORMATION AVAILABLE. HOWEVER, UNDOCUMENTED CHANGES MAY EXIST. THE CONTRACTOR SHALL PROVIDE THE NECESSARY CHANGES TO PROVIDE A COMPLETE AND OPERABLE SYSTEM ACCORDING TO THE INTENT OF THIS AND ALL DRAWINGS.
- NEW SWITCHBOARD COMPONENTS SHALL MEET OR EXCEED SHORT CIRCUIT RATING OF EXISTING SWITCHBOARD AND SHALL BE OF THE SAME MANUFACTURER.

NOTES BY SYMBOL:

- CONCRETE STEEL REINFORCED DUCTBANKS SHALL BE EXTENDED UNDERNEATH STRUCTURES PER DETAIL 'D' SHOWN ON SHEET EZ-1.
- CONDUIT SYSTEM ROUTING TO EQUIPMENT NOT SHOWN FOR CLARITY. CONTRACTOR SHALL INSTALL PVC COATED RIGID CONDUIT EXPOSED UNDERNEATH EXISTING GRATING. PROVIDE ALL LABOR, MATERIAL, AND INCIDENTALS REQUIRED TO ROUTE CONDUIT SYSTEM FOR UNFORESEEN CONDITIONS THAT MAY BE ENCOUNTERED IN THE FIELD.
- USE THIS AREA FOR CONDUIT TRANSITION TO THE DUCTBANK FROM THE ELECTRICAL SYSTEMS FROM OTHER ROOMS.

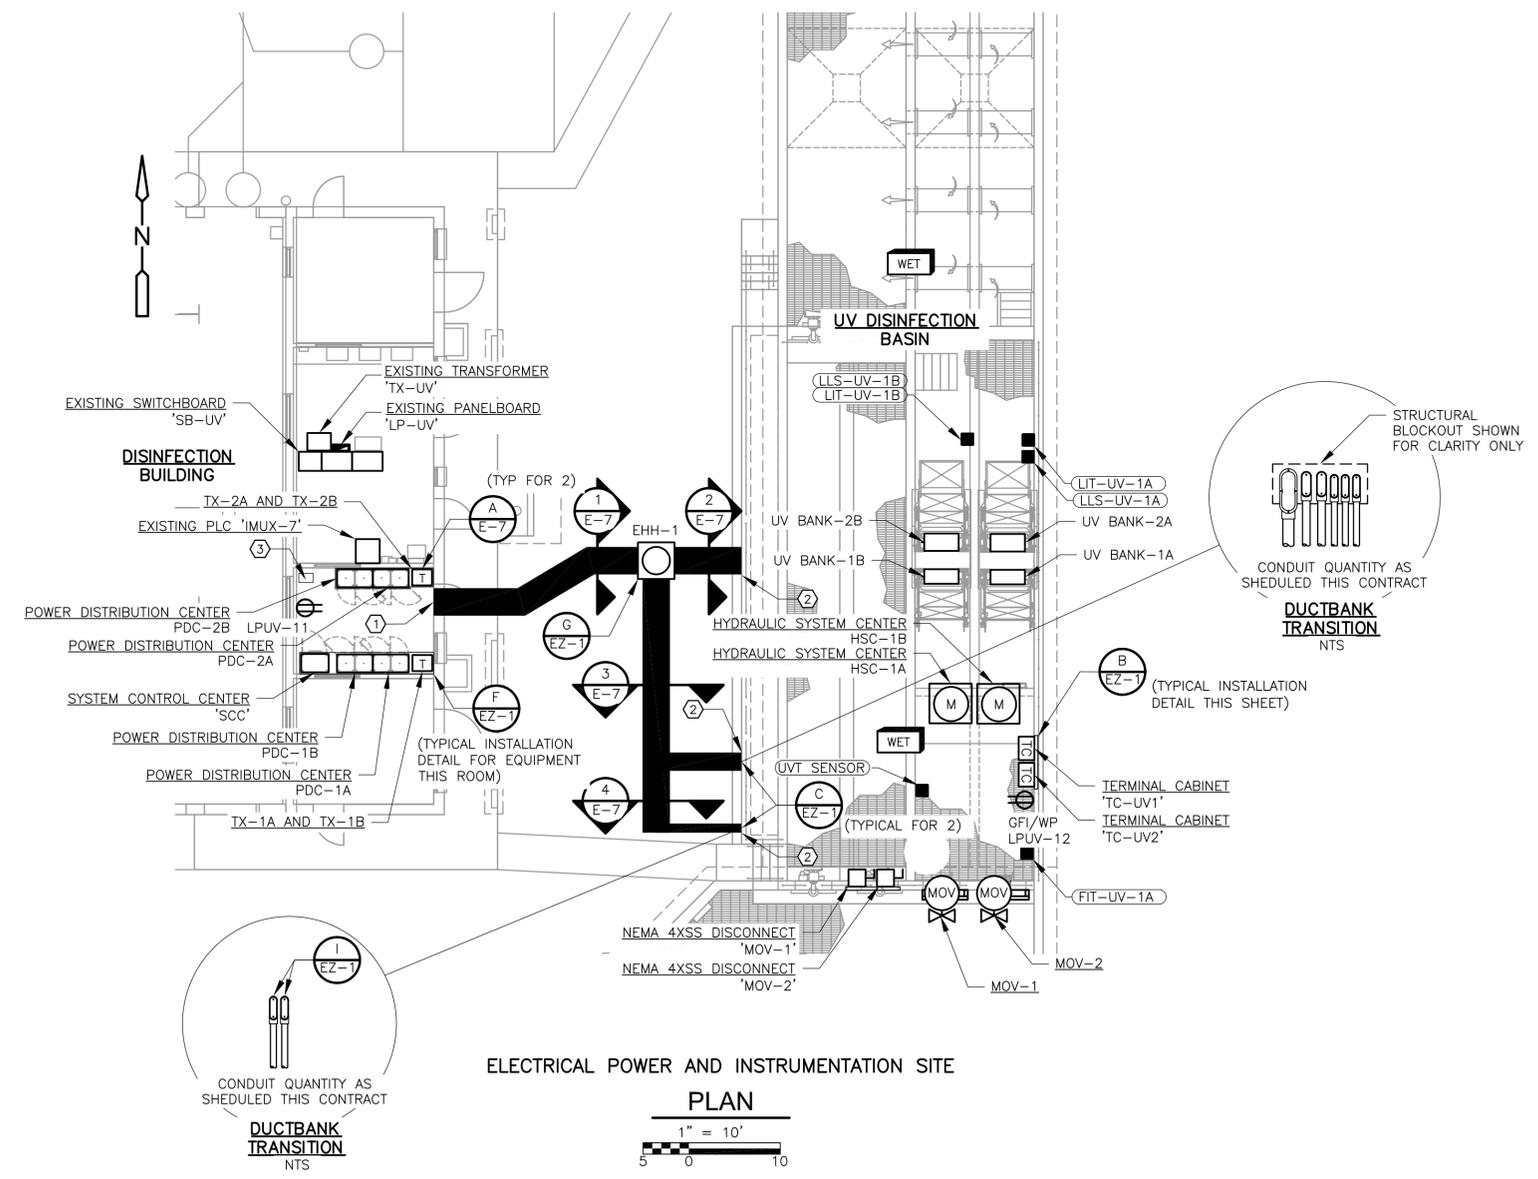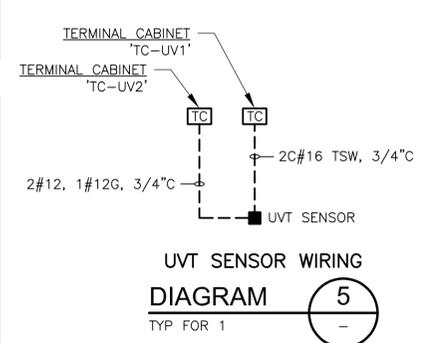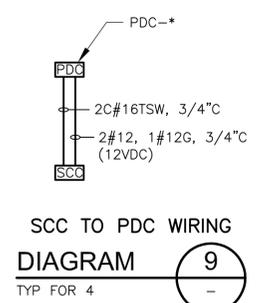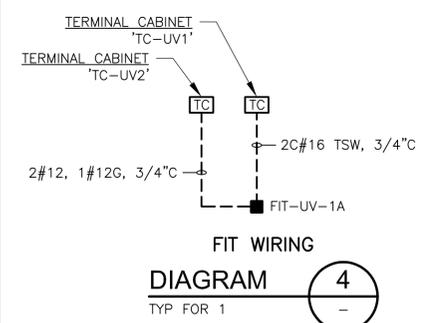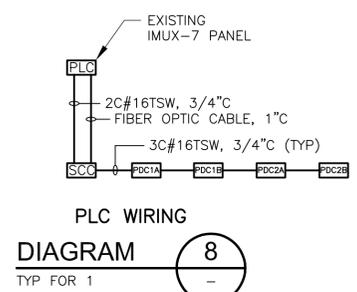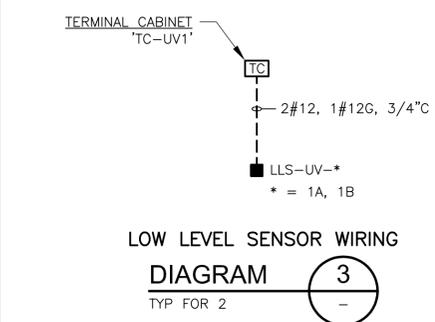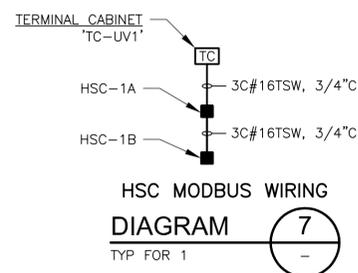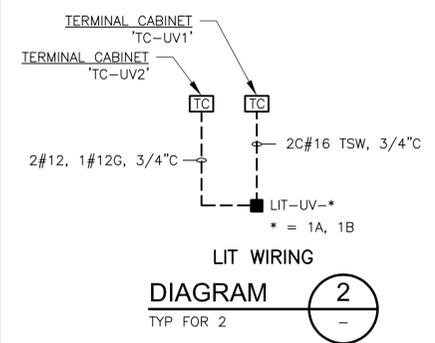


REV. NO.	DATE	DRWN	CHKD	REMARKS

DESIGNED BY: J. VARGHESE
 DRAWN BY: J. VARGHESE
 SHEET CHK'D BY: M. HANDLEY
 CROSS CHK'D BY: M. HANDLEY
 APPROVED BY: I. PJETROVIC
 DATE: APRIL 2015

CDM Smith
 9200 Ward Parkway, Suite 500
 Kansas City, MO 64114
 Tel: (816) 444-9270
 MO COA No. 001431

CITY OF WICHITA, KANSAS
 WATER AND SEWER DEPARTMENT
**SEWAGE TREATMENT PLANT NO.2 IMPROVMENTS
 UV DISINFECTION**

**ELECTRICAL POWER AND INSTRUMENTATION
 SITE PLAN**

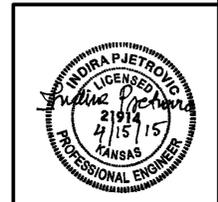

PROJECT NO. 2395-104609
 FILE NAME: E-5.DWG
 SHEET NO.
E-5